ISSUE DATE

REVISIONS

FEB. 20, 2002

SHEET NUMBER

PIPING NOTES (PERTAINS TO ALL PIPING) 1. ALL PIPING SHOWN SHALL BE CONSIDERED DIAGRAMMATIC.


2. COORDINATE ALL PIPING WITH PLUMBING MECHANICAL AND ELECTRICAL. 3. ALL PIPING BELOW POOL FLOOR SHALL BE ENCASED IN CONCRETE. 4. COORDINATE ALL POOL PIPE ROUTING AND ELEVATIONS WITH ALL TRADES. ALL ENCASED PIPES SHOWN ARE NOMINAL PIPE DIAMETERS, SCHEDULE 40 PVC, ALL EXPOSED PIPES ARE NOMINAL PIPE DIAMETERS, SCHEDULE 80 PVC UNLESS OTHERWISE INDICATED.

ALL SWIMMING POOL PIPING MUST MEET ASTM D-1785 AND BE NSF APPROVED. SEE SPECIFICATIONS FOR MORE DETAIL.

7. ALL DIMENSIONS ARE SHOWN TO INSIDE FINISHED WALLS AND DO NOT TAKE INTO ACCOUNT FLOOR SLOPES.


8. INSTALL FLOW SENSORS AND/OR IMPACT FLOW METERS 10 PIPE DIAMETERS DOWNSTREAM AND 5 PIPE DIAMETERS UPSTREAM OF ANY FITTING.

THE CHEMICAL SENSOR LINE SHALL BE A 1/2" PVC LINE EXTENDING FROM THE WET CELL SENSOR TO THE POOL'S RESPECTIVE FILL FUNNEL.

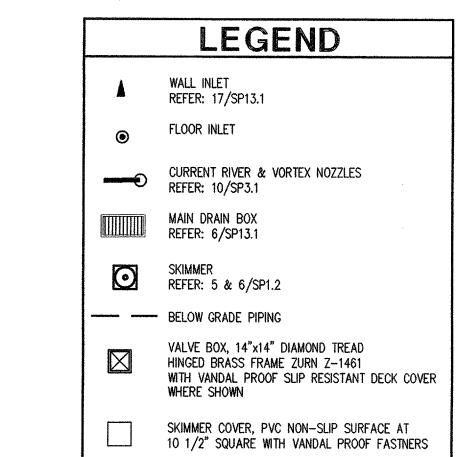

`		PUMP SCHEDULE					
			SPECIFICATIONS				
	ID	DESCRIPTION	GPM	TDH	HP		
	PP1	LEISURE POOL RECIRCULATION PUMP	790	60	20		
	PP2	VORTEX PUMP	500	40	10		
	PP3	WATER FALL PUMP	750	40	15		
	PP4	LEISURE POOL HYDROTHERAPY PUMP	190	40	3		
	PP5	CHILDREN'S WATER FEATURE PUMP	1000	40	15		
	PP6	CHILDREN'S POOL RECIRCULATION PUMP	250	60	7.5		
	PP7	AIR BLOWER	70 SCFM	9 75" H2O	3		
	PP8	STENNER PUMP					
	PP9	STENNER PUMP					
	PP10	SEASONAL BYPASS	200	60	5		

PIPING SCHEDULE				
ID	SIZE	DESCRIPTION		
P1	6"	TO UPPER POOL INLETS - 1		
P2	4"	TO, UPPER POOL INLETS — 2		
Р3	4"	TO LOWER POOL INLETS - 1		
P4	3"	TO LOWER POOL INLETS - 2		
P5	6"	TO VORTEX NOZZLE		
P6	6"	WATER FALL PRIMARY		
P7	3"	LOWER POOL FEATURE		
P8	6"	TO WATERFALL BRANCH		
P9	3"	TO HYDROTHERAPY INLETS		
P10	6"	TO WATER FEATURES VALVE BOX		
P11	3"	TO SPRAYBAR		
P12	4"	TO AQUADUCT		
P13.	2"	TO WATER WHOPPY		
P14	2"	TO WALLSPRAY		
P15	4"	to Childrens' pool inlets		
P16	8"	FROM LEISURE POOL SKIMMERS		
P17	8"	FROM LEISURE POOL MAIN DRAINS		
P18	6"	FROM CHILDRENS' POOL SKIMMERS - 1		
P19	4"	FROM CHILDRENS' POOL SKIMMERS - 2		
P20	8"	FROM VORTEX MAIN DRAIN		
P21	8"	FROM WATER FALL MAIN DRAINS		
P22	4"	FROM HYDROTHERAPY MAIN DRAIN		
P23	8"	FROM WATER FEATURES MAIN DRAINS		
P24	6"	FROM CHLDRENS' POOL MAIN DRAINS		
P25	2"	EQUALIZER TAP		
P26	3"	FROM BLOWER TO BUBBLE COUCH		
F1	3"	LEISURE POOL FILL LINE		
F2	3"	CHILDRENS POOL FILL LINE		
S1	2"	LEISURE POOL STATIC LINE		
S2	2"	CHILDRENS POOL STATIC LINE		

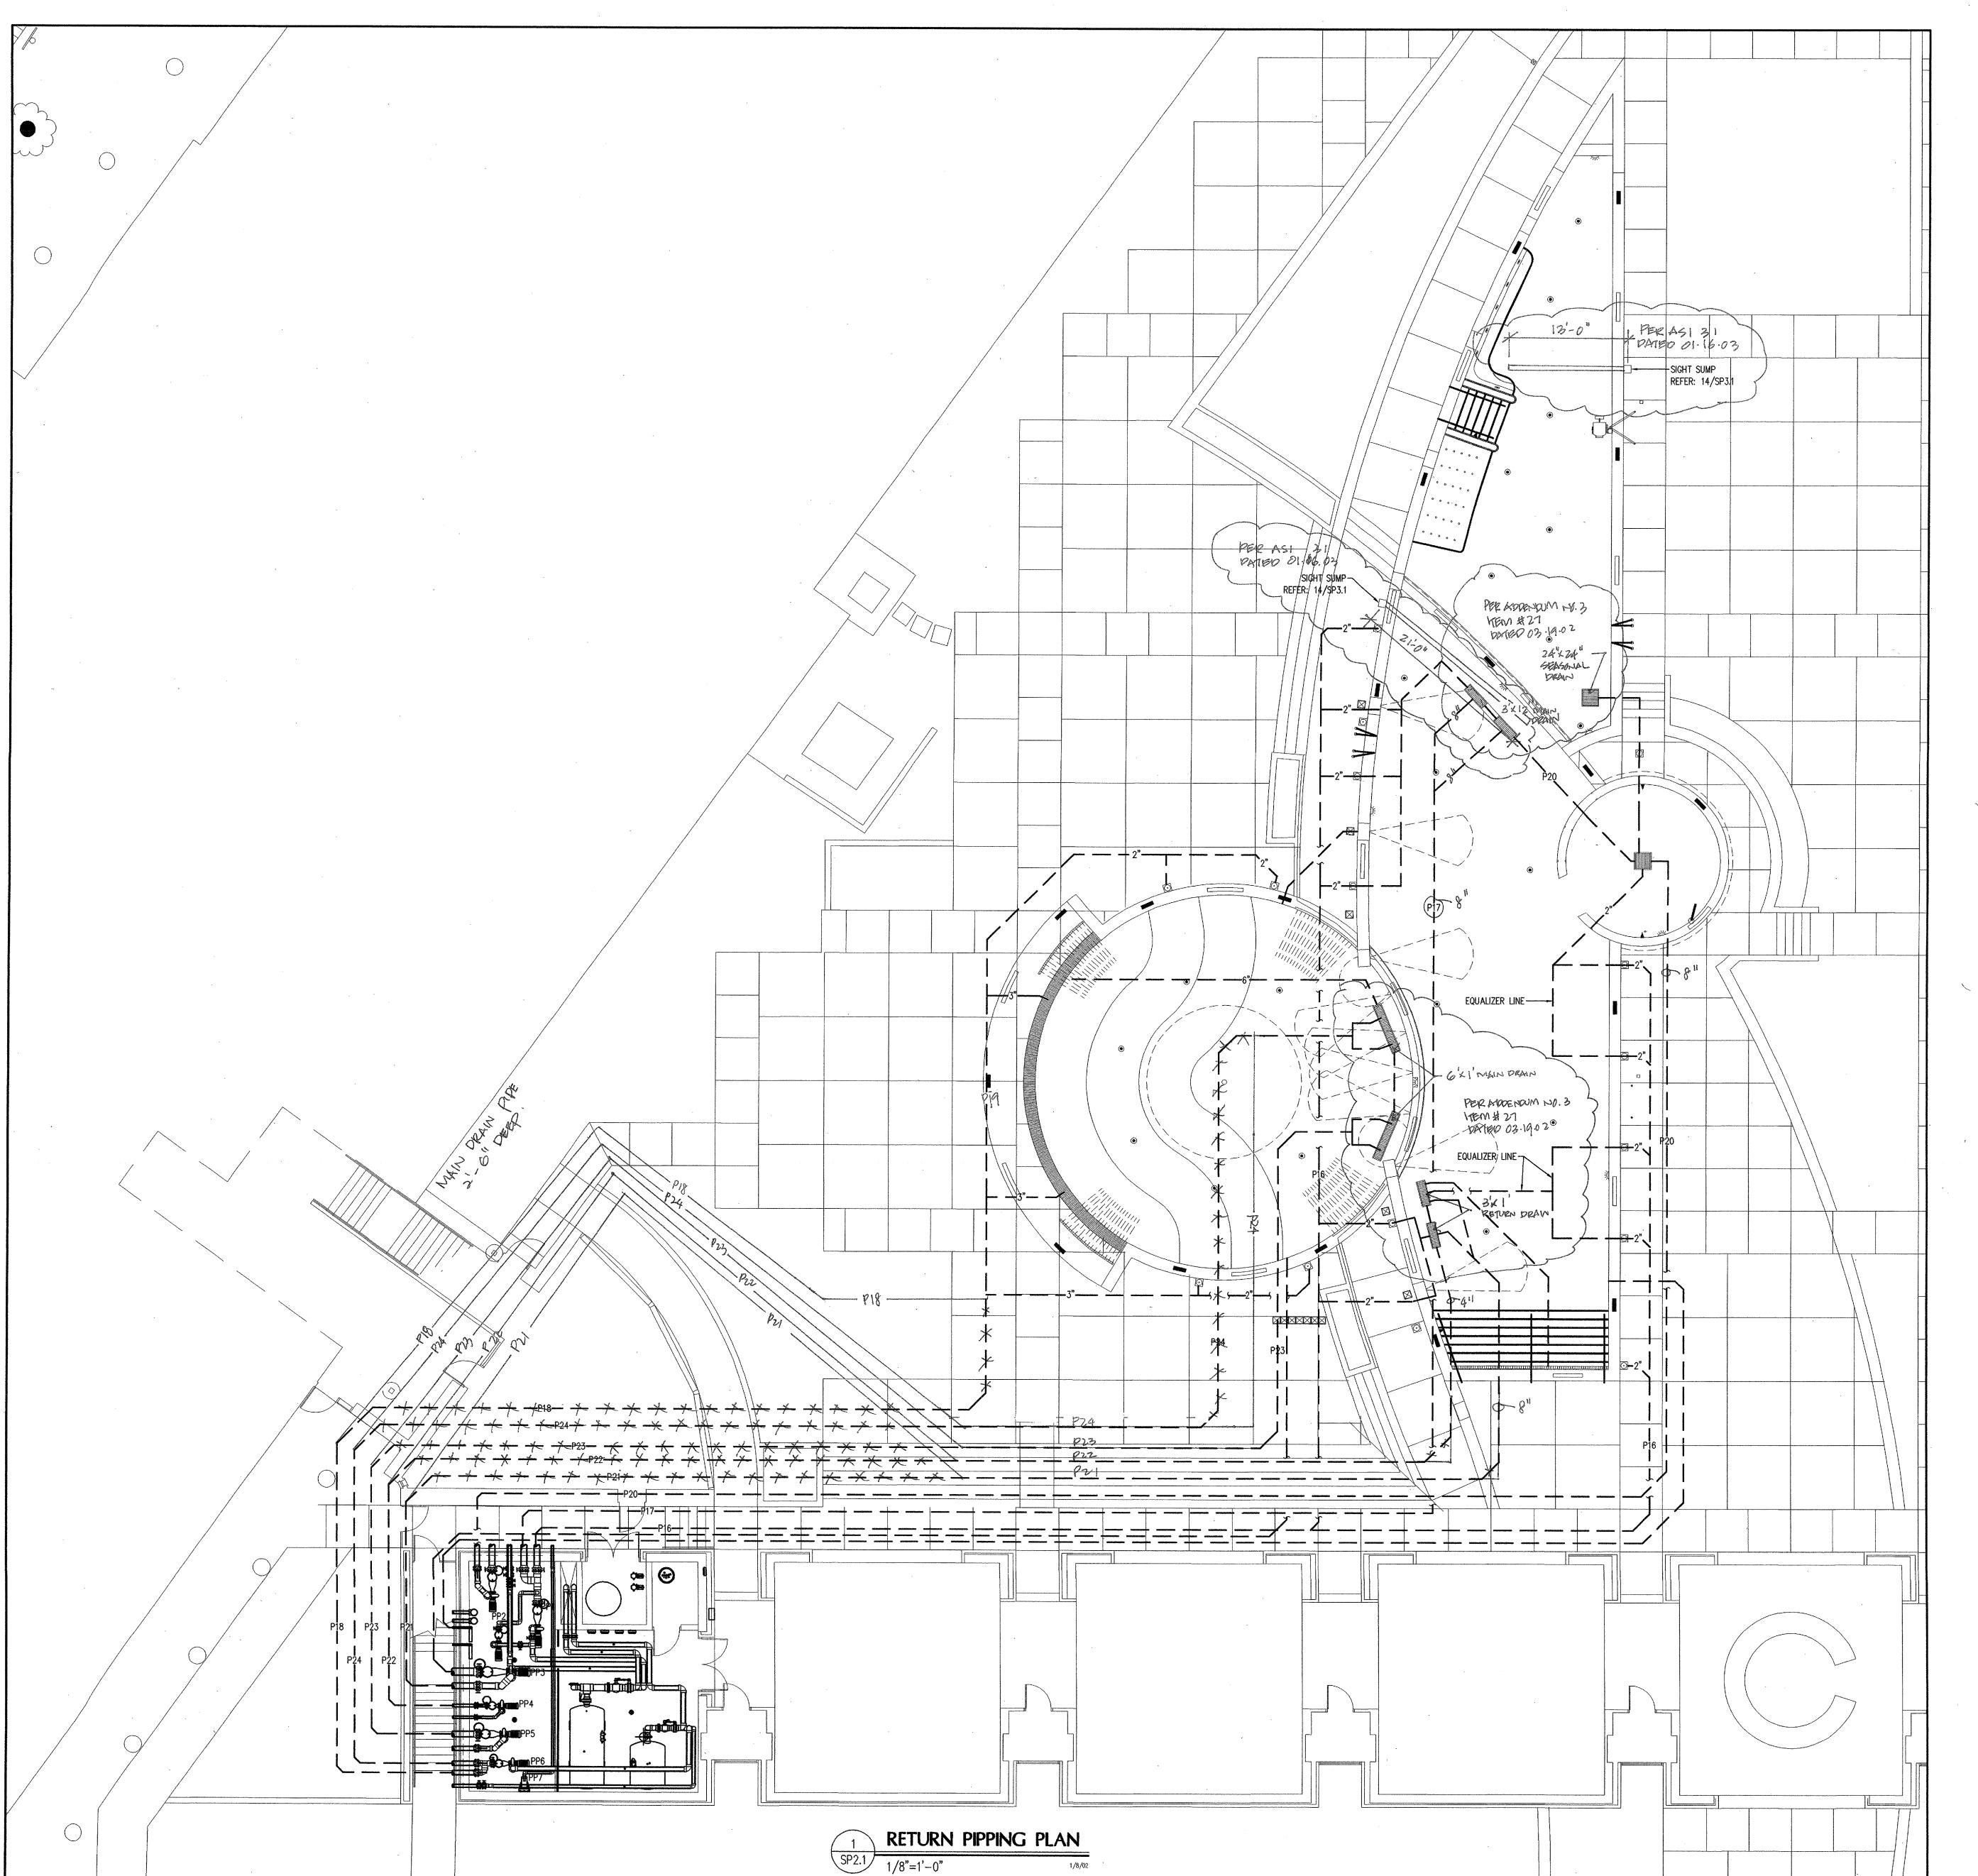

SP2.1 100% CD's