

No. Date REVISIONS

PLAN

8642-12 06.28.12

		P2.1
PLAN NORTH	Last Revision	
	Date	06.28.1
	Project No.	8642-1


GENERAL PLUMBING NOTES:

- CONTRACTOR SHALL ROUTE PRIMARY CONDENSATE LINES FROM AIR HANDLERS TO NEAREST CODE APROVED DRAIN.
- CONTRACTOR SHALL ROUTE SECONDARY DRAIN LINES FROM PANS OUT TO THE NEAREST SOFFIT AND PENETRATE SOFFIT WITH 90-DEGREE ELBOW 6" AWAY FROM WALL.
- CONTRACTOR SHALL SUPPLY AND INSTALL 1/2" TRAP PRIMERS FOR ALL FLOOR AND HUB DRAINS AS REQUIRED BY CODE.
- ALL HANDICAP FIXTURES SHALL BE SUPPLIED WITH LEVER TYPE HANDLES.
- ALL WATER PIPING EXPOSED TO FREEZING CONDITIONS (ATTIC, EXTERIOR WALLS, ETC).


WATER KEYNOTES:

1) 3/4" CW AND HW UP IN WALL, EXTEND 1/2" LINE TO EACH LAV. 2 1-1/4" CW UP IN WALL, EXTEND 1" TO WC, 3/4" TO WH AND 1/2" CW EACH TO LAV, MS AND TRAP PRIMER VALVE AND 3/4" HW DN IN WALL FROM WH, EXTEND 1/2" HW EACH TO LAV AND


3 2" CW UP IN WALL, EXTEND 1" LINE TO EACH WC, 1" LINE TO EACH UR, AND 1/2" LINE TO EACH TRAP PRIMER VALVE.

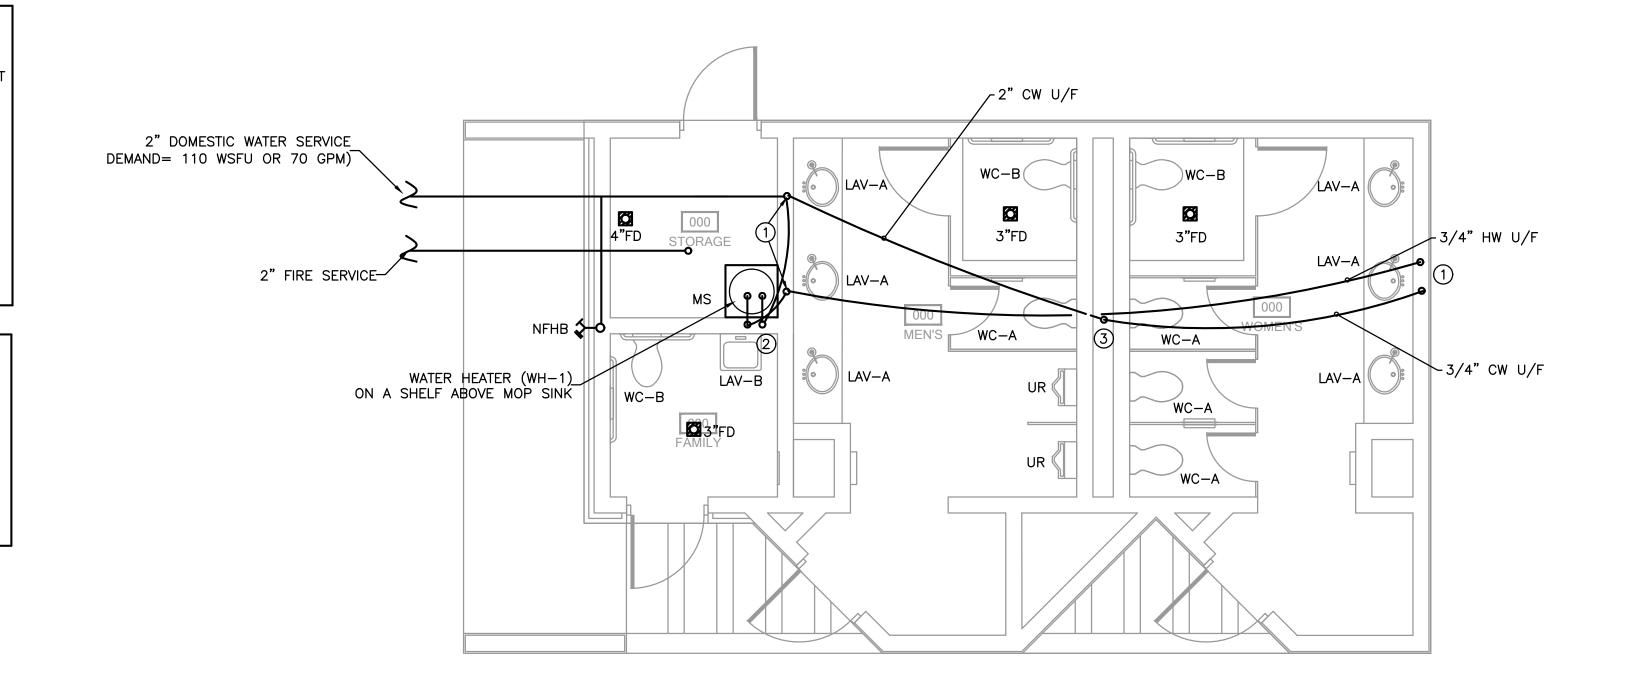

FLOOR PLAN - WATER 2) SCALE: 1/4"= 1'-@"

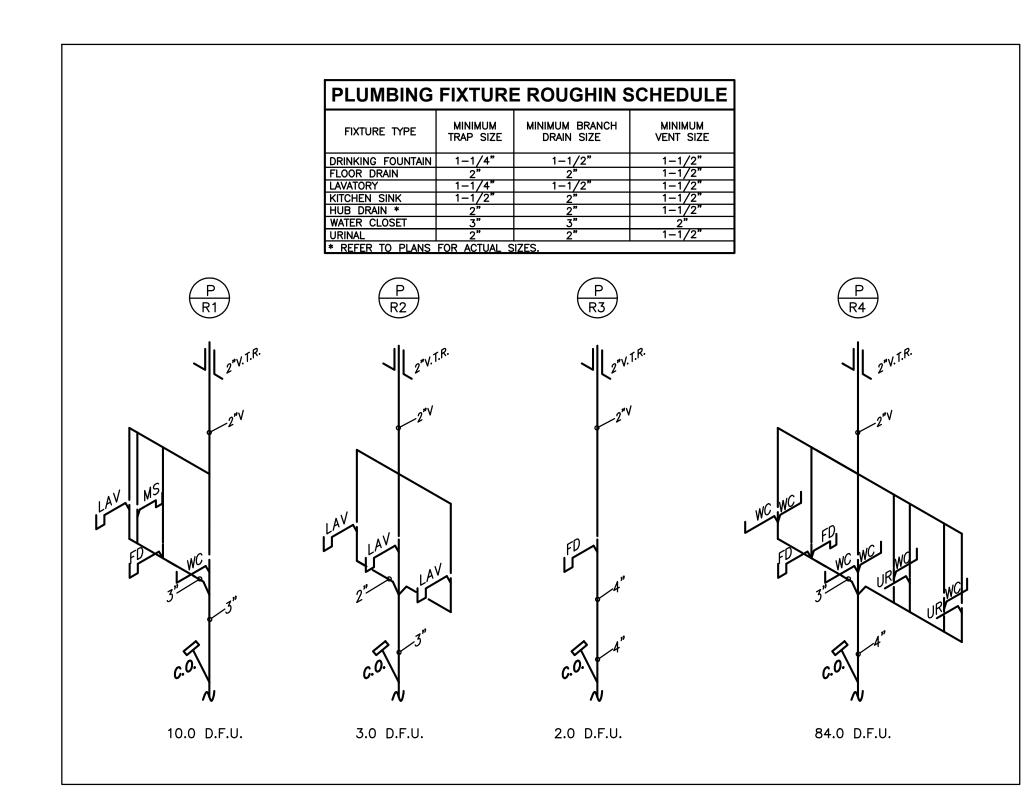



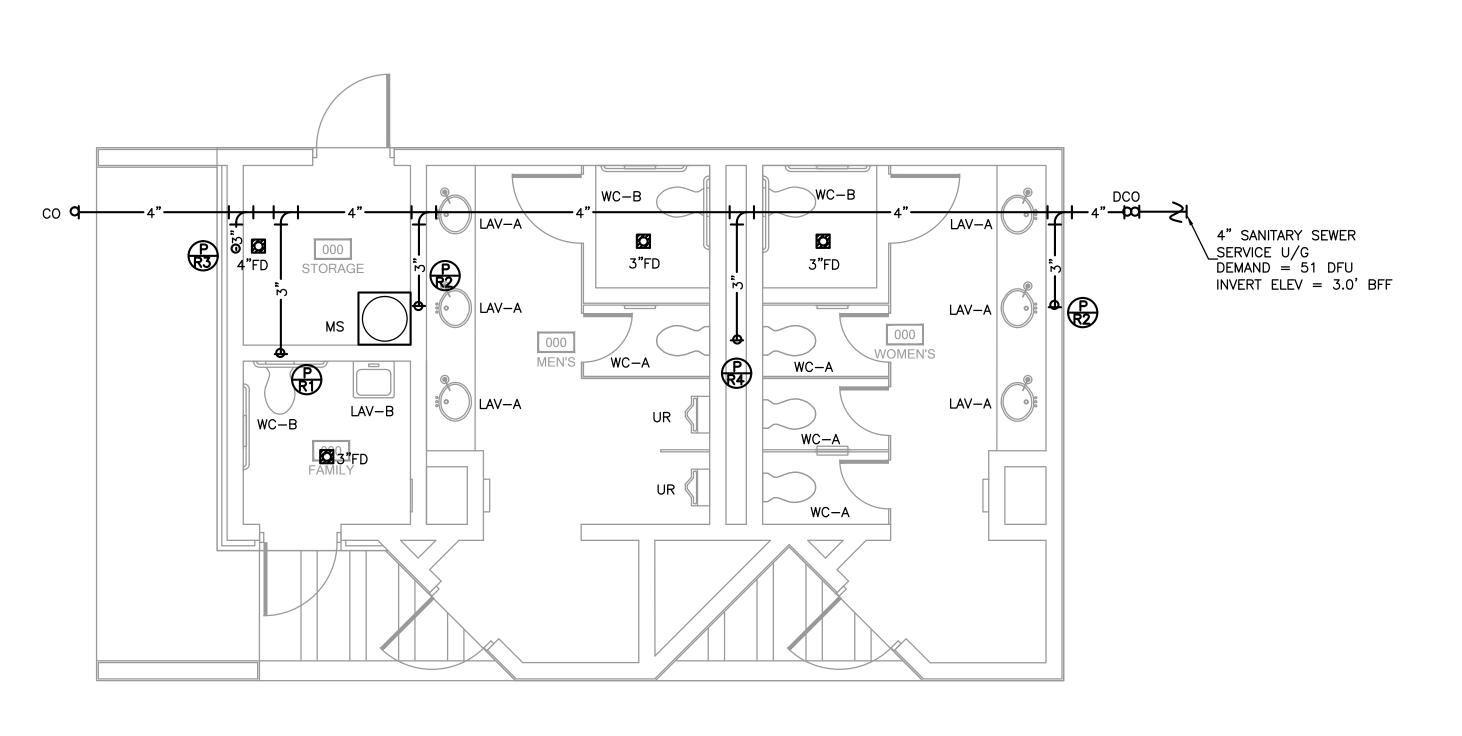

FLOOR PLAN - SEWER

SCALE: 1/4"= 1'-0"

TRUE NORTH