

CITY COPY

INDEX OF DRAWINGS

ADDISON AIRPORT TUNNEL
BARRIER TOLL PLAZA

DECEMBER, 1997

RECOMMENDED BY:
GINN CORPORATION

H. Wayne J. RE.

DATE: 12/10/97

DEPARTMENTAL REVIEW	HOLD	APPROVED	REVIEWED BY
FIRE		5-5-98	RC
ENGINEERING			
UTILITIES			
STREETS			
LANDSCAPE			

OK PER JEFF
ATC 5-6-98

INSPECTION REVIEW	HOLD	APPROVED	REVIEWED BY
BUILDING		5-5-98	RC
PLUMBING		5-5-98	L.F.
ELECTRICAL		5-5-98	RC
MECHANICAL		5-5-98	RC
ZONING			
HEALTH			

RECOMMENDED BY:
NORTH TEXAS TOLLWAY AUTHORITYJames W. Griffith
CHIEF ENGINEER

DATE: December 19, 1997

1. UPON COMPLETION OF BLD. THE ARCHITECT
MUST SUBMIT A LETTER STATING THAT
BLO AND SITE MEET HANDICAP
REQ OF CH 31 1991 UBC.

2. SPECIAL INSPECTOR REQ FOR ALL
STRUCTURAL ELEMENTS. - AND UPON
COMPLETION AN ENGINEER MUST SUBMIT
A LETTER STATING BLD WAS
CONSTRUCTED PER PLAN.

APPROVED BY:
NORTH TEXAS TOLLWAY AUTHORITYJames W. Griffith
EXECUTIVE DIRECTOR

DATE: 12/19/97

NO.	TITLE
1	AT-G0.1 COVER SHEET
2	AT-G0.2 ABBREVIATIONS, SYMBOLS, GENERAL NOTES, & CODE SUMMARY
3	AT-G0.3 LOCATION MAPS

CIVIL

4	AT-C1.1 SITE PLAN
5	AT-C2.1 DIMENSIONAL CONTROL PLAN - A
6	AT-C2.2 DIMENSIONAL CONTROL PLAN - B
7	AT-C3.1 PAVING AND GRADING PLAN - A
8	AT-C3.2 PAVING AND GRADING PLAN - B
9	AT-C4.1 UTILITY PLAN AND PROFILE A
10	AT-C4.2 UTILITY PLAN AND PROFILE B
11	AT-C5.1 PLAZA PLAN
12	AT-C6.1 PAVEMENT JOINTING PLAN - A
13	AT-C6.2 PAVEMENT JOINTING PLAN - B
14	AT-C7.1 TYPICAL ISLAND PLANS, SECTIONS AND DETAILS I
15	AT-C7.2 TYPICAL ISLAND PLANS, SECTIONS AND DETAILS II
16	AT-C8.1 PAVEMENT SECTIONS AND DETAILS
17	AT-C8.2 DETAILS AND SECTIONS
18	AT-C9.1 BARRIER WALL DETAIL AND SECTIONS
19	AT-C9.2 CONCRETE CRASH BUNKER DETAIL AND SECTIONS

ARCHITECTURAL

20	AT-A1.1 TUNNEL PLAZA SITE PLAN
21	AT-A2.1 CANOPY PLAN, BOOTH PLAN, SCHEDULES AND DETAILS
22	AT-A3.1 TUNNEL PLAZA CANOPY ROOF PLAN
23	AT-A4.1 TUNNEL PLAZA CANOPY ELEVATIONS
24	AT-A4.2 TUNNEL PLAZA CANOPY SECTIONS
25	AT-A4.3 TUNNEL PLAZA CANOPY WALL SECTIONS
26	AT-A4.4 TUNNEL PLAZA BOOTH WALL SECTIONS
27	AT-A5.1 TUNNEL PLAZA BOOTH ELEVATIONS, SECTIONS AND DETAILS
28	AT-A6.1 TUNNEL PLAZA REFLECTED CEILING PLANS
29	AT-A7.1 TUNNEL PLAZA SIGNAGE DETAILS
30	AT-A8.1 TUNNEL PLAZA BOOTH INTERIOR ELEVATIONS AND DETAILS
31	AT-A8.2 INTERIOR DETAILS
32	AT-A8.3 INTERIOR DETAILS
33	AT-A10.1 "V.I.V.I.D." EQUIPMENT COORDINATION DRAWINGS

STRUCTURAL

34	AT-S0.1 STRUCTURAL GENERAL NOTES
35	AT-S0.2 STRUCTURAL GENERAL NOTES- CONT'D
36	AT-S1.1 STRUCTURAL FOUNDATION PLANS AND DETAILS
37	AT-S2.1 STRUCTURAL FRAMING PLANS
38	AT-S3.1 STRUCTURAL SECTIONS AND DETAILS
39	AT-S4.1 STRUCTURAL SECTIONS AND DETAILS

MECHANICAL

40	AT-M1.1 MECHANICAL SYMBOLS AND ABBREVIATIONS
41	AT-M2.1 MECHANICAL H.V.A.C. PLAN
42	AT-M6.1 MECHANICAL H.V.A.C. SCHEDULES AND DETAILS
43	AT-P1.1 PLUMBING PLANS & SCHEDULES

ELECTRICAL

44	AT-E0.1 ELECTRICAL GENERAL NOTES, SYMBOLS, ABBREVIATIONS
45	AT-E1.1 ELECTRICAL SITE/UTILITY & GROUNDING PLAN
46	AT-E1.2 ELECTRICAL CONDUIT LAYOUT LIGHTING PLAN
47	AT-E2.1 ELECTRICAL LIGHTING PLANS
48	AT-E3.1 ELECTRICAL POWER/COMMUNICATION PLANS
49	AT-E4.1 ELECTRICAL / ILP COMMUNICATIONS PLANS
50	AT-E6.1 ELECTRICAL RISER DIAGRAMS AND DETAILS
51	AT-E6.2 ELECTRICAL DETAILS
52	AT-E6.3 ELECTRICAL DETAILS
53	AT-E7.1 ELECTRICAL SCHEDULES AND RISER DIAGRAMS

ADDISON AIRPORT TUNNEL

CLOSED CLOSED CLOSED

AT ANY LOCATION WITHIN THESE PLANS AND THE ACCOMPANYING SPECIFICATIONS, PROPOSALS, AND CONTRACT WHERE THE WORDS "TEXAS TURNPIKE AUTHORITY" APPEAR, THESE WORDS SHALL, BY DEFINITION, MEAN THE "NORTH TEXAS TOLLWAY AUTHORITY", A BODY POLITIC AND CORPORATE AND A POLITICAL SUBDIVISION OF THE STATE OF TEXAS.

PREPARED BY:
CHIANG, PATEL & YERBY

CIVIL ENGINEER

DATE: 12/11/97

PREPARED AND REVIEWED BY:
AGUIRREcorporation

PRINCIPAL IN CHARGE

DATE: 12/16/97

PREPARED AND REVIEWED BY:
AGUIRREcorporation

PROJECT MANAGER

DATE: 12/10/97

PREPARED BY:
AGUIRREcorporation

REGISTERED ARCHITECT

DATE: 12/10/97

PREPARED BY:
AGUIRREcorporation

STRUCTURAL ENGINEER

DATE: 12/16/97

PREPARED BY:
AGUIRREcorporation

MECHANICAL ENGINEER

DATE: 12.16.97

PREPARED BY:
AGUIRREcorporation


ELECTRICAL ENGINEER

DATE: 12.16.97





GENERAL NOTES



1. SCALES ARE APPROXIMATE. MAPS ARE SHOWN FOR GENERAL INFORMATION AND ARE NOT INTENDED TO PROVIDE EXACT DISTANCES.
2. ROADWAY ON ADJACENT SIDES OF PLAZA AND TUNNEL WORK ARE BY OTHER CONTRACTORS. WORK MAY OR MAY NOT BE COMPLETED WHEN TOLL PLAZA CONTRACTOR BEGINS ADDISON AIRPORT TUNNEL TOLL PLAZA
3. TOLL PLAZA CONTRACTOR SHALL COORDINATE WITH ROADWAY CONTRACTOR TO PROVIDE BETWEEN ROADWAY AND PLAZA A SMOOTH TRANSITION AT INTERFACE.

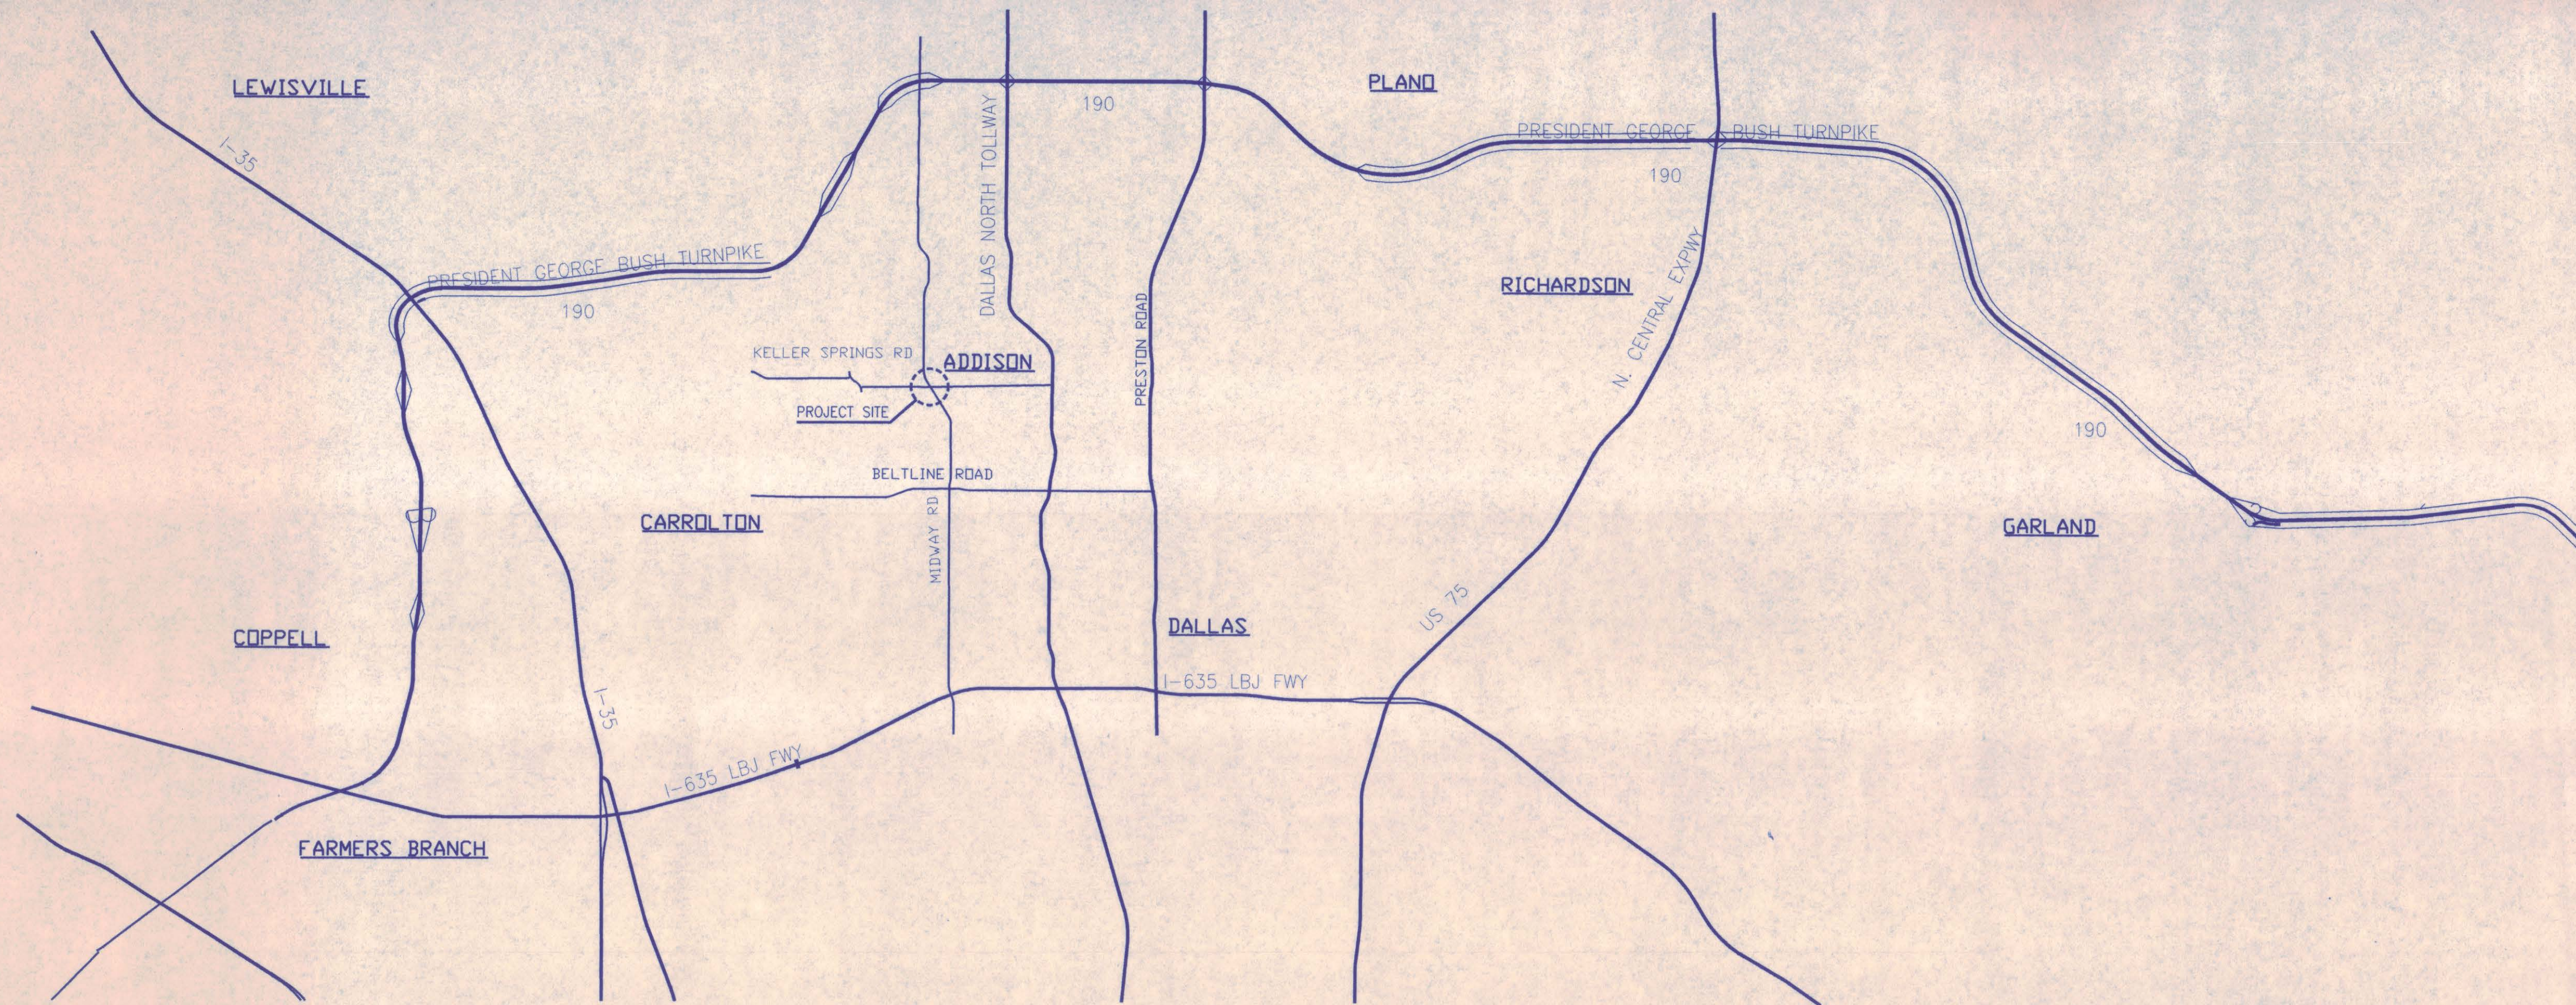

1 LOCATION MAP
SCALE AS SHOWN
190_MP.DWG

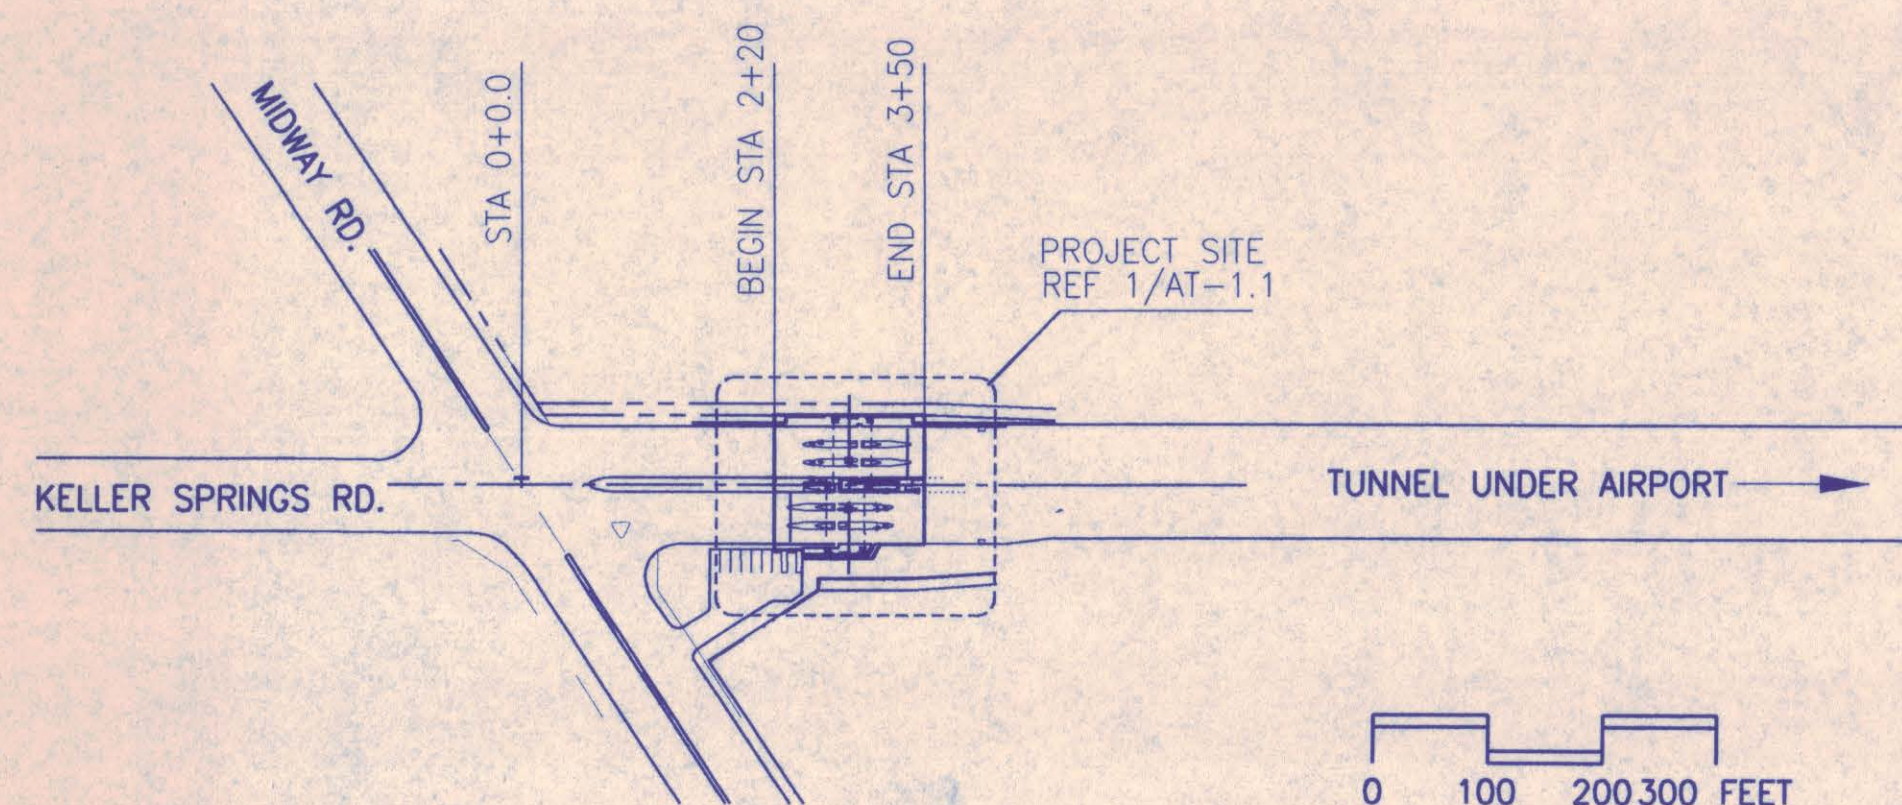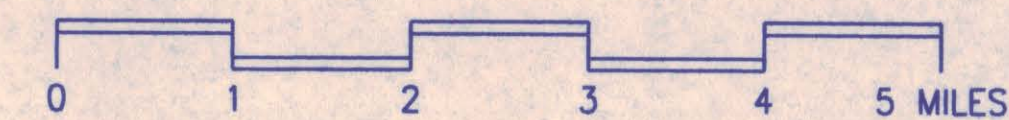

2 SEGMENT / PHASE
SCALE AS SHOWN
TAATAPS1.DWG

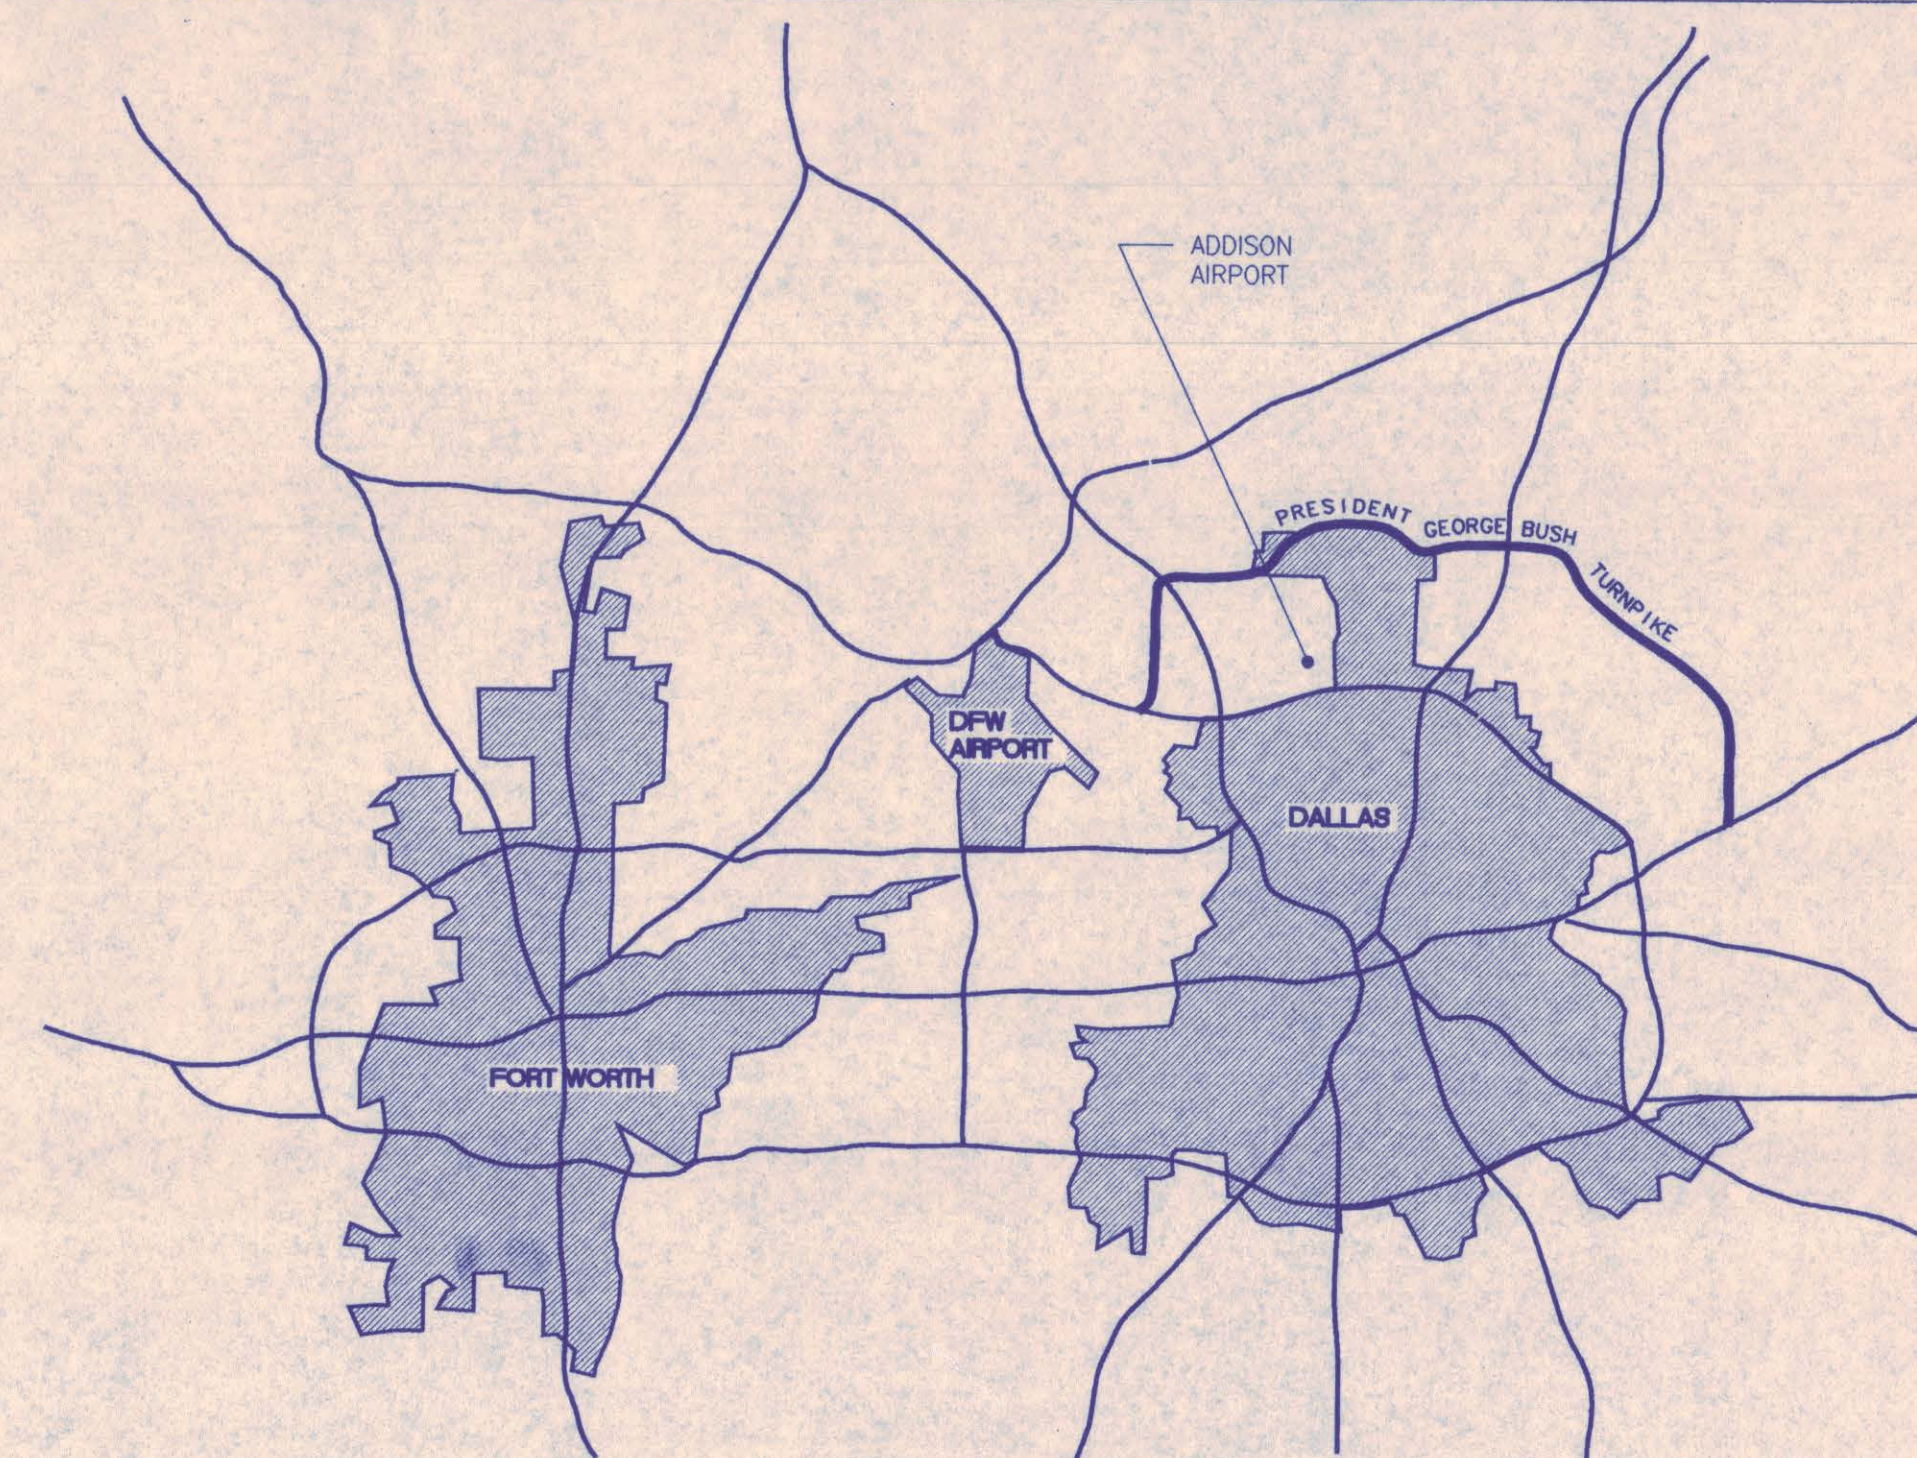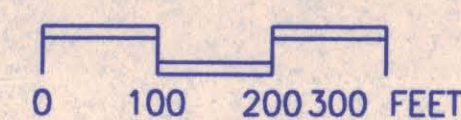

3 AREA MAP
NO SCALE
DFW.DWG



AT-GO.3








Stephen D. Hall
12/18/97
REGISTERED ARCHITECT
STEPHEN OWEN HALL
2015
STATE OF TEXAS

NO.	REVISION	BY	DATE
NORTH TEXAS TOLLWAY AUTHORITY ADDISON AIRPORT TUNNEL BARRIER TOLL PLAZA			
LOCATION MAPS			
AGUIRE Corporation 9700 PARK CENTRAL DRIVE 18 TH FLOOR DALLAS TEXAS 75201 TEL. 972 789-8008			SECTION XIII
CHECKED <i>Don</i>	DATE 12/18/97	DESIGNED MM	DATE 8/15/96
CHECKED <i>FEg</i>	DATE 12/18/97	SCALE NO SCALE	
CONTRACT NO. DNT-290	SHEET 3	OF 53	

ABBREVIATION LEGEND

[illegible]

     ARCHITECTURAL SYMBOLS

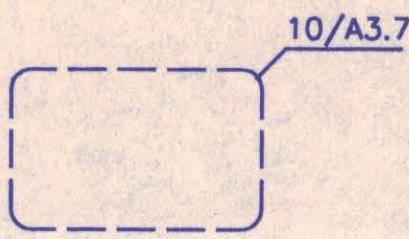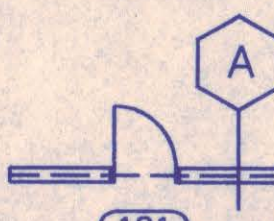	PLASTER, GROUT
	INSULATION (BATTEN)
	INSULATION (RIGID)
	BRICK
	CMU
	SOLID POLYMER
	EARTH
	CENTER LINE
	HIDDEN LINE
	BREAK LINE
	WORK TO BE REMOVED, FUTURE WORK WORK ABOVE, WORK BELOW OR WORK BEYOND ALL AS NOTED
	LEVEL LINE, FLOOR LEVEL OR ELEVATION
	COLUMN LINE
	ANGLE
	FASTENERS IN ELEVATION
	PLAN NORTH TRUE NORTH AS NOTED
	REVISIONS
	ELEVATION MARK
	WALL & BUILDING SECTIONS
	AREA DETAIL REFERENCE
	ROOM NAME & NUMBER
	PARTITION TYPE
	DOOR NUMBER

CODE SUMMARY

APPLICABLE CODES

1991 UNIFORM BUILDING CODE
1991 UNIFORM MECHANICAL CODE
1991 UNIFORM MECHANICAL CODE W/ AMENDMENTS
1990 NATIONAL ELECTRICAL CODE W/ AMENDMENTS
1991 NATIONAL FIRE CODE

OCCUPANCY CLASSIFICATION

CANOPY - GROUP B, DIVISION I
BOOTH- GROUP B, DIVISION I

CONSTRUCTION TYPE

CANOPY-	TYPE II N
BOOTH-	TYPE II N

ALLOWABLE FLOOR AREA

ALLOWABLE FLOOR AREA— 12,000 S.F. UBC TABLE 5-C

ACTUAL CANOPY AREA- 3,860 S.F.
ACTUAL BOOTH AREA- 408 S.F.

MAXIMUM ALLOWABLE HEIGHT UBC TABLE 5-D

ALLOWABLE STORIES/ HEIGHT- 2 STORIES / 55 FT.

ACTUAL CANOPY HEIGHT- 1 STORY / 33.5 FT.
ACTUAL BOOTH HEIGHT- 1 STORY / 13.4 FT.

CONSTRUCTION REQUIREMENTS- FIRE RESISTIVE REQUIREMENTS

STRUCTURAL FRAME _____ N
 INTERIOR/ EXTERIOR BEARING WALLS _____ N
 EXTERIOR/ NON-BEARING WALLS _____ N
 EXTERIOR DOORS AND WINDOWS _____ N
 PERMANENT PARTITIONS _____ N
 SHAFT ENCLOSURES _____ N
 ROOF/ CEILING _____ N

UBC TABLE 17-A

SHEET NUMBERING KEY

NN-XO.1

SITE DESIGNATION
(SEE BELOW)

SEQUENTIAL NUMBER

DISCIPLINE:

- A - ARCHITECTURAL
- C - CIVIL
- E - ELECTRICAL
- M - MECHANICAL
- P - PLUMBING
- S - STRUCTURAL
- G - GENERAL INFORMATION

R - RAMP PLAZA
(A THROUGH P)

B - BARRIER PLAZA
(#6 THROUGH #9)



OP- OPERATIONS BLDG.

AT- ADDISON TUNNEL

GENERAL NOTES


- 1.- CONTRACTOR SHALL VERIFY ALL EXISTING CONDITIONS AND INFORM THE ARCHITECT OF ANY DISCREPANCIES BETWEEN THESE AND THE CONTRACT DOCUMENTS.
- 2.- COORDINATE ALL WORK WITH CIVIL, STRUCTURAL, MECHANICAL, PLUMBING, ELECTRICAL, AND SECURITY DRAWINGS.
- 3.- COORDINATE ALL WORK AT LIMITS OF CONSTRUCTION WITH CONTRACTOR FOR ADJACENT WORK IN ORDER TO FACILITATE CONTINUATION OF FINISHES, MATERIAL AND APPROPRIATE CONNECTIONS.
- 4.- FINISH FLOOR OF BOOTH AT 634.33 FEET ABOVE MEAN SEA LEVEL EQUALS ARCHITECTURAL ELEVATION +100'-0".
- 5.- DIMENSIONS SHOWN ON DRAWINGS OVERRIDE GRAPHIC REPRESENTATIONS THERE ON. ANY SIGNIFICANT DISCREPANCIES FOUND WHICH ARE NOT INDICATED AS "NOT TO SCALE" ON THE DRAWINGS SHALL BE BROUGHT TO THE ATTENTION OF THE ENGINEER PRIOR TO CUTTING, FABRICATIONS OF INSTALLATIONS OR ASSEMBLIES. DO NOT SCALE DRAWINGS TO OBTAIN DIMENSIONS.

PROVIDE BIRD PREVENTION SYSTEMS AT EACH END OF ALL PRECAST CONCRETE TEES; TO BE MOUNTED ON TOP OF THE SUPPORTING CONCRETE BEAMS—

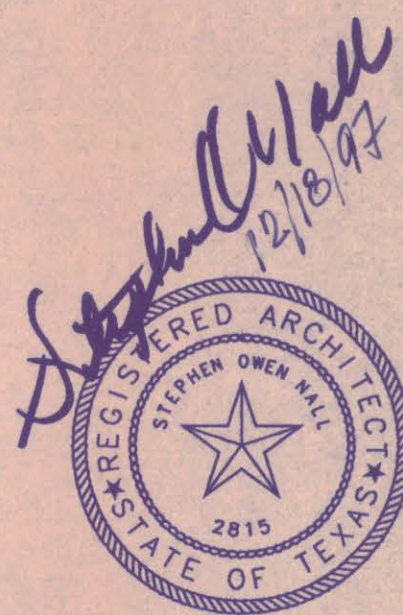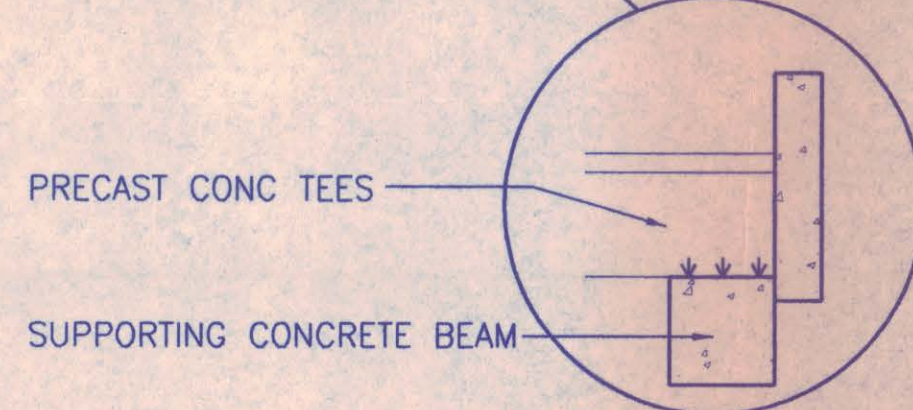

NO.	REVISION	BY	DATE
NORTH TEXAS TOLLWAY AUTHORITY ADDISON AIRPORT TUNNEL BARRIER TOLL PLAZA			
ABBREVIATIONS, SYMBOLS, GENERAL NOTES AND CODE SUMMARY			
AGUIRRE Corporation 5700 PARK CENTRAL DRIVE 18 TH FLOOR DALLAS TEXAS 75201 TEL. (972) 758-9505		SECTION XIII	
CHECKED <i>[Signature]</i>	DATE <u>12/18/97</u>	DESIGNED MM	DATE <u>8/15/96</u>
CHECKED <i>[Signature]</i>	DATE <u>12/18/97</u>	SCALE <u>N/A</u>	
CONTRACT NO.	DNT-290	SHEET 2	OF 53

AT-GO.2

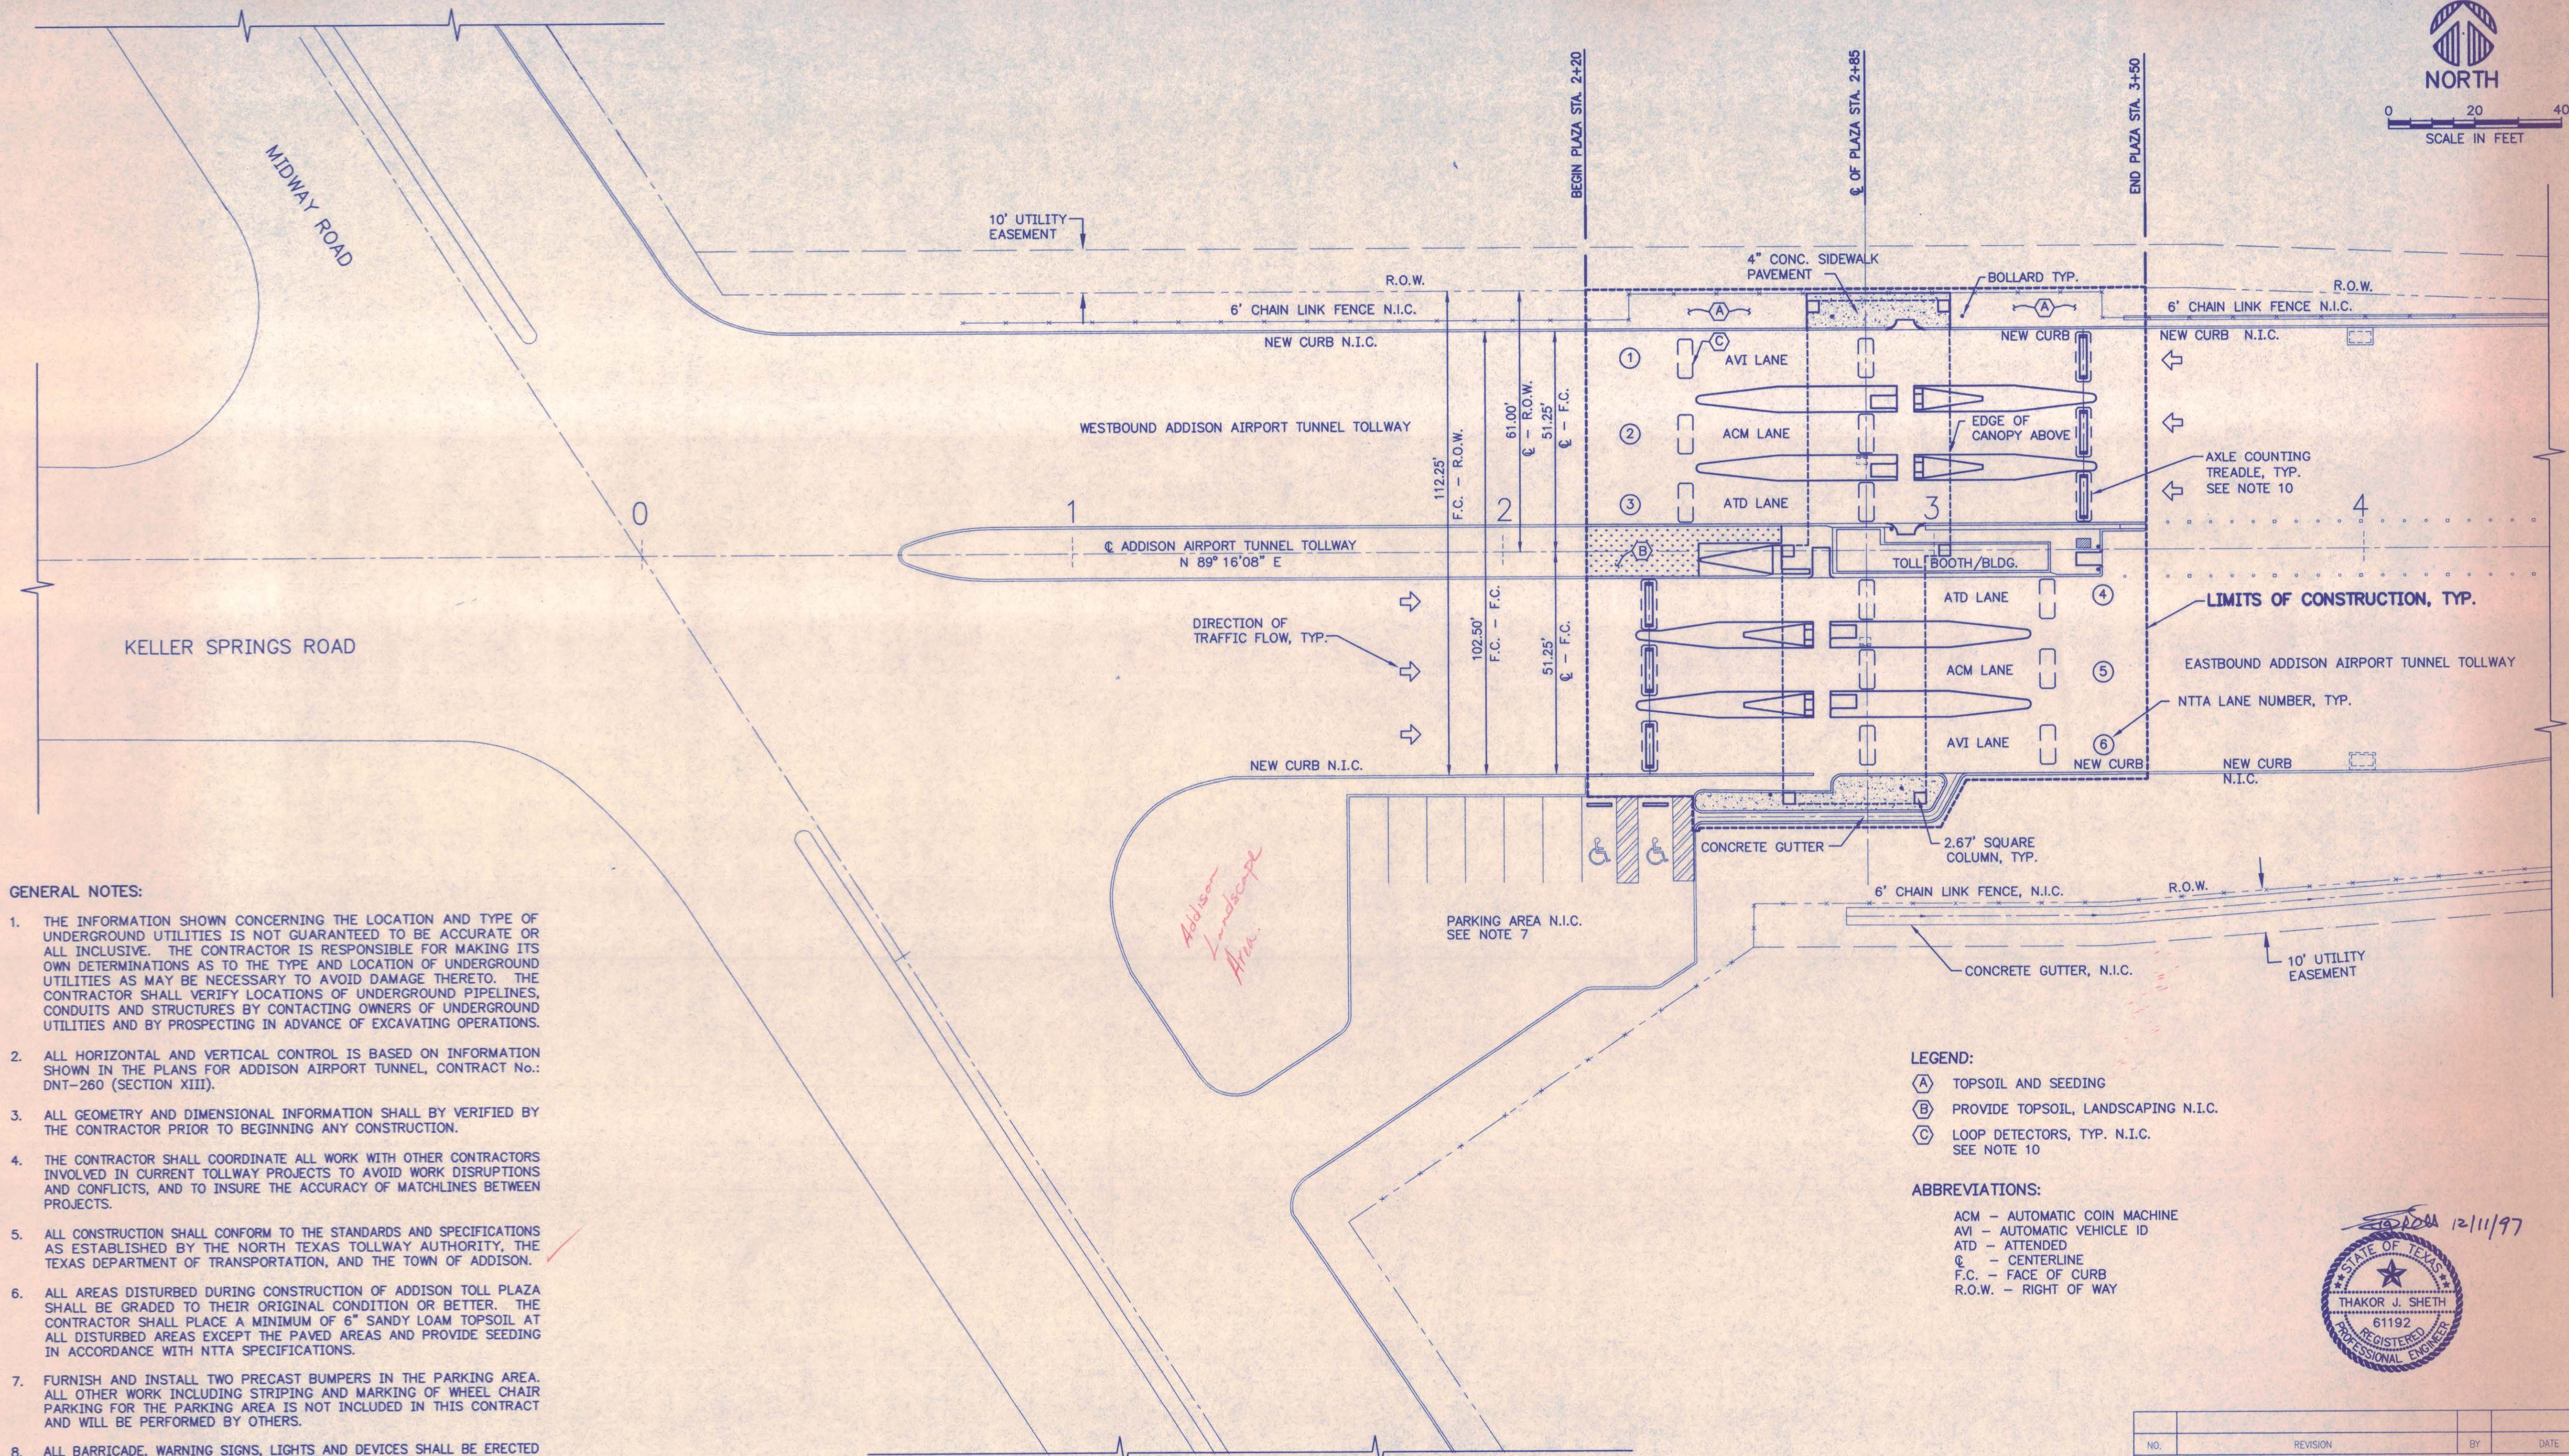

GENERAL NOTES:


1. THE INFORMATION SHOWN CONCERNING THE LOCATION AND TYPE OF UNDERGROUND UTILITIES IS NOT GUARANTEED TO BE ACCURATE OR ALL INCLUSIVE. THE CONTRACTOR IS RESPONSIBLE FOR MAKING ITS OWN DETERMINATIONS AS TO THE TYPE AND LOCATION OF UNDERGROUND UTILITIES AS MAY BE NECESSARY TO AVOID DAMAGE THERETO. THE CONTRACTOR SHALL VERIFY LOCATIONS OF UNDERGROUND PIPELINES, CONDUITS AND STRUCTURES BY CONTACTING OWNERS OF UNDERGROUND UTILITIES AND BY PROSPECTING IN ADVANCE OF EXCAVATING OPERATIONS.
2. ALL HORIZONTAL AND VERTICAL CONTROL IS BASED ON INFORMATION SHOWN IN THE PLANS FOR ADDISON AIRPORT TUNNEL, CONTRACT No.: DNT-260 (SECTION XIII).
3. ALL GEOMETRY AND DIMENSIONAL INFORMATION SHALL BY VERIFIED BY THE CONTRACTOR PRIOR TO BEGINNING ANY CONSTRUCTION.
4. THE CONTRACTOR SHALL COORDINATE ALL WORK WITH OTHER CONTRACTORS INVOLVED IN CURRENT TOLLWAY PROJECTS TO AVOID WORK DISRUPTIONS AND CONFLICTS, AND TO INSURE THE ACCURACY OF MATCHLINES BETWEEN PROJECTS.
5. ALL CONSTRUCTION SHALL CONFORM TO THE STANDARDS AND SPECIFICATIONS AS ESTABLISHED BY THE NORTH TEXAS TOLLWAY AUTHORITY, THE TEXAS DEPARTMENT OF TRANSPORTATION, AND THE TOWN OF ADDISON.
6. ALL AREAS DISTURBED DURING CONSTRUCTION OF ADDISON TOLL PLAZA SHALL BE GRADED TO THEIR ORIGINAL CONDITION OR BETTER. THE CONTRACTOR SHALL PLACE A MINIMUM OF 6" SANDY LOAM TOPSOIL AT ALL DISTURBED AREAS EXCEPT THE PAVED AREAS AND PROVIDE SEEDING IN ACCORDANCE WITH NTTA SPECIFICATIONS.
7. FURNISH AND INSTALL TWO PRECAST BUMPERS IN THE PARKING AREA. ALL OTHER WORK INCLUDING STRIPING AND MARKING OF WHEEL CHAIR PARKING FOR THE PARKING AREA IS NOT INCLUDED IN THIS CONTRACT AND WILL BE PERFORMED BY OTHERS.
8. ALL BARRICADE, WARNING SIGNS, LIGHTS AND DEVICES SHALL BE ERECTED AT MIDWAY ROAD, AND EAST OF PLAZA CONTRACTOR'S CONSTRUCTION LIMITS IMMEDIATELY AFTER THE TUNNEL CONTRACTOR REMOVES THE BARRICADES AT THESE LOCATIONS FOR THE GUIDANCE AND PROTECTION OF TRAFFIC AND PEDISTRIANS. THEY MUST CONFORM TO THE INSTALLATION SHOWN ON TMUTCD. THESE TRAFFIC CONTROL DEVICES SHALL BE MAINTAINED UNTIL THE ENTIRE TUNNEL PROJECT IS OPENED TO TRAFFIC.
9. A TEMPORARY POLLUTION PREVENTION AND CONTROL PLAN IS NOT REQUIRED BECAUSE OF THE NATURE OF THE CONSTRUCTION (SHORT DURATION AND SMALL DISTURBED AREA). HOWEVER, IF POLLUTION PREVENTION MEASURES ARE DETERMINED TO BE REQUIRED DURING THE CONSTRUCTION, THEN THE CONTRACTOR SHALL FURNISH ALL MATERIALS, LABOR AND EQUIPMENT FOR INSTALLATION, MAINTENANCE AND REMOVAL OF ALL MEASURES REQUIRED BY THE ENGINEER. THIS WORK WILL BE COMPENSATED AS AN EXTRA WORK.
10. FURNISHING AND INSTALLATION OF LOOP DETECTORS ARE NOT INCLUDED IN THIS CONTRACT. TREADLE FRAME WILL BE FURNISHED BY THE AUTHORITY. INSTALLATION OF TREADLE FRAME IS INCLUDED IN THIS CONTRACT.

LEGEND:

- (A) TOPSOIL AND SEEDING
- (B) PROVIDE TOPSOIL, LANDSCAPING N.I.C.
- (C) LOOP DETECTORS, TYP. N.I.C. SEE NOTE 10

ABBREVIATIONS:

- ACM - AUTOMATIC COIN MACHINE
- AVI - AUTOMATIC VEHICLE ID
- ATD - ATTENDED
- C - CENTERLINE
- F.C. - FACE OF CURB
- R.O.W. - RIGHT OF WAY

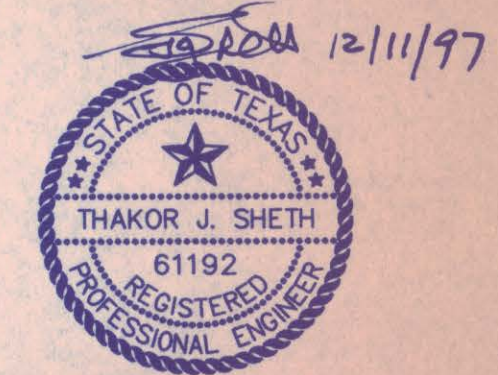

BENCHMARK T-301

5/8" I.R. SET APPROXIMATELY 100' E. OF MIDWAY ROAD AND 250' S. OF KELLER SPRINGS AND MIDWAY ROAD INTERSECTION EL. 639.96

BENCHMARKS: TOWN OF ADDISON


1. "SQUARE" CUT IN SOUTHEAST TOP OF CURB OF PARKING LOT AT BUILDING #15950 ELEV. 637.75.
2. "SQUARE" CUT IN SOUTHWEST TOP OF CURB OF PARKING LOT AT 4125 KELLER SPRINGS ROAD. 60± WEST OF MIDWAY PLACE SIGN. ELEV. 634.62.

Chiang, Patel & Yerby, Inc.
Consulting Engineers • Planners • Project Managers
Dallas • Fort Worth • Houston • San Antonio

NO.		REVISION		BY		DATE	
NORTH TEXAS TOLLWAY AUTHORITY ADDISON AIRPORT TUNNEL							
SITE PLAN							
AGUIRRE ASSOCIATES INC 12700 PARK CENTRAL DRIVE 15 TH FLOOR DALLAS TEXAS 75251 TEL (972) 788-1508				SECTION XIII			
DRAWN WAB		DATE 8/28/97		DESIGNED WAB		DATE 12/20/96	
CHECKED TJS		DATE 11/5/97		SCALE 1"=20'-0"			
CONTRACT NO. DNT-290 SHEET 4 OF 53							

AT-C1.1

131011M AT-C11.DWG

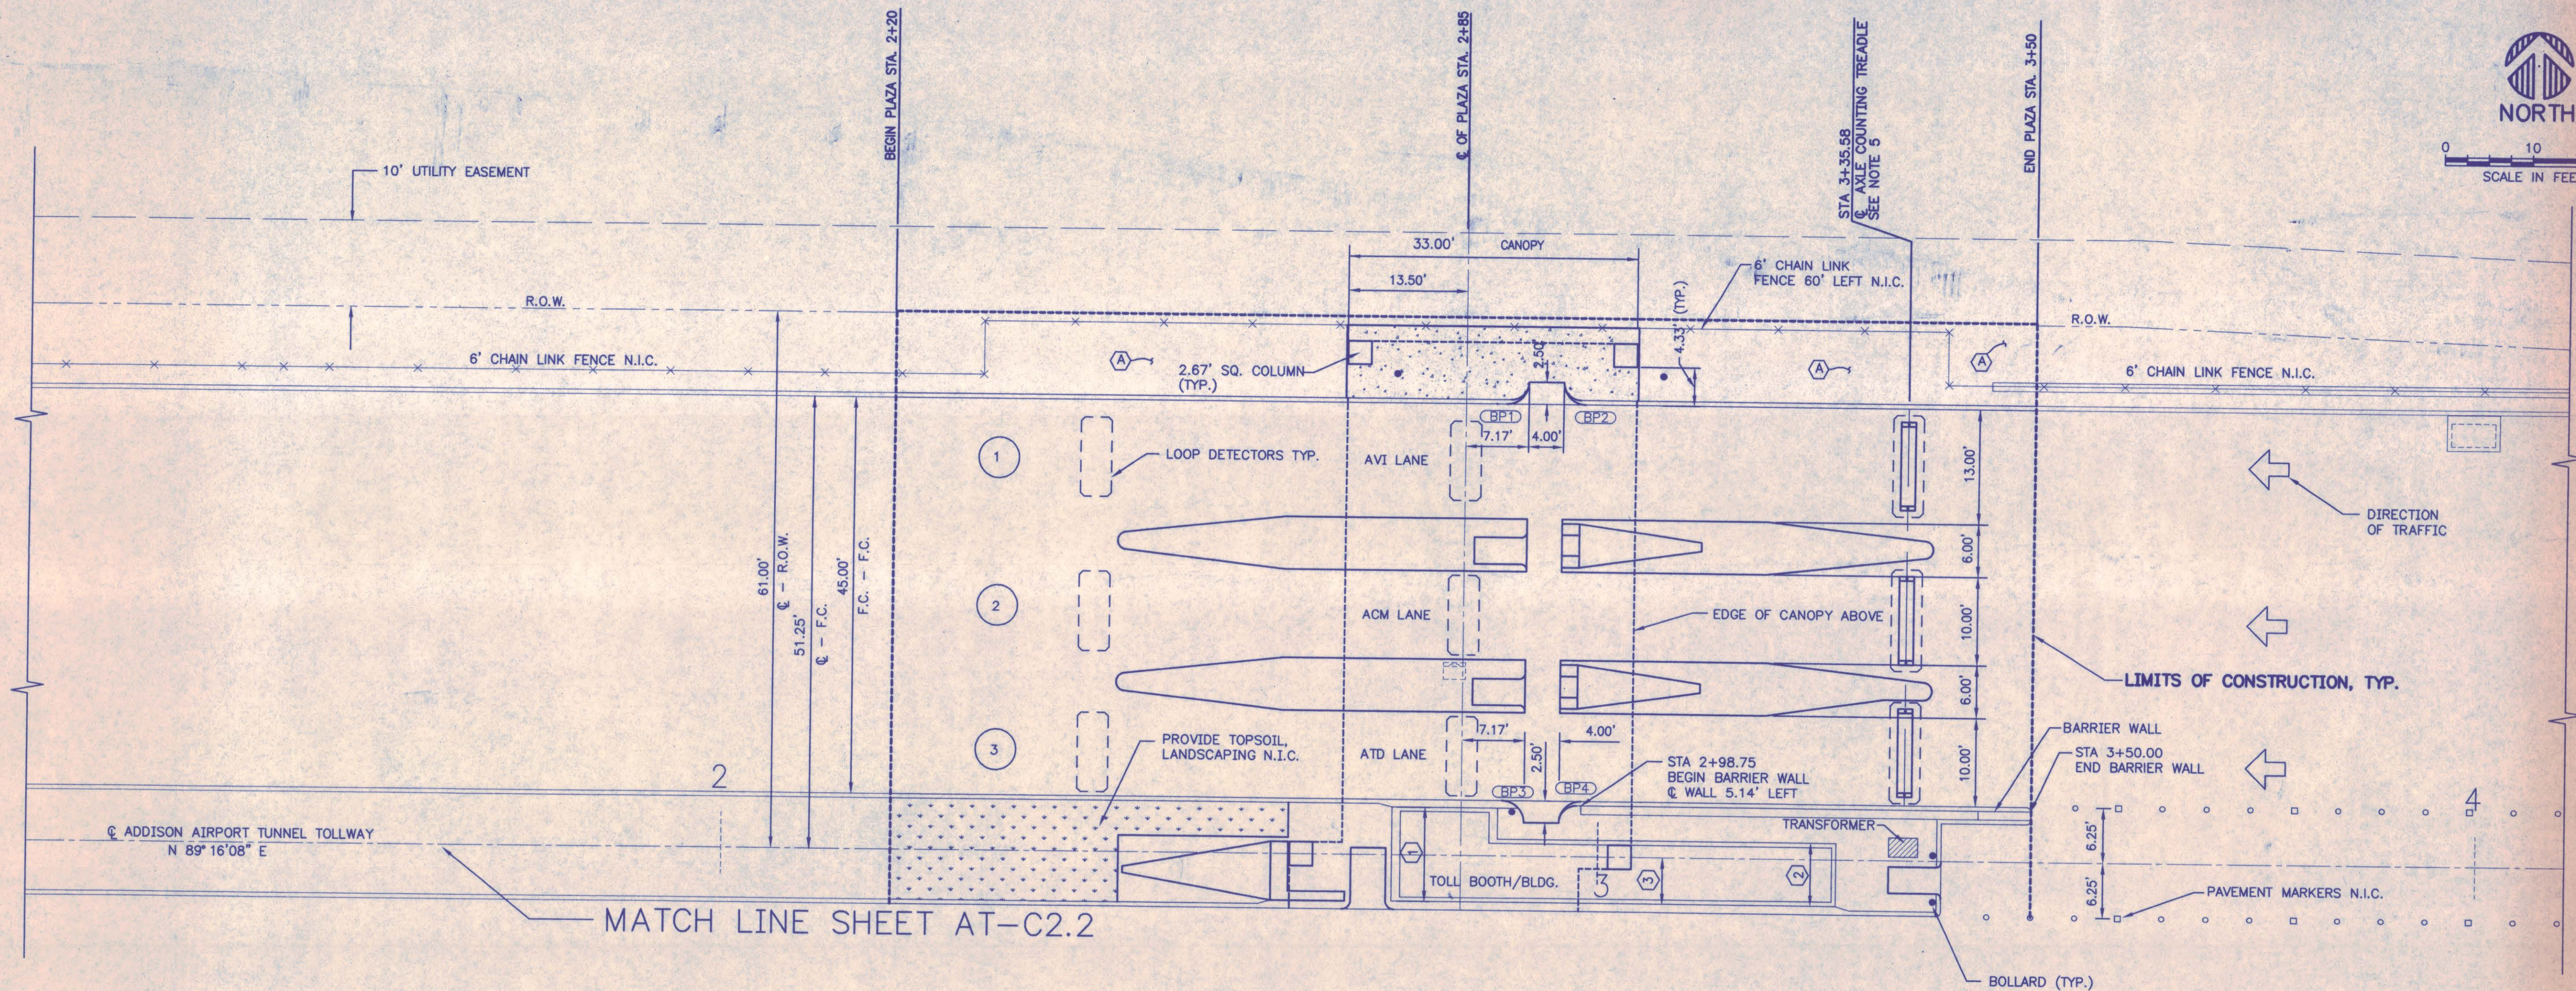

NOTES:

1. SEE GENERAL NOTES ON SHEET AT-C1.1.
2. PAVEMENT STRIPING FOR MAIN LANES IS NOT INCLUDED IN THIS CONTRACT.
3. FOR DIMENSIONAL INFORMATION ON THE ISLANDS IN MAIN PLAZA AREAS, SEE SHEETS AT-C7.1 AND AT-C7.2.
4. FOR FURTHER INFORMATION ON THE TOLL BOOTH/BLDG. AND CANOPY STRUCTURES WITHIN THE MAIN PLAZA AREA, SEE ARCHITECTURAL SHEETS AT-A2.1 AND STRUCTURAL SHEETS AT-S1.1.
5. VERIFY LOCATION OF AXLE COUNTING TREADLE WITH TTA PRIOR TO PAVEMENT CONSTRUCTION.
6. FOR LOCATION OF LOOP DETECTORS SEE SHEET AT-C5.1.

CURVE DATA TABLE				
CURVE No.	DELTA	RADIUS	TANGENT	LENGTH
BP1	90°00'00"	2.50'	2.50'	3.93'
BP2	90°00'00"	2.50'	2.50'	3.93'
BP3	90°00'00"	2.50'	2.50'	3.93'
BP4	90°00'00"	2.50'	2.50'	3.93'

* FACE OF THE CURB RADIUS IS SHOWN IN THE ABOVE TABLE.

BENCHMARKS: TOWN OF ADDISON

1. "SQUARE" CUT IN SOUTHEAST TOP OF CURB OF PARKING LOT AT BUILDING #15950 ELEV. 637.75.
2. "SQUARE" CUT IN SOUTHWEST TOP OF CURB OF PARKING LOT AT 4125 KELLER SPRINGS ROAD 60'± WEST OF MIDWAY PLACE SIGN. ELEV. 634.62.

BENCHMARK T-301


5/8" I.R. SET APPROXIMATELY 100' E. OF MIDWAY RD. AND 250' S. OF KELLER SPRINGS AND MIDWAY RD. INTERSECTION EL. 639.96

ABBREVIATIONS:

CL - CENTERLINE
F.C. - FACE OF CURB
O.F. - OUTSIDE FACE

LEGEND:


- ① 10.67' O.F. - O.F.
- ② 7.17' O.F. - O.F.
- ③ 5.33' O.F. - CL
- (A) 6" TOPSOIL AND SEEDING

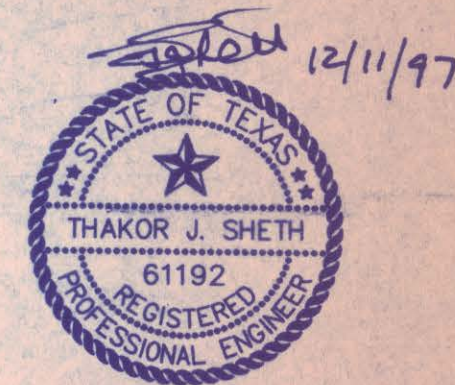

Chiang, Patel & Yerby, Inc.
Consulting Engineers • Planners • Project Managers
Dallas • Fort Worth • Houston • San Antonio

NO.	REVISION	BY	DATE
NORTH TEXAS TOLLWAY AUTHORITY ADDISON AIRPORT TUNNEL			
DIMENSIONAL CONTROL PLAN A			
AQUIRE ASSOCIATES INC 12700 PARK CENTRAL DRIVE 15 TH FLOOR DALLAS TEXAS 75261 TEL (972) 788-1608		SECTION XIII	
DRAWN WAB	DATE 8/28/97	DESIGNED WAB	DATE 12/20/97
CHECKED TJS	DATE 11/5/97	SCALE 1"=10'-0"	
CONTRACT NO. DNT-290 SHEET 5 OF 53			

AT-C2.1

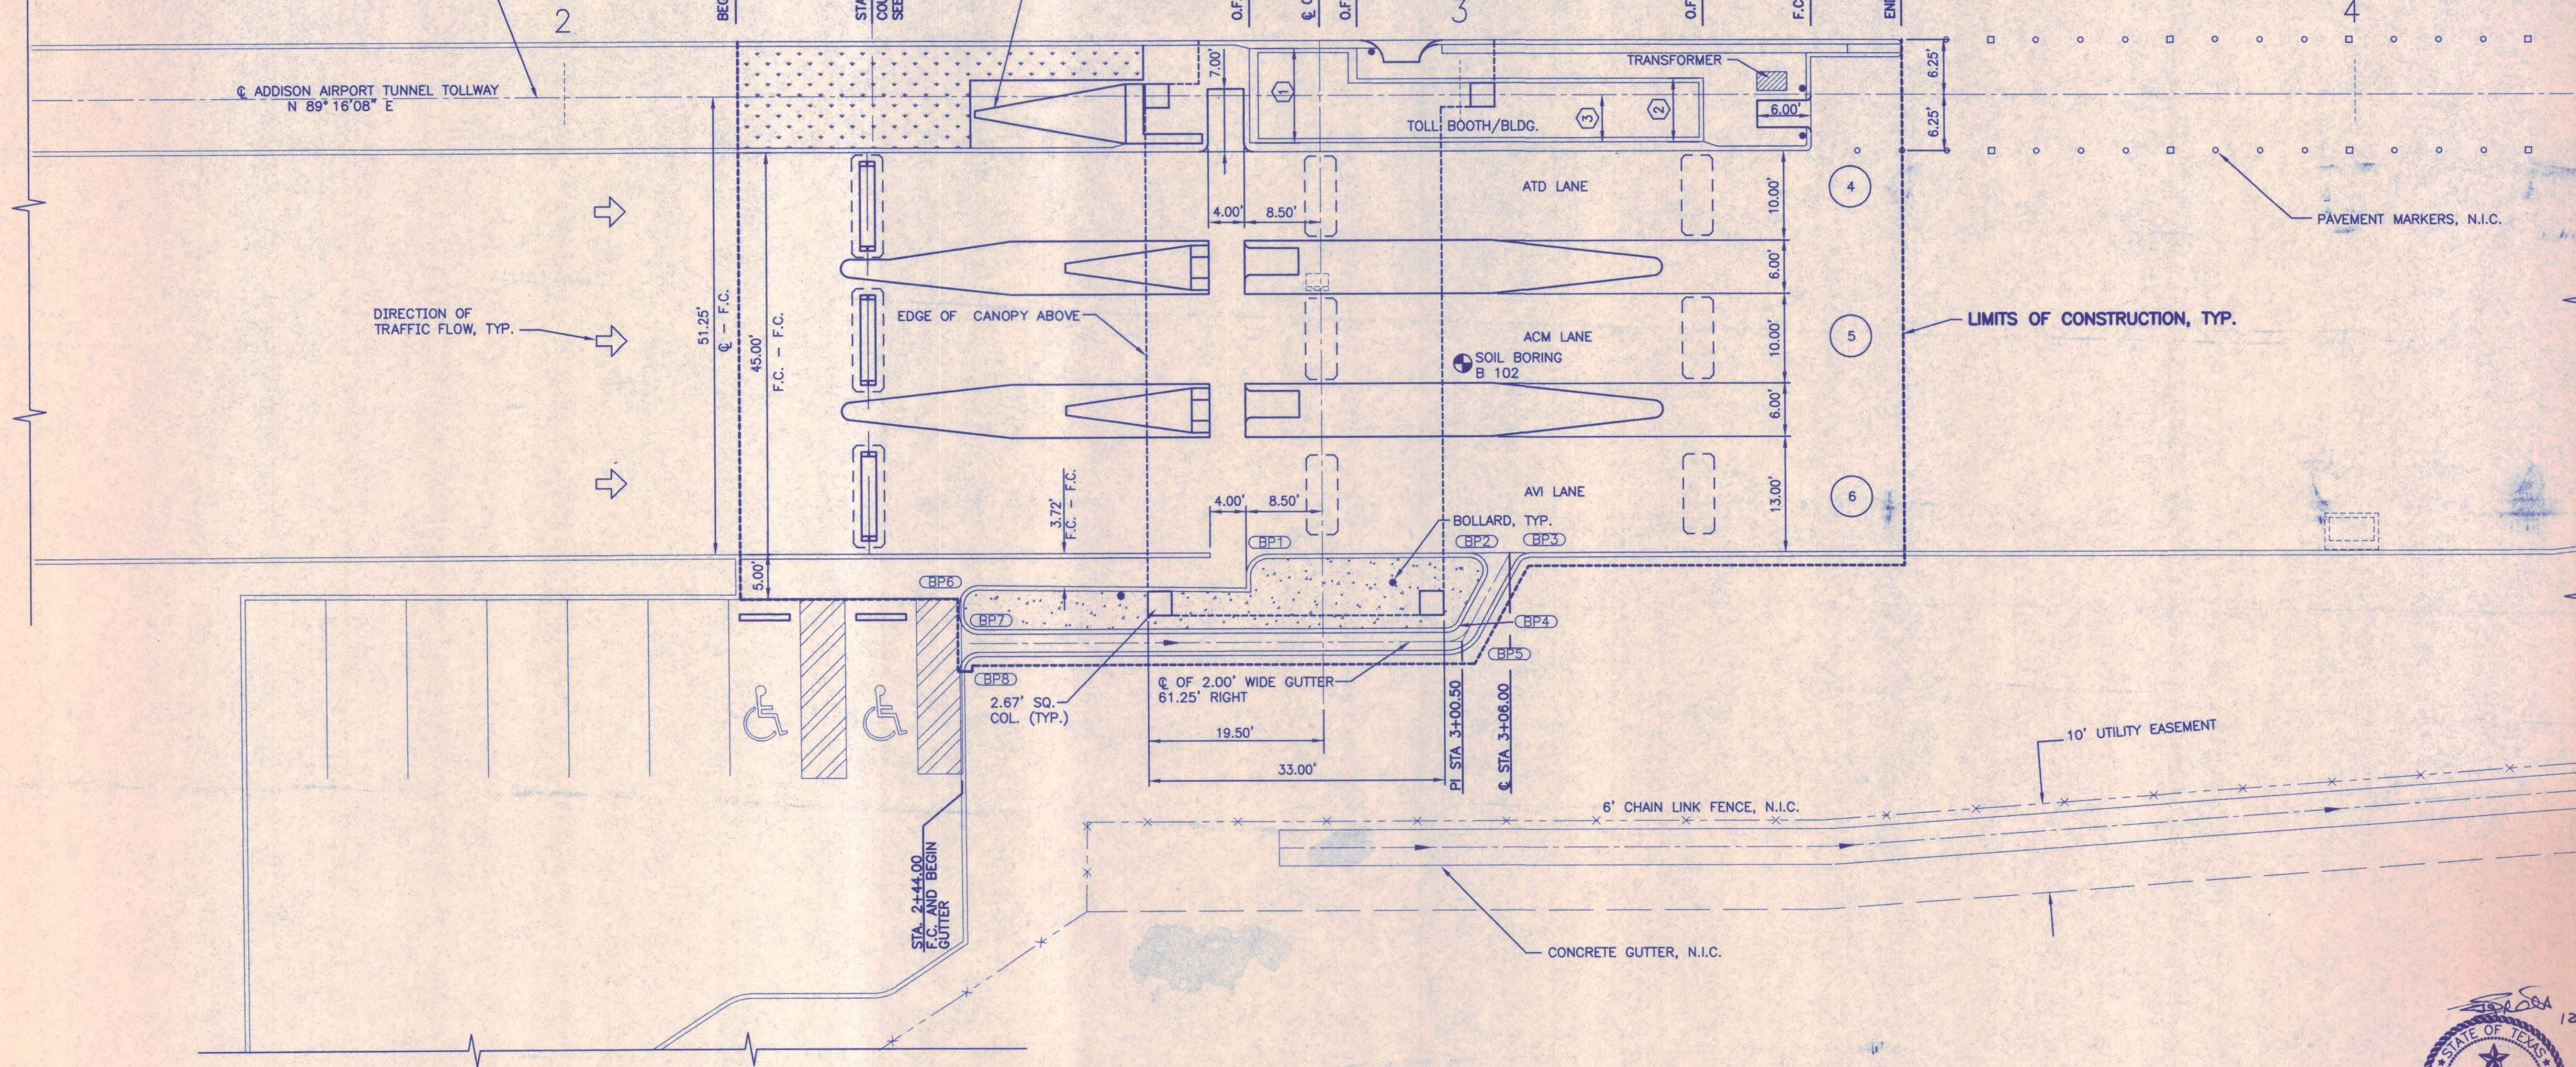


NO.	REVISION	BY	DATE
NORTH TEXAS TOLLWAY AUTHORITY ADDISON AIRPORT TUNNEL			
DIMENSIONAL CONTROL PLAN B			
		SECTION XIII	
AGUIRRE ASSOCIATES INC. 12700 PARK CENTRAL DRIVE 15 TH FLOOR DALLAS TEXAS 75251 TEL. (972) 755-1503			
DRAWN WAB	DATE 8/28/97	DESIGNED WAB	DATE 12/20/97
CHECKED TJS	DATE 11/5/97	SCALE 1"=10'-0"	
CONTRACT NO. DNT-290		SHEET 6 OF 53	

AT-C2.2



0 10 20
SCALE IN FEET

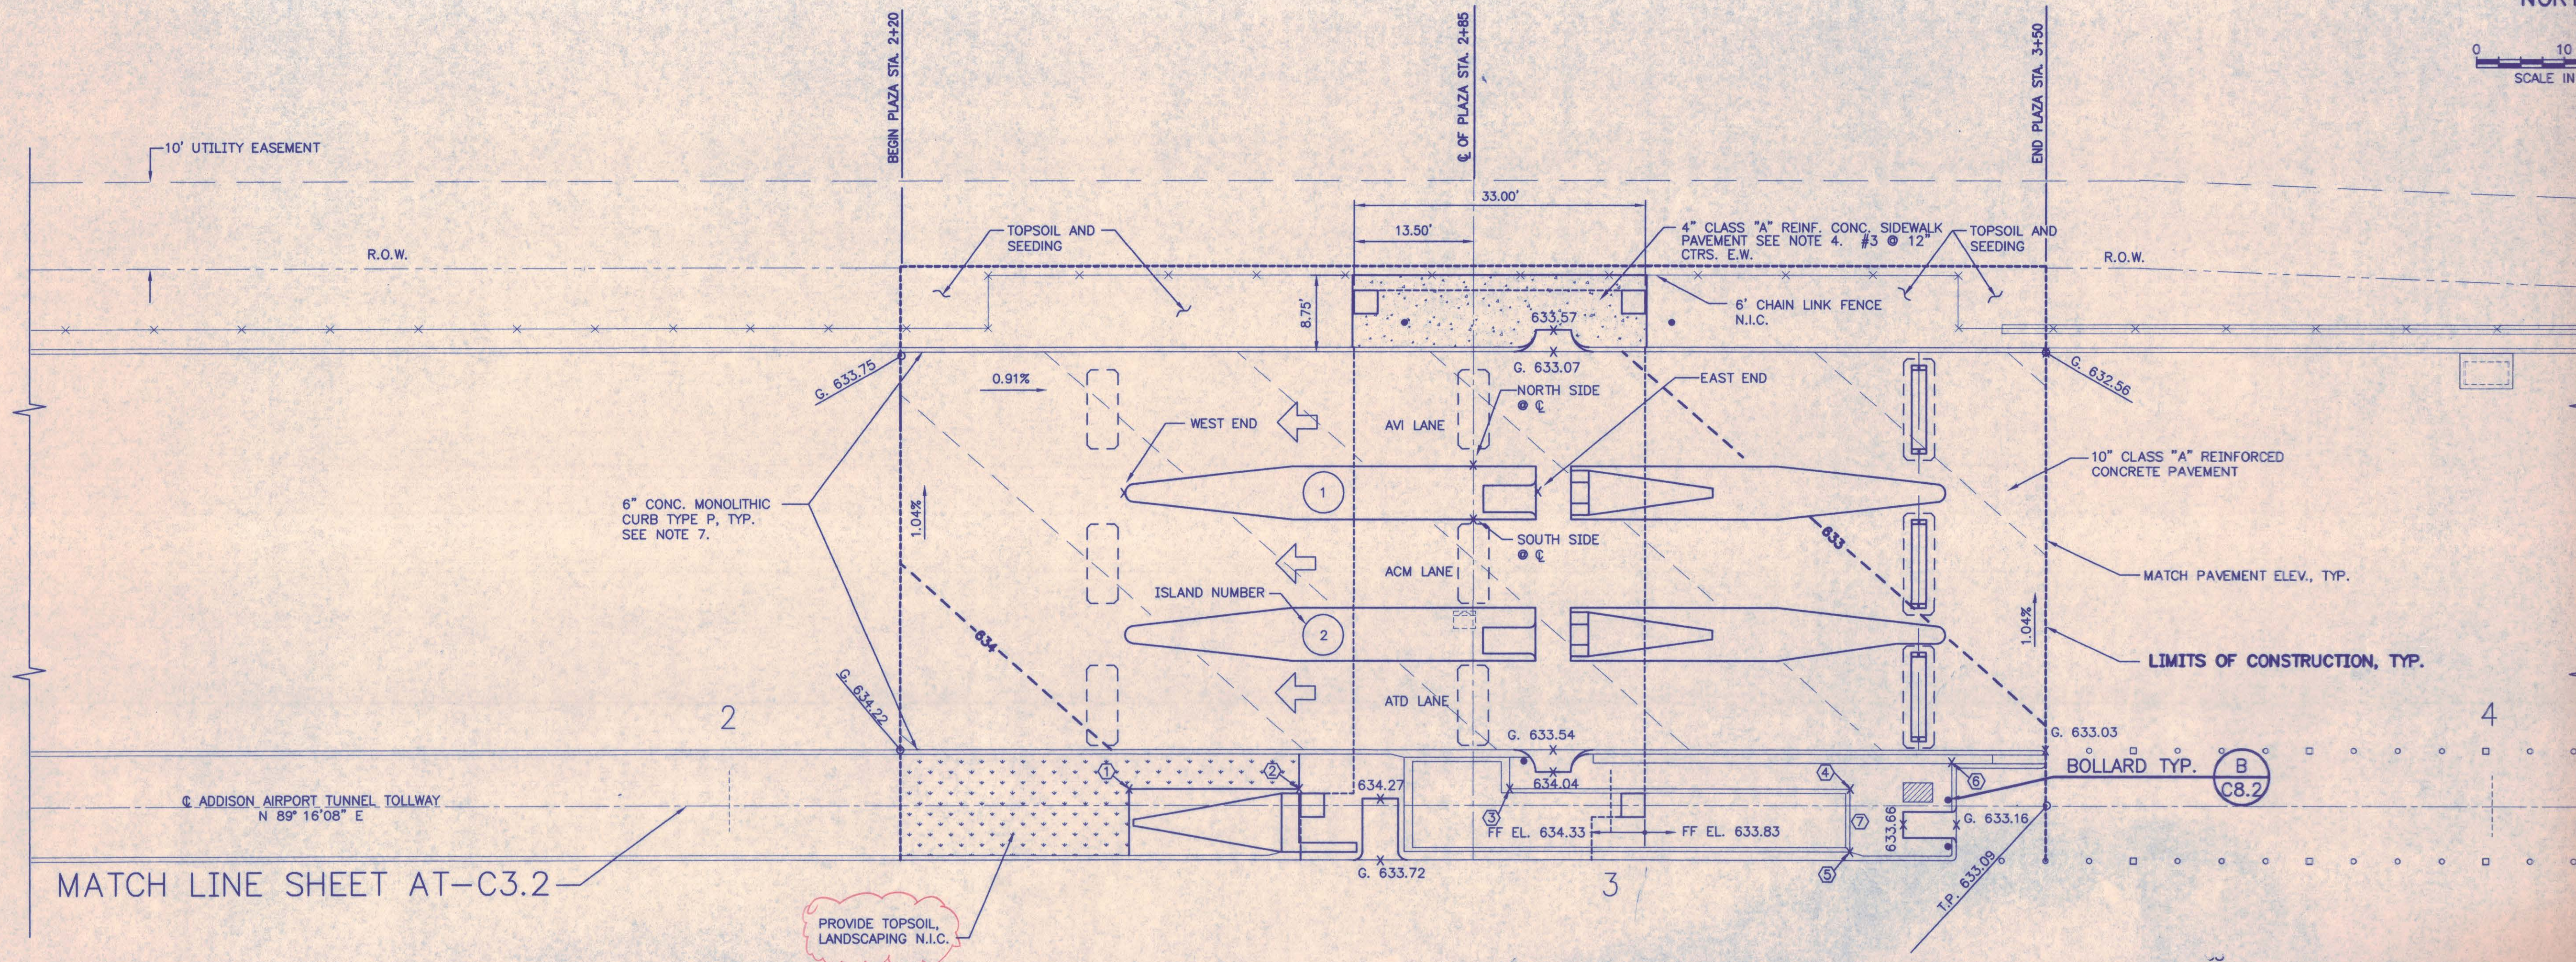

NOTES:

1. SEE GENERAL NOTES ON SHEET AT-C1.1.
2. SEE SHEET AT-C8.1 FOR PAVEMENT AND SIDEWALK JOINTS.
3. CONTOURS SHOWN REPRESENT TOP OF PAVEMENT ELEVATIONS.
4. ALL SIDEWALK PAVEMENT SHALL BE PLACED ON A MINIMUM OF 2" CONSOLIDATED SAND BASE.
5. THE ELEVATIONAL DATA FOR THE PROFILE GRADE LINE AS SHOWN ON THIS SHEET, WAS TAKEN FROM SHEET C26 OF DNT CONTRACT No. 260.
6. EXISTING GRADE AT THE MAIN LANE PAVING AREA IS APPROXIMATELY 12" BELOW THE TOP OF PAVEMENT ELEVATIONS SHOWN ON THIS DRAWING.
7. REFER TO SHEET AT-C8.1 FOR TYPE P CURB.
8. THE LIME TREATED SUBGRADE WITHIN AND ADJACENT TO THE TOLL PLAZA CONSTRUCTION LIMITS HAS PREVIOUSLY BEEN LIME TREATED AND STABILIZED BY OTHERS. IF THAT LIME STABILIZED SUBGRADE SUBSEQUENTLY IS DAMAGED BY THE CONTRACTOR'S CONSTRUCTION OPERATION, THE SUBGRADE SHALL BE REPAIRED WITH AVAILABLE STOCKPILE LIME TRIMMINGS OR WITH LIME SLURRY AS DIRECTED BY THE ENGINEER.

LOCATION	PAVEMENT ELEVATIONS							
	WEST END		N. SIDE @ PLAZA		S. SIDE @ PLAZA		EAST END	
	G	TC	G	TC	G	TC	G	TC
N. GUTTER	633.75	634.25	N/A	N/A	633.16	633.66	632.56	633.06
ISLAND 1	633.68	634.18	633.30	633.80	633.36	633.86	633.25	633.25
ISLAND 2	633.84	634.34	633.45	633.95	633.52	634.02	633.43	633.43
S. GUTTER	634.22	634.72	633.63	634.13	N/A	N/A	633.03	633.53

(SEE ISLAND 1 FOR TYPICAL SPOT ELEVATION LOCATIONS)

ABBREVIATIONS:

G - GUTTER
N - NORTH
S - SOUTH
TC - TOP OF CURB
TP - TOP OF PAVEMENT

LEGEND:

- x — x — CHAIN LINK FENCE
- - - - - MAIN CONTOURS (1' INTERVALS)
- - - - - INTERMEDIATE CONTOURS (0.2' INTERVALS)



- ① TOP OF MEDIAN EL. 634.57
② TOP OF MEDIAN EL. 634.40
③ TOP OF MEDIAN EL. 634.18
④ TOP OF MEDIAN EL. 633.81
⑤ TOP OF MEDIAN EL. 633.71
⑥ TOP OF CURB EL. 633.64
⑦ TOP OF MEDIAN EL. 633.79
⊙ DOOR

CURB TRANSITION

TYPE A CURB TO TYPE P CURB
NORTH & SOUTH CURB. FROM
STA. 2+20.00 TO STA. 2+22.50

TYPE P CURB TO TYPE A CURB
NORTH CURB. FROM STA.
3+47.50 TO STA. 3+50.00

BENCHMARKS: TOWN OF ADDISON


1. "SQUARE" CUT IN SOUTHEAST TOP OF CURB OF PARKING LOT AT BUILDING #15950 ELEV. 637.75.
2. "SQUARE" CUT IN SOUTHWEST TOP OF CURB OF PARKING LOT AT 4125 KELLER SPRINGS ROAD. 60'± WEST OF MIDWAY PLACE SIGN. ELEV. 634.62.

BENCHMARK T-301

5/8" I.R. SET APPROXIMATELY 100' E. OR MIDWAY RD AND 250' S. OF KELLER SPRINGS AND MIDWAY RD INTERSECTION EL. 639.96



Chiang, Patel & Yerby, Inc.
Consulting Engineers • Planners • Project Managers
Dallas • Fort Worth • Houston • San Antonio

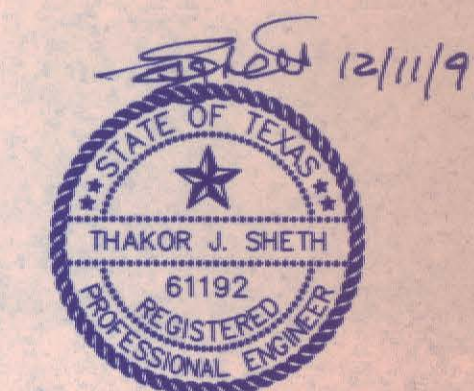

**NORTH TEXAS TOLLWAY AUTHORITY
ADDISON AIRPORT TUNNEL**

**PAVING AND GRADING
PLAN A**

AGUIRRE ASSOCIATES INC
12700 PARK CENTRAL DRIVE
15 TH FLOOR
DALLAS TEXAS 75251
TEL (972) 788-1608

SECTION XIII

DRAWN WAB DATE 8/28/97 DESIGNED WAB DATE 12/20/96
CHECKED TJS DATE 11/5/97 SCALE 1"=10'-0"

CONTRACT NO. DNT-290 SHEET 7 OF 53

AT-C3.1



0 10 20
SCALE IN FEET

MATCH LINE SHEET AT-C3.1

2

3

4

ADDISON AIRPORT TOLLWAY
N 89° 16' 08" E

BEGIN PLAZA STA. 2+20

CL OF PLAZA STA. 2+85

END PLAZA STA. 3+50

PROVIDE TOPSOIL, LANDSCAPING N.I.C.

PAVEMENT MARKERS N.I.C.

BOLLARD
TYP. (B)
C8.2

MATCH EXIST. PVMT. ELEV., TYP.

LIMITS OF CONSTRUCTION, TYP.

CURB TRANSITION

TYPE A CURB TO TYPE P CURB
NORTH AND SOUTH CURB. FROM
STA. 2+20.00 TO STA. 2+22.50


TYPE P CURB TO TYPE A CURB
SOUTH CURB. FROM STA. 3+47.50
TO STA. 3+50.00

ABBREVIATIONS:

G - GUTTER
N - NORTH
S - SOUTH
TC - TOP OF CURB
TP - TOP OF PAVEMENT


LEGEND:

CHAIN LINK FENCE
MAIN CONTOURS
(1' INTERVALS)
INTERMEDIATE CONTOURS
(0.2' INTERVALS)
4" SIDEWALK PAVEMENT

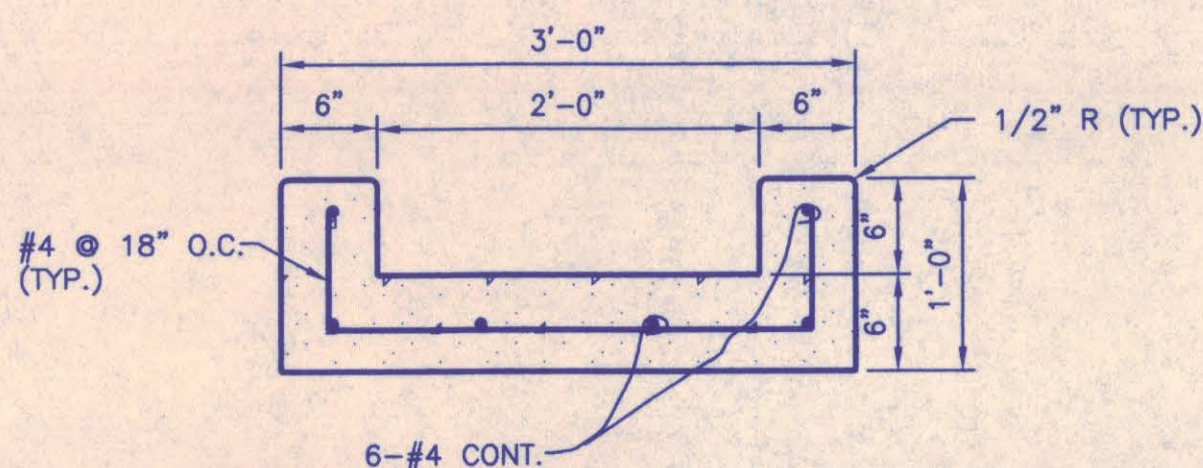

CONCRETE GUTTER (TY A) (2'-0")

SCALE: 1"=1'-0"

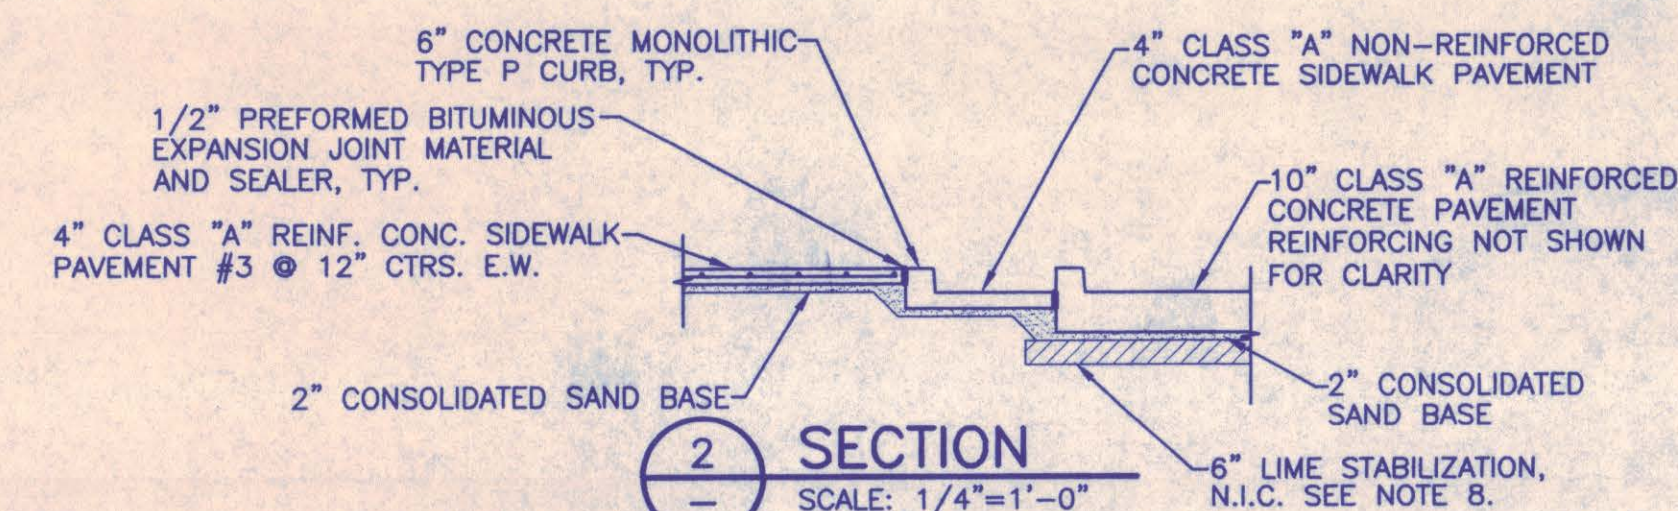


SECTION
SCALE: 1/4"=1'-0"

LOCATION	WEST END		N. SIDE @ PLAZA		S. SIDE @ PLAZA		EAST END	
	G	TC	G	TC	G	TC	G	TC
N. GUTTER	634.22	634.72	N/A	N/A	633.63	634.13	633.03	N/A
ISLAND 3	633.56	633.56	633.53	634.03	633.47	633.97	633.14	633.64
ISLAND 4	633.40	633.40	633.36	633.86	633.30	633.80	632.97	633.47
S. GUTTER	633.75	634.25	633.16	633.66	N/A	N/A	632.56	633.06

(SEE ISLAND 3 FOR TYPICAL SPOT ELEVATION LOCATIONS)

NOTES:

- SEE GENERAL NOTES ON SHEET AT-C1.1.
- SEE SHEET AT-C8.1 FOR PAVEMENT AND SIDEWALK JOINTS.
- CONTOURS SHOWN REPRESENT TOP OF PAVEMENT ELEVATIONS.
- ALL SIDEWALK PAVEMENT SHALL BE PLACED ON A MINIMUM OF 2" CONSOLIDATED SAND BASE.
- THE ELEVATIONAL DATA FOR THE PROFILE GRADE LINE AS SHOWN ON THIS SHEET, WAS TAKEN FROM SHEET C26 OF DNT CONTRACT NO. 260.
- EXISTING GRADE AT THE MAIN LANE PAVING AREA IS APPROXIMATELY 12" BELOW THE TOP OF PAVEMENT ELEVATIONS SHOWN ON THIS DRAWING.
- REFER TO SHEET AT-C8.1 FOR TYPE "P" CURB.
- THE LIME TREATED SUBGRADE WITHIN AND ADJACENT TO THE TOLL PLAZA CONSTRUCTION LIMITS HAS PREVIOUSLY BEEN LIME TREATED AND STABILIZED BY OTHERS. IF THAT LIME STABILIZED SUBGRADE SUBSEQUENTLY IS DAMAGED BY THE CONTRACTOR'S CONSTRUCTION OPERATIONS, THE SUBGRADE SHALL BE REPAIRED WITH AVAILABLE STOCKPILED LIME TRIMMINGS OR WITH LIME SLURRY AS DIRECTED BY THE ENGINEER.
- FURNISH AND INSTALL PRECAST BUMPERS IN THE PARKING AREA AS SHOWN IN THIS DRAWING. SIGNAGE, STRIPING AND WHEEL CHAIR SYMBOLS ARE NOT INCLUDED IN THIS CONTRACT.
- ALL ACCESS RAMPS EXCEPT RAMP AT THE NORTH CANOPY COLUMN AND NORTH OF THE TOLL BOOTH SHALL BE CONSTRUCTED IN ACCORDANCE WITH ADA ACCESSIBILITY GUIDELINES FOR BUILDINGS AND FACILITIES. RAMP SURFACE AREA SHALL BE COVERED WITH A DETECTABLE WARNINGS AS DESCRIBED IN THESE STANDARDS.

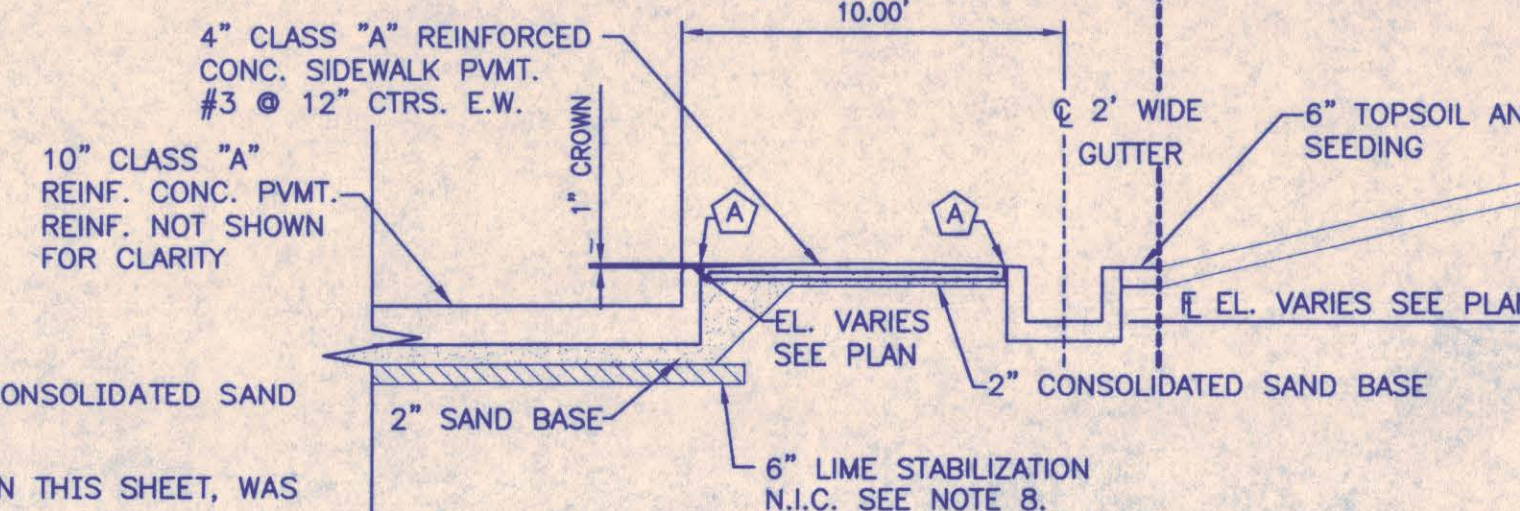

1/2" PREFORMED BITUMINOUS
EXPANSION JOINT MATERIAL & SEALER



SECTION
SCALE: 1"=5'-0"



Chiang, Patel & Yerby, Inc.
Consulting Engineers • Planners • Project Managers
Dallas • Fort Worth • Houston • San Antonio



NO.	REVISION	BY	DATE
NORTH TEXAS TOLLWAY AUTHORITY ADDISON AIRPORT TUNNEL			
PAVING AND GRADING PLAN B			
DRAWN WAB CHECKED TJS DATE 8/28/97 DATE 11/5/97 DESIGNED WAB SCALE 1"=10'-0"			
CONTRACT NO. DNT-290 SHEET 8 OF			

AT-C3.2

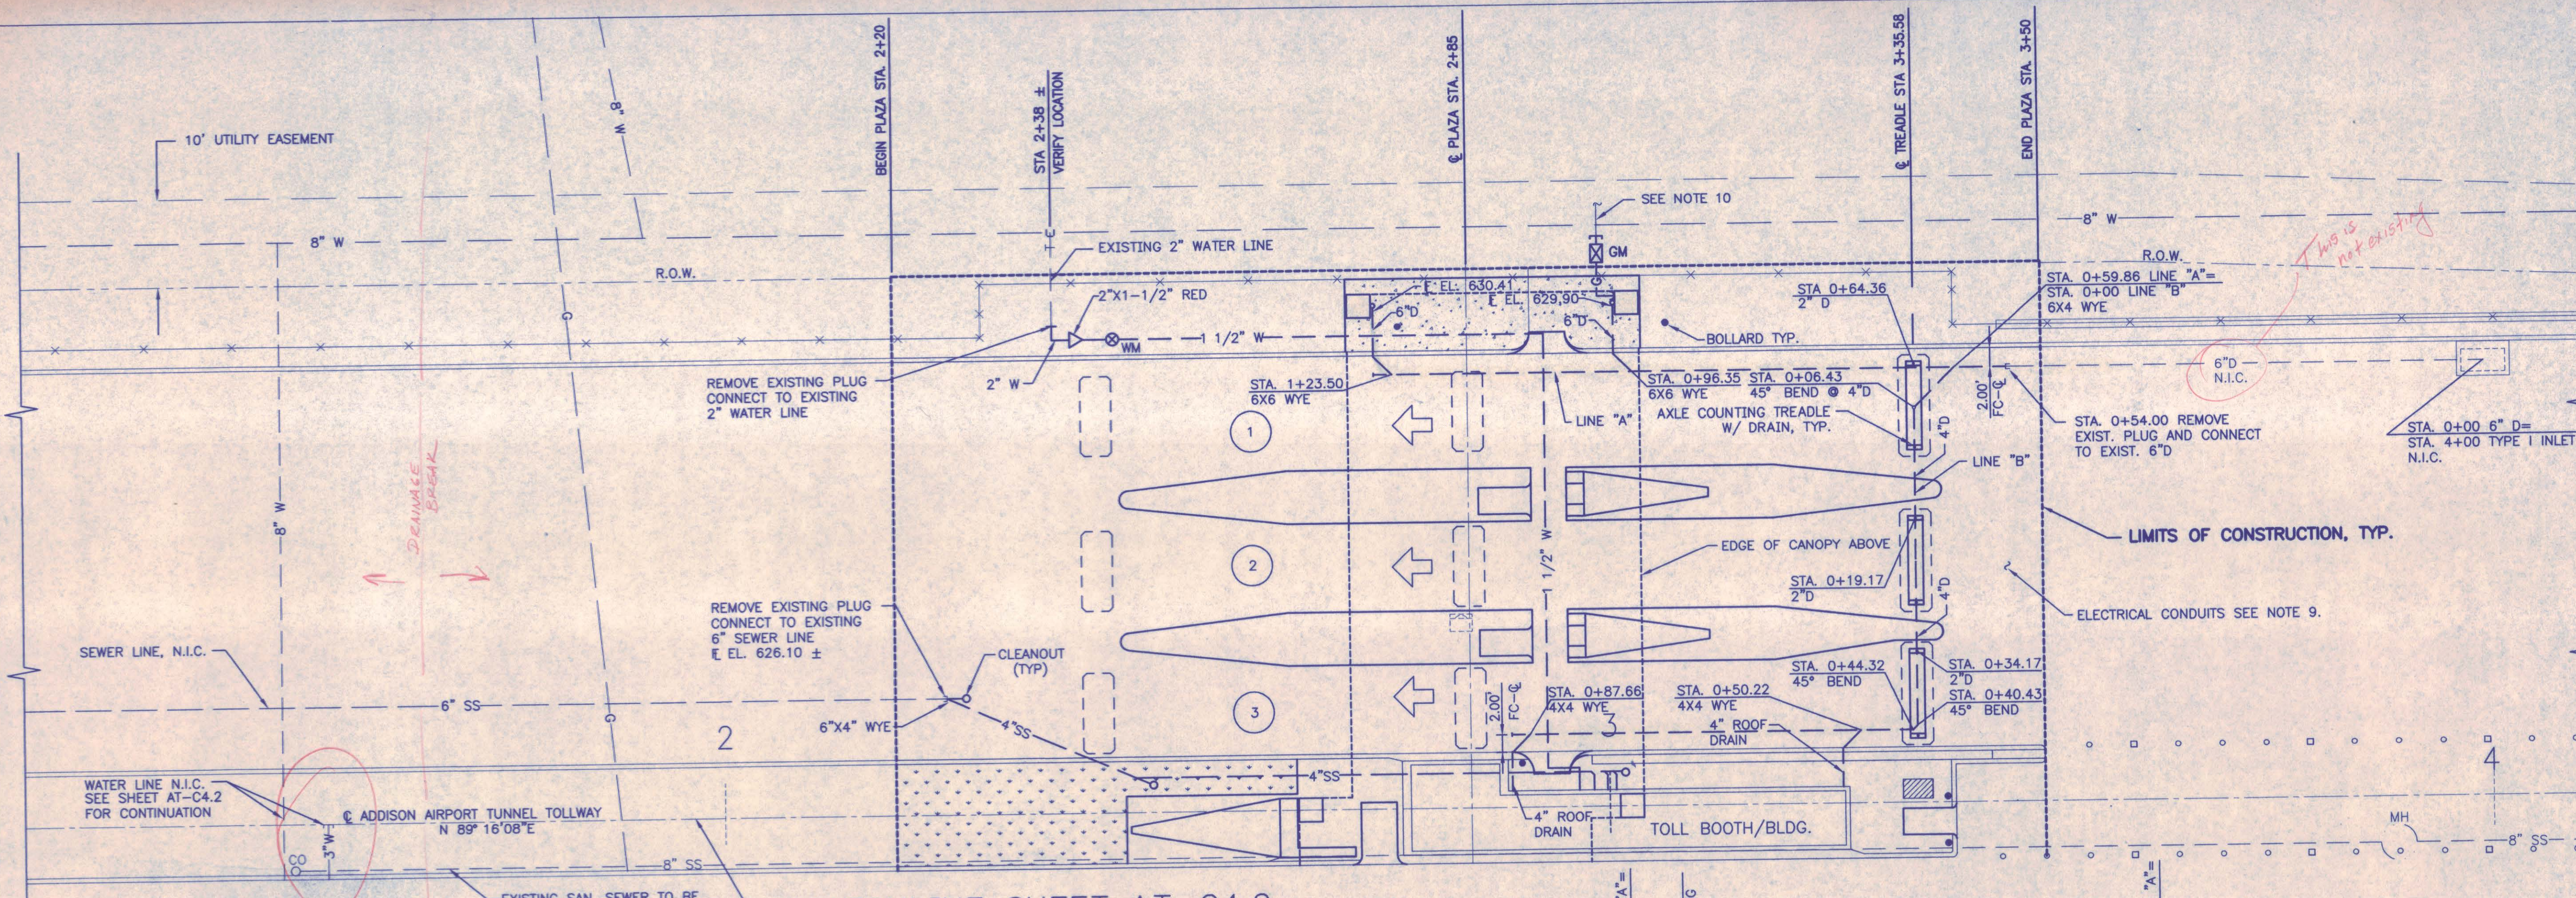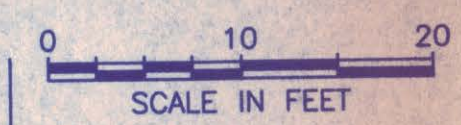


- LEGEND:**
- NEW**
- W — WATER LINE
 - SS — SANITARY SEWER LINE
 - D — DRAIN LINE
 - WM — WATER METER (WM)
 - GM — GAS METER (GM)
- EXISTING OR BY OTHERS**
- W-T — WATER LINE W/VALVE
 - G — GAS LINE
 - D — DRAIN LINE
 - SS — SANITARY SEWER LINE W/MH AND CO
- MH — MANHOLE

- NOTES:**
- SEE GENERAL NOTES ON SHEET AT-C1.1.
 - ALL WATER, SANITARY SEWER, AND DRAINAGE CONSTRUCTION SHALL CONFORM TO THE TOWN OF ADDISON STANDARDS, AND NORTH CENTRAL TEXAS COUNCIL OF GOVERNMENTS STANDARD SPECIFICATIONS FOR PUBLIC WORK CONSTRUCTION.
 - ALL WATER LINES SHALL BE TYPE K COPPER PIPE CONFORMING TO ASTM B88.
 - ALL SANITARY SEWER LINES AND DRAIN LINES SHALL BE SDR-35 PVC PIPE.
 - EMBODIMENT FOR ALL PVC SANITARY SEWER LINES AND DRAIN LINES SHALL BE CLASS 4 EMBEDMENT CONFORMING TO TOWN OF ADDISON STANDARD CONSTRUCTION DETAILS.
 - CONTRACTOR SHALL PROVIDE SHEETING AND SHORING AS REQUIRED TO PROTECT EXISTING UTILITIES AND STRUCTURES.
 - PROVIDE A MINIMUM OF 3' COVER FOR ALL UTILITIES UNLESS OTHERWISE NOTED.
 - REFER TO PLUMBING DRAWINGS FOR CONTINUATION OF WATER AND SANITARY SEWER LINES TO TOLL BOOTH BUILDING.
 - REFER TO ELECTRICAL DRAWINGS FOR ELECTRICAL CONDUIT LOCATIONS.
 - CONNECTION TO EXISTING GAS LINE WILL BE PROVIDED BY LONE STAR GAS. THE CONTRACTOR SHALL COORDINATE WITH LONE STAR GAS TO DETERMINE THE EXACT LOCATION OF THE SERVICE BEYOND THE METER.
 - GAS METER AND REGULATOR TO PROVIDE 30 CFH AT MEDIUM PRESSURE 2 PSI TO 1.5 PSI.

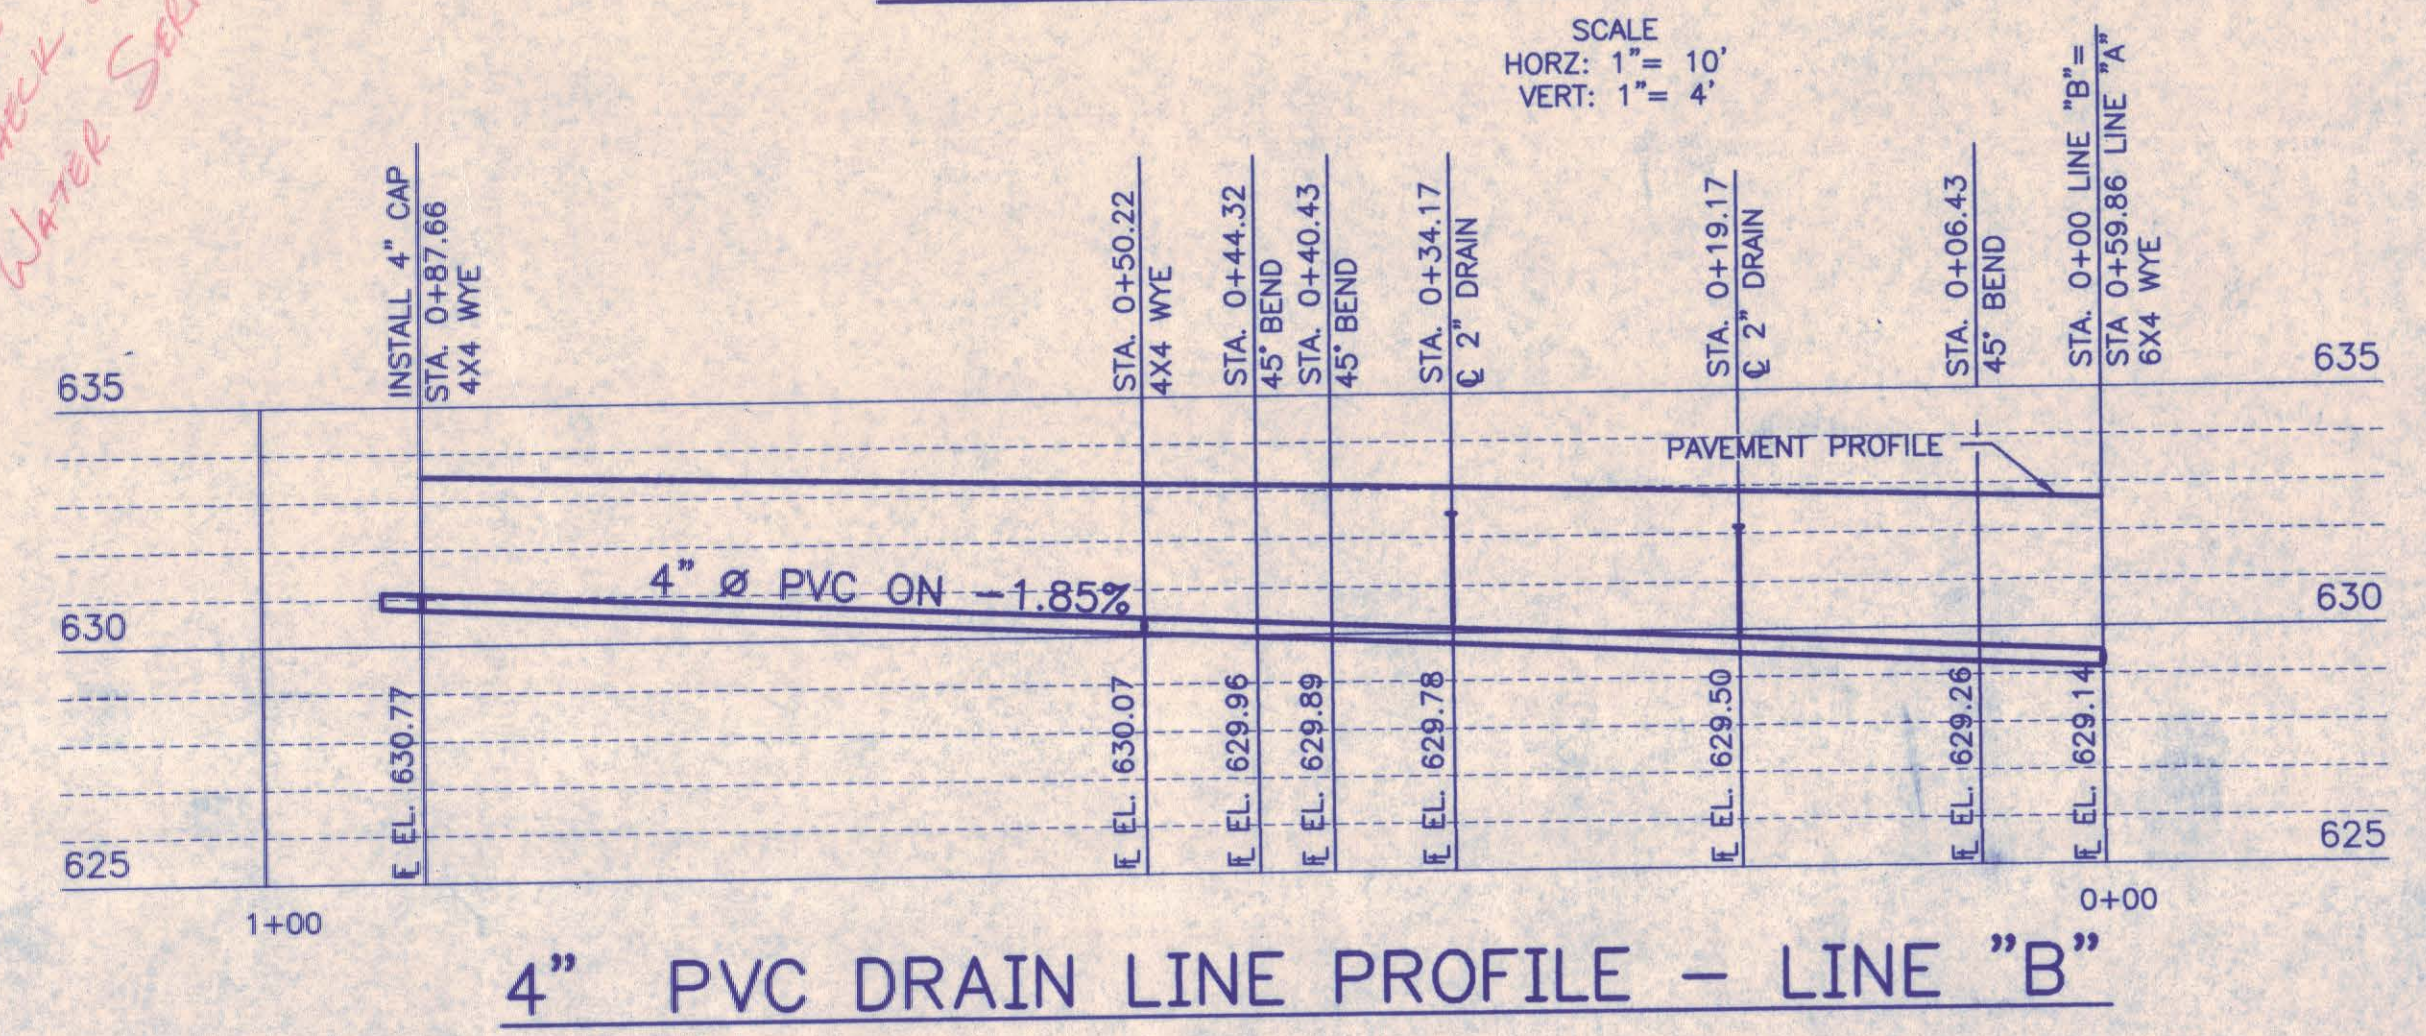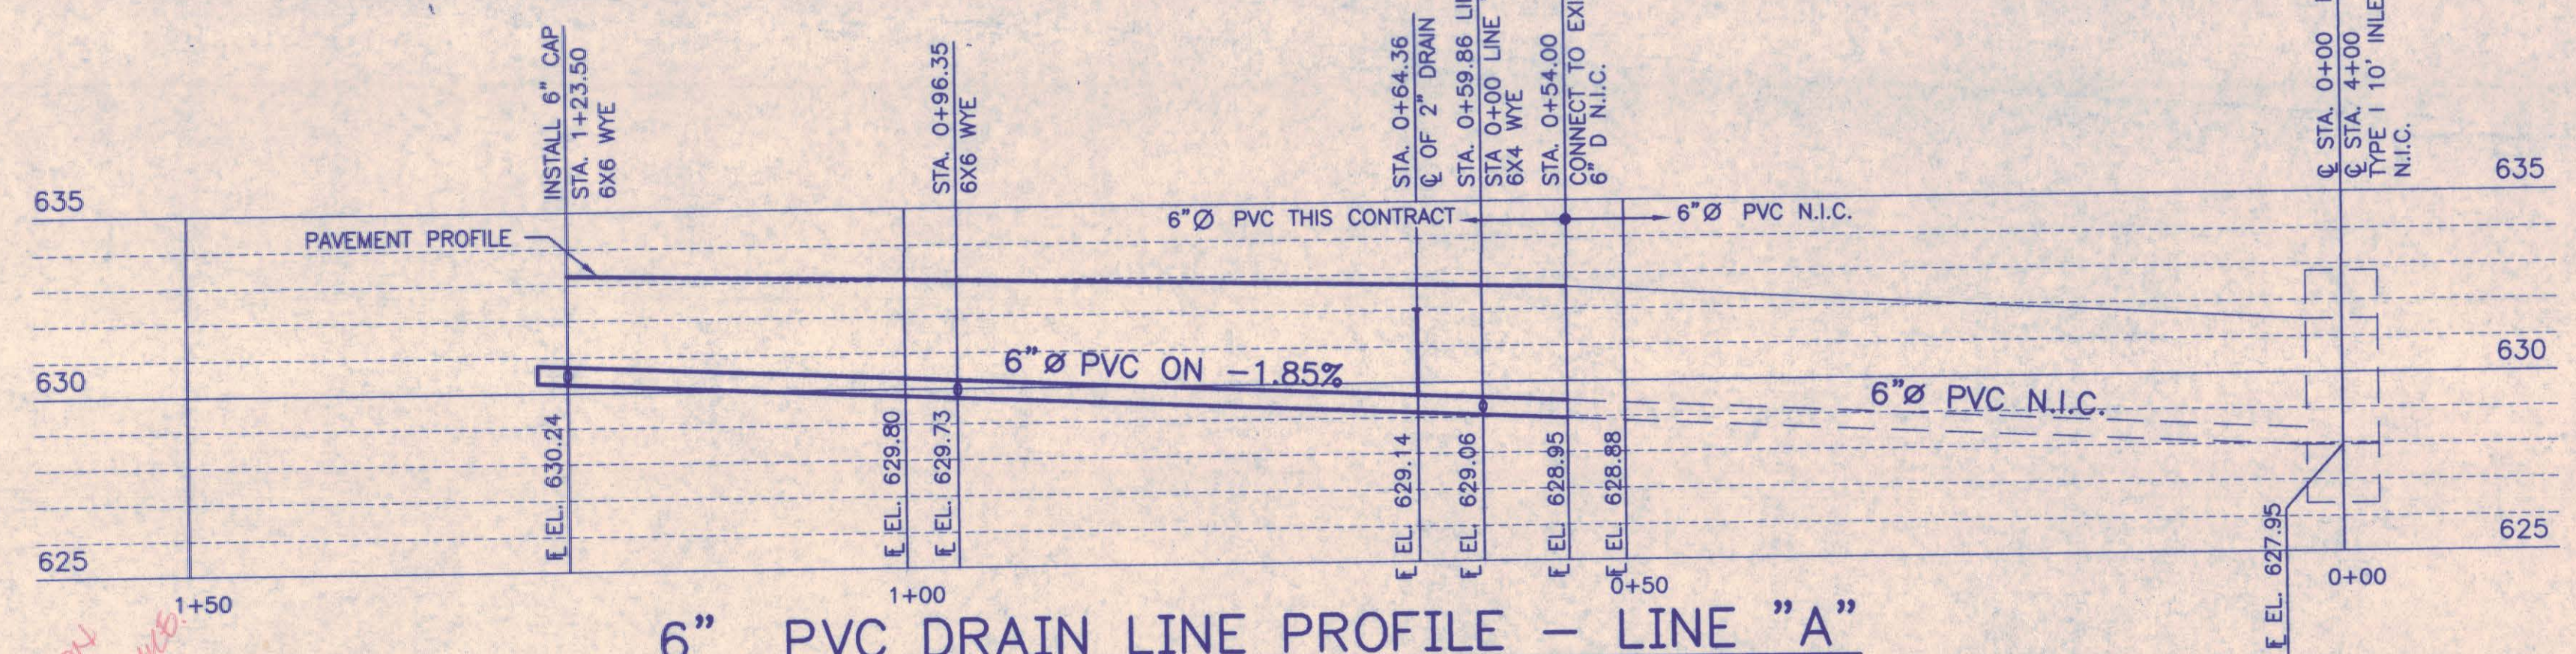

Double check on Water Service

Chiang, Patel & Yerby, Inc.
Consulting Engineers • Planners • Project Managers
Dallas • Fort Worth • Houston • San Antonio

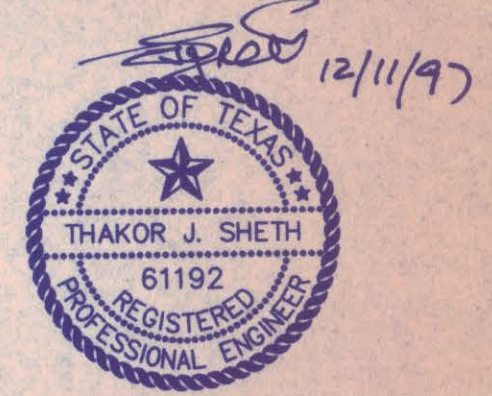

NO.		REVISION		BY	DATE
NORTH TEXAS TOLLWAY AUTHORITY ADDISON AIRPORT TUNNEL					
UTILITY PLAN AND PROFILE A					
DRAWN WAB		DATE 8/28/97		DESIGNED WAB DATE 12/20/96	
CHECKED TJS		DATE 11/5/97		SCALE 1"=10'-0"	
CONTRACT NO. DNT-290		SHEET 9		OF 53	


SECTION XIII

AT-C4.1



0 10 20
SCALE IN FEET

MATCH LINE SHEET AT-C4.1

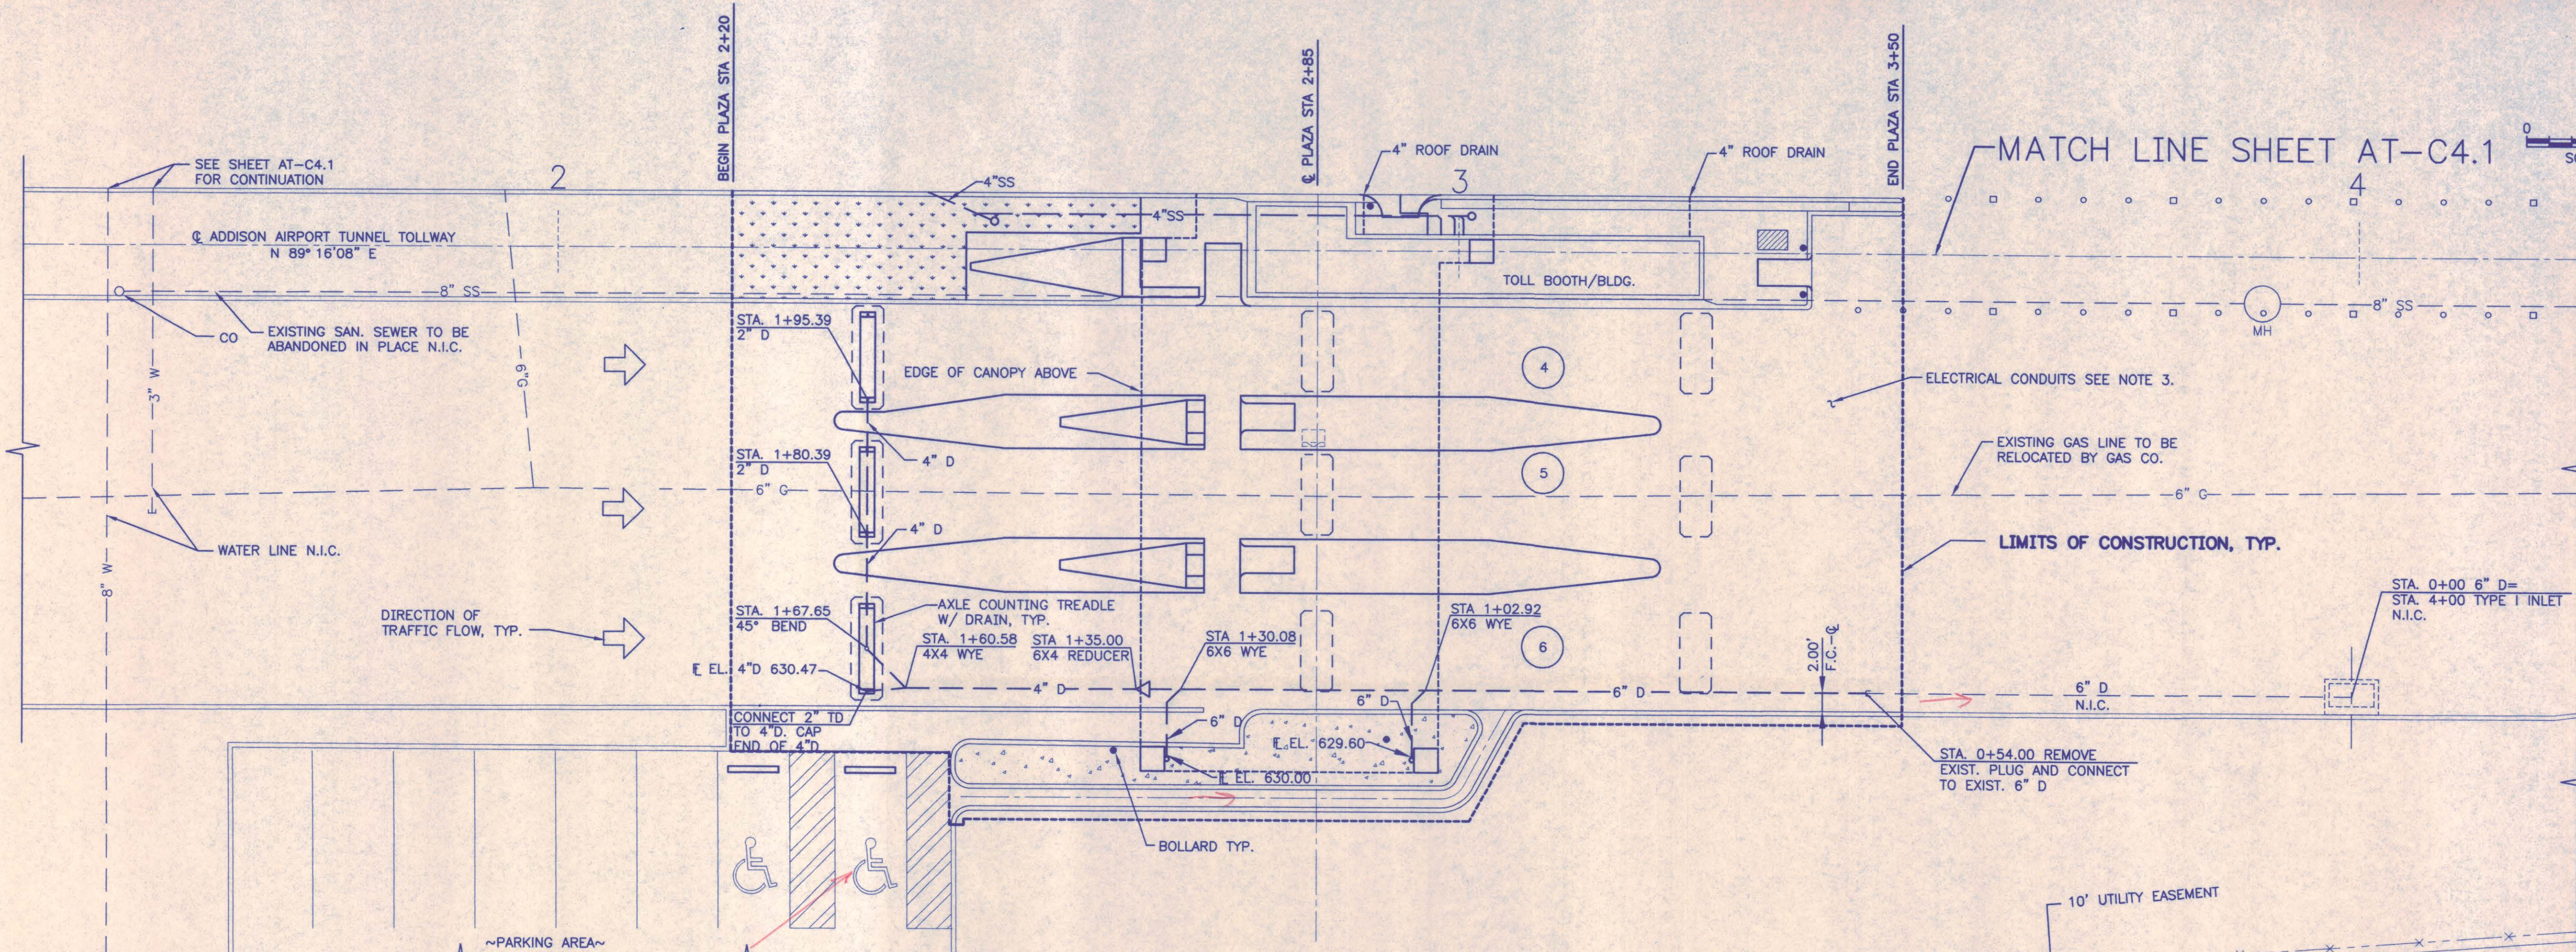

NOTES:

1. SEE GENERAL NOTES ON SHEET AT-C1.1.
2. ALL WATER, SANITARY SEWER, AND DRAINAGE CONSTRUCTION SHALL CONFORM TO THE TOWN OF ADDISON STANDARDS, AND NORTH CENTRAL TEXAS COUNCIL OF GOVERNMENTS STANDARD SPECIFICATION FOR PUBLIC WORK CONSTRUCTION.
3. REFER TO ELECTRICAL DRAWINGS FOR ELECTRICAL CONDUIT LOCATIONS.
4. REFER TO PLUMBING DRAWINGS FOR CONTINUATION OF WATER AND SEWER LINE TO TOLL BOOTH/BUILDING.
5. DRAIN SHALL BE SDR-35 PVC PIPE. EMBEDMENT FOR PVC DRAIN LINES SHALL BE CLASS 4 EMBEDMENT CONFORMING TO TOWN OF ADDISON STANDARD CONSTRUCTION DETAILS.
6. CONTRACTOR SHALL PROVIDE SHEETING AND SHORING AS REQUIRED TO PROTECT EXISTING UTILITIES AND STRUCTURES.

LEGEND:

NEW



— W — WATER LINE
— G — GAS LINE
— SS — SANITARY SEWER LINE
— D — DRAIN LINE

EXISTING OR BY OTHER

— W-T — WATER LINE W/VALVE
— G — GAS LINE
— D — DRAIN LINE
— SS — SANITARY SEWER LINE W/MH AND CO

DRAIN LINE PROFILE

SCALE
HORZ: 1" = 10'
VERT: 1" = 4'

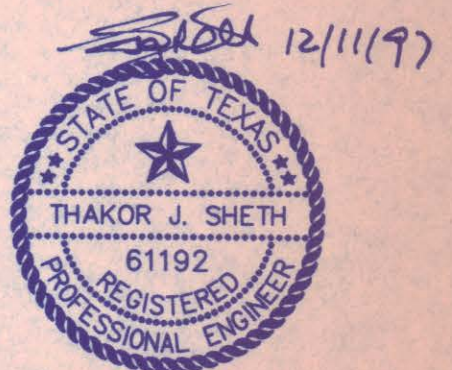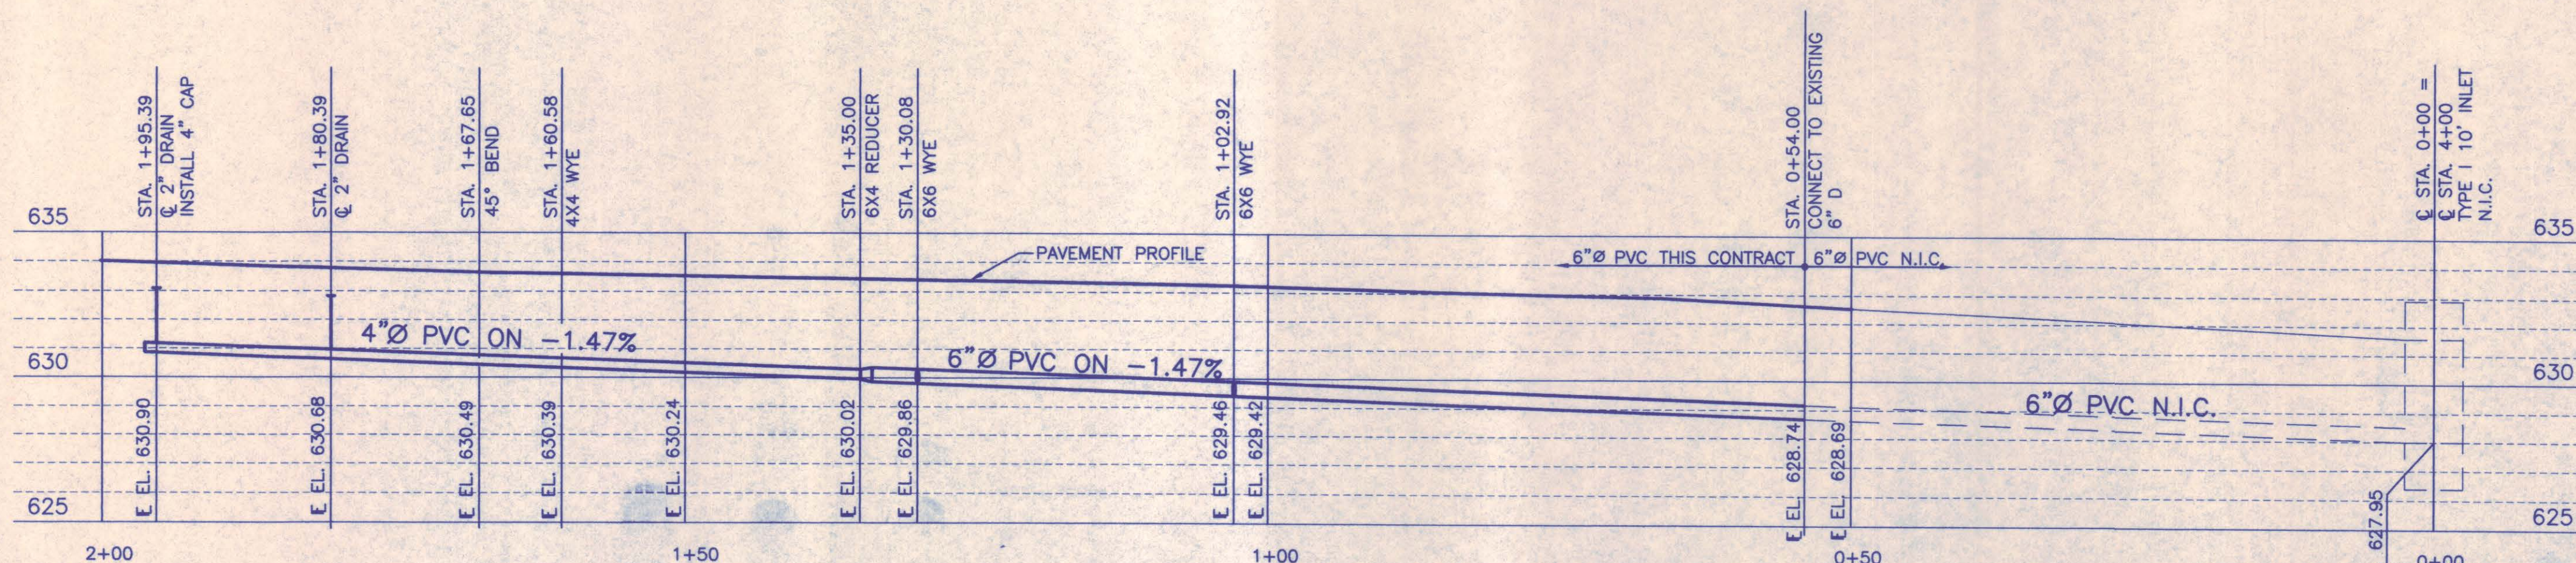



NO.	REVISION	BY	DATE
NORTH TEXAS TOLLWAY AUTHORITY ADDISON AIRPORT TUNNEL			
UTILITY PLAN AND PROFILE B			
DRAWN WAB		DATE 8/28/97	DESIGNED WAB
CHECKED TJS		DATE 11/5/97	SCALE 1"=10'-0"
CONTRACT NO. DNT-290		SHEET 10 OF 53	

AGUIRRE ASSOCIATES INC
12700 PARK CENTRAL DRIVE
15 TH FLOOR
DALLAS, TEXAS 75261
TEL 972 788-1508


SECTION XIII

Chiang, Patel & Yerby, Inc.
Consulting Engineers • Planners • Project Managers
Dallas • Fort Worth • Houston • San Antonio

AT-C4.2

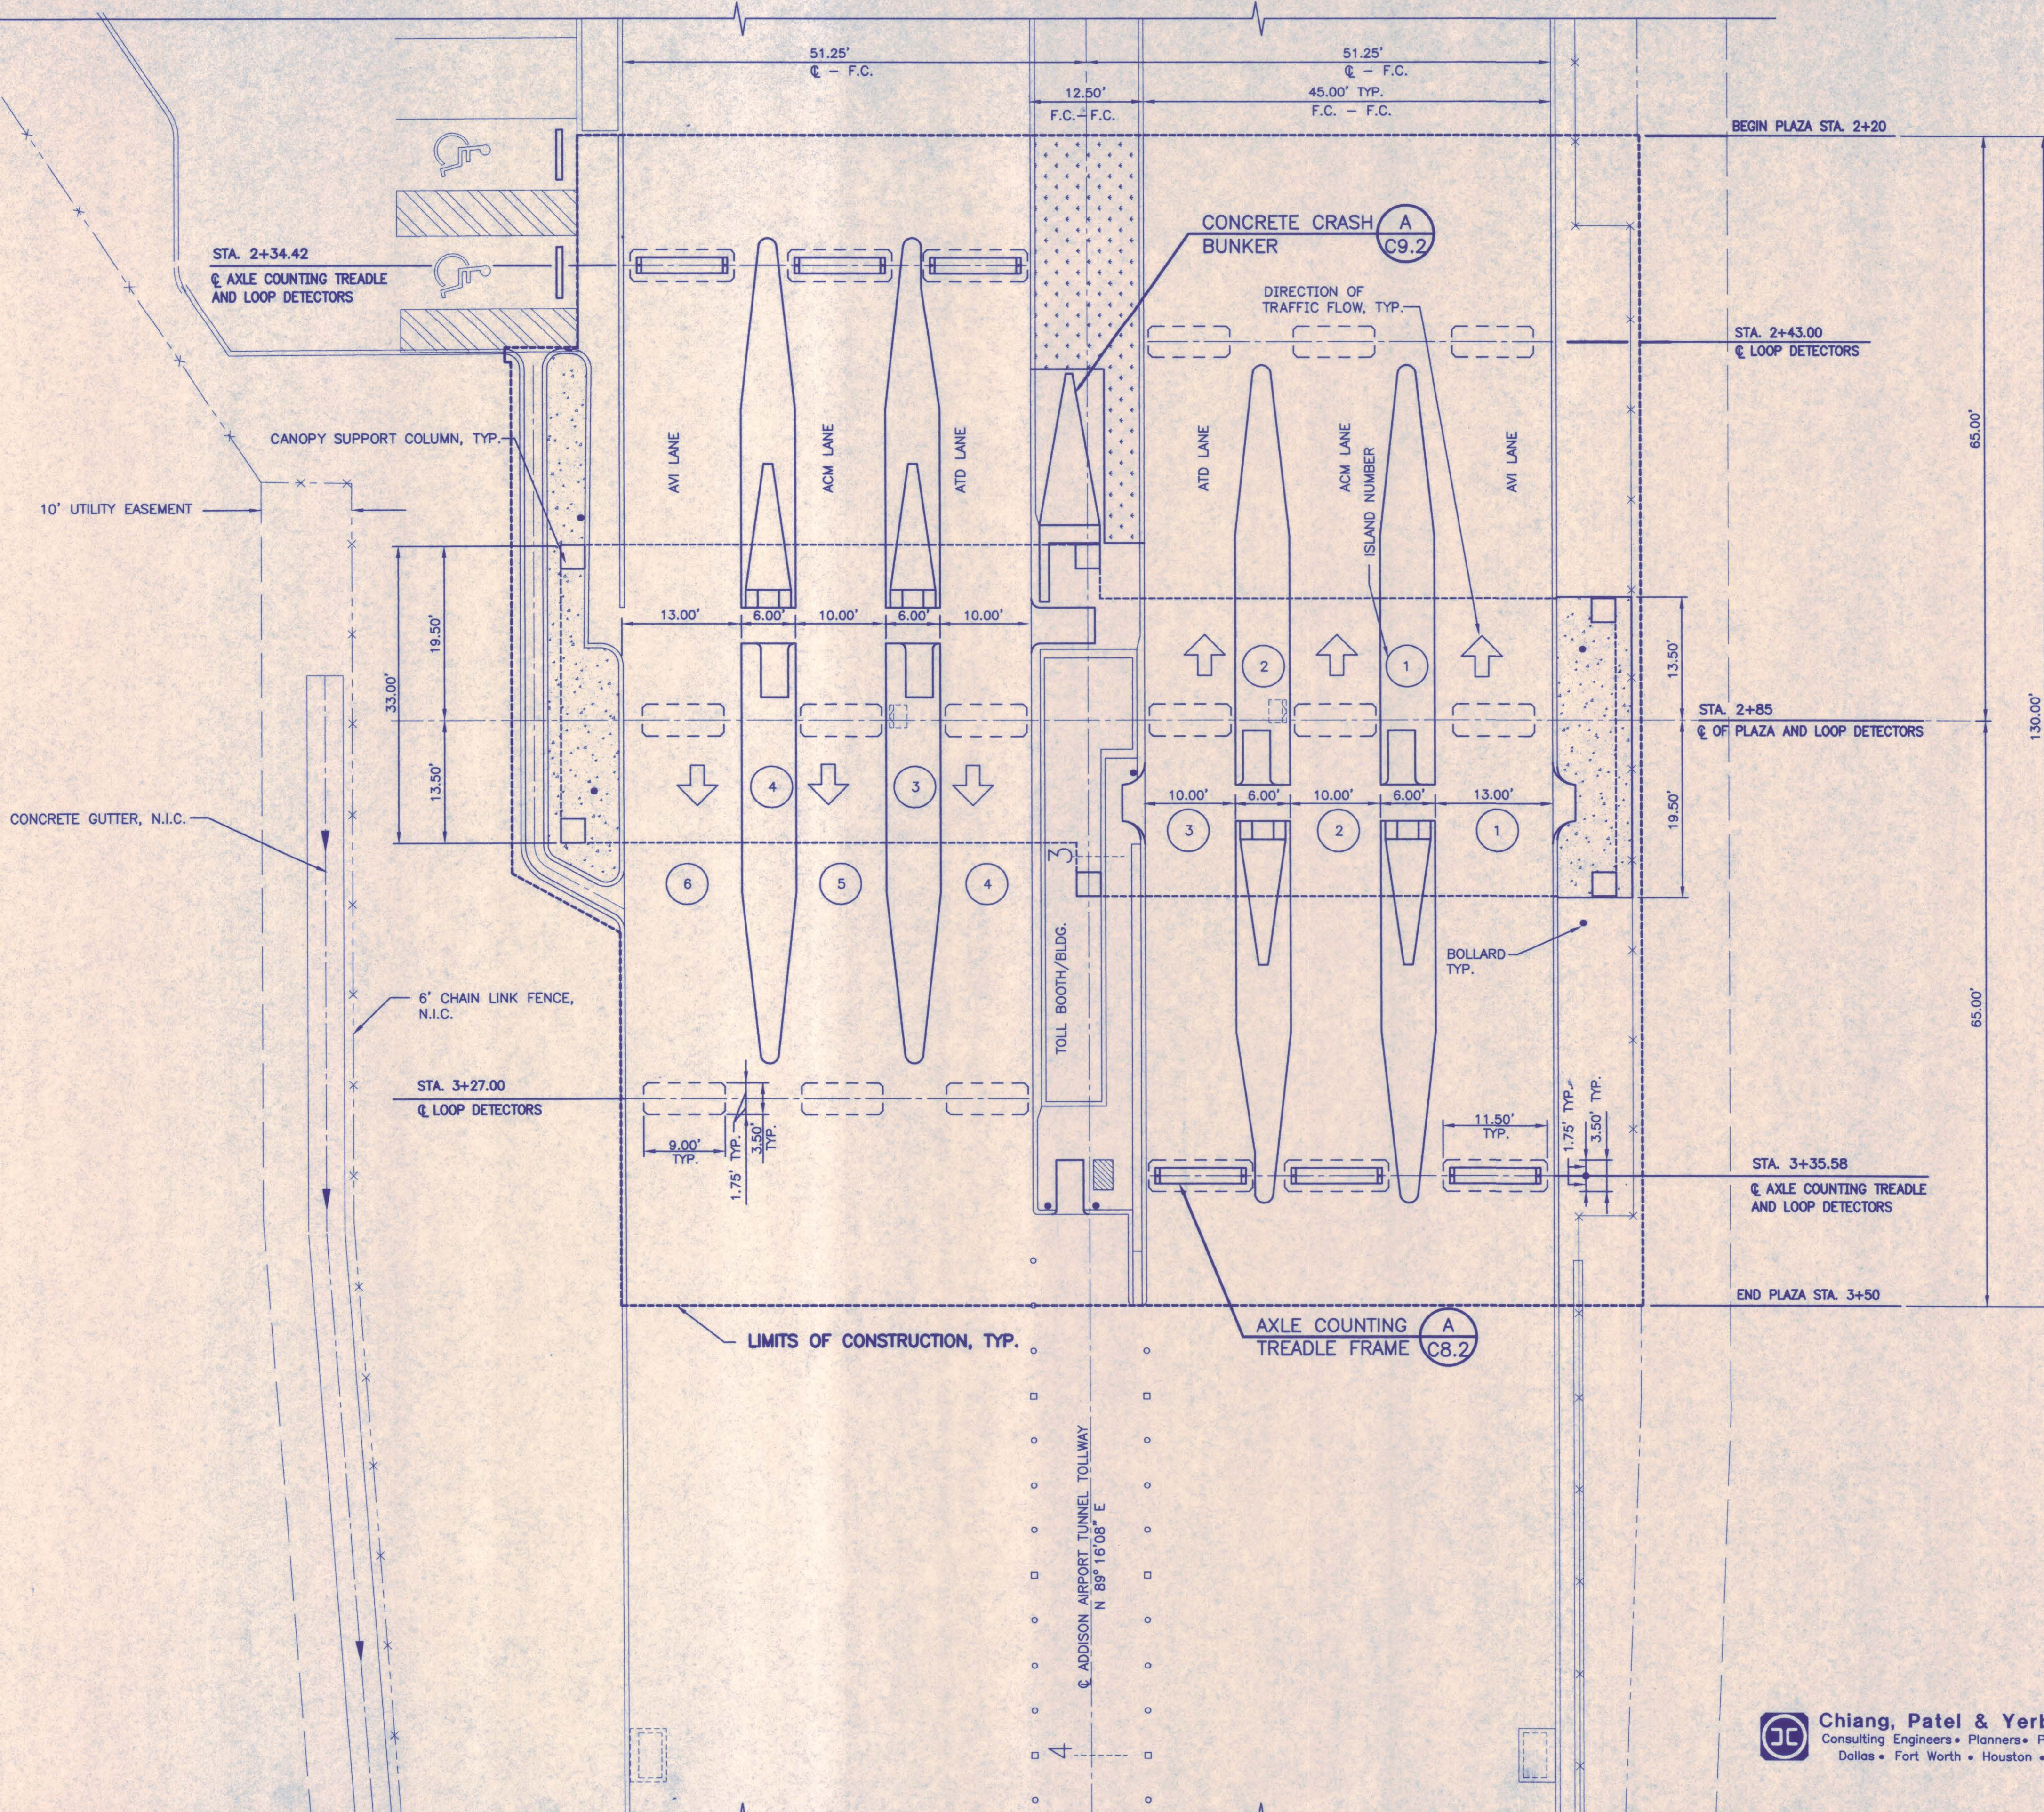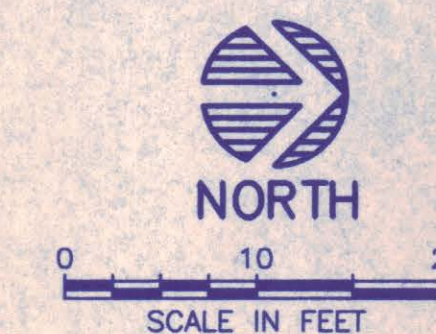

- NOTES:
1. SEE GENERAL NOTES ON SHEET AT-C1.1.
 2. FOR ISLAND DETAILS SEE SHEETS AT-C7.1 AND AT-C7.2.
 3. FOR FURTHER INFORMATION ON THE TOLLBOOTH AND CANOPY STRUCTURES WITHIN THE MAIN PLAZA, SEE ARCHITECTURAL SHEETS AT-A2.1 AND STRUCTURAL SHEETS AT-S1.1
 4. FOR INFORMATION ON GRADING AND ELEVATIONS IN THE MAIN PLAZA SEE SHEETS AT-C3.1 AND AT-C3.2.

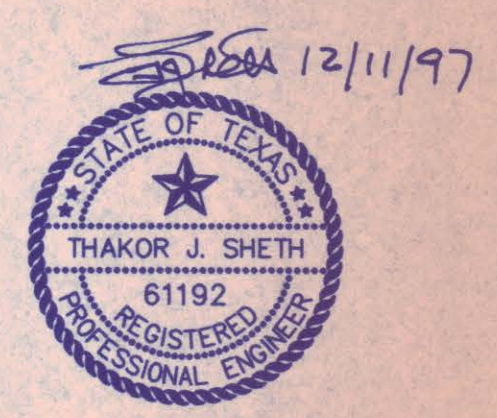


NO.	REVISION	BY	DATE
NORTH TEXAS TOLLWAY AUTHORITY ADDISON AIRPORT TUNNEL			
PLAZA PLAN			
AGUIRRE ASSOCIATES INC 12700 PARK CENTRAL DRIVE 15 TH FLOOR DALLAS TEXAS 75261 TEL (972) 788-1608			SECTION XIII
DRAWN WAB	DATE 8/28/97	DESIGNED WAB	DATE 12/20/96
CHECKED TJS	DATE 11/5/97	SCALE 1"=10'-0"	
CONTRACT NO. DNT-290 SHEET 11 OF 53			

Chiang, Patel & Yerby, Inc.
Consulting Engineers • Planners • Project Managers
Dallas • Fort Worth • Houston • San Antonio

AT-C5.1



0 10 20
SCALE IN FEET

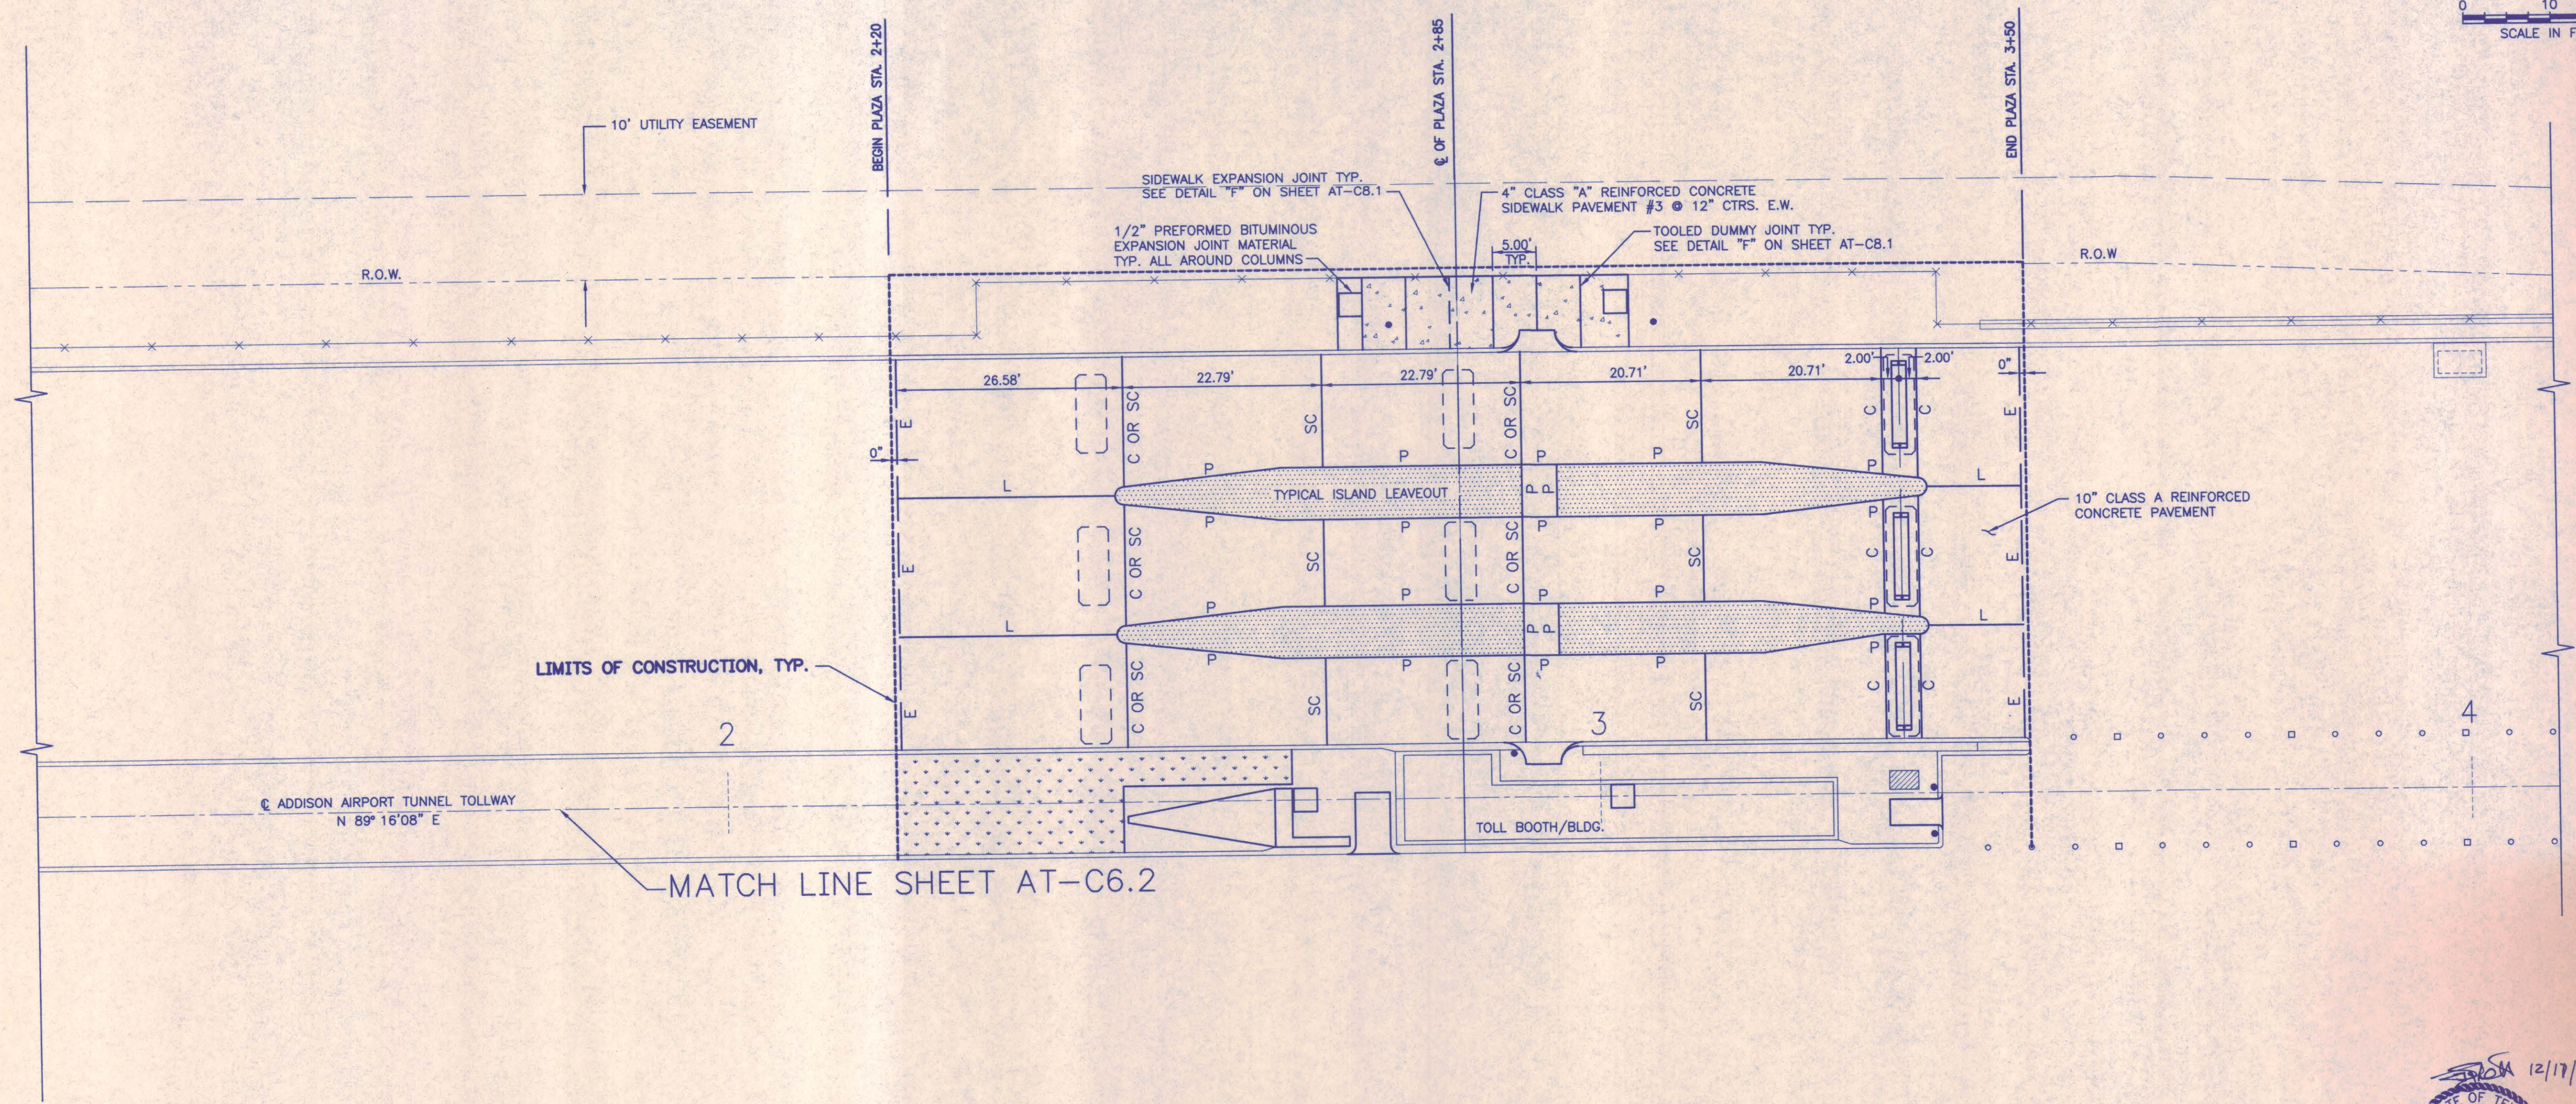


LEGEND:

	E	EXPANSION JOINT
	L	LONGITUDINAL CONSTRUCTION JOINT
	C	CONSTRUCTION JOINT
	SC	CONTRACTION JOINT
	P	PLAZA JOINT
	S	SAWED DUMMY JOINT
		DENOTES ISLAND LEAVEOUT

NOTE:

1. SEE GENERAL NOTES ON SHEET AT-C1.1.

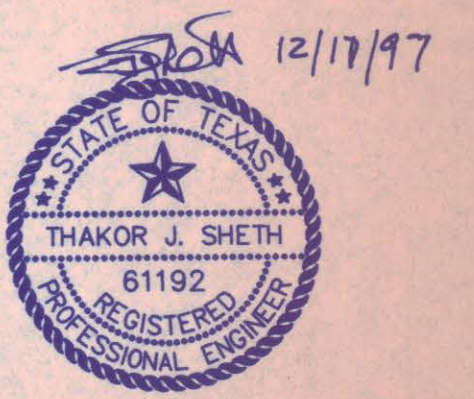

NO.	REVISION	BY	DATE
NORTH TEXAS TOLLWAY AUTHORITY ADDISON AIRPORT TUNNEL			
PAVEMENT JOINTING PLAN A			
AGUIRRE ASSOCIATES INC 12700 PARK CENTRAL DRIVE 15 TH FLOOR DALLAS TEXAS 75251 TEL (972) 788-1508		SECTION XIII	
DRAWN	WAB	DATE	8/28/97
CHECKED	TJS	DATE	11/5/97
DESIGNED	WAB	DATE	12/20/96
SCALE		1"=10'-0"	
CONTRACT NO.		DNT-290	
SHEET		12 OF 53	

Chiang, Patel & Yerby, Inc.
Consulting Engineers • Planners • Project Managers
Dallas • Fort Worth • Houston • San Antonio

AT-C6.1

132211M AT-C6.1.DWG



0 10 20
SCALE IN FEET

MATCH LINE SHEET AT-C6.1

BEGIN PLAZA STA 2+20

Q OF PLAZA STA 2+85

END PLAZA STA 3+50

ADDISON AIRPORT TUNNEL TOLLWAY
N 89° 16' 08" E

EXPANSION JOINT
(TYP. @ EACH END)

EXPANSION JOINT
SEE NOTE 2.

TOLL BOOTH/BLDG.

TYPICAL ISLAND LEAVEOUT

10" CLASS A REINFORCED
CONCRETE PAVEMENT

LIMITS OF CONSTRUCTION

EXPANSION JOINT MATERIAL
SEE NOTE 2.

TOOLED DUMMY JOINT, TYP.
SEE DETAIL "F" ON SHEET AT-C8.1

SIDEWALK EXPANSION JOINT, TYP.
SEE DETAIL "F" ON SHEET AT-C8.1

4" CLASS "A" NON-REINFORCED
CONCRETE SIDEWALK PAVEMENT

4" CLASS "A" REINFORCED CONCRETE
SIDEWALK PAVEMENT #3 @ 12" CTRS. E.W.

6' CHAIN LINK FENCE, N.I.C.

CONCRETE GUTTER, N.I.C.

10' UTILITY EASEMENT

PARKING AREA

LEGEND:

E	EXPANSION JOINT
L	LONGITUDINAL CONSTRUCTION JOINT
C	CONSTRUCTION JOINT
SC	CONTRACTION JOINT
P	PLAZA JOINT
S	SAWED DUMMY JOINT
[Pattern]	DENOTES ISLAND LEAVEOUT

NOTES:

1. SEE GENERAL NOTES ON SHEET AT-C1.1.
2. PROVIDE 1/2" PREFORMED BITUMINOUS EXPANSION JOINT MATERIAL ALONG THE BACK OF CURB, ALONG PARKING AREA PAVEMENT AND AROUND THE STRUCTURAL COLUMNS FOR THE CANOPY.








NO.	REVISION	BY	DATE
NORTH TEXAS TOLLWAY AUTHORITY ADDISON AIRPORT TUNNEL			
PAVEMENT JOINTING PLAN B			
AGUIRRE ASSOCIATES INC 12700 PARK CENTRAL DRIVE 16 TH FLOOR DALLAS TEXAS 75251 TEL (972) 788-1608		SECTION XIII	
DRAWN	WAB	DATE	8/28/97
CHECKED	TJS	DATE	11/5/97
DESIGNED	WAB	DATE	12/20/96
SCALE	1"=10'-0"		
CONTRACT NO.	DNT-290	SHEET	13 OF 53



Chiang, Patel & Yerby, Inc.
Consulting Engineers • Planners • Project Managers
Dallas • Fort Worth • Houston • San Antonio


AT-C6.2

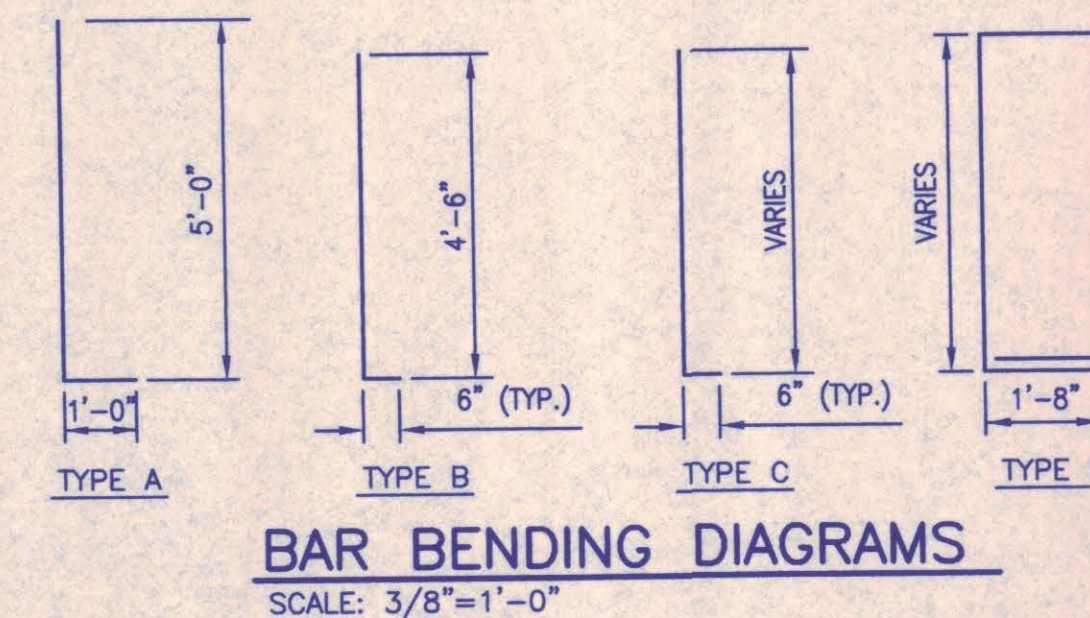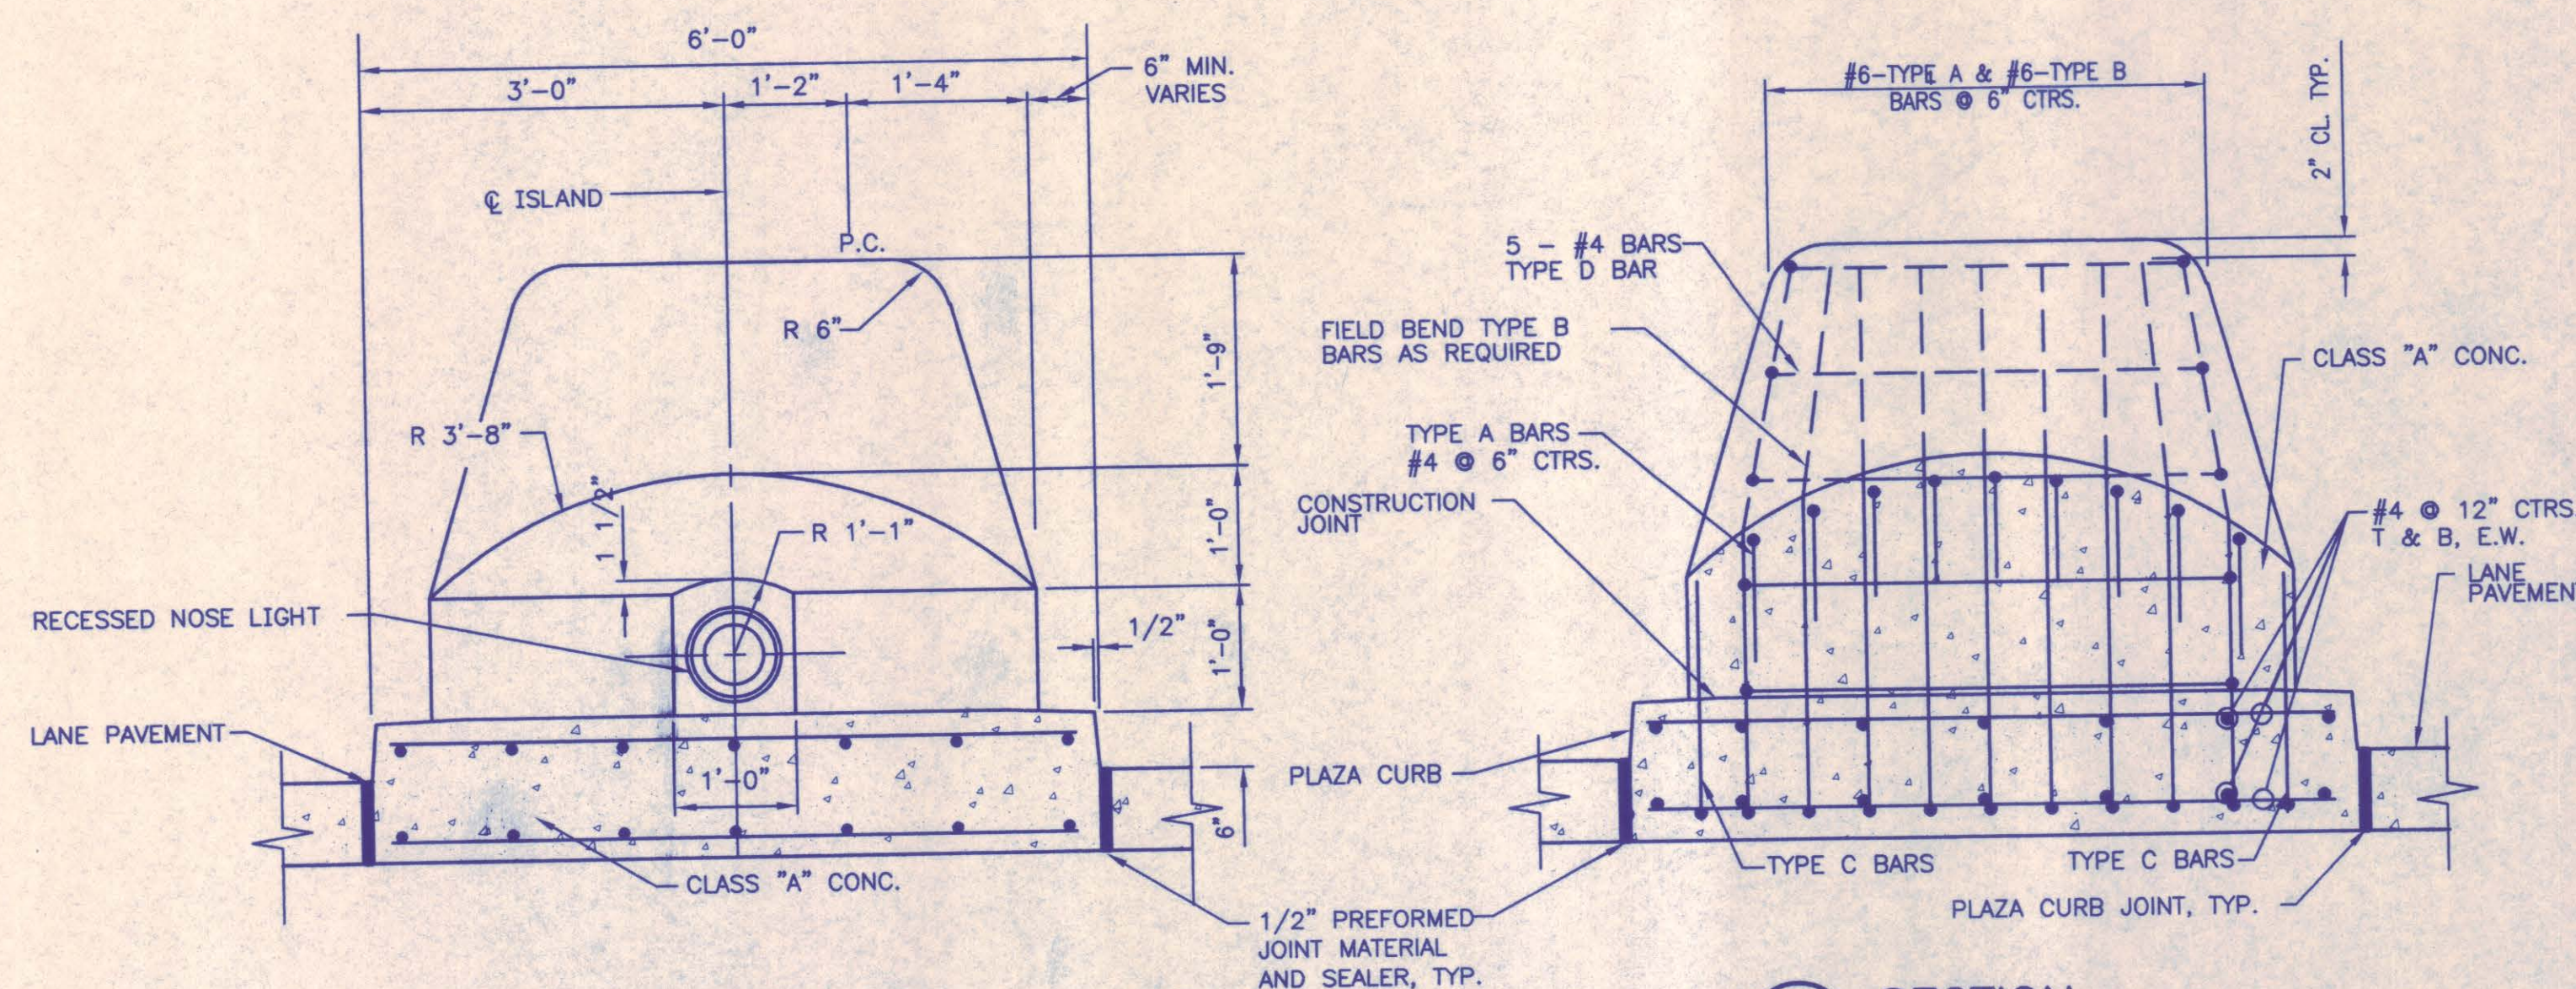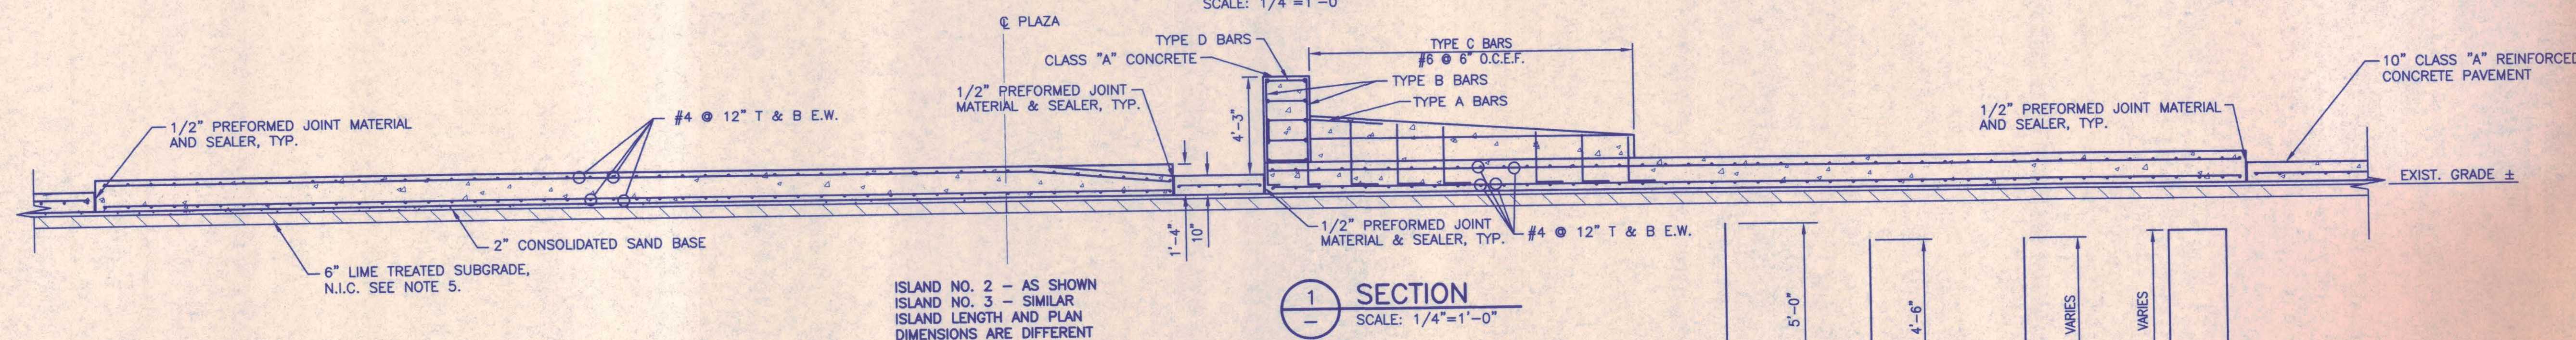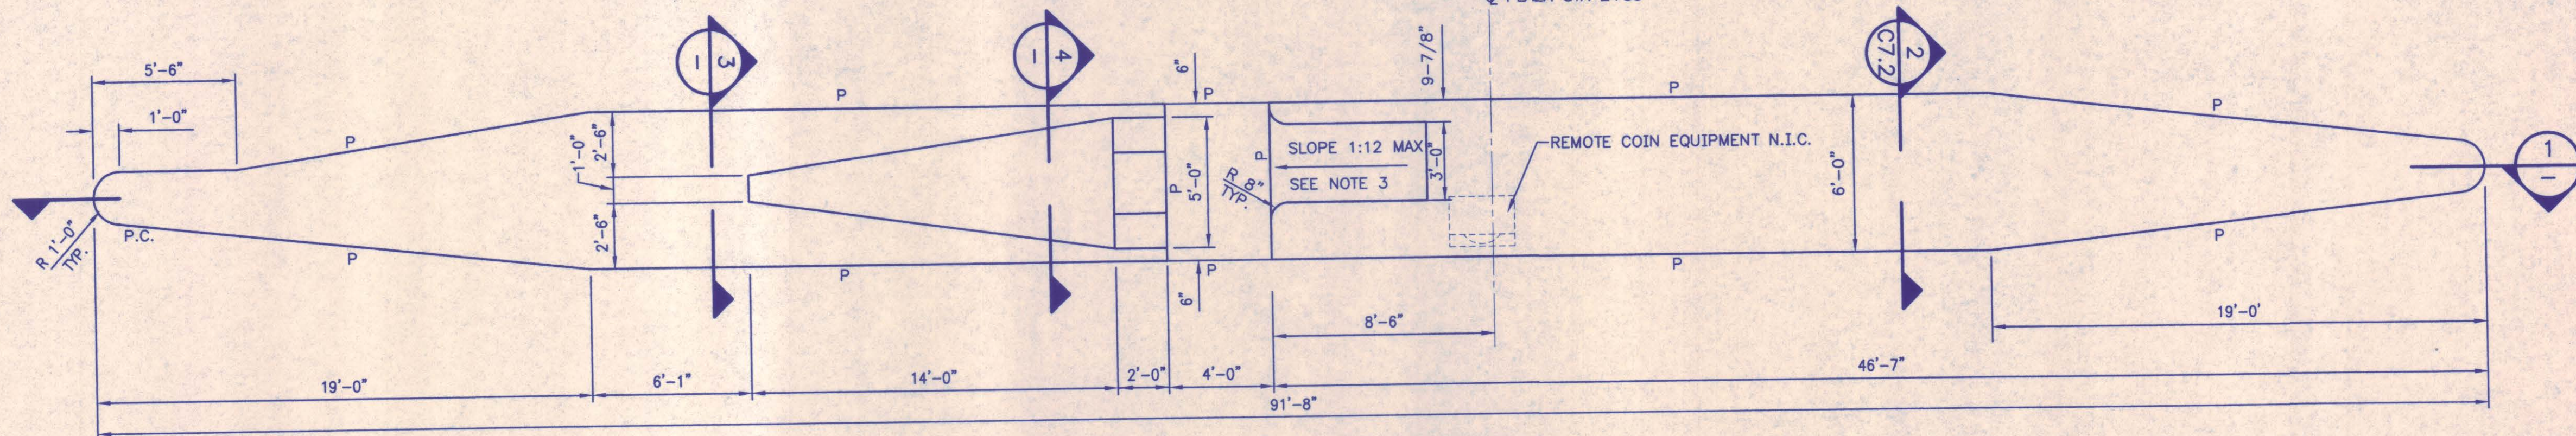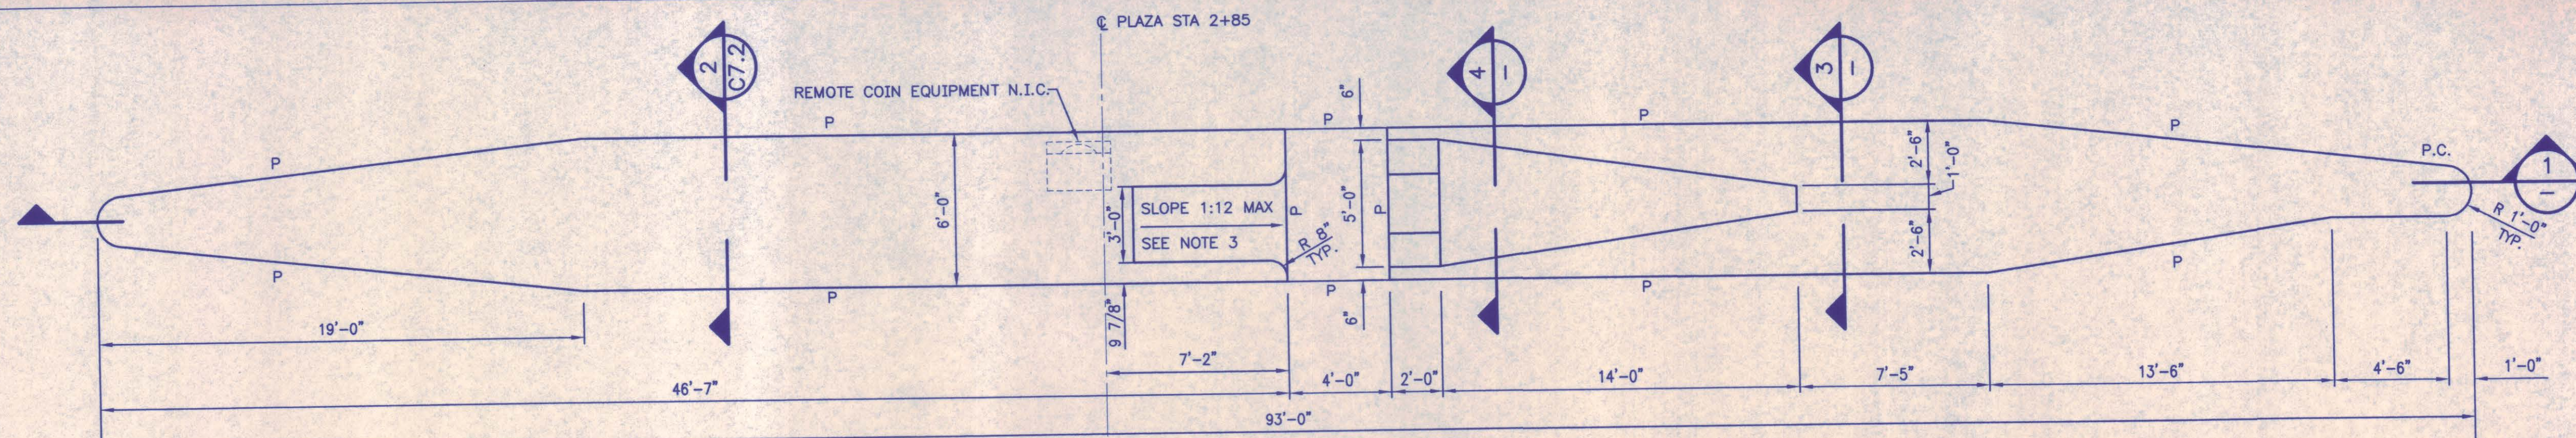

NOTES:


- FOR FURTHER INFORMATION ON THE LOCATION AND TYPE OF ELECTRICAL UTILITIES AND APPURTENANCES WITHIN THE MAIN PLAZA, SEE ELECTRICAL DRAWINGS.
- FOR FURTHER INFORMATION ON THE TOLLBOOTH BLDG. AND CANOPY STRUCTURES WITHIN THE MAIN PLAZA, SEE STRUCTURAL AND ARCHITECTURAL DRAWINGS.
- ALL ACCESS RAMPS EXCEPT RAMPS AT THE NORTH CANOPY COLUMNS AND NORTH OF THE TOLL BOOTH SHALL BE CONSTRUCTED IN ACCORDANCE WITH ADA ACCESSIBILITY GUIDELINES FOR BUILDINGS AND FACILITIES. RAMP SURFACE AREA SHALL BE COVERED WITH DETECTABLE WARNINGS AS DESCRIBED IN THESE STANDARDS.
- SEE GENERAL NOTES ON SHEET AT-C1.1.
- LIME TREATMENT OF SUBGRADE WITHIN AND ADJACENT TO THE PLAZA CONSTRUCTION LIMITS HAS PREVIOUSLY BEEN LIME TREATED AND STABILIZED BY OTHERS. IF THAT LIME STABILIZED SUBGRADE SUBSEQUENTLY IS DAMAGED BY THE CONTRACTOR'S CONSTRUCTION OPERATIONS, THE SUBGRADE SHALL BE REPAIRED WITH AVAILABLE STOCKPILED LIME TRIMMINGS OR WITH LIME SLURRY AS DIRECTED BY THE ENGINEER.

Chiang, Patel & Yerby, Inc.
Consulting Engineers • Planners • Project Managers
Dallas • Fort Worth • Houston • San Antonio

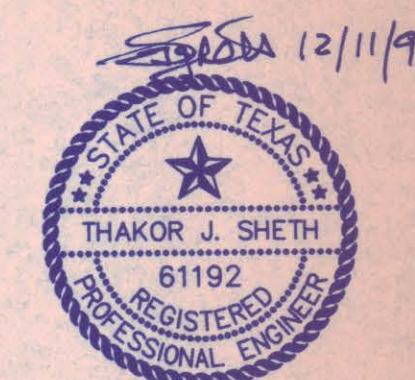


NO.	REVISION	BY	DATE
NORTH TEXAS TOLLWAY AUTHORITY ADDISON AIRPORT TUNNEL			
TYPICAL ISLAND PLANS, SECTIONS AND DETAILS I			
AGUIRRE ASSOCIATES INC. 12700 PARK CENTRAL DRIVE 15 TH FLOOR DALLAS TEXAS 75251 TEL (972) 788-1508		SECTION XIII	
DRAWN WAB	DATE 8/28/97	DESIGNED WAB	DATE 12/20/96
CHECKED TJS	DATE 11/5/97	SCALE AS SHOWN	
CONTRACT NO. DNT-290		SHEET 14 OF 53	


AT-C7.1

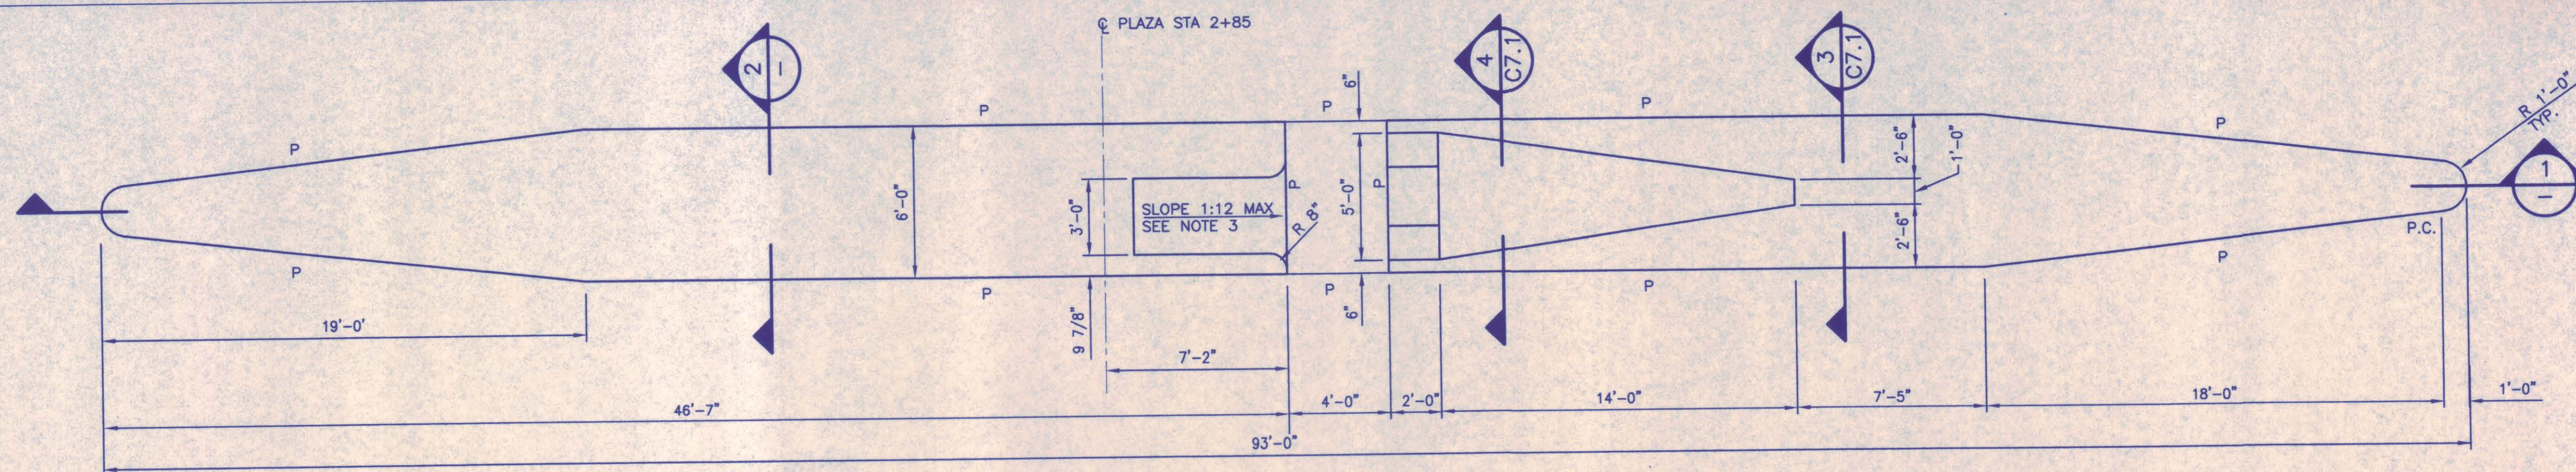

SCALE: $1/4"=1'-0"$

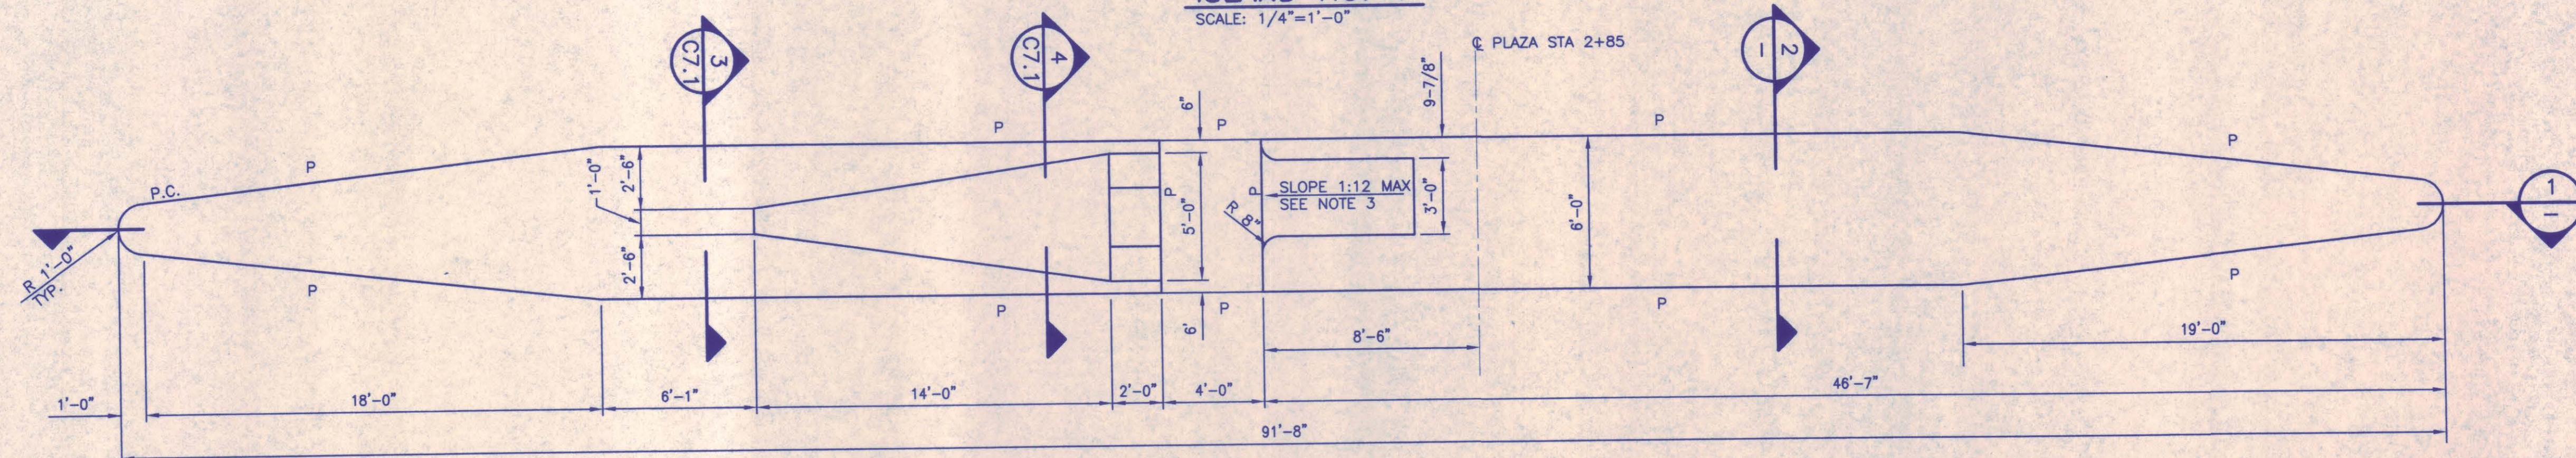


SCALE: $1/4"=1'-0"$

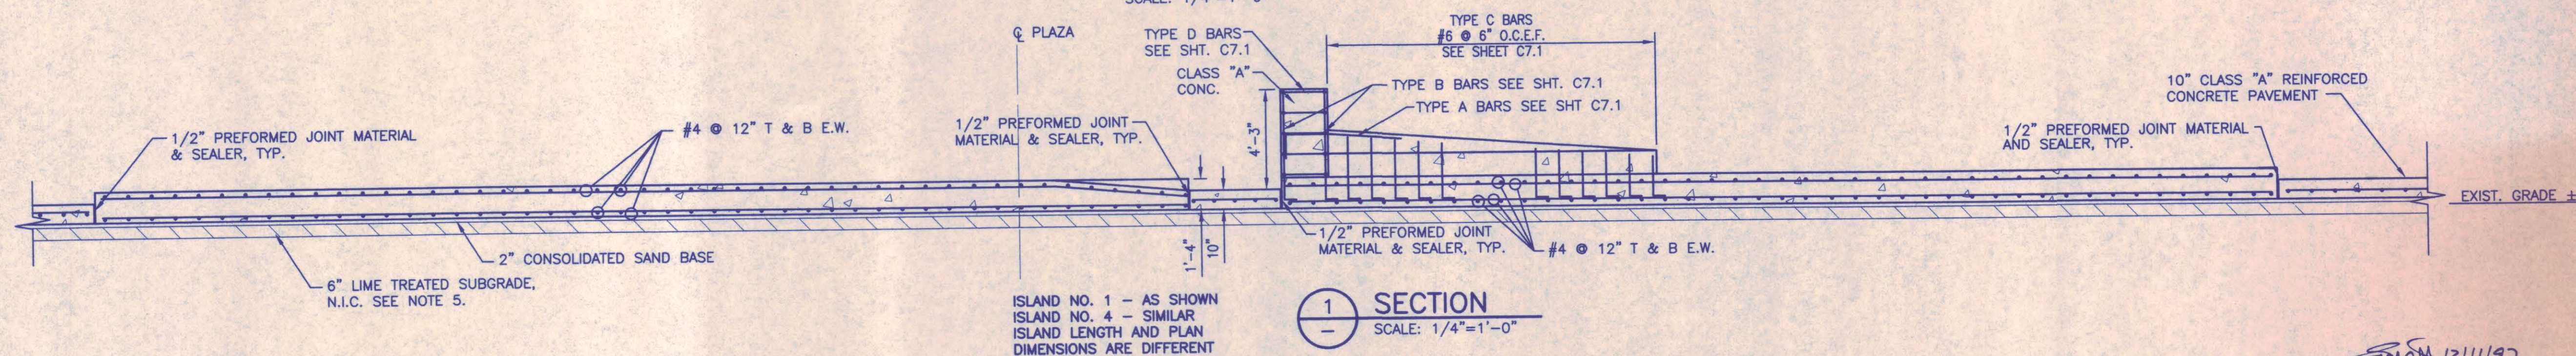


SCALE: $1/4"=1'-0"$

1. FOR FURTHER INFORMATION ON THE LOCATION AND TYPE OF ELECTRICAL UTILITIES AND APPURTENANCES WITHIN THE MAIN PLAZA, SEE ELECTRICAL DRAWINGS.
2. FOR FURTHER INFORMATION ON THE TOLLBOOTH AND CANOPY STRUCTURES WITHIN THE BARRIER PLAZA, SEE STRUCTURAL AND ARCHITECTURAL DRAWINGS.
3. ALL ACCESS RAMPS EXCEPT RAMPS AT THE NORTH CANOPY COLUMNS AND NORTH OF THE TOLL BOOTH SHALL BE CONSTRUCTED IN ACCORDANCE WITH ADA ACCESSIBILITY GUIDELINES FOR BUILDINGS AND FACILITIES. RAMP SURFACE AREA SHALL BE COVERED WITH A DETECTABLE WARNINGS AS DESCRIBED IN THESE STANDARDS.
4. SEE GENERAL NOTES ON SHEET AT-C1.1.
5. THE LIME TREATED SUBGRADE WITHIN AND ADJACENT TO THE TOLL PLAZA CONSTRUCTION HAS PREVIOUSLY BEEN LIME TREATED AND STABILIZED BY OTHERS. IF THAT LIME STABILIZED SUBGRADE SUBSEQUENTLY IS DAMAGED BY THE CONTRACTOR'S CONSTRUCTION OPERATIONS, THE SUBGRADE SHALL BE REPAIRED WITH AVAILABLE STOCKPILED LIME TRIMMINGS OR WITH LIME SLURRY AS DIRECTED BY THE ENGINEER.

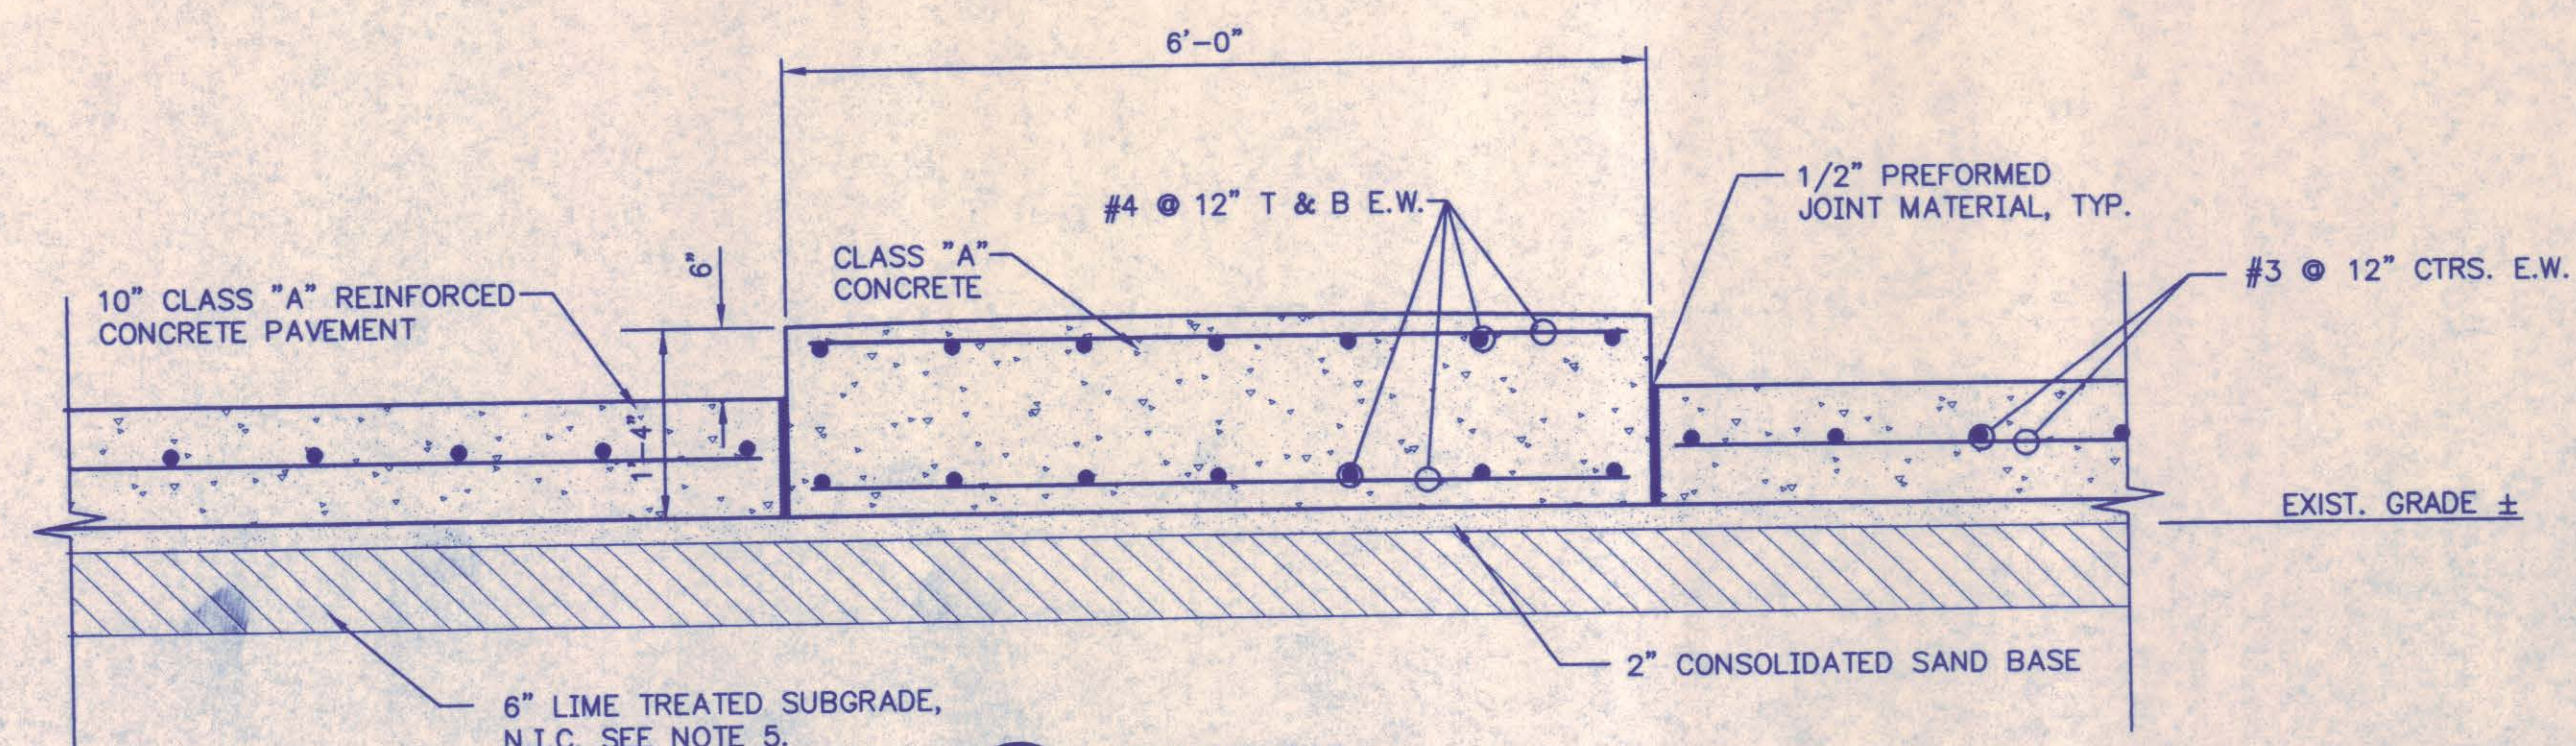


C7.1 SCALE: 3/4"=1'-0"

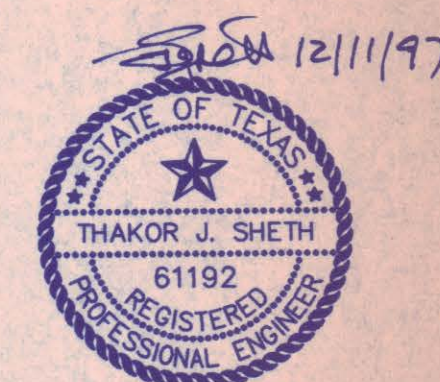


NO.	REVISION	BY	DATE
NORTH TEXAS TOLLWAY AUTHORITY ADDISON AIRPORT TUNNEL			
TYPICAL ISLAND PLANS, SECTIONS AND DETAILS II			
 AQUIRRE ASSOCIATES INC 12700 PARK CENTRAL DRIVE 15 TH FLOOR DALLAS TEXAS 75251 TEL (972) 788-1506		SECTION XIII	
DRAWN <u>WAB</u> CHECKED <u>TJS</u>	DATE <u>8/28/97</u> DATE <u>11/5/97</u>	DESIGNED <u>WAB</u> DATE <u>12/20/97</u> SCALE <u>AS SHOWN</u>	
CONTRACT NO. DNT-290		SHEET 15 OF 53	

Chiang, Patel & Yerby, Inc.
Consulting Engineers • Planners • Project Managers
Dallas • Fort Worth • Houston • San Antonio


AT-C7.2

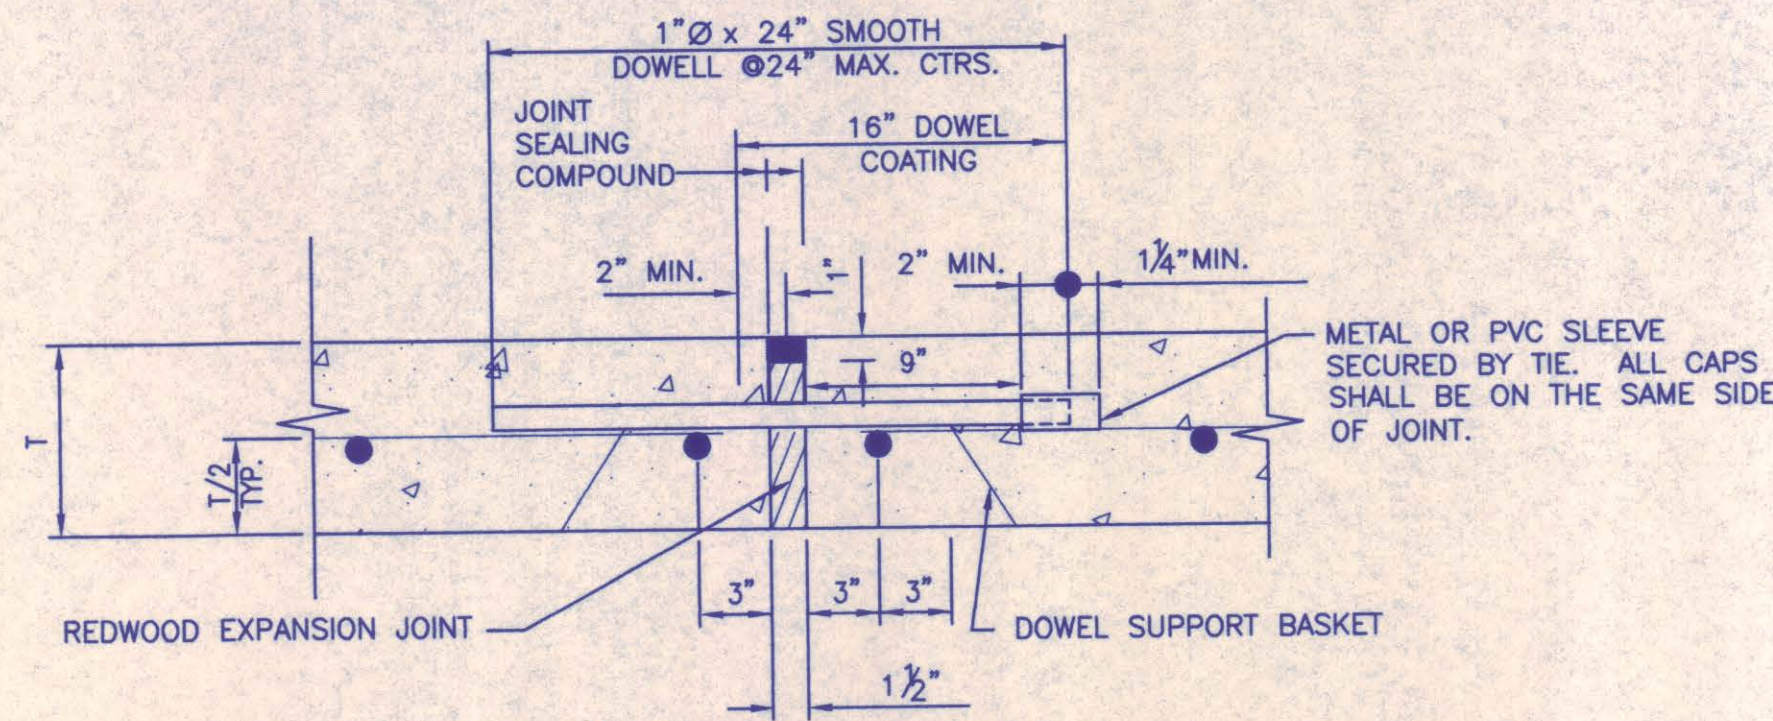


A EXPANSION JOINT (E)
SCALE: 1 1/2" = 1'

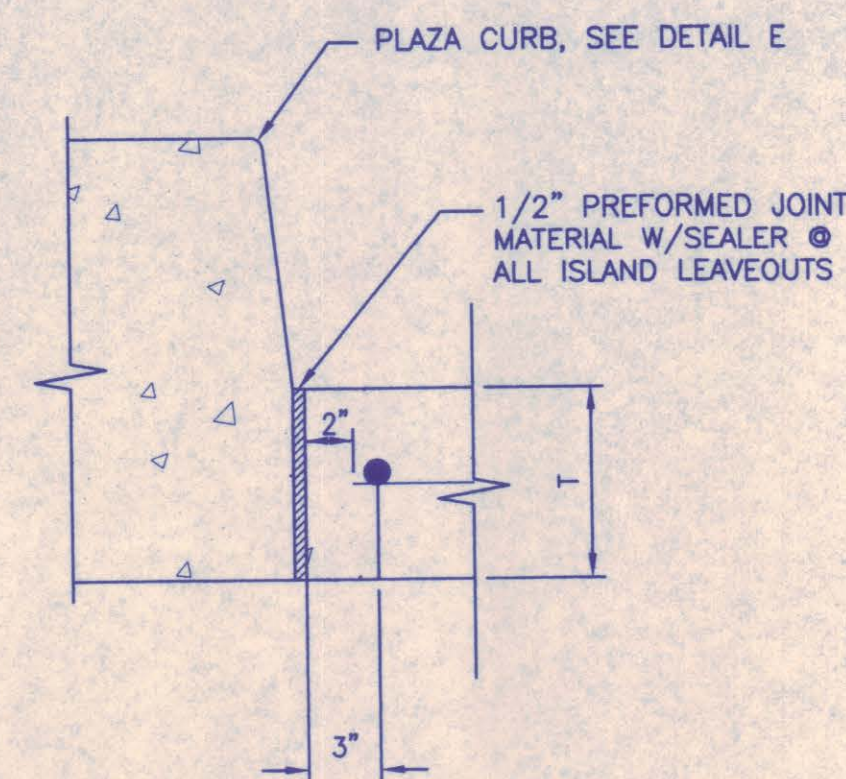


B PLAZA JOINTS (P)
SCALE: 1 1/2" = 1'

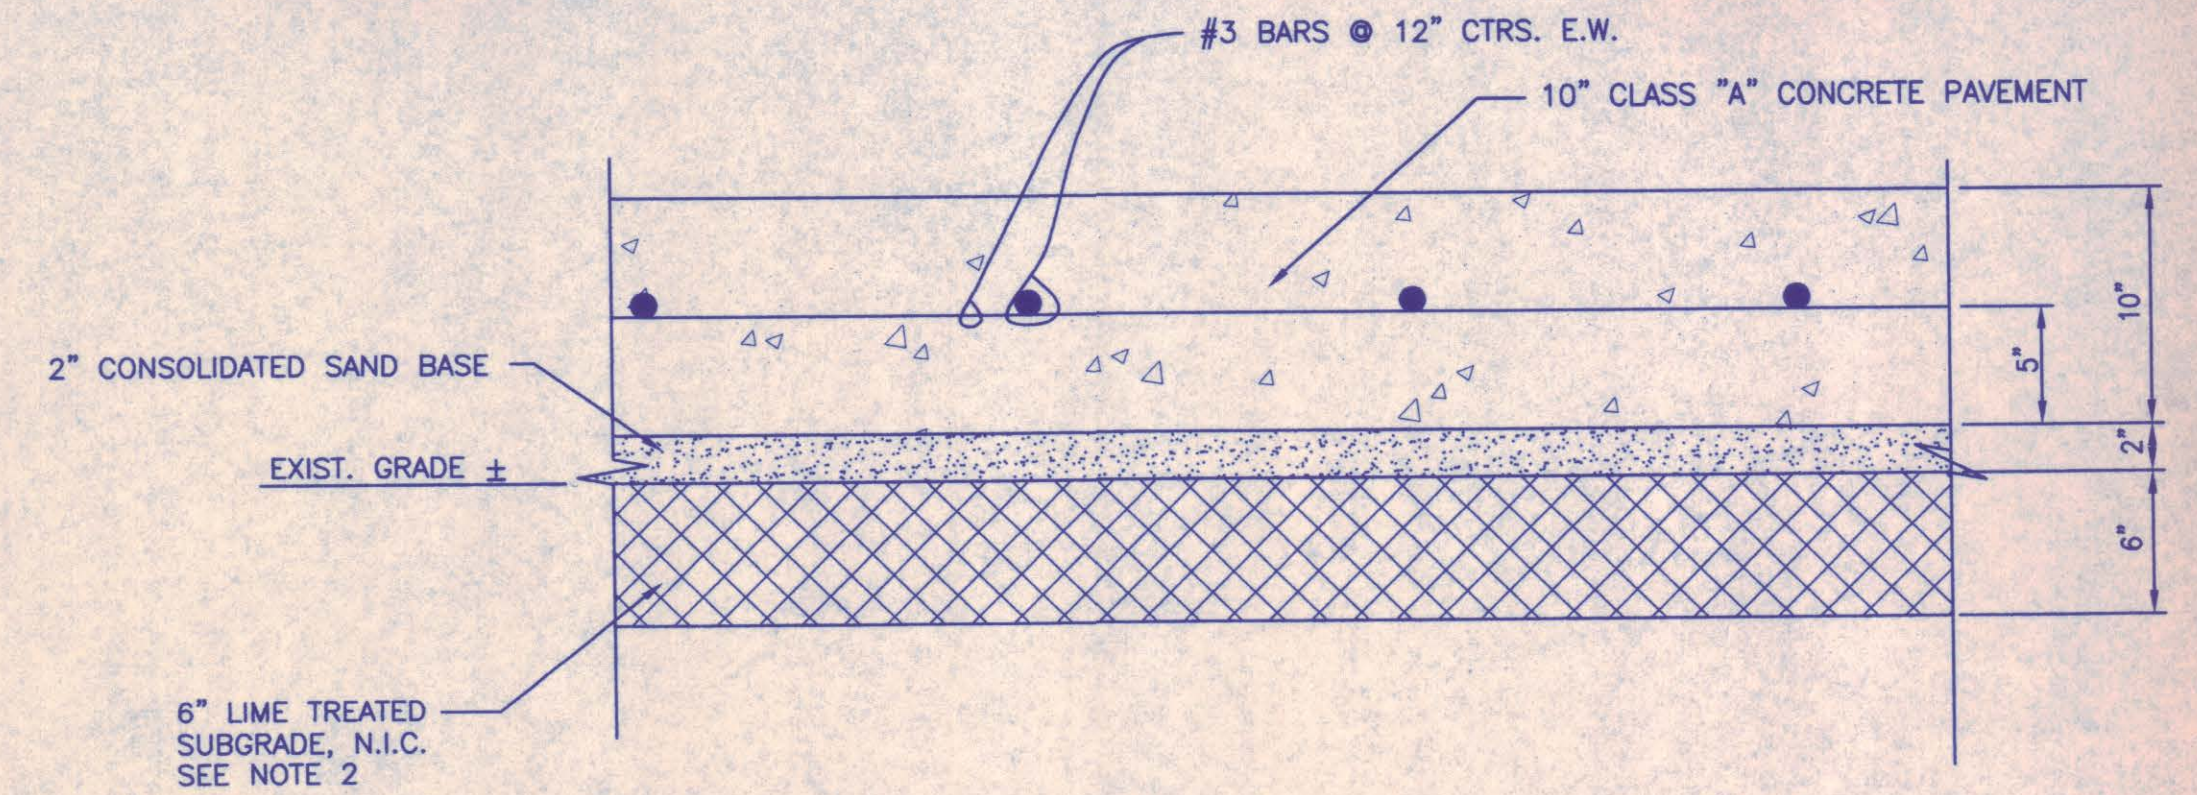


C TYPICAL PLAZA PAVEMENT
SCALE: 1 1/2" = 1'

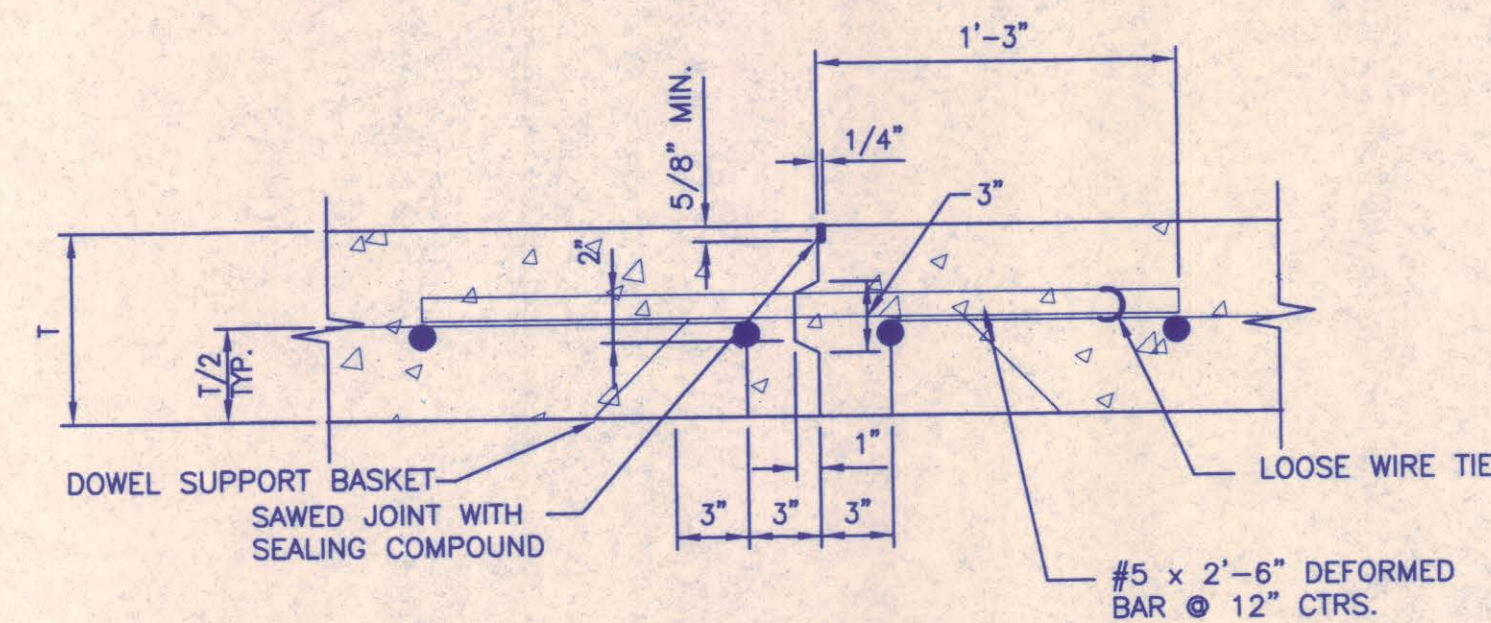

D LONGITUDINAL JOINT (L) & CONSTRUCTION JOINT (C)
SCALE: 1 1/2" = 1'

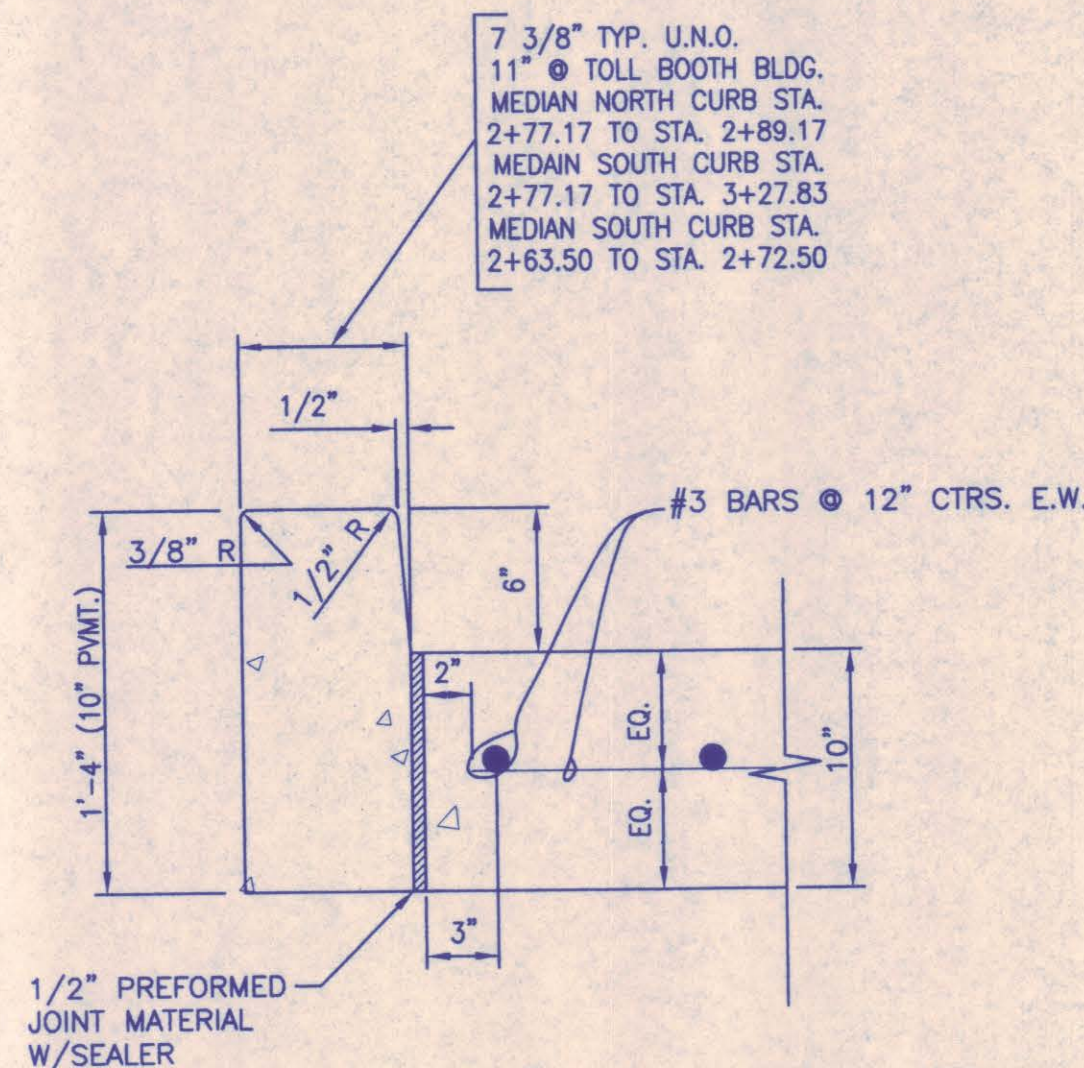


E TYPE P MONOLITHIC CURB
SCALE: 1 1/2" = 1'

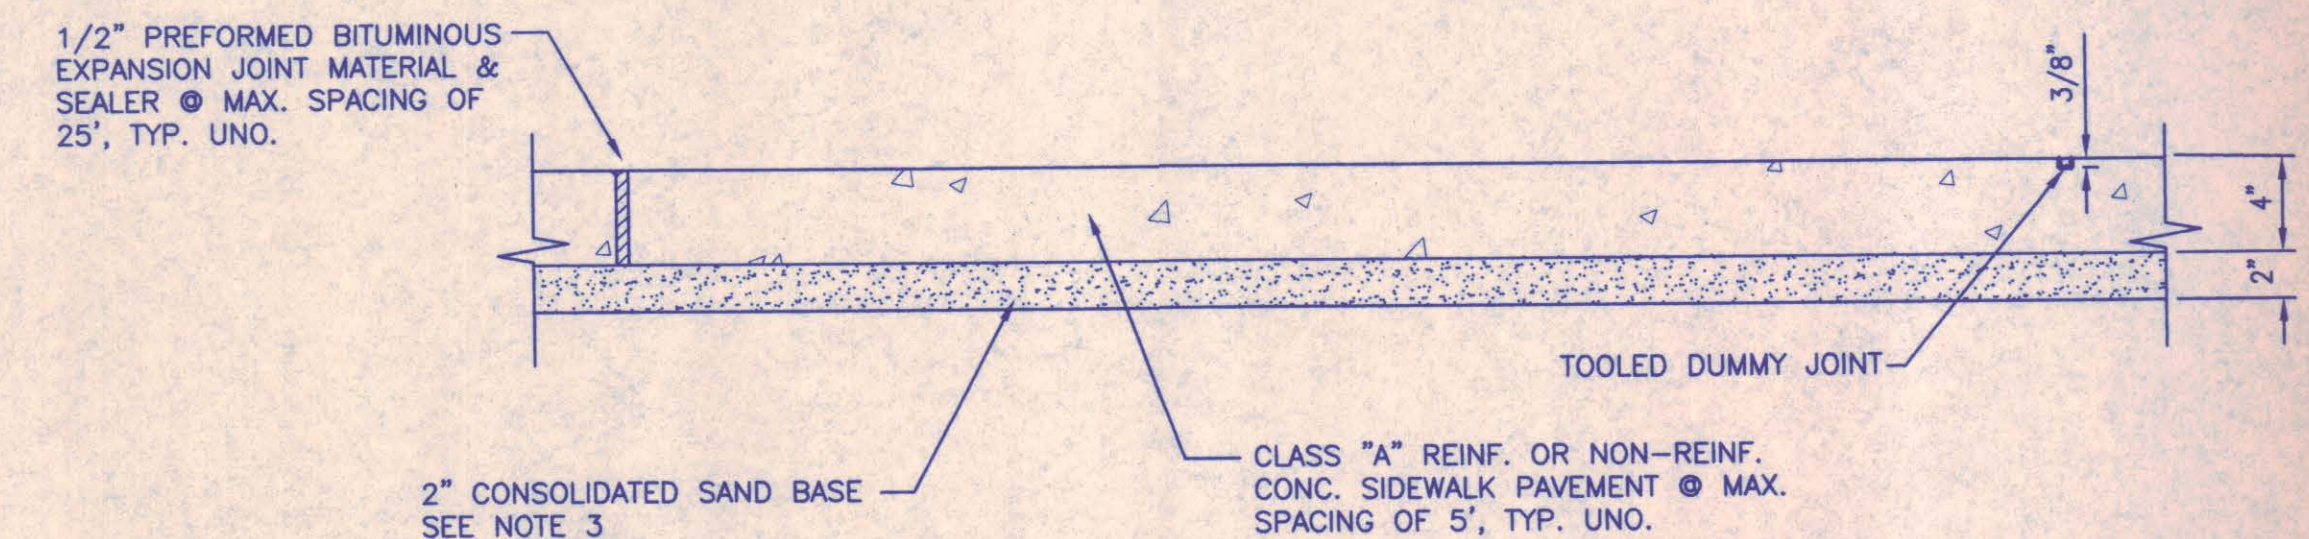


F TYPICAL SIDEWALK JOINTS
SCALE: 1 1/2" = 1'

NOTES:


1. PLAZA CONTRACTOR SHALL PROVIDE ALL EXPANSION JOINT HARDWARE BETWEEN PLAZA AND ROADWAY TO ROADWAY CONTRACTOR.
2. THE LIME TREATED SUBGRADE WITHIN AND ADJACENT TO THE TOLL PLAZA CONSTRUCTION LIMITS HAS PREVIOUSLY BEEN LIME TREATED AND STABILIZED BY OTHERS. IF THAT LIME STABILIZED SUBGRADE SUBSEQUENTLY IS DAMAGED BY THE CONTRACTOR'S CONSTRUCTION OPERATIONS, THE SUBGRADE SHALL BE REPAIRED WITH AVAILABLE STOCKPILED LIME TRIMMINGS OR WITH LIME SLURRY AS DIRECTED BY THE ENGINEER.
3. ANY FILL MATERIAL REQUIRED BELOW 2" SAND BASE FOR SIDEWALK AND BELOW CONC. PAVEMENT SHALL BE SELECT FILL MATERIAL WITH A LIQUID LIMIT OF 35 OR LESS AND PLASTICITY INDEX BETWEEN 8 AND 20. A MINIMUM OF 35 PERCENT PASSING NO. 200 SIEVE, A MINIMUM OF 85 PERCENT PASSING NO. 4 SIEVE AND FREE FROM ORGANIC OR OTHER DELETERIOUS MATERIAL. SELECT FILL MATERIAL SHALL BE PLACED IN MAXIMUM OF 6" LAYERS, LOOSE MEASURE COMPACTED TO NOT LESS THAN 98 PERCENT OF MAXIMUM DENSITY AS DETERMINED BY TXDOT METHOD TEX-114-E. REFER TO TXDOT'S SPECIFICATIONS AND NTIA'S SPECIAL PROVISIONS ITEM 132 FOR FILL MATERIAL AND COMPACTION REQUIREMENTS.

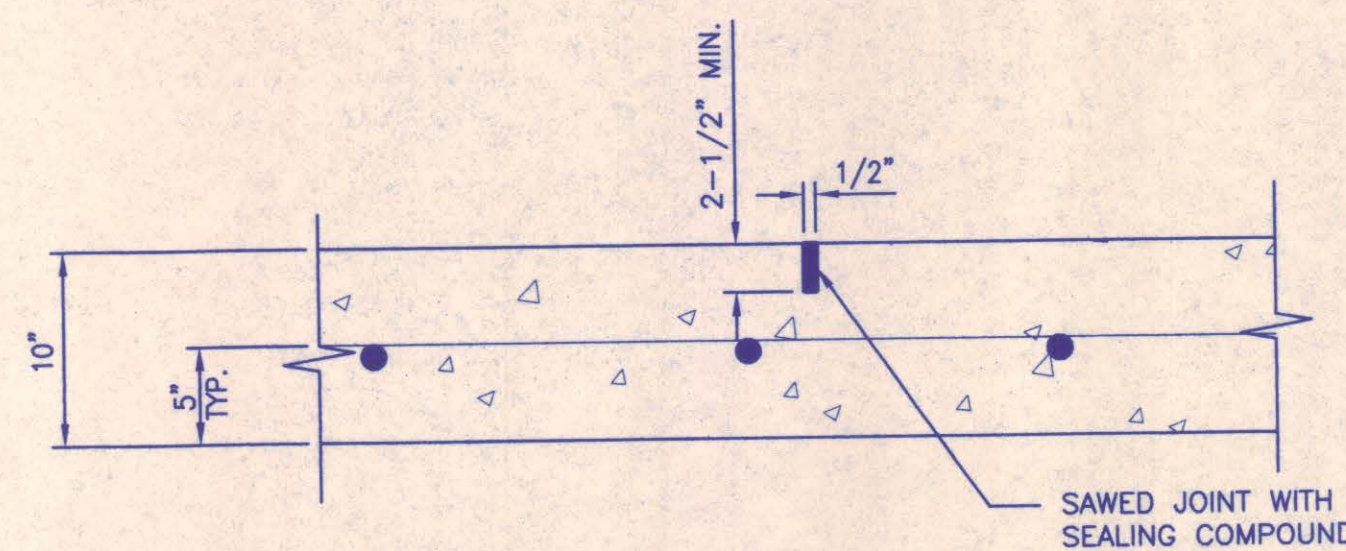

G SAWED DUMMY JOINT (S)
SCALE: 1 1/2" = 1'

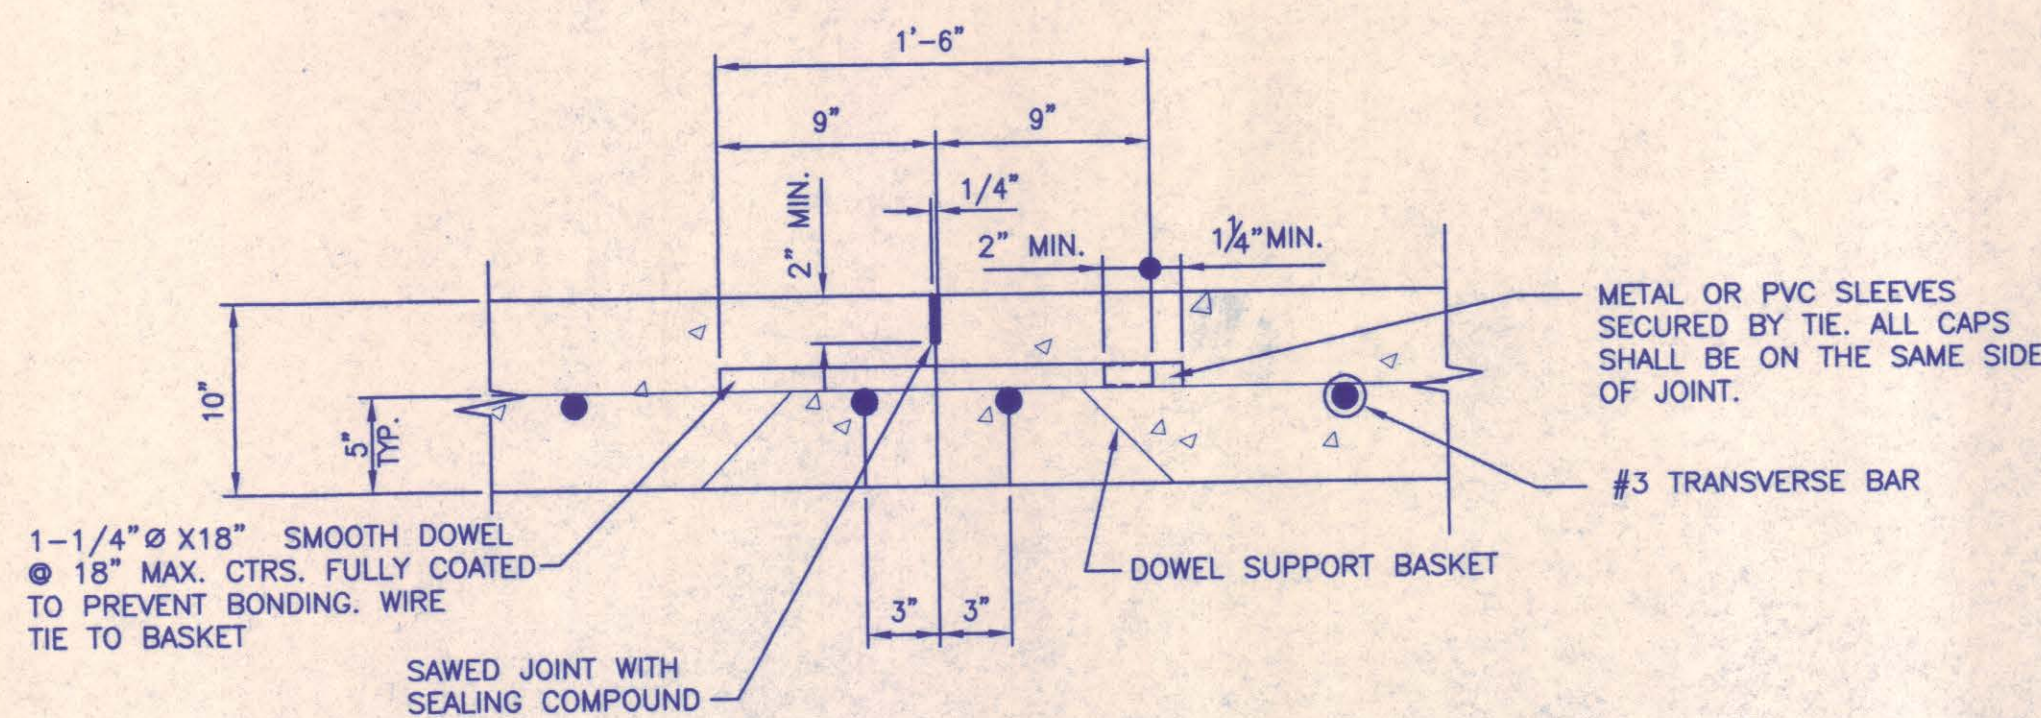

H CONTRACTION JOINT (SC)
SCALE: 1 1/2" = 1'

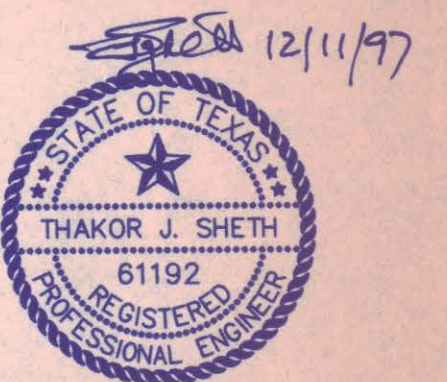

Chiang, Patel & Yerby, Inc.
Consulting Engineers • Planners • Project Managers
Dallas • Fort Worth • Houston • San Antonio

AT-C8.1

NO.	REVISION	BY	DATE
NORTH TEXAS TOLLWAY AUTHORITY ADDISON AIRPORT TUNNEL			
PAVEMENT SECTIONS AND DETAILS			
AQUIRRE ASSOCIATES INC. 12700 PARK CENTRAL DRIVE 15 TH FLOOR DALLAS TEXAS 75251 TEL. (972) 788-1500		SECTION XIII	
DRAWN MM	DATE 8/28/97	DESIGNED MM	DATE 12/20/96
CHECKED TJS	DATE 11/5/97	SCALE AS SHOWN	
CONTRACT NO. DNT-290		SHEET 16 OF 53	

1/64" MAX. TOLERANCE
NON-ACCUMULATIVE
FOR HOLE LOCATIONS

7-1/2" DIA. AIR HOLES
@ 1'-6" O.C. EACH

1'-0 1/2"

11 3/4"

8 3/4"

3/8"

1'-7"

1'-7"

1'-7"

1'-7"

1'-7"

1'-7"

3 1/8"

L1x1x1/8

1 1/2" CONDUIT

CONTINUOUS WELD

4x3/8 x12 1/2 STEEL PLATE

2 1/2" DIA. HOLE

3/8 x 3 BARS

1/2 x 2 1/2 BARS (TYP.)

NON-CORROSIVE BUSHING (TYP.)

3/8" x 1 1/2" BARS

1'-0 1/8"

4'-0"

4'-0"

1'-0 1/8"

6 1/8"

6"

6"

6"

6"

6"

1'-0"

1'-0"

1'-0"

6"

6"

6"

6"

6"

6 1/8"

10'-0 1/4"

NOTES:

1. TREADLE FRAME WILL BE FURNISHED BY OWNER TO PLAZA CONTRACTOR FOR INSTALLATION.
2. PLAZA CONTRACTOR SHALL FURNISH AND INSTALL ALL CONDUITS AND DRAIN LINES TO TREADLE FRAME JUNCTION BOXES AS SHOWN ON THE DRAWINGS.
3. VERIFY LOCATION OF TREADLE WITH TTA PRIOR TO PAVEMENT CONSTRUCTION.
4. REFER TO ELECTRICAL DRAWINGS FOR CONTINUATION OF ELECTRICAL CONDUIT FROM AXLE COUNTING TREADLE.
5. SURFACE PREPARATION - SSPC SP-6 COMMERCIAL BLAST CLEANING. PRIMER 5.0 MILS DFT - NEMEC, 66 COLOR, HIGH BUILD PRIMER OR CARBOLINE, 890 EPOXY. FINISH COAT 4.0 MILS DFT - NEMEC, 75-COLOR, ENDURA SHIELD OR CARBOLINE, 134 HS POLYURETHANE. PRIMER AND FINISH COAT PAINT SHALL BE SUPPLIED BY A SINGLE MANUFACTURER.
6. 4"Ø PVC DRAIN IS NOT SHOWN FOR CLARITY.


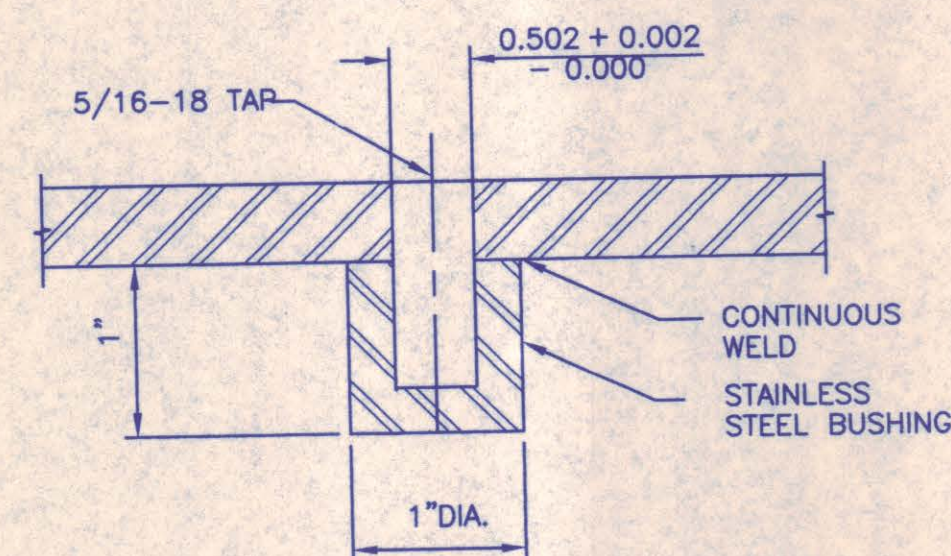


Diagram illustrating the cross-section of a concrete curb. The curb has a top width of 8" and a base width of 3½". The height of the curb is 6". The slope of the curb is 1:1. The material is CLASS "H" CONCRETE. The top of the pavement is indicated. The curb is reinforced with 2-#4 BAR. The minimum thickness of the curb is 4" (MIN.).


NOTES:

1. PRECAST CONCRETE BUMPER SHALL BE 6' LONG.
2. MINIMUM COMPRESSIVE STRENGTH OF CONCRETE AT 28 DAYS SHALL BE 3,500 p.s.i.



PRECAST CONCRETE BUMPER
SCALE: NONE

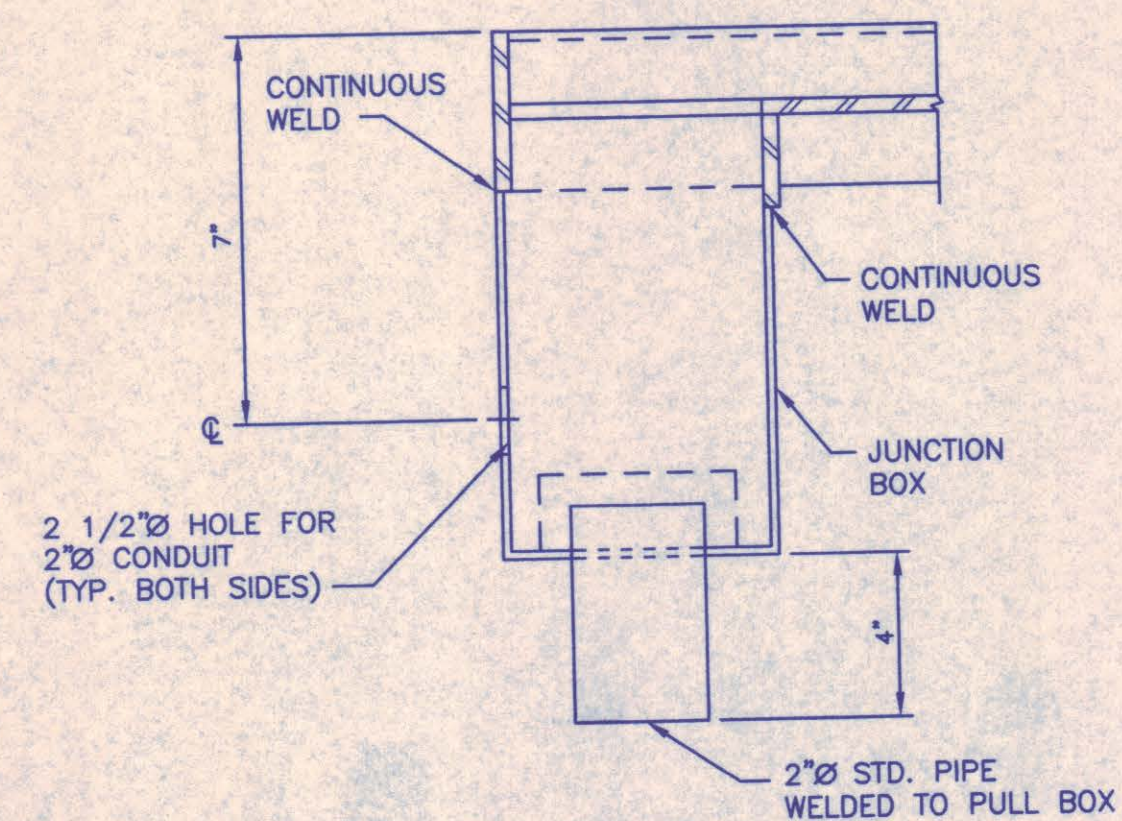


2,3 SECTION
— SCALE: NONE

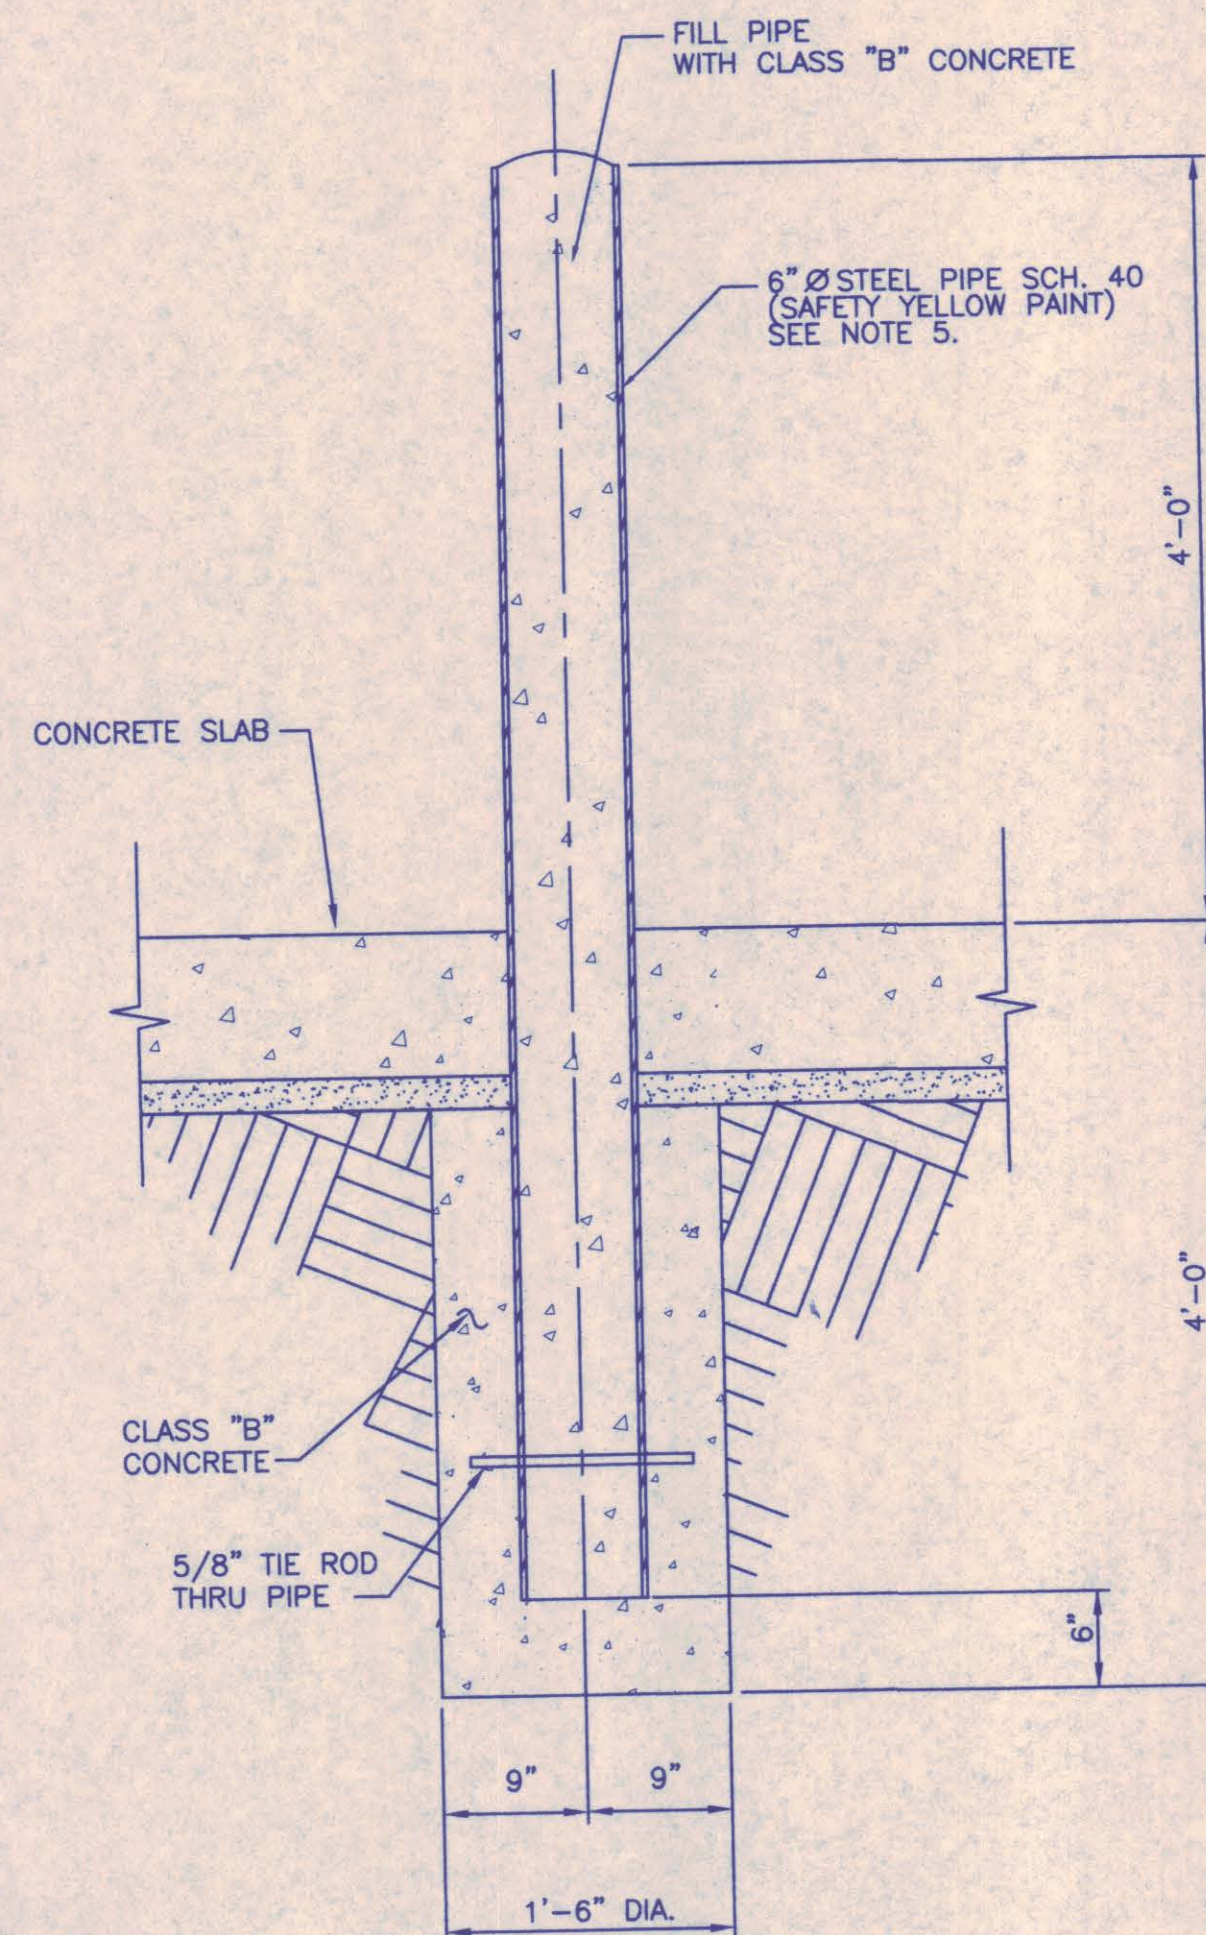

BOLLARD
SCALE: 1" = 1'-0"

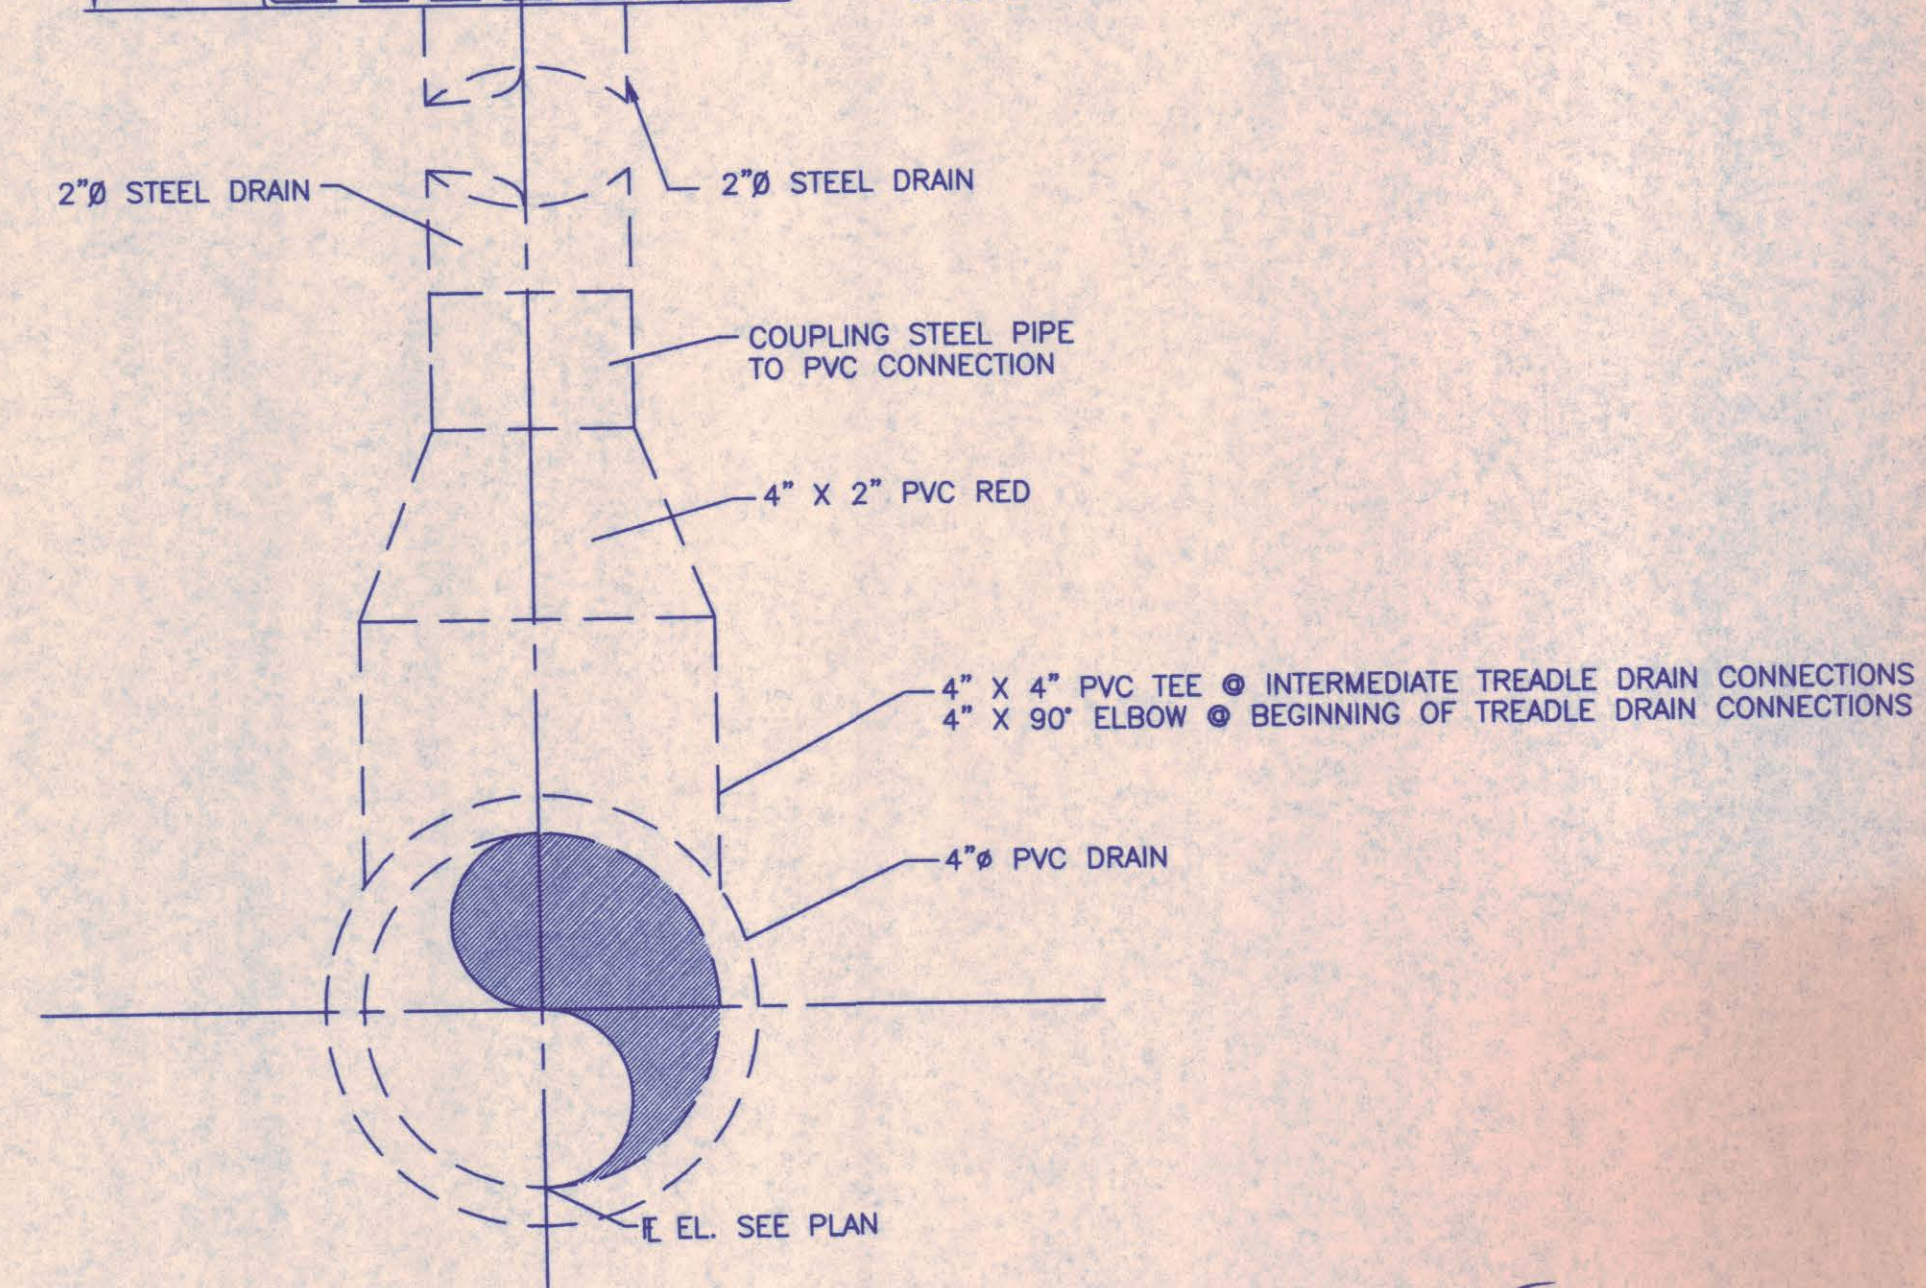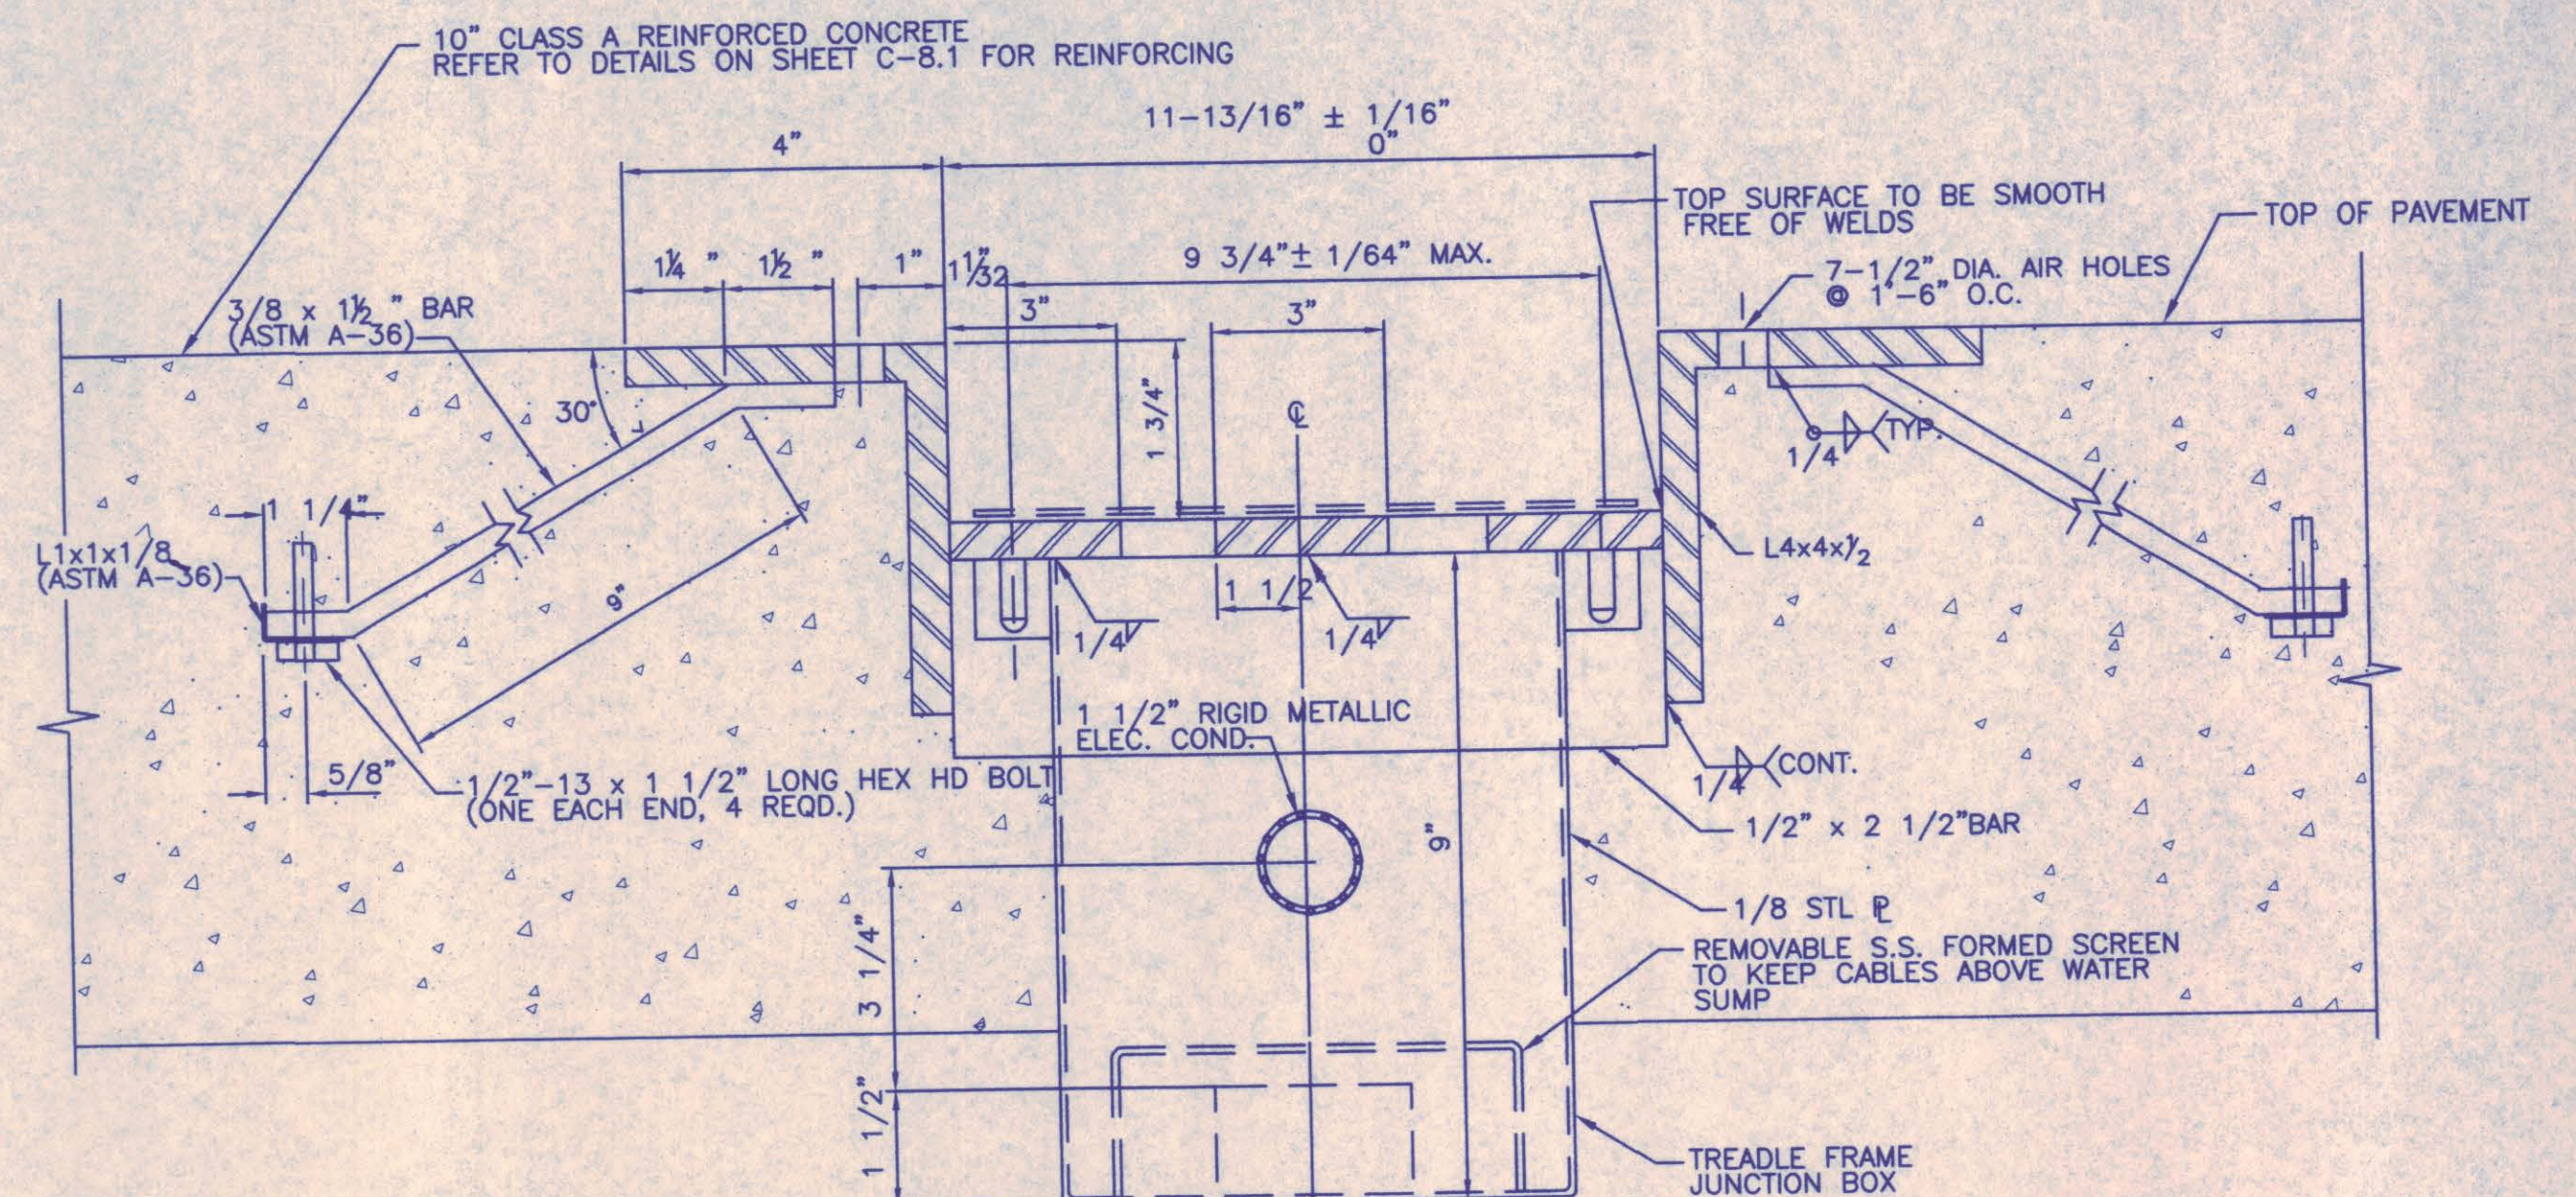


1 SECTION
— SCALE: NONE

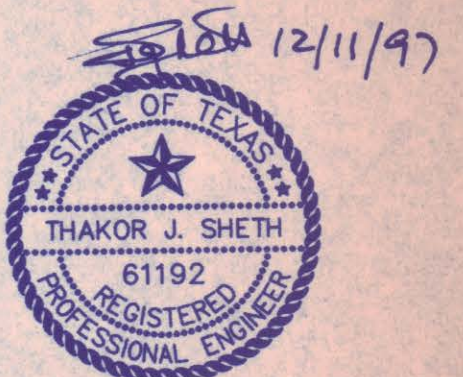


NO.	REVISION	BY	DATE
NORTH TEXAS TOLLWAY AUTHORITY ADDISON AIRPORT TUNNEL			
DETAILS AND SECTIONS			
 AGUIRRE ASSOCIATES INC 12700 PARK CENTRAL DRIVE 15 TH FLOOR DALLAS TEXAS 75251 TEL (972) 786-1508		SECTION XIII	
DRAWN MM	DATE 8/28/97	DESIGNED MM	DATE 12/20/97
CHECKED TJS	DATE 11/5/97	SCALE AS SHOWN	
CONTRACT NO. DNT-290		SHEET 17 OF 53	

AT-C8.2


 **Chiang, Patel & Yerby, Inc.**
Consulting Engineers • Planners • Project Managers
Dallas • Fort Worth • Houston • San Antonio

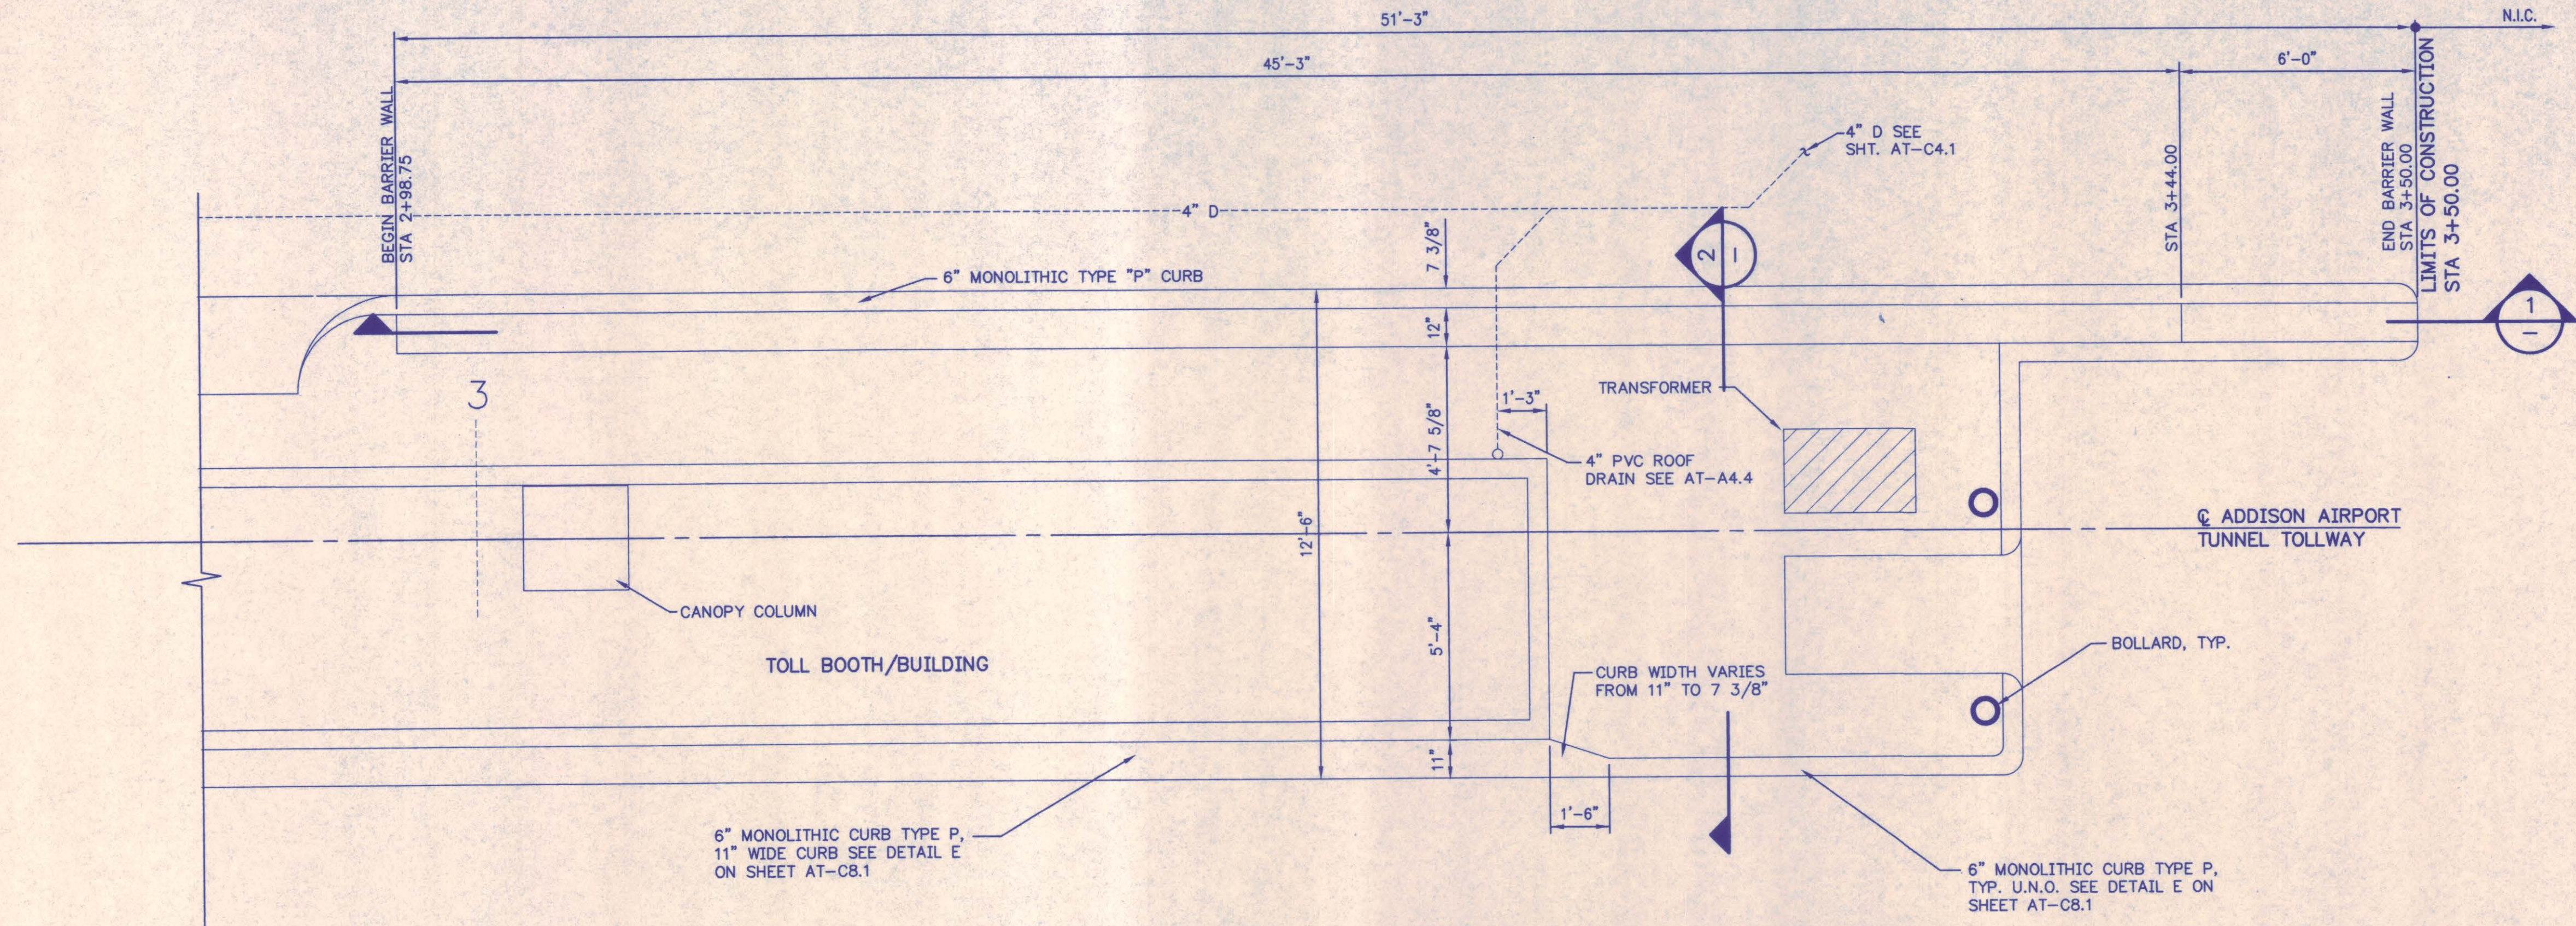

BARRIER WALL
SCALE: 3/8"=1'-0"

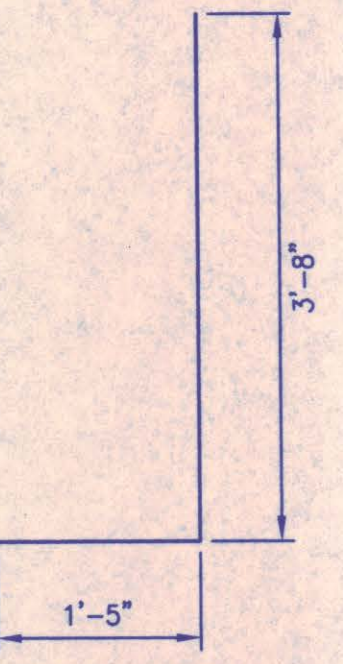


TYPE A
BAR BENDING DIAGRAM
SCALE: 3/4"=1'-0"

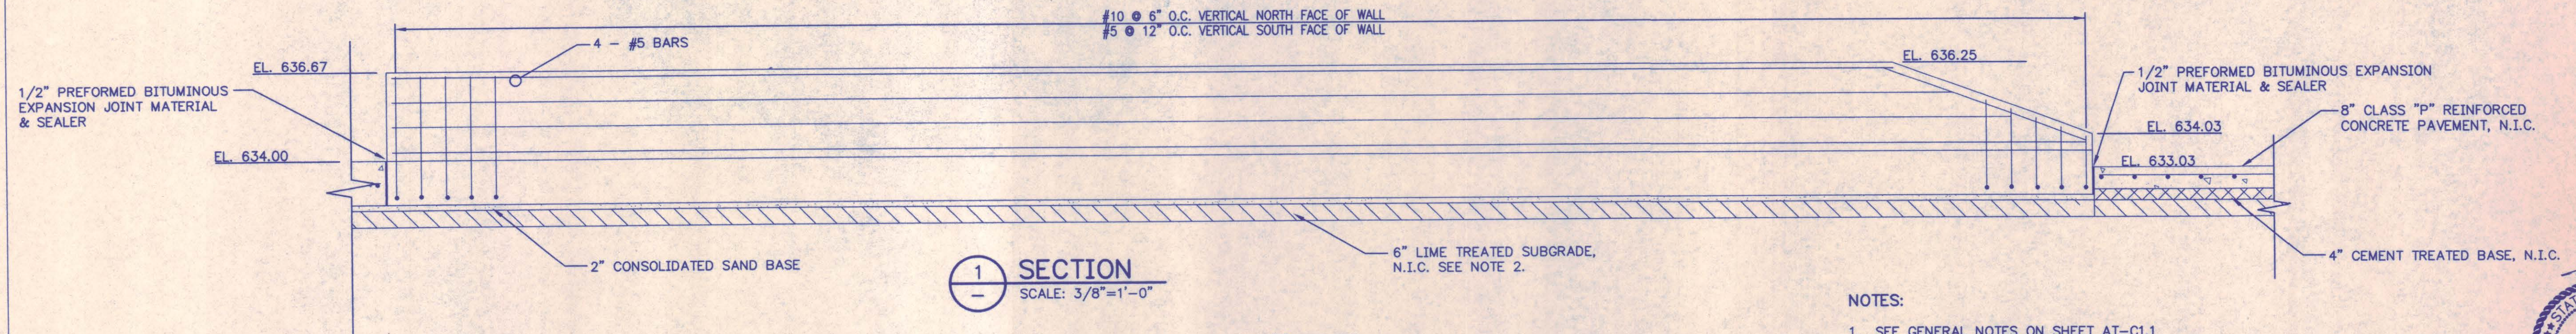

1 SECTION
SCALE: 3/8"=1'-0"

- NOTES:**
1. SEE GENERAL NOTES ON SHEET AT-C1.1
 2. THE LIME TREATED SUBGRADE WITHIN AND ADJACENT TO THE CONSTRUCTION LIMITS HAS PREVIOUSLY BEEN LIME TREATED AND STABILIZED BY OTHERS. IF THAT LIME STABILIZED SUBGRADE SUBSEQUENTLY IS DAMAGED BY THE CONTRACTOR'S CONSTRUCTION OPERATIONS, THE SUBGRADE SHALL BE REPAIRED WITH AVAILABLE STOCKPILED LIME TRIMMINGS OR WITH LIME SLURRY AS DIRECTED BY THE ENGINEER.

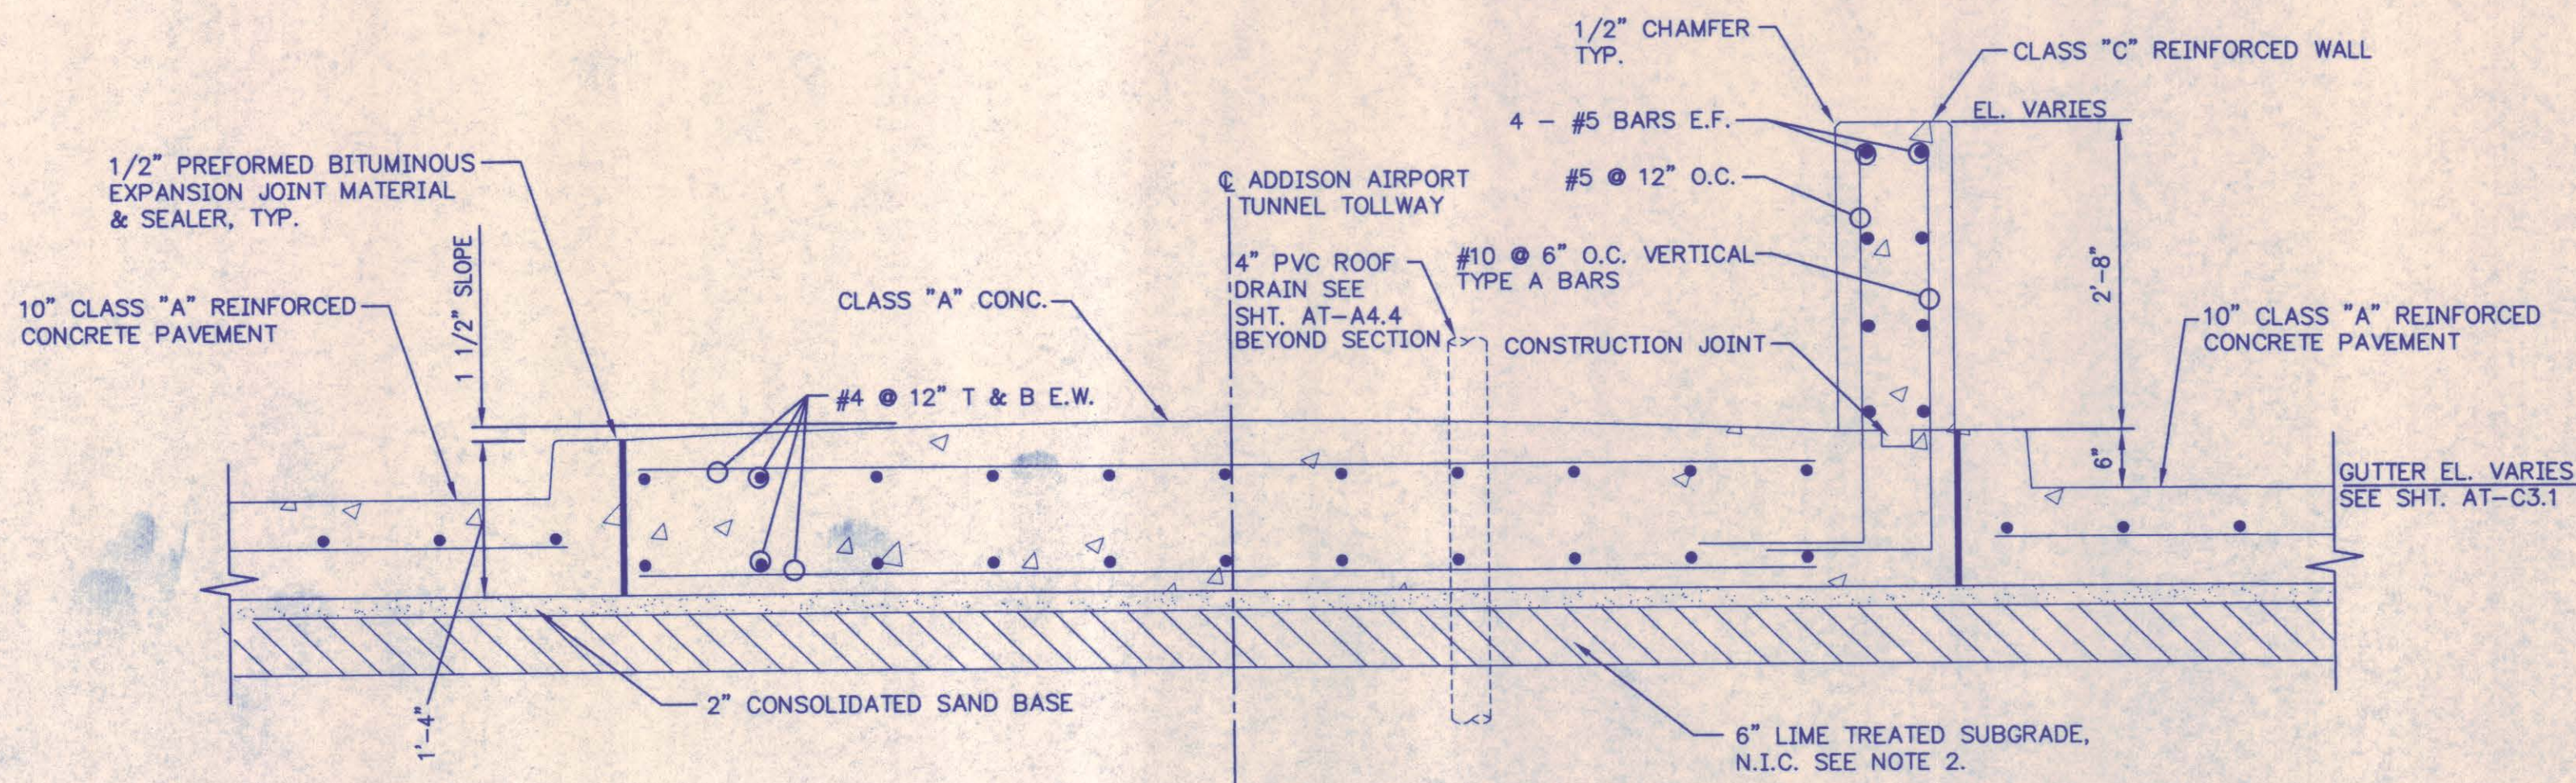


2 SECTION
SCALE: 3/4"=1'-0"

Chiang, Patel & Yerby, Inc.
Consulting Engineers • Planners • Project Managers
Dallas • Fort Worth • Houston • San Antonio


NO.		REVISION		BY		DATE	
NORTH TEXAS TOLLWAY AUTHORITY							
ADDISON AIRPORT TUNNEL							
BARRIER WALL DETAIL AND SECTIONS							
 AGUIRRE ASSOCIATES INC 12700 PARK CENTRAL DRIVE 15 TH FLOOR DALLAS TEXAS 75251 TEL (972) 788-1508						SECTION XIII	
DRAWN WAB		DATE 8/28/97		DESIGNED WAB		DATE 12/20/96	
CHECKED TJS		DATE 8/28/97		SCALE AS SHOWN			
CONTRACT NO. DNT-290				SHEET 18		OF 53	

AT-C9.1


133311M AT-C9.1.DWG

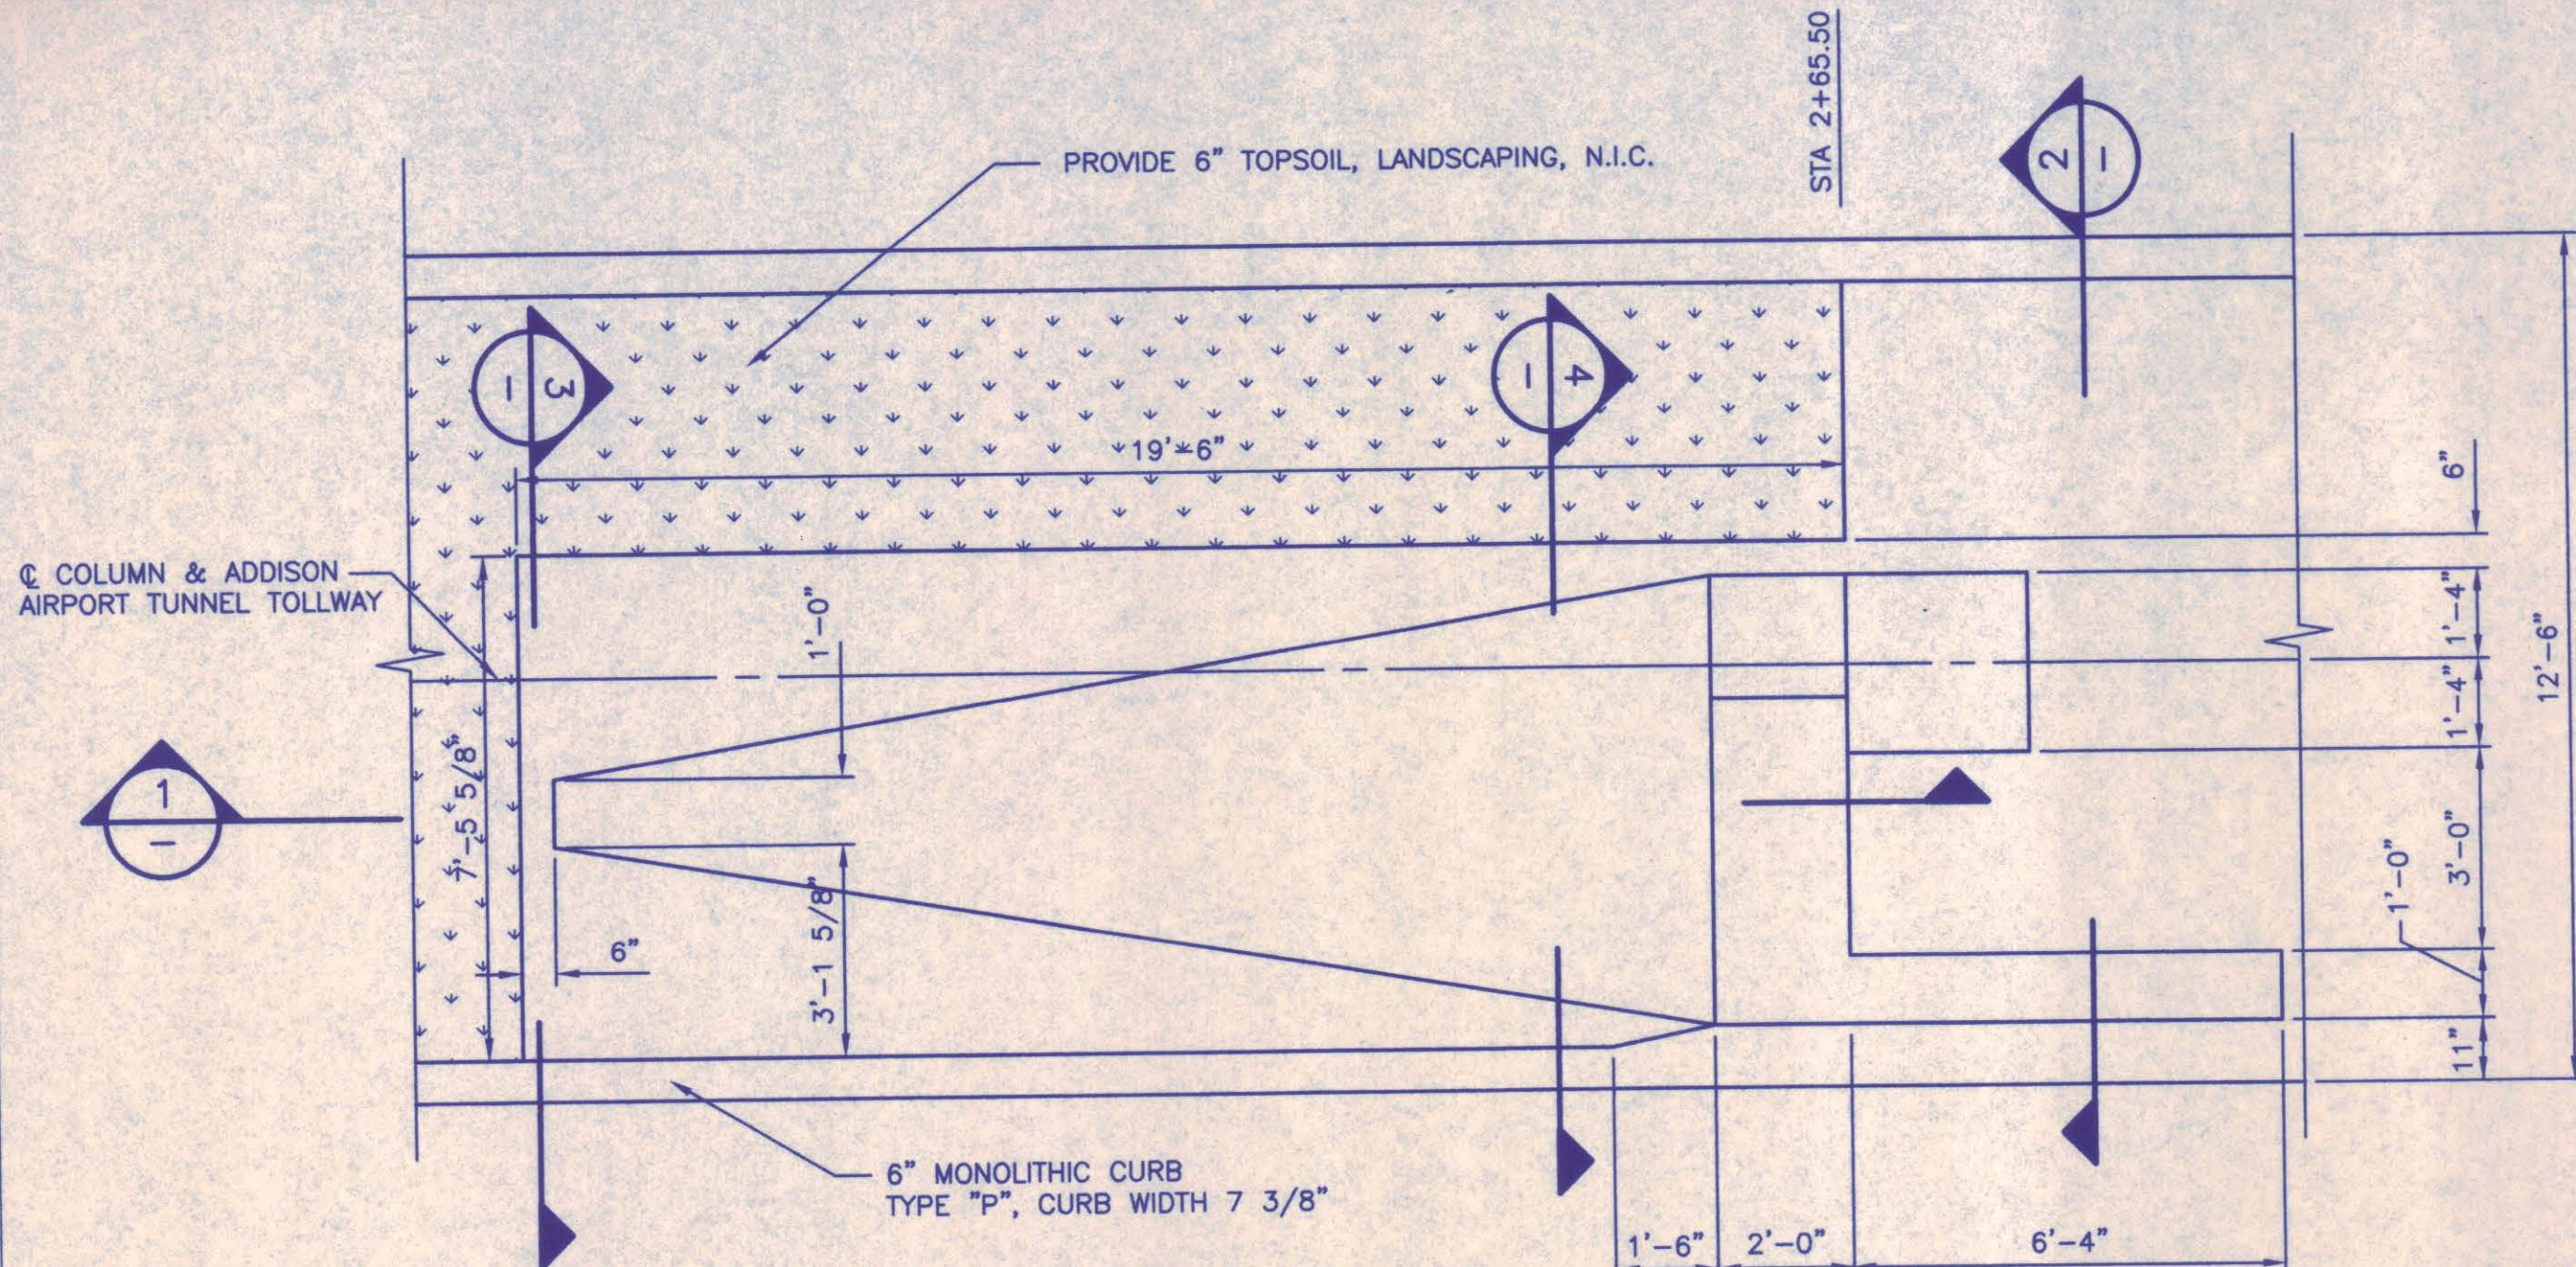


(A) CONCRETE CRASH BUNKER
C5.1 SCALE: 3/8"=1'-0"

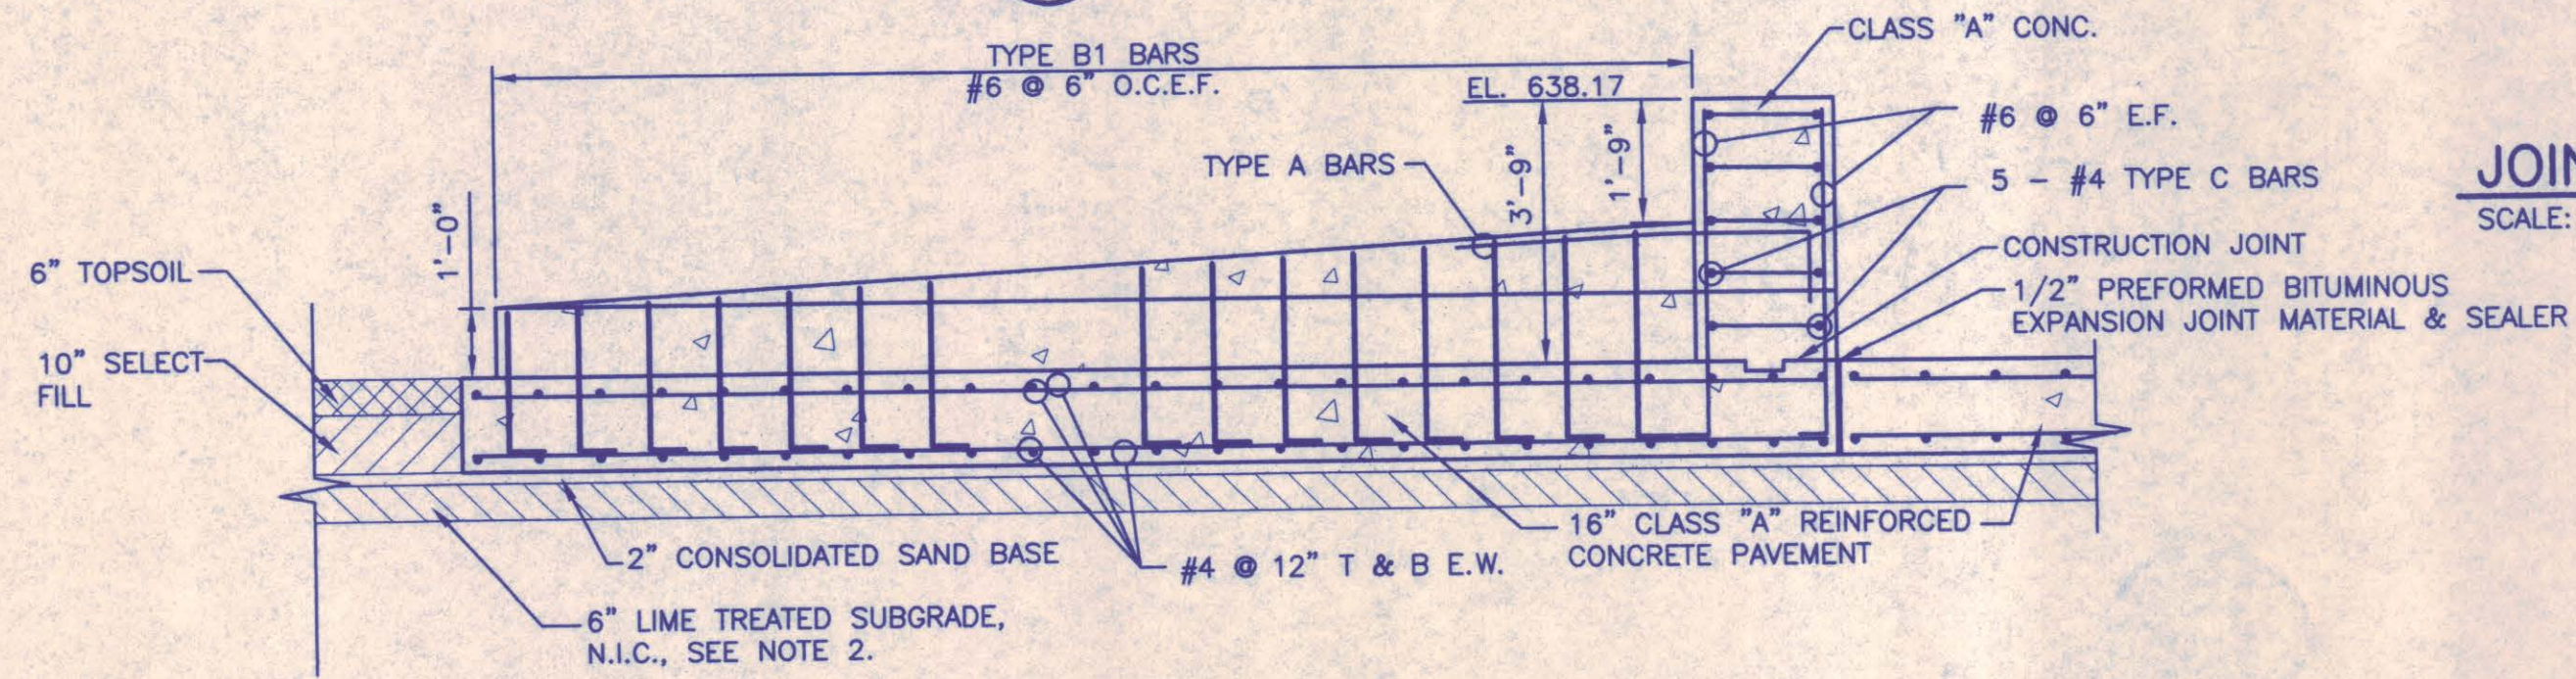


(1) SECTION
SCALE: 3/8"=1'-0"

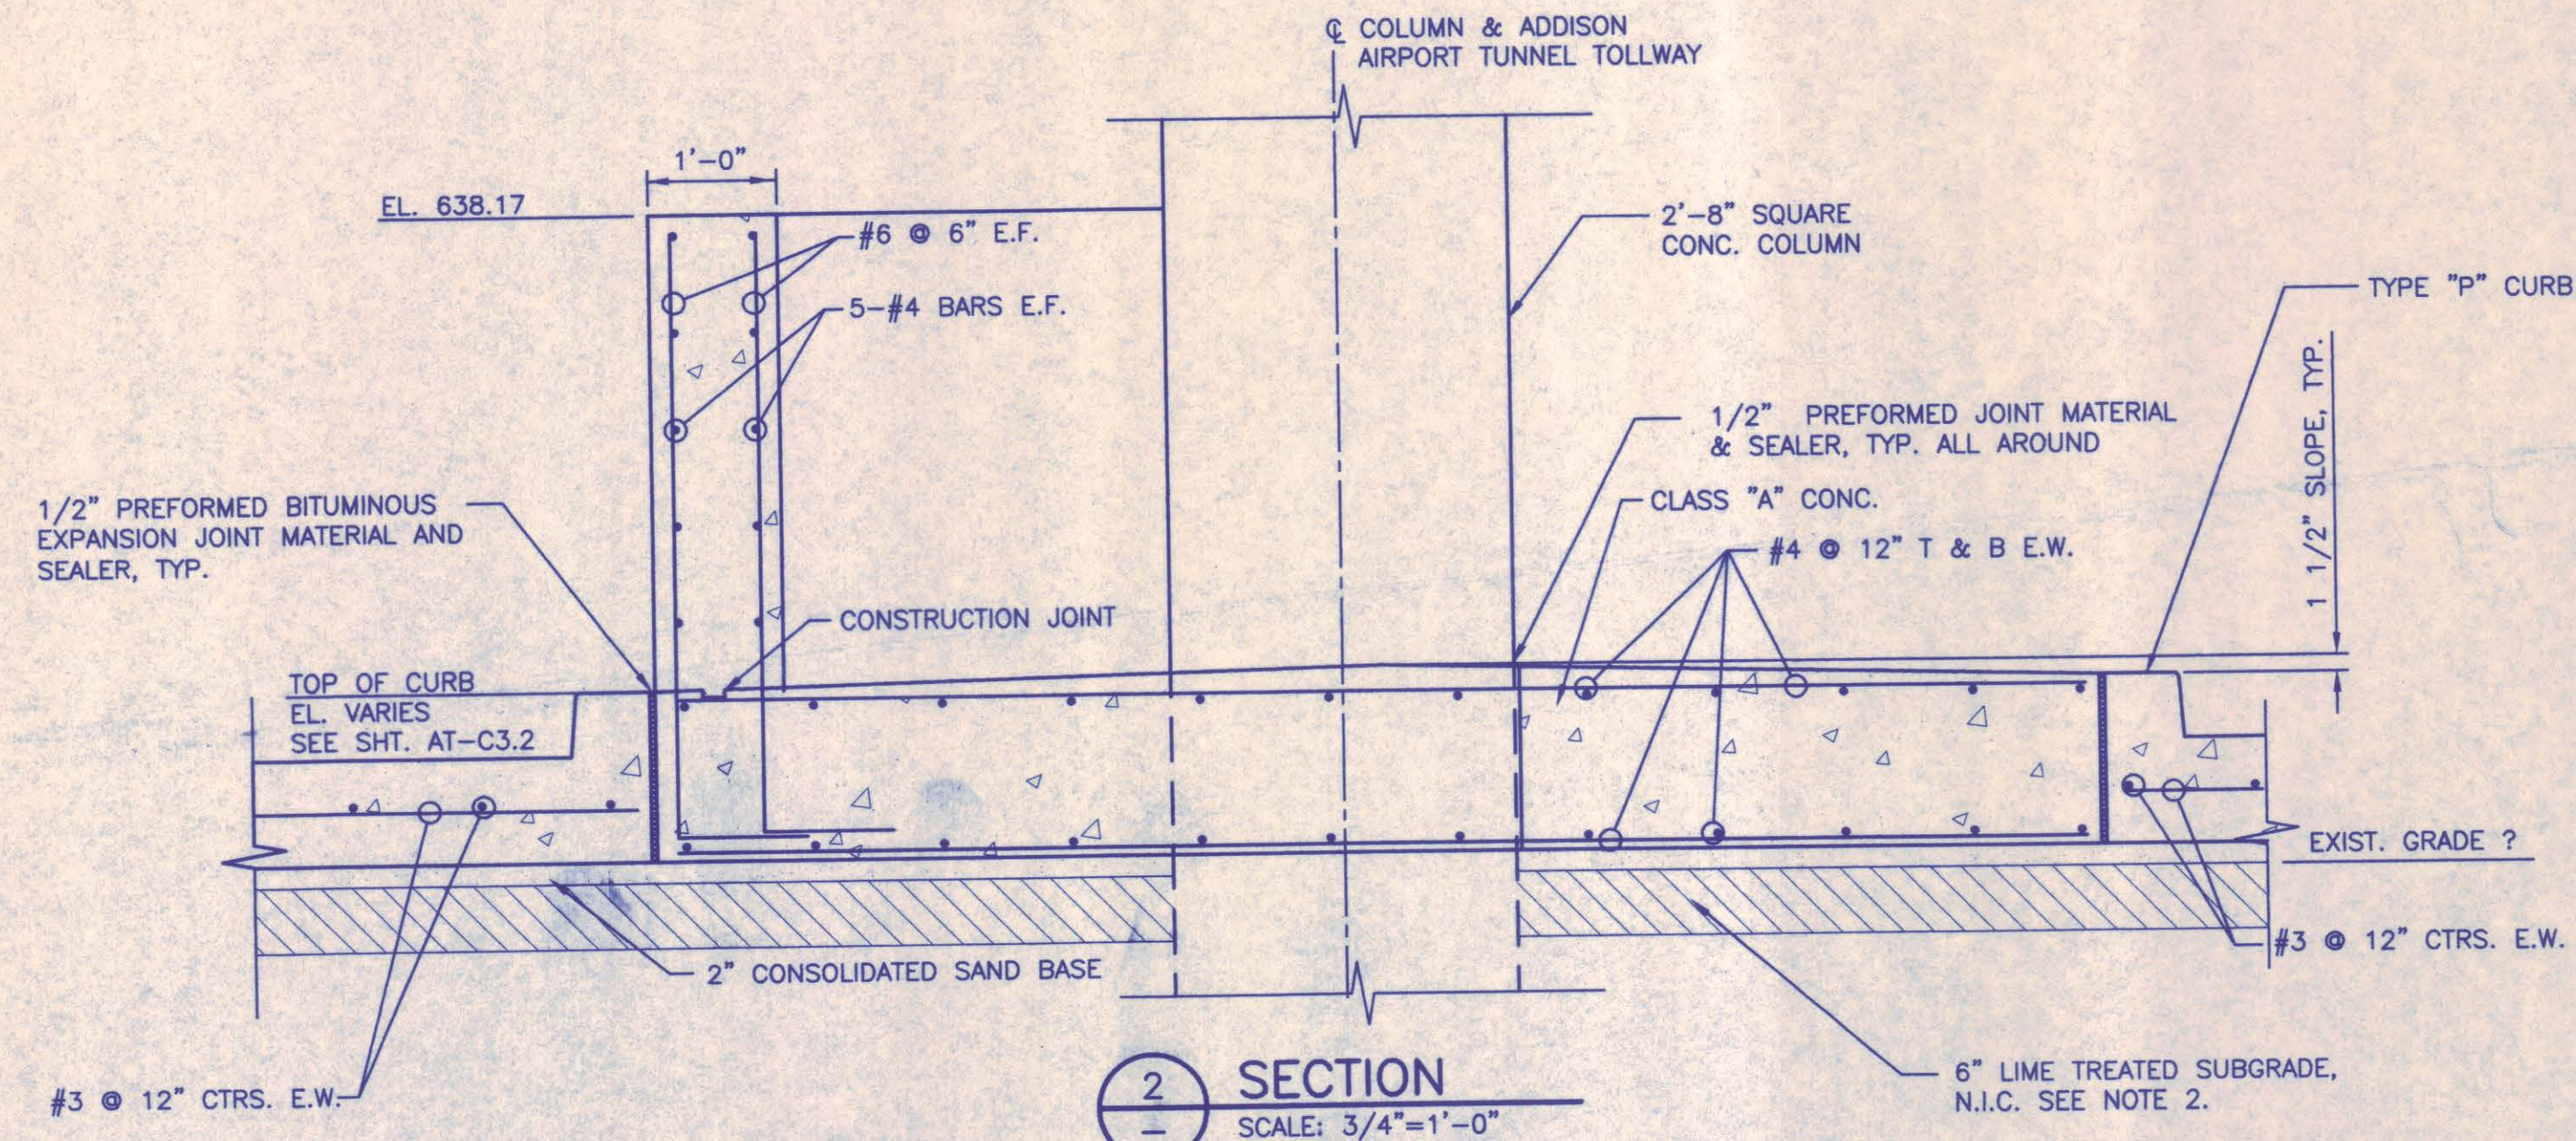


(2) SECTION
SCALE: 3/4"=1'-0"

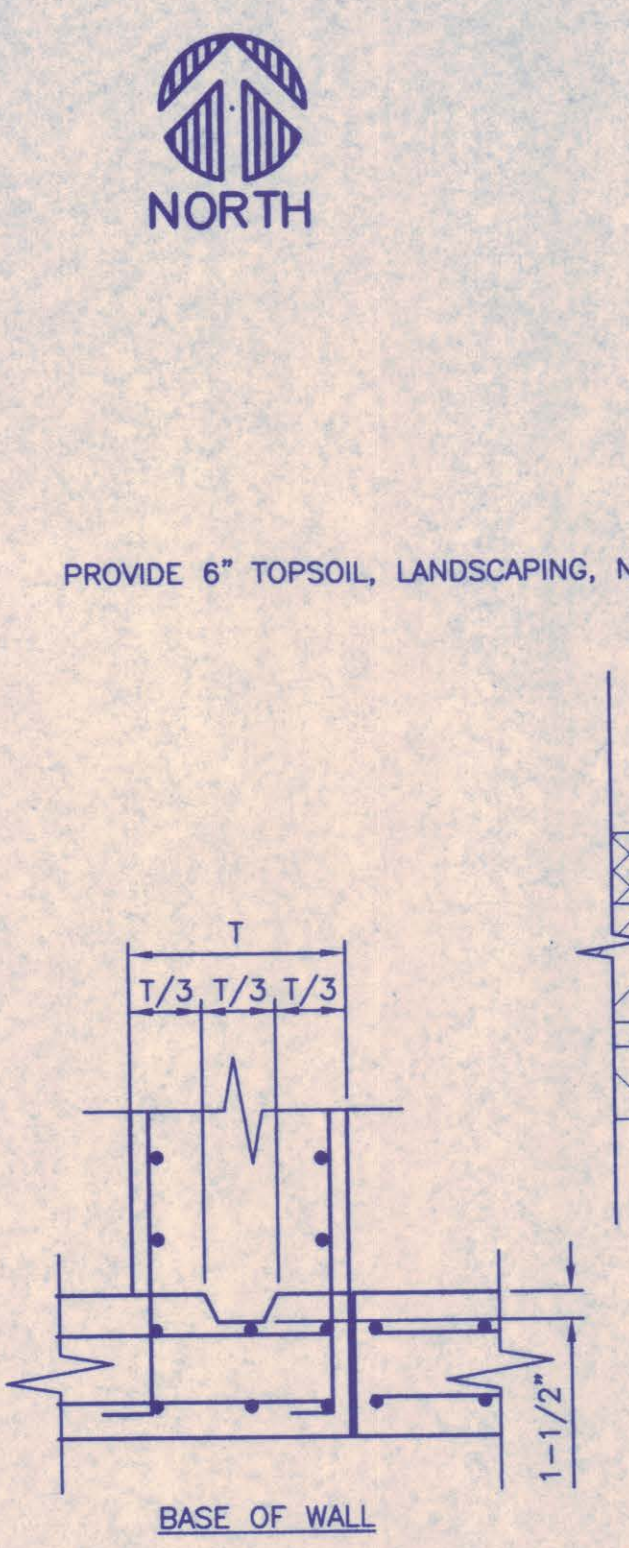


JOINTS WITHOUT WATER STOPS
SCALE: N.T.S.

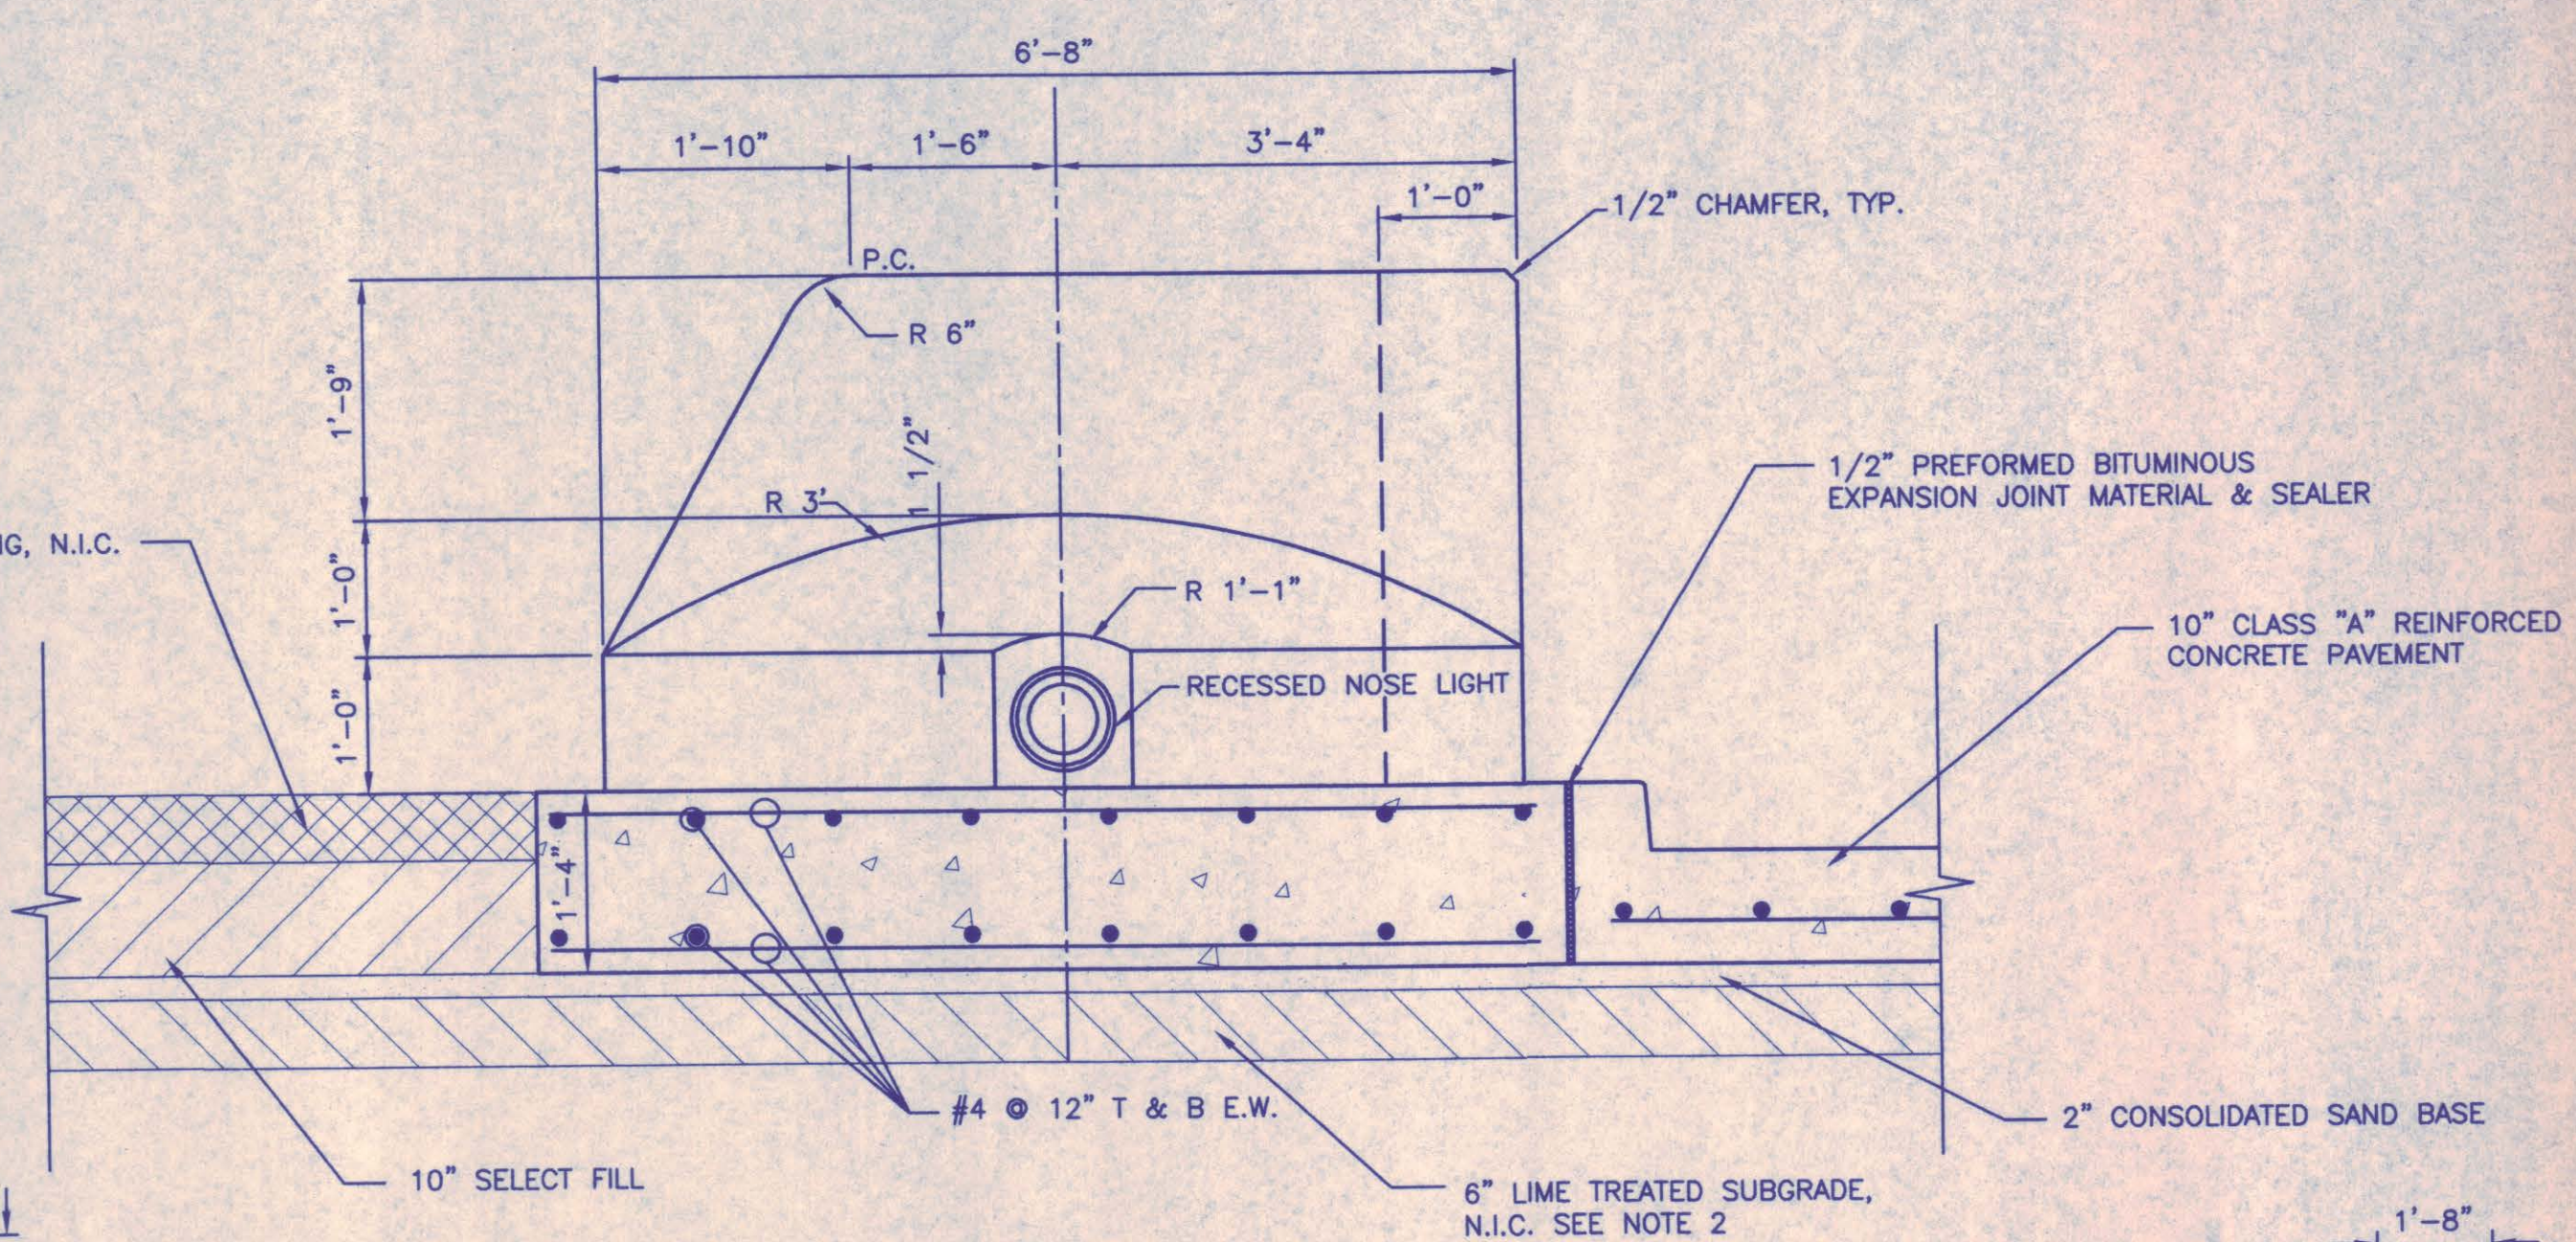

(3) SECTION
SCALE: 3/4"=1'-0"

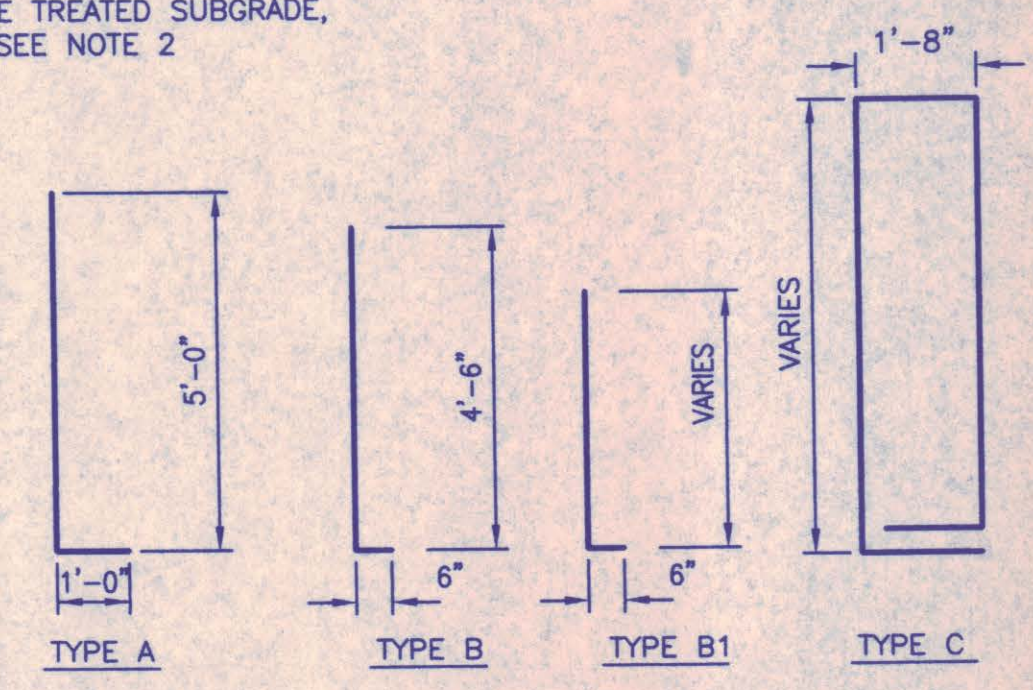


BAR BENDING DIAGRAMS
SCALE: 3/8"=1'-0"

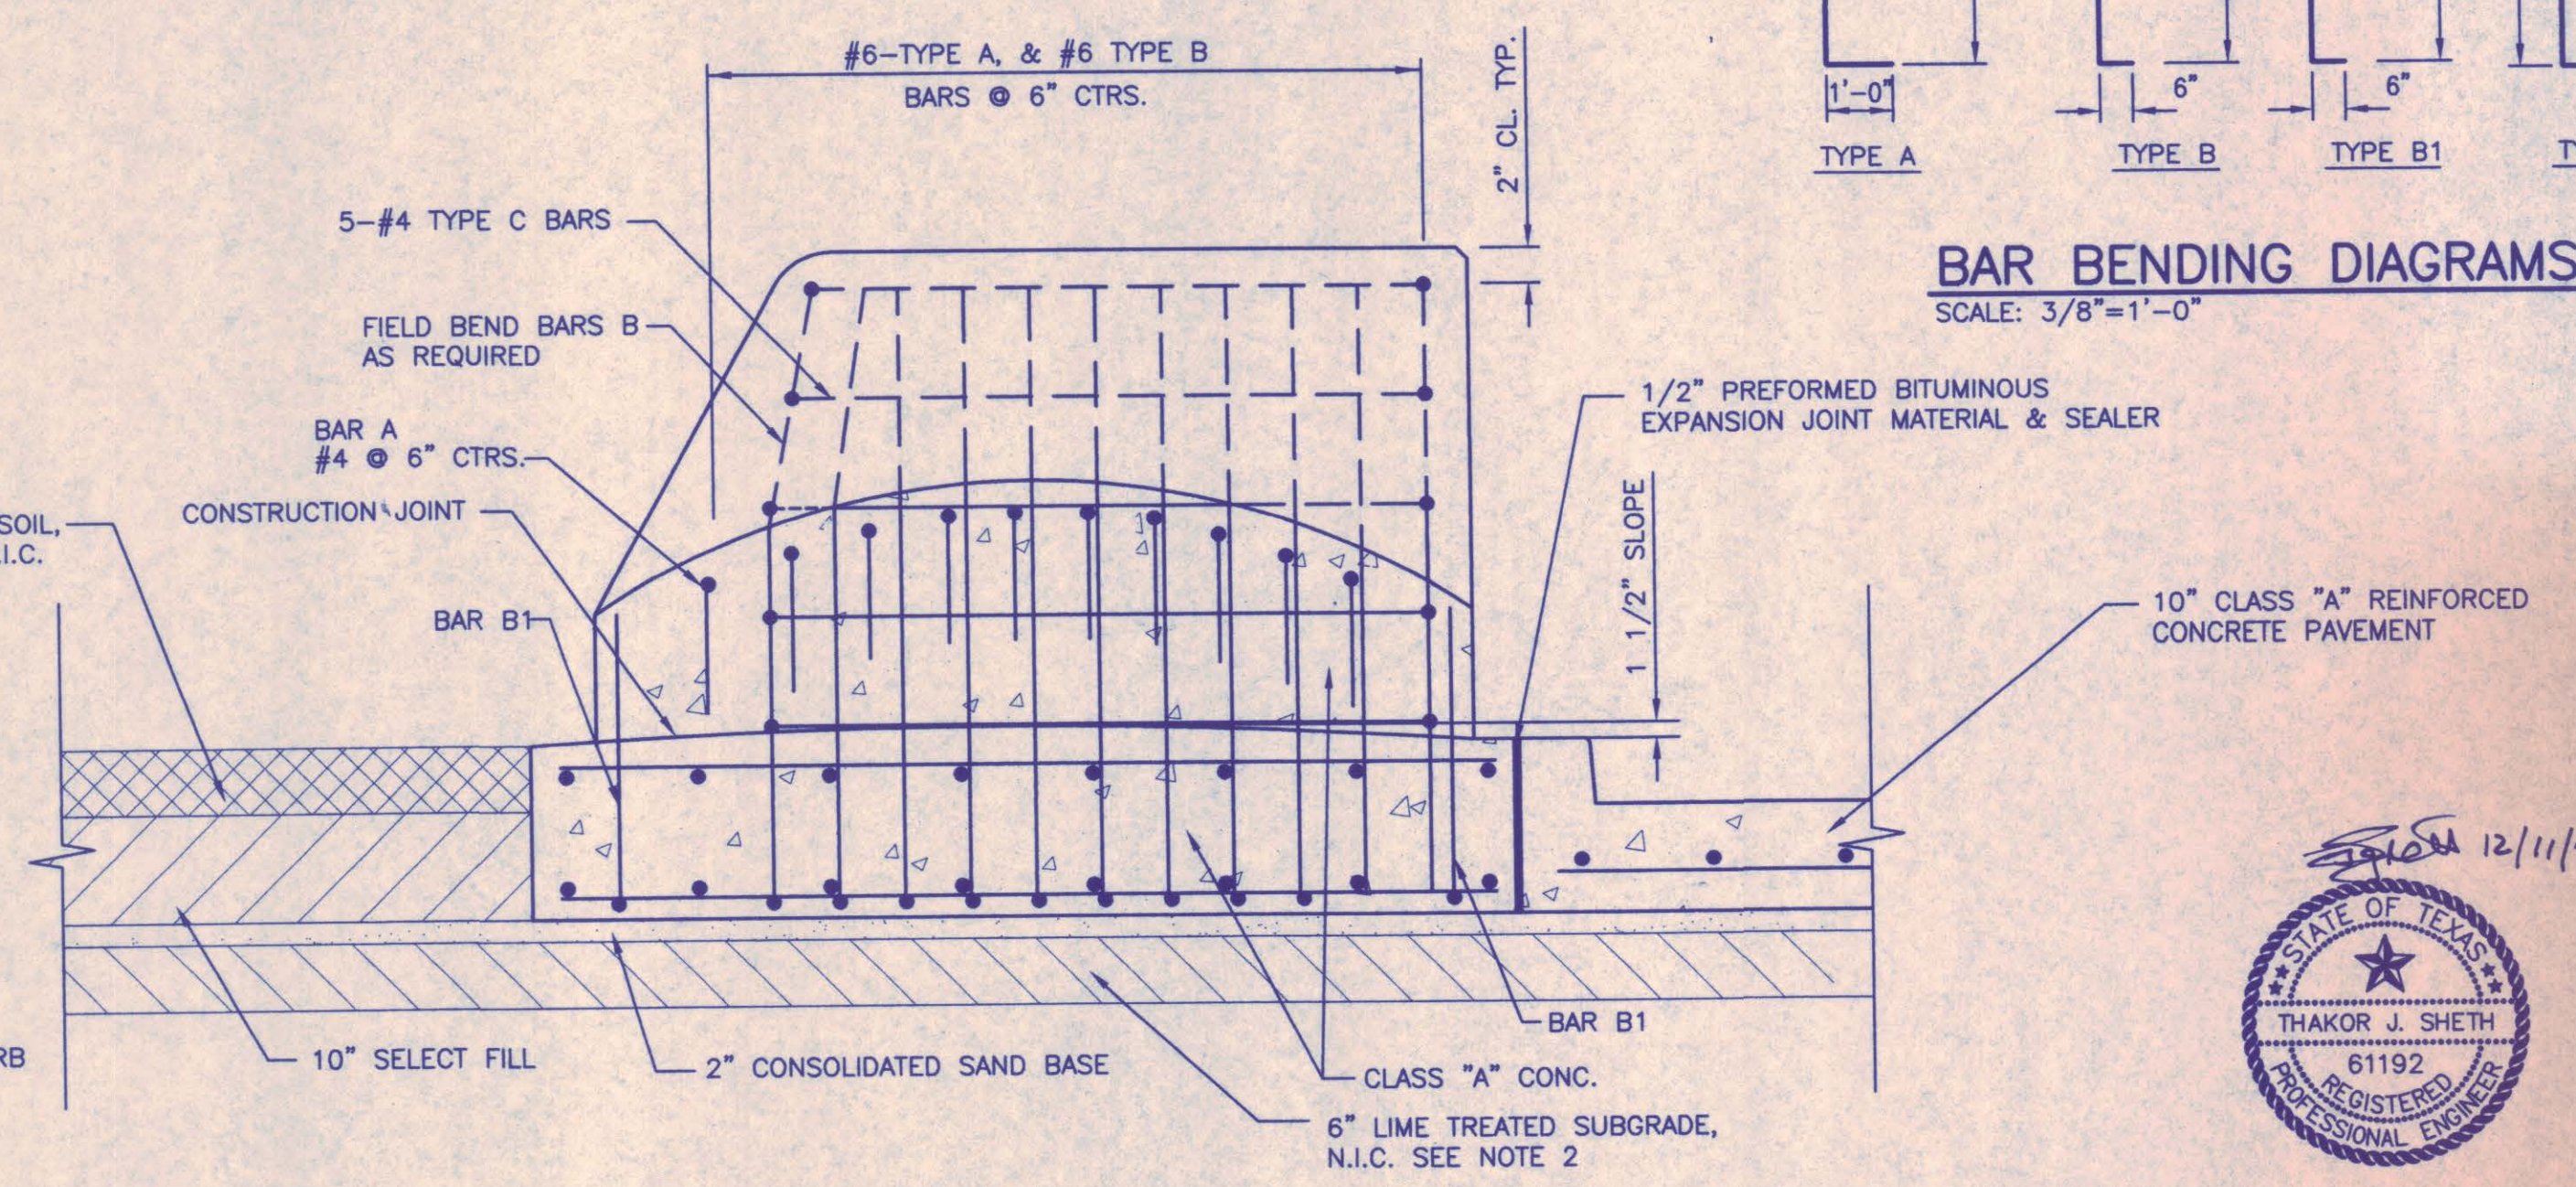

(4) SECTION
SCALE: 3/4"=1'-0"


- NOTES:**
- SEE GENERAL NOTE SHEET AT-C1.1
 - THE LIME TREATED SUBGRADE WITHIN AND ADJACENT TO THE TOLL PLAZA CONSTRUCTION LIMITS HAS PREVIOUSLY BEEN LIME TREATED AND STABILIZED BY OTHERS. IF THAT LIME STABILIZED SUBGRADE SUBSEQUENTLY IS DAMAGED BY THE CONTRACTOR'S CONSTRUCTION OPERATIONS, THE SUBGRADE SHALL BE REPAIRED WITH AVAILABLE STOCKPILED LIME TRIMMINGS OR LIME SLURRY AS DIRECTED BY THE ENGINEER.

Chiang, Patel & Yerby, Inc.
Consulting Engineers • Planners • Project Managers
Dallas • Fort Worth • Houston • San Antonio

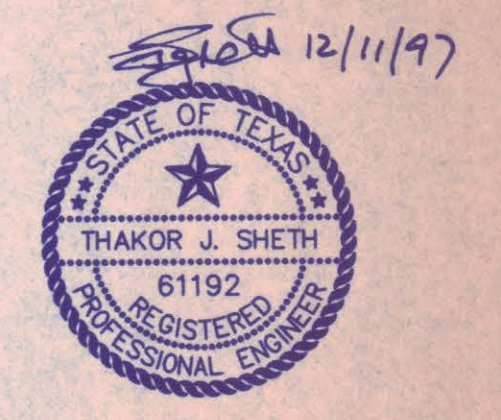

NO.	REVISION	BY	DATE
NORTH TEXAS TOLLWAY AUTHORITY ADDISON AIRPORT TUNNEL			
CONCRETE CRASH BUNKER DETAIL AND SECTIONS			
AGUIRRE ASSOCIATES INC. 12700 PARK CENTRAL DRIVE 16 TH FLOOR DALLAS TEXAS 75251 TEL (972) 788-1608		SECTION XIII	
DRAWN MM	DATE 8/28/97	DESIGNED MM	DATE 12/20/96
CHECKED TJS	DATE 11/5/97	SCALE AS SHOWN	
CONTRACT NO. DNT-290		SHEET 19 OF 53	

AT-C9.2

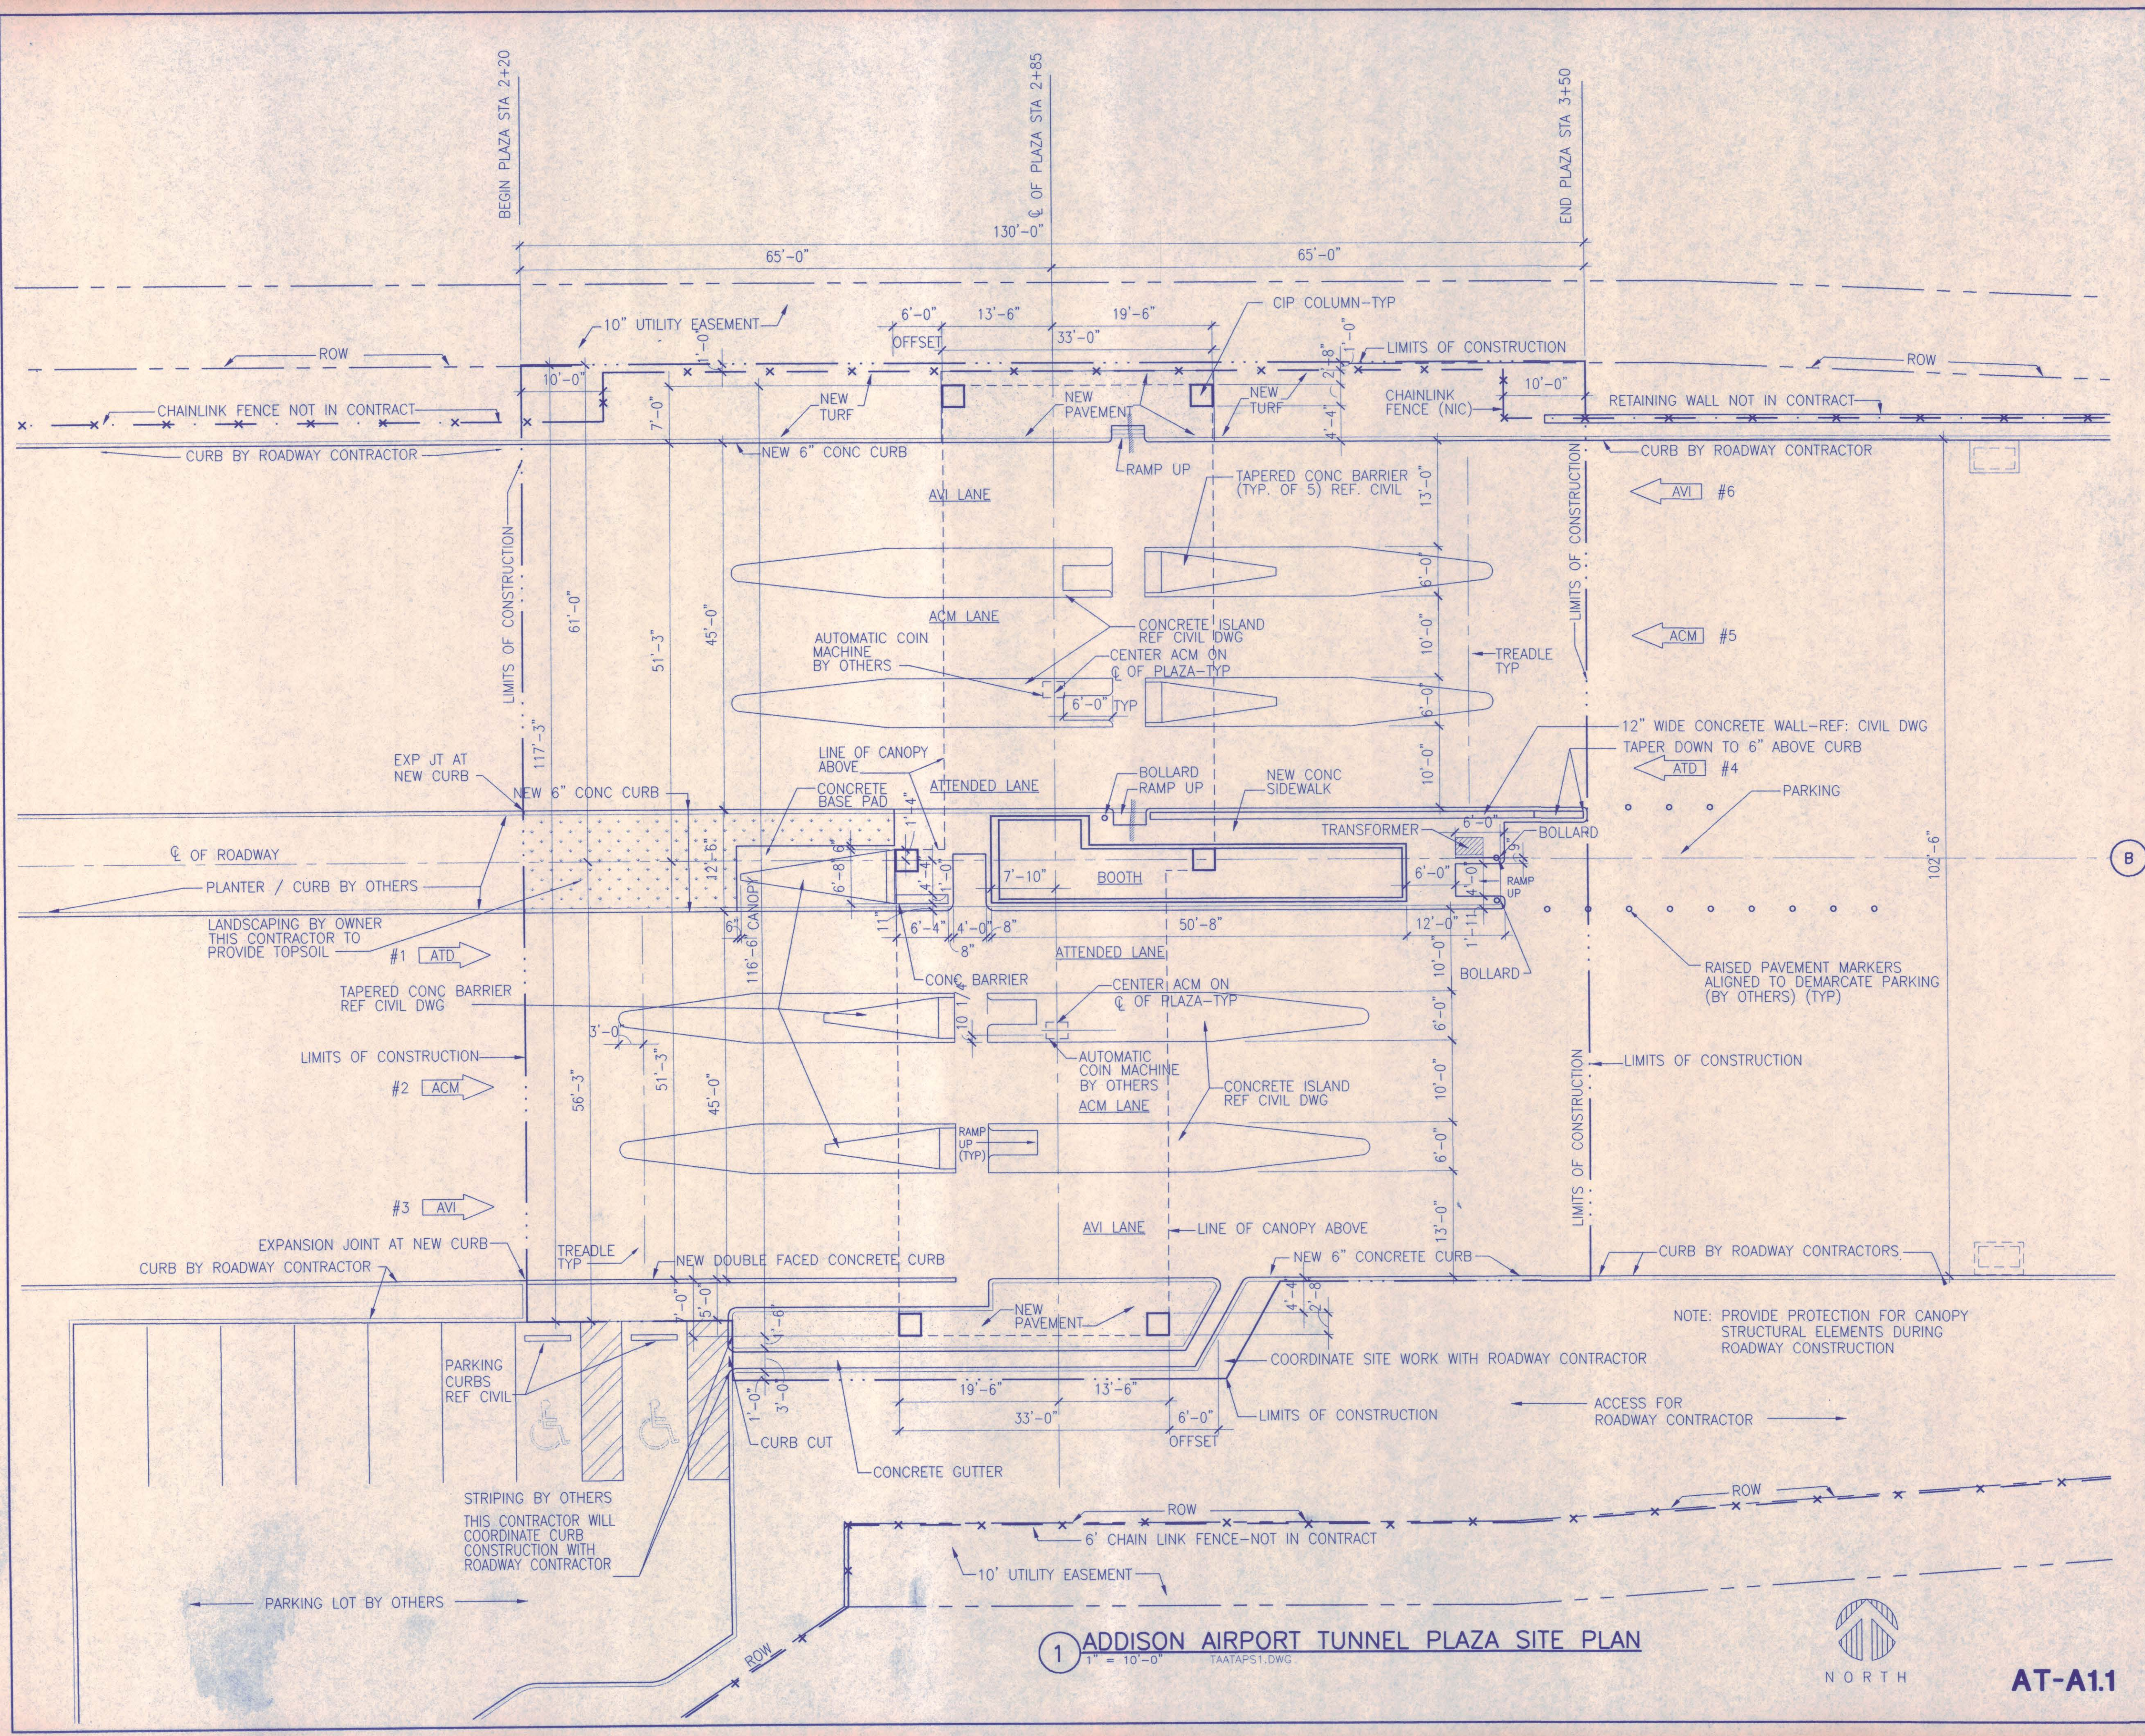

- GENERAL NOTES**
1. REFER TO CIVIL DRAWINGS FOR DIMENSIONED PLANS, GRADES, UTILITY LOCATIONS AND SITE DETAILS.
 2. SITE ELECTRICAL LOCATIONS ARE SHOWN ON ELECTRICAL SITE PLAN.
 3. BOOTH TRANSACTION AREA FINISH FLOOR ELEVATION AT 634.33 FEET ABOVE MEAN SEA LEVEL AND EQUAL TO DATUM ELEVATION OF 100'-0".
 4. REFER TO ARCHITECTURAL DRAWING SHEET AT-A2.1 FOR BOTH BUILDING PLANS.

LANE DESIGNATION KEY

XXX #N

LANE TYPE

LANE NUMBER

TRAFFIC DIRECTION

LANE TYPES:

- AVI - AUTOMATIC VEHICLE ID (TOLLTAG®)
- ACM - AUTOMATIC COIN MACHINE
- ATD - ATTENDED LANE





1 ADDISON AIRPORT TUNNEL PLAZA SITE PLAN
1" = 10'-0" TAATAPS1.DWG




AT-A1.1

NO.		REVISION	BY	DATE
NORTH TEXAS TOLLWAY AUTHORITY ADDISON AIRPORT TUNNEL BARRIER TOLL PLAZA				
TUNNEL PLAZA SITE PLAN				
AGUIRRE Corporation 3700 PARK CENTRAL DRIVE 15 TH FLOOR DALLAS TEXAS 75201 TEL. (972) 758-9508				SECTION XIII
CHECKED <i>Jon</i>	DATE 12/18/97	DESIGNED MM	DATE 8/15/96	
CHECKED <i>kg</i>	DATE 12/18/97	SCALE 1"=1'-0"		
CONTRACT NO. DNT-290		SHEET 20 OF 53		

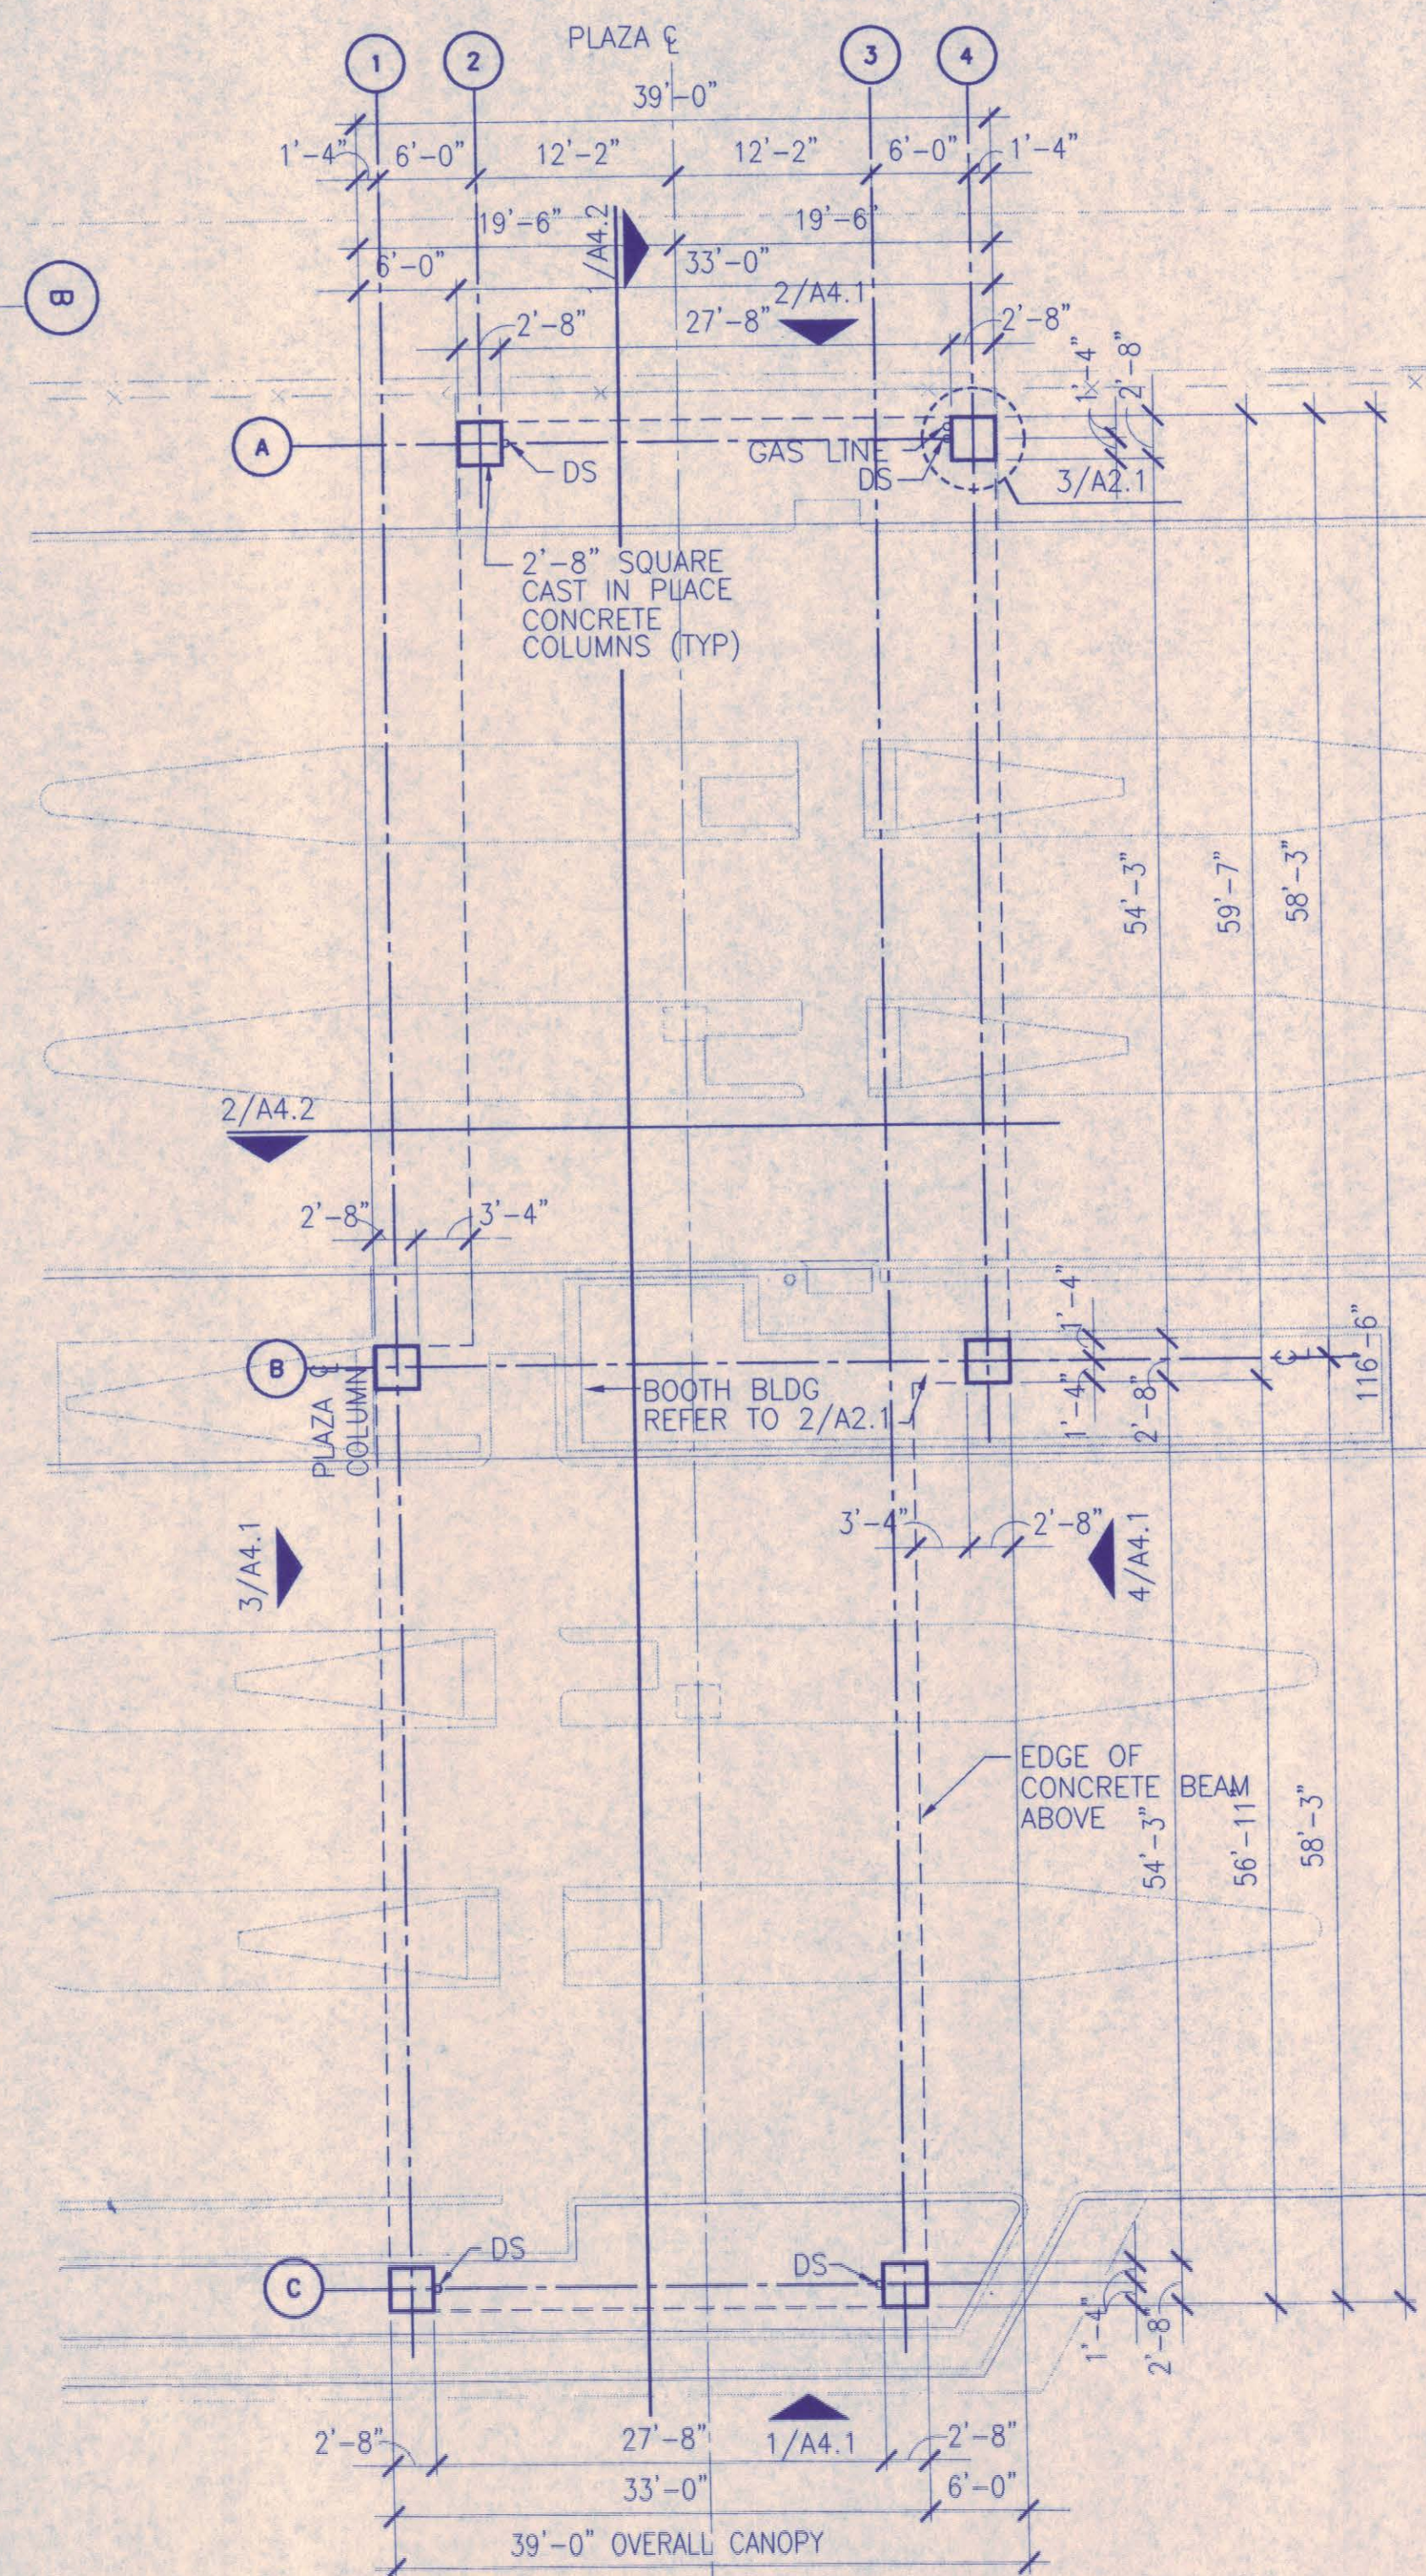


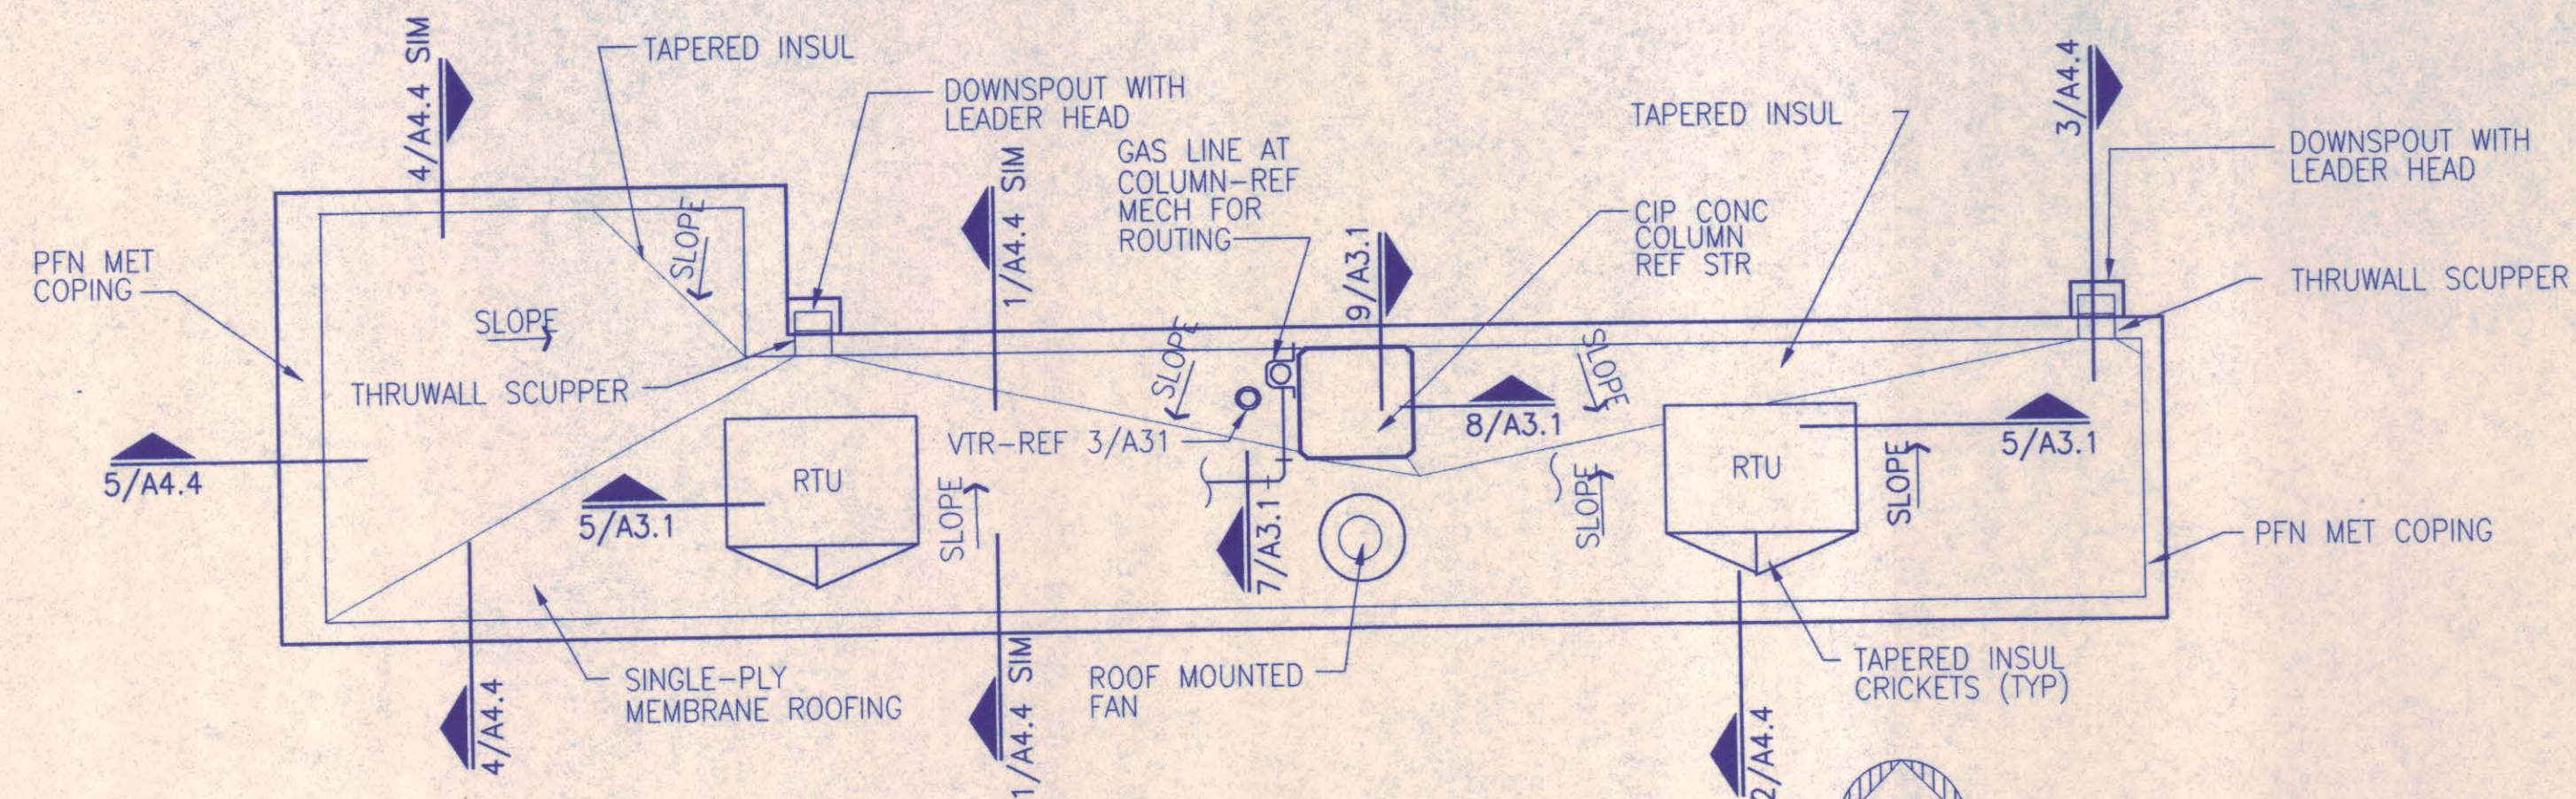


2 BOOTH ROOF PLAN
1/4"=1'-0" TAATAPR2.DWG

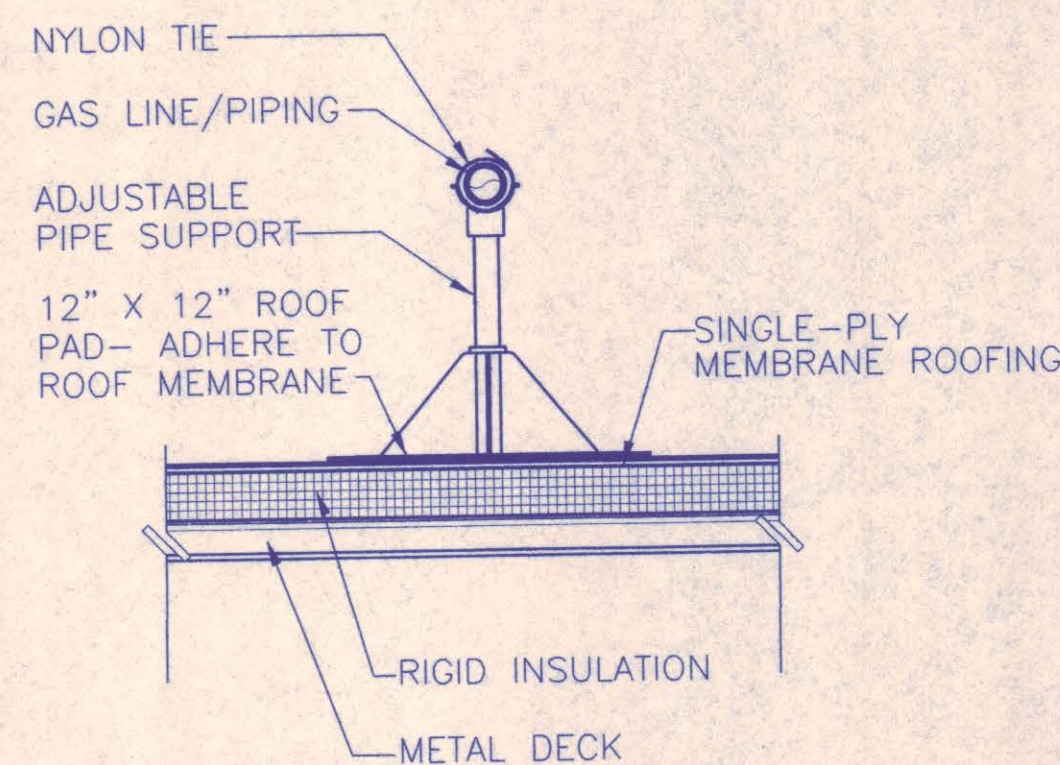


7 PIPE SUPPORT DETAIL @ BOOTH
1 1/2"=1'-0" TAATAD19

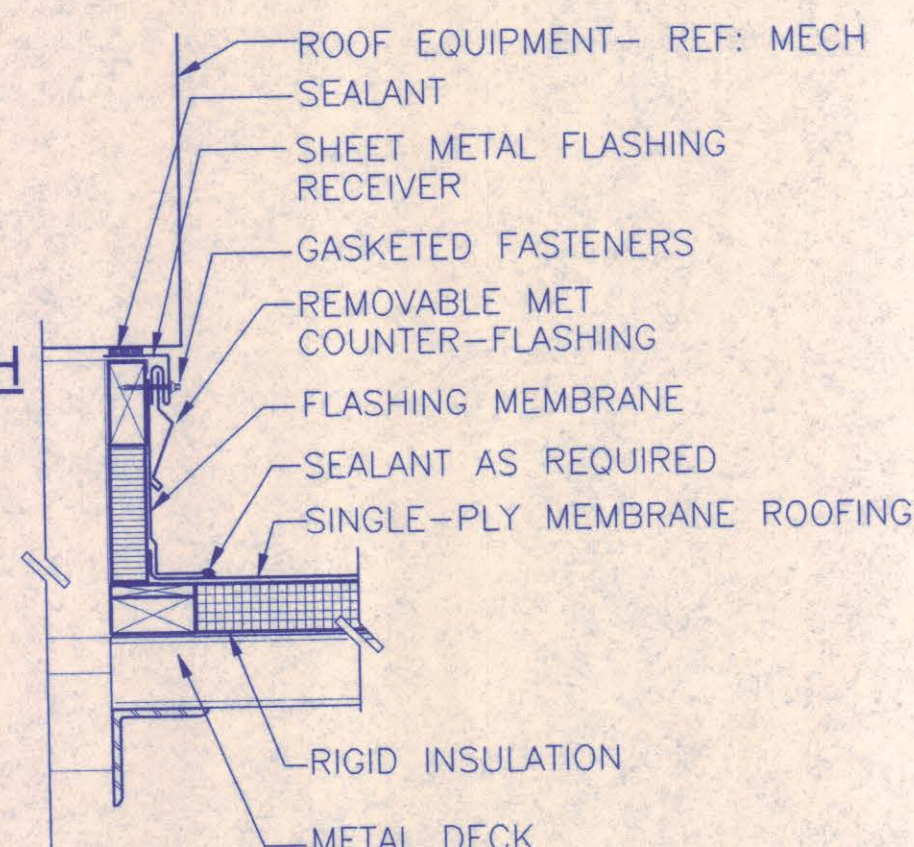


5 ROOF CURB DETAIL @ BOOTH
1 1/2"=1'-0" TAATAD12

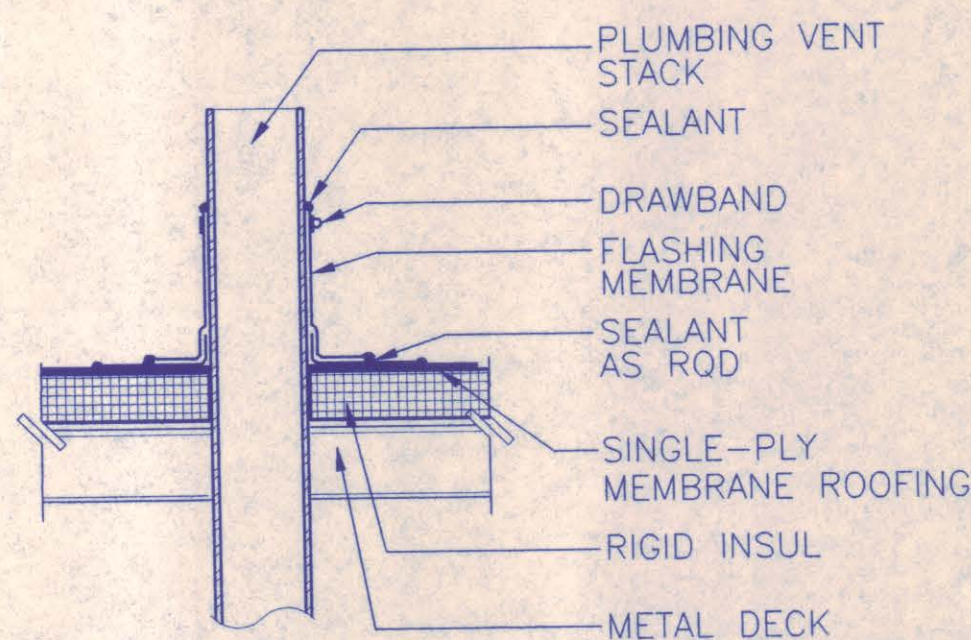


3 ROOF PENETRATION DETAIL @ BOOTH
1 1/2"=1'-0" TAATAD11

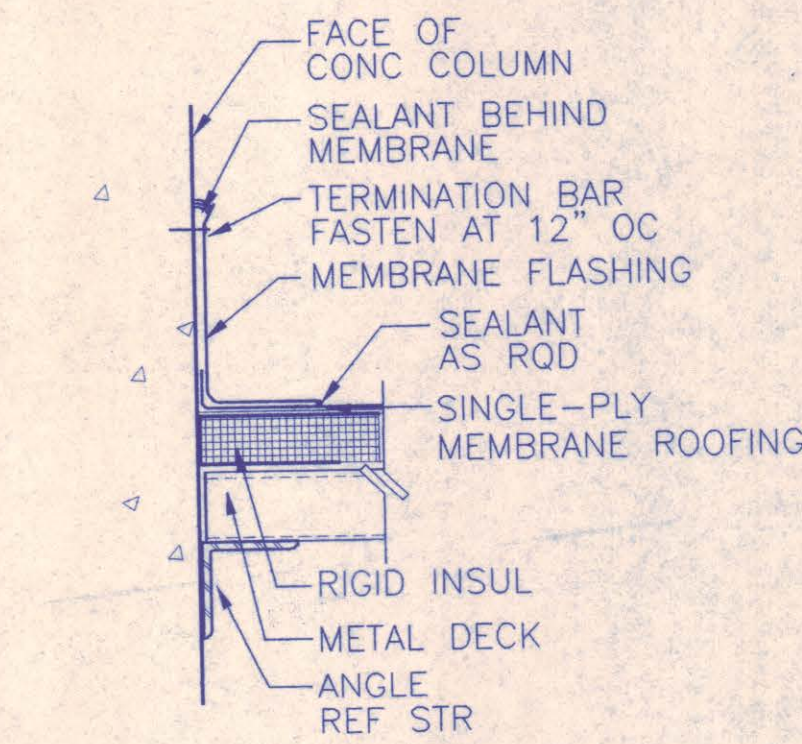


8 FLASHING @ COLUMN
1 1/2"=1'-0" TAATAD43

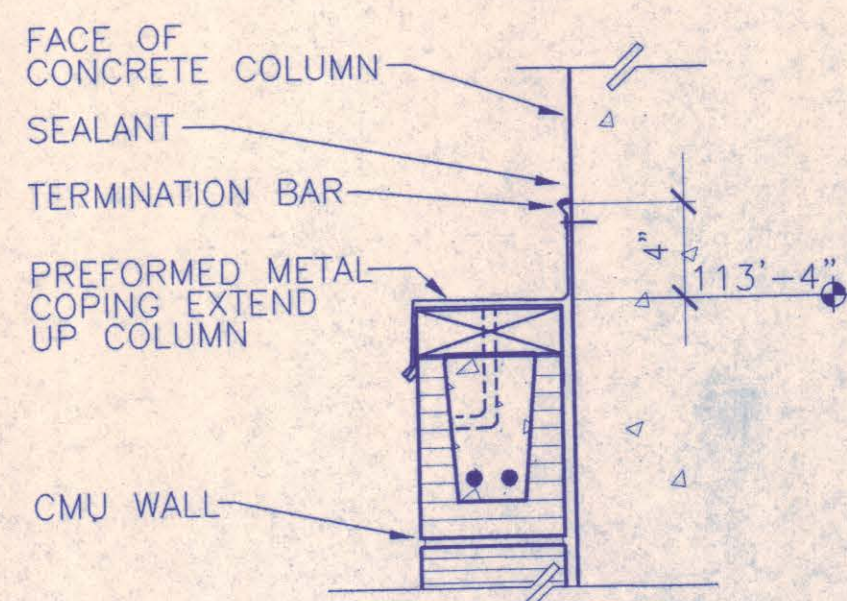


9 FLASHING DETAIL
1 1/2"=1'-0" TAATAD44

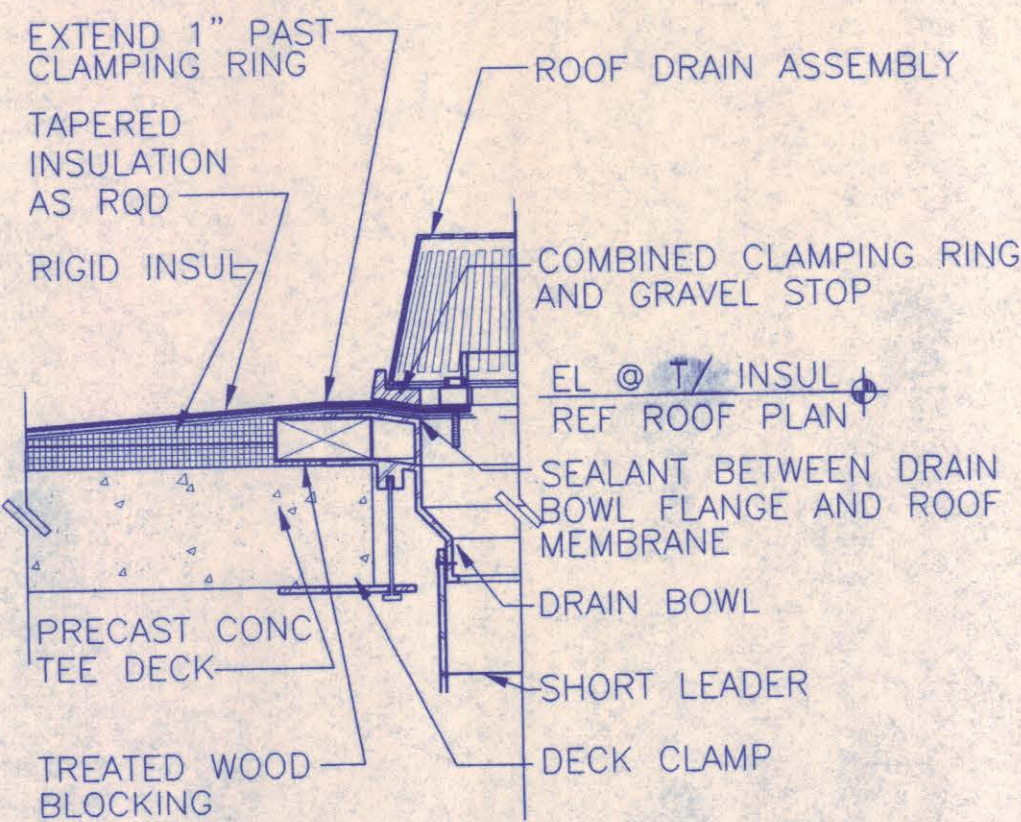


6 OVERFLOW DRAIN DETAIL
1 1/2"=1'-0" TAATAD18.DWG

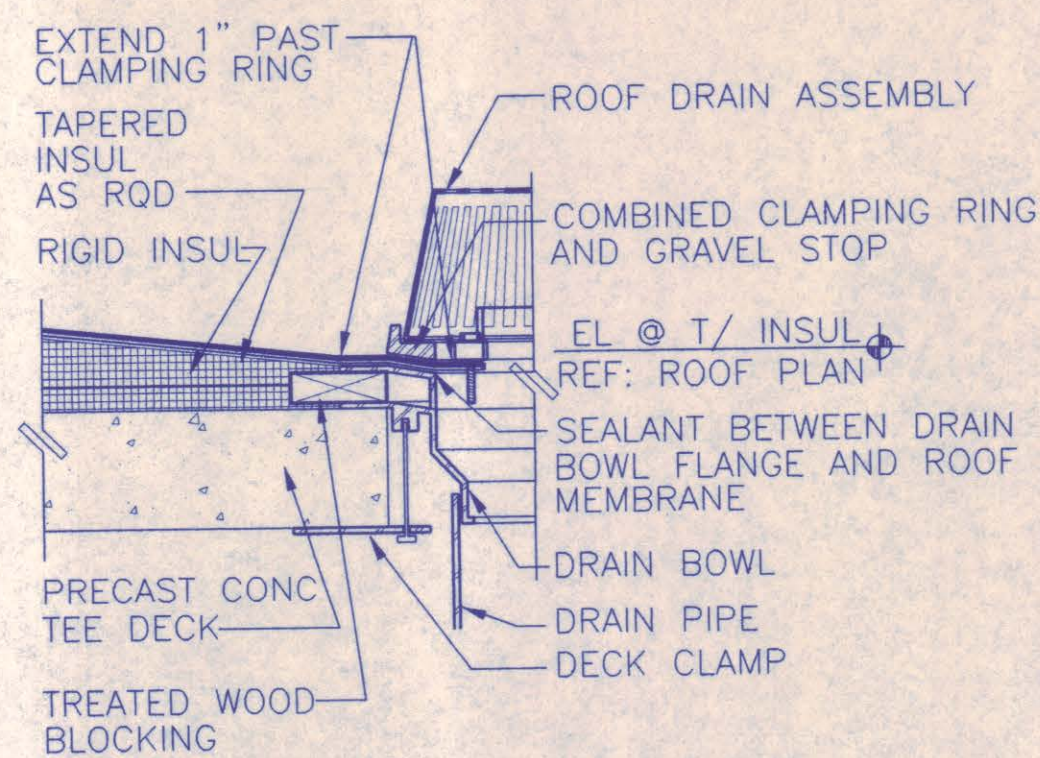

4 ROOF DRAIN DETAIL
1 1/2"=1'-0" TAATAD15.DWG

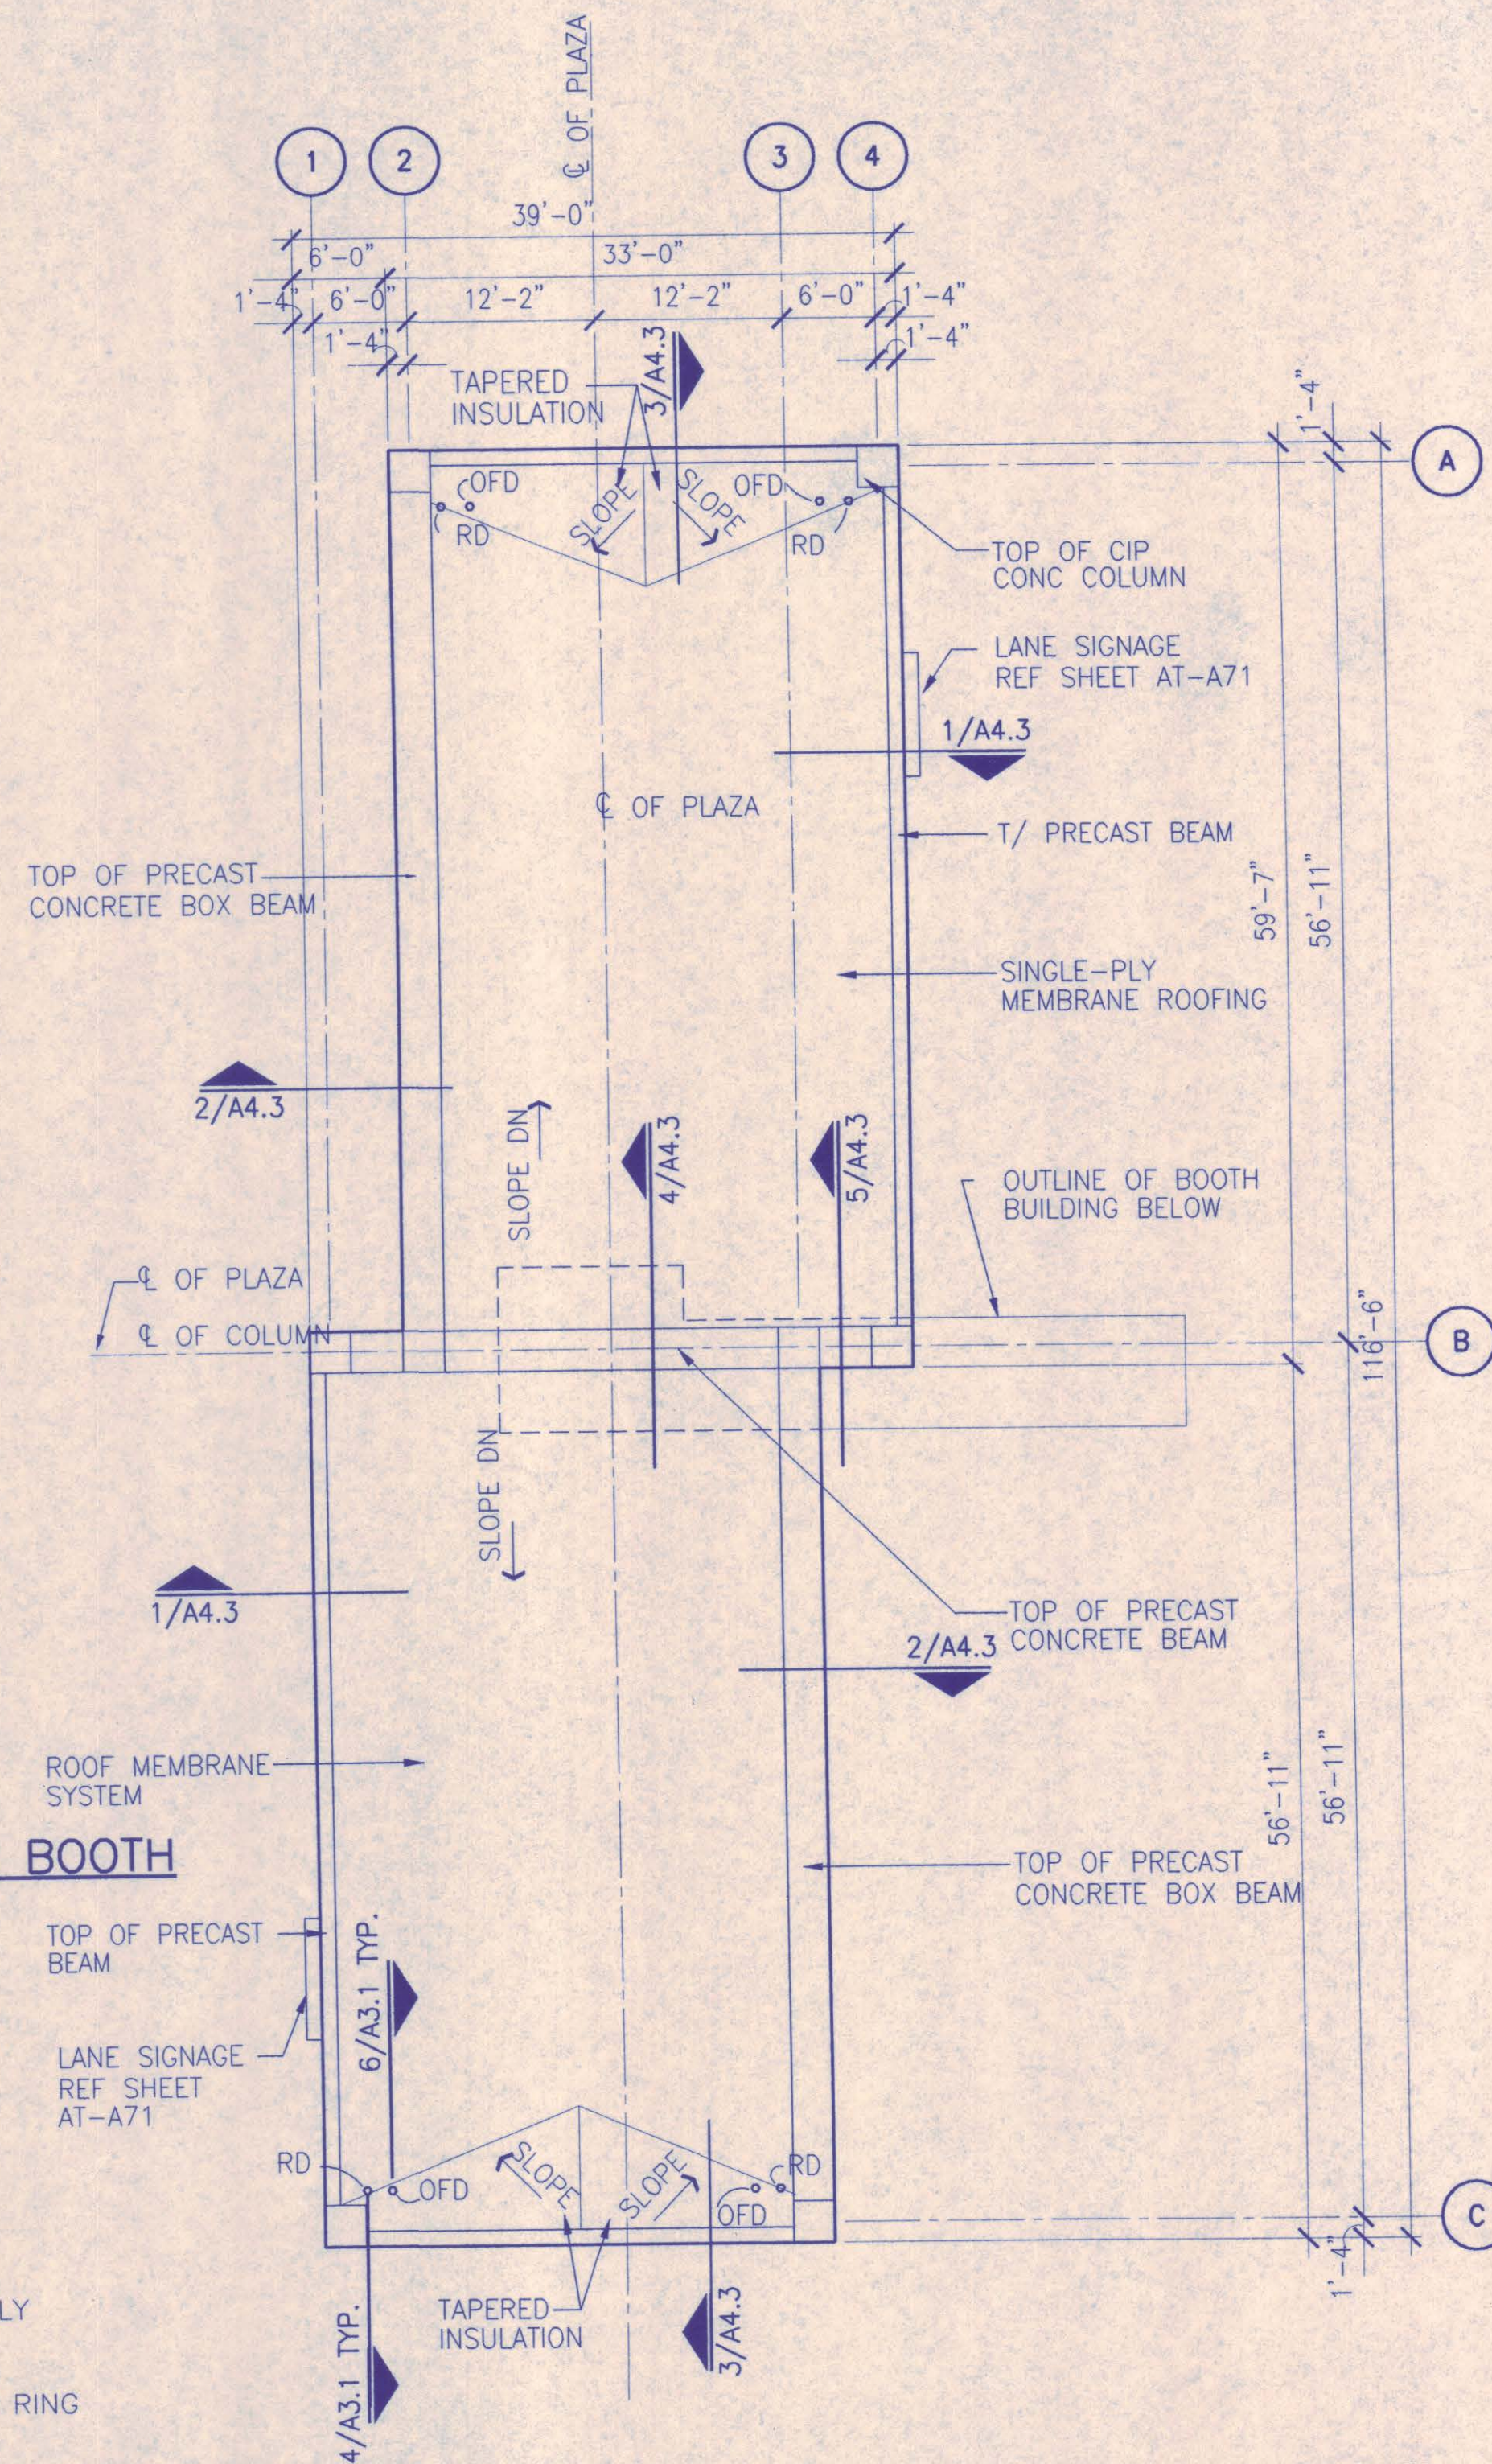


1 CANOPY ROOF PLAN
1/8"=1'-0" TAATAPR1.DWG

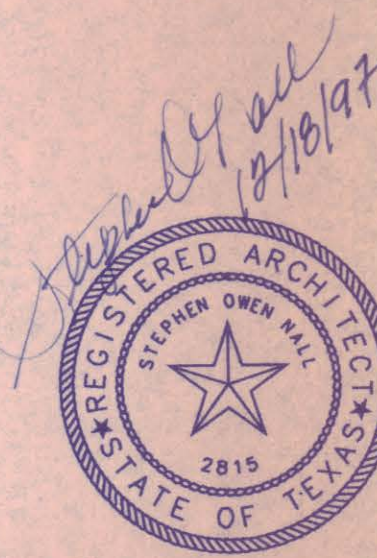


NO.	REVISION	BY	DATE
NORTH TEXAS TOLLWAY AUTHORITY			
ADDISON AIRPORT TUNNEL			
BARRIER TOLL PLAZA			
TUNNEL PLAZA			
CANOPY ROOF PLAN			
AGUIRRE Corporation 1800 PARK CENTRAL DRIVE 16 TH FLOOR DALLAS TEXAS 75201 TEL 972 768-9008			SECTION XIII
CHECKED <i>[Signature]</i>	DATE 12/18/97	DESIGNED MM	DATE 8/15/96
CHECKED <i>[Signature]</i>	DATE 12/18/97	AS SHOWN	SCALE
CONTRACT NO. DNT-290		SHEET 22 OF 53	


AT-A3.1

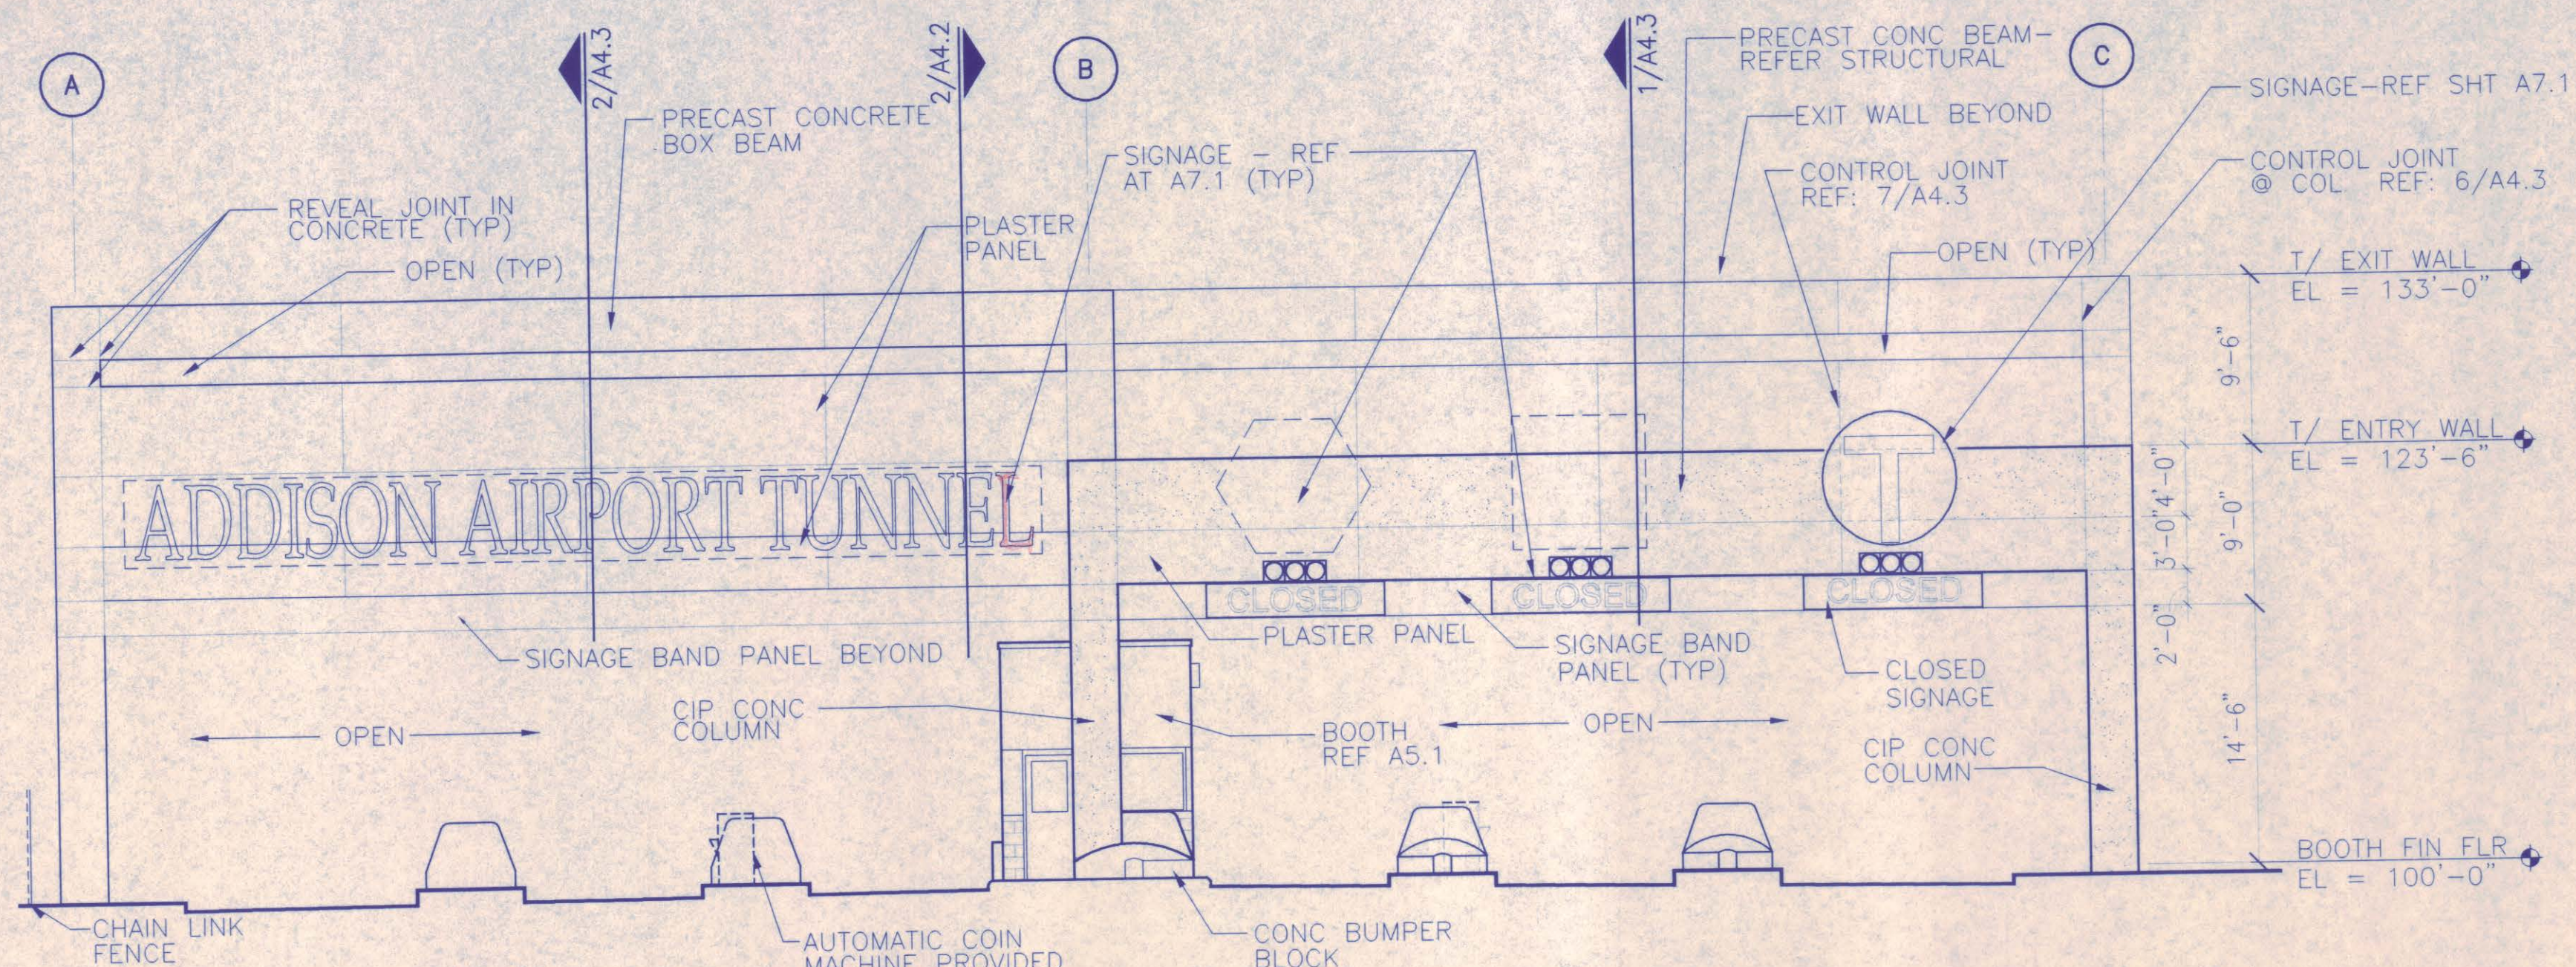


3 CANOPY ELEVATION-WEST
1/8"=1'-0"

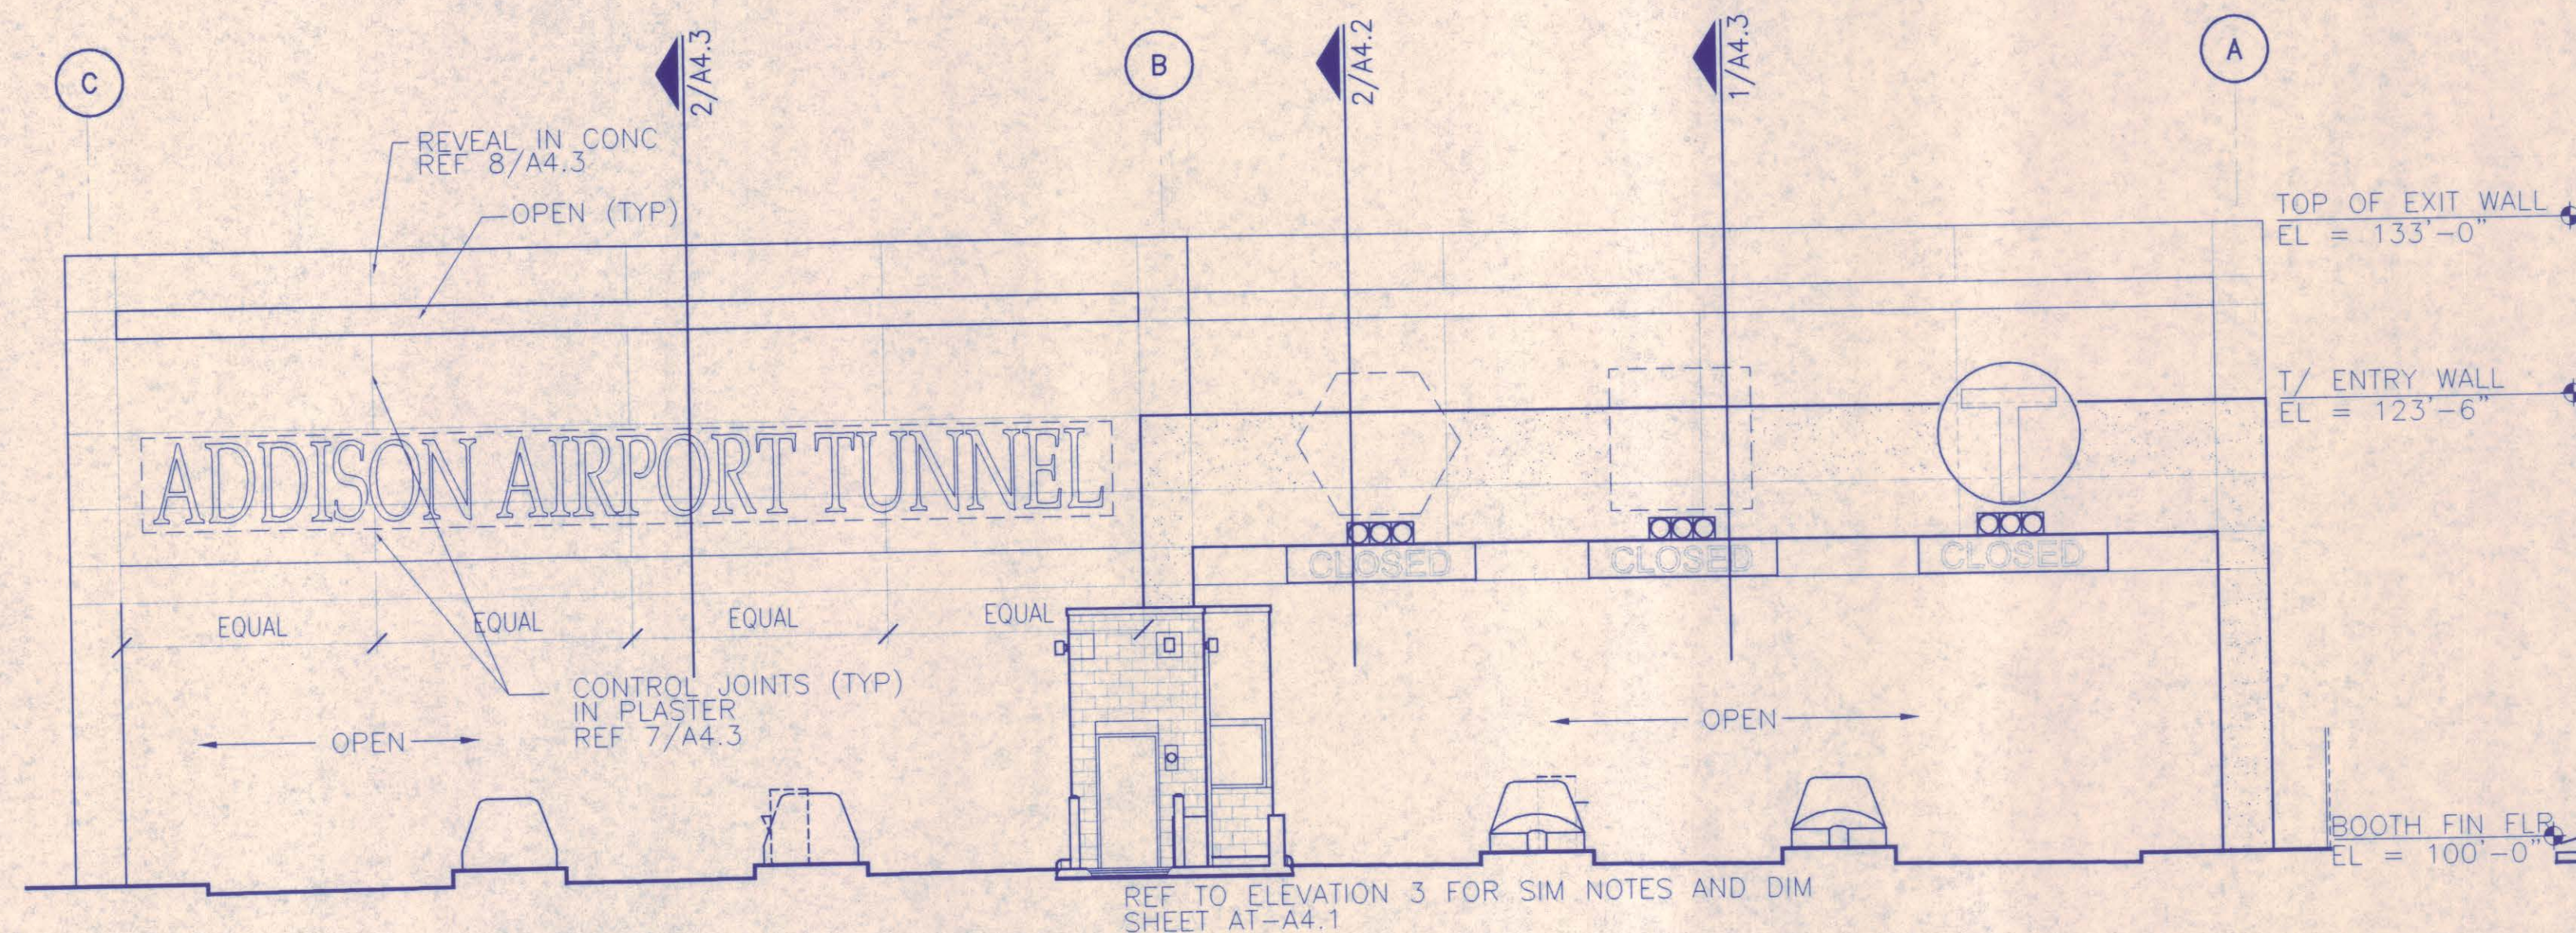

4 CANOPY ELEVATION-EAST
1/8"=1'-0"

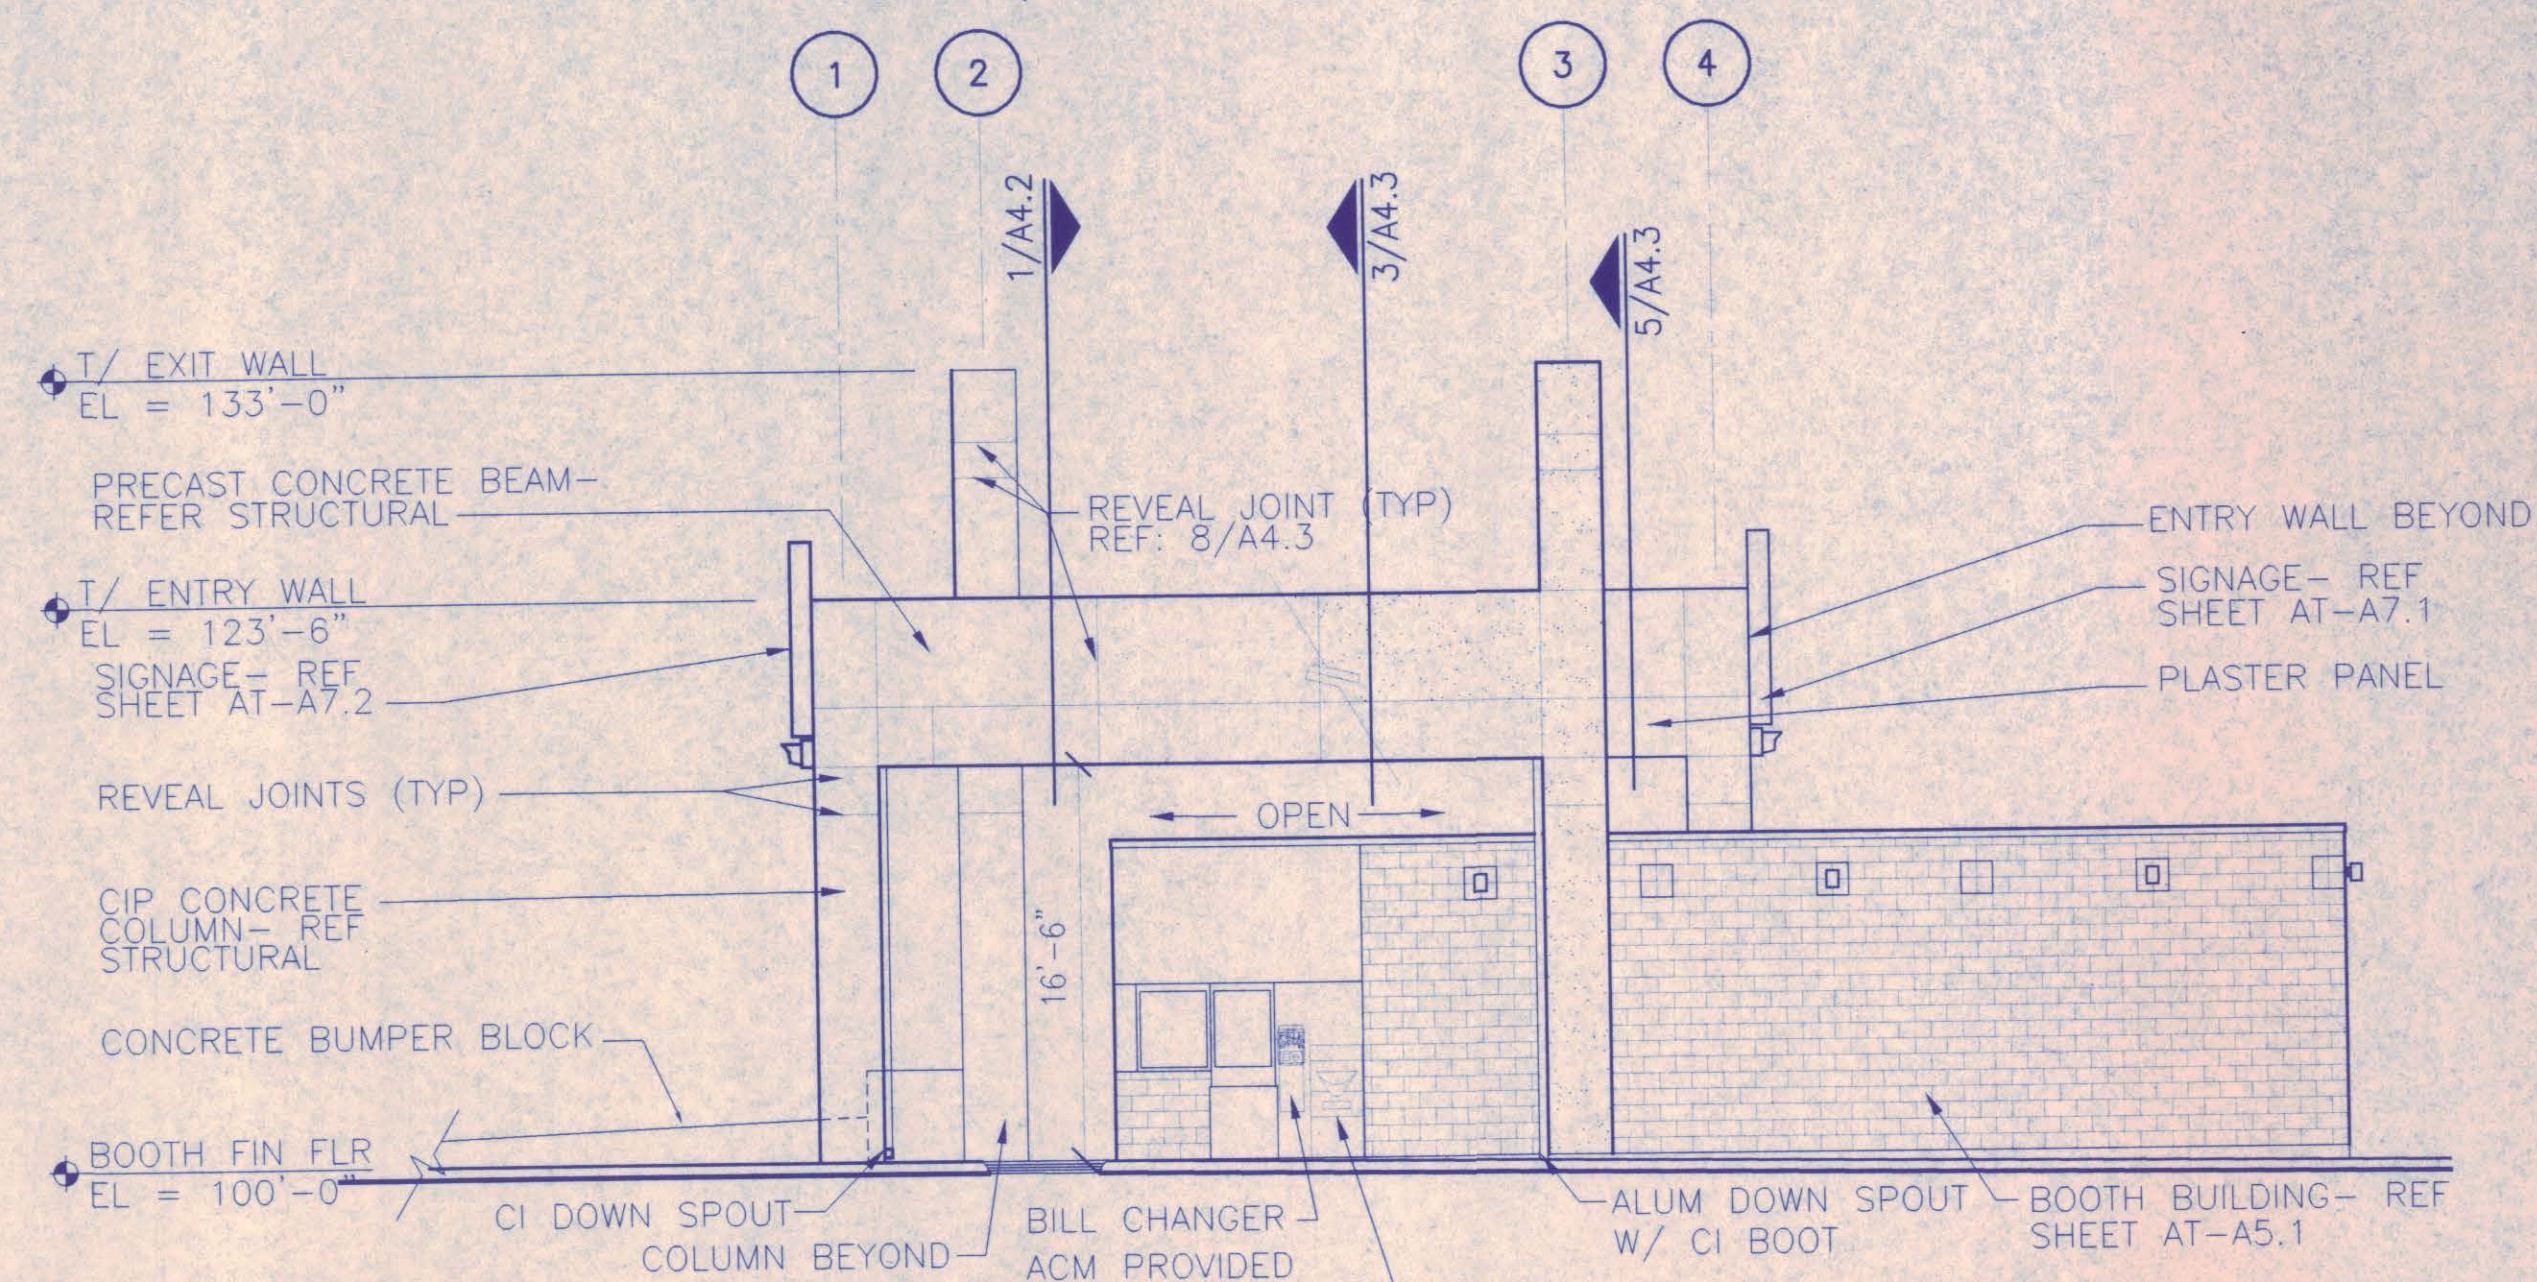

1 CANOPY ELEVATION-SOUTH
1/8"=1'-0"

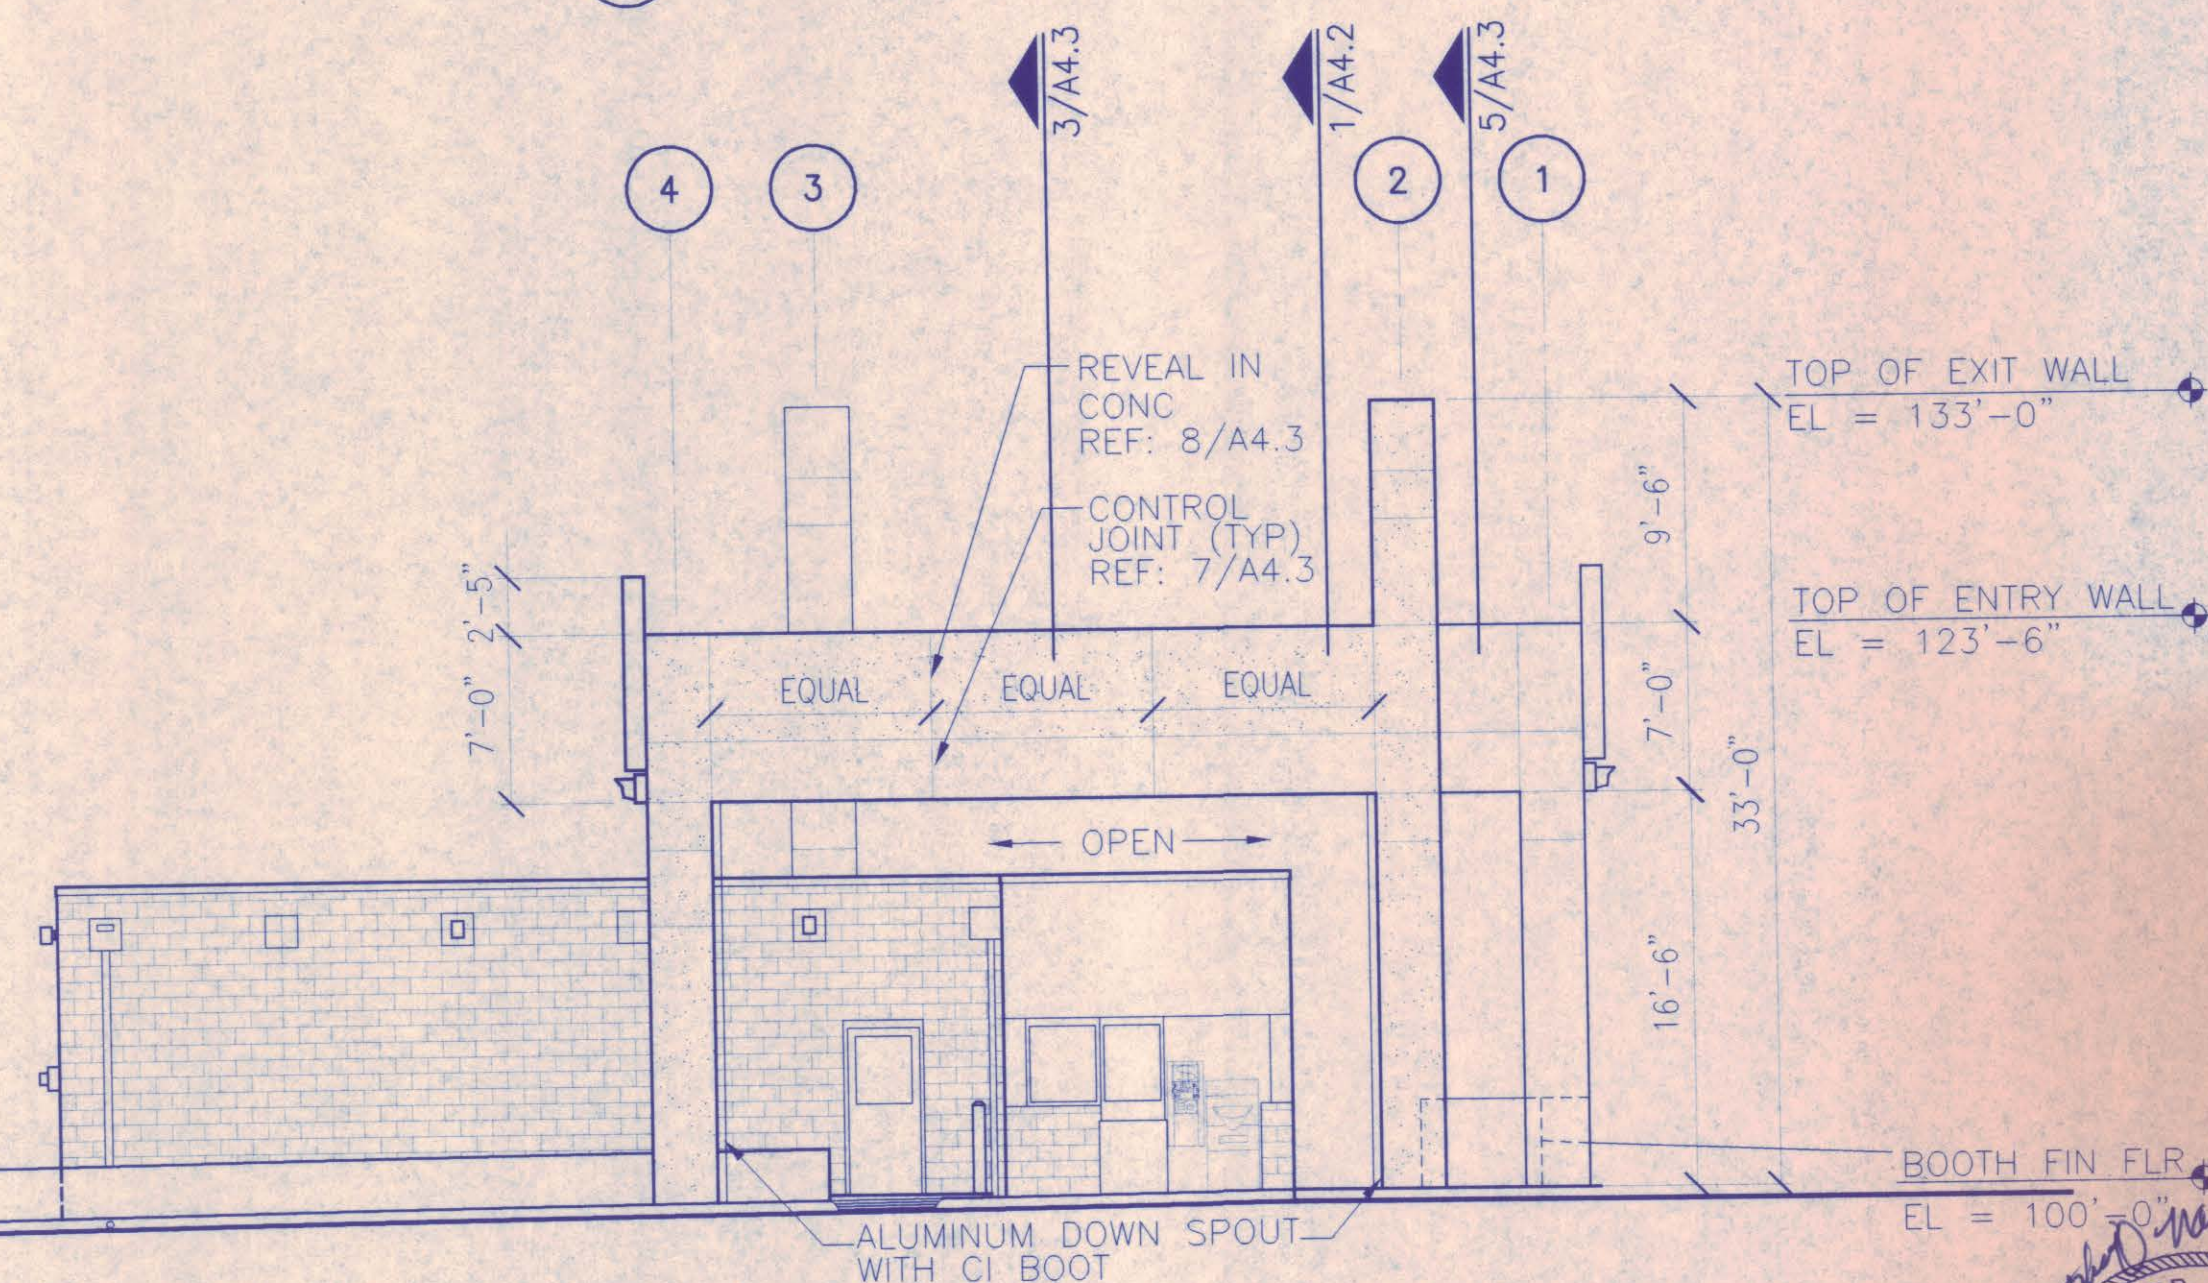


2 CANOPY ELEVATION-NORTH
1/8"=1'-0"

GENERAL NOTES:


- ALL EXPOSED CAST IN PLACE CONCRETE COLUMNS TO RECEIVE SAND BLAST FINISH AND SEALER.
- ALL EXPOSED PRE-CAST SPANDREL AND BOX BEAMS TO RECEIVE SAND BLAST FINISH AND SEALER.
- DO NOT SANDBLAST PRECAST CONC TEE MEMBERS

AT-A4.1


NO.	REVISION	BY	DATE
NORTH TEXAS TOLLWAY AUTHORITY ADDISON AIRPORT TUNNEL BARRIER TOLL PLAZA			
TUNNEL PLAZA CANOPY ELEVATIONS			
AGUIRRE Corporation 12700 PARK CENTRAL DRIVE 16 TH FLOOR DALLAS TEXAS 75241 TEL. (972) 788-1008			SECTION XIII
CHECKED <i>[Signature]</i>	DATE 12/18/97	DESIGNED MM	DATE 8/15/96
CHECKED <i>[Signature]</i>	DATE 12/18/97	SCALE 1/8"=1'-0"	
CONTRACT NO. DNT-290	SHEET 23	OF 53	

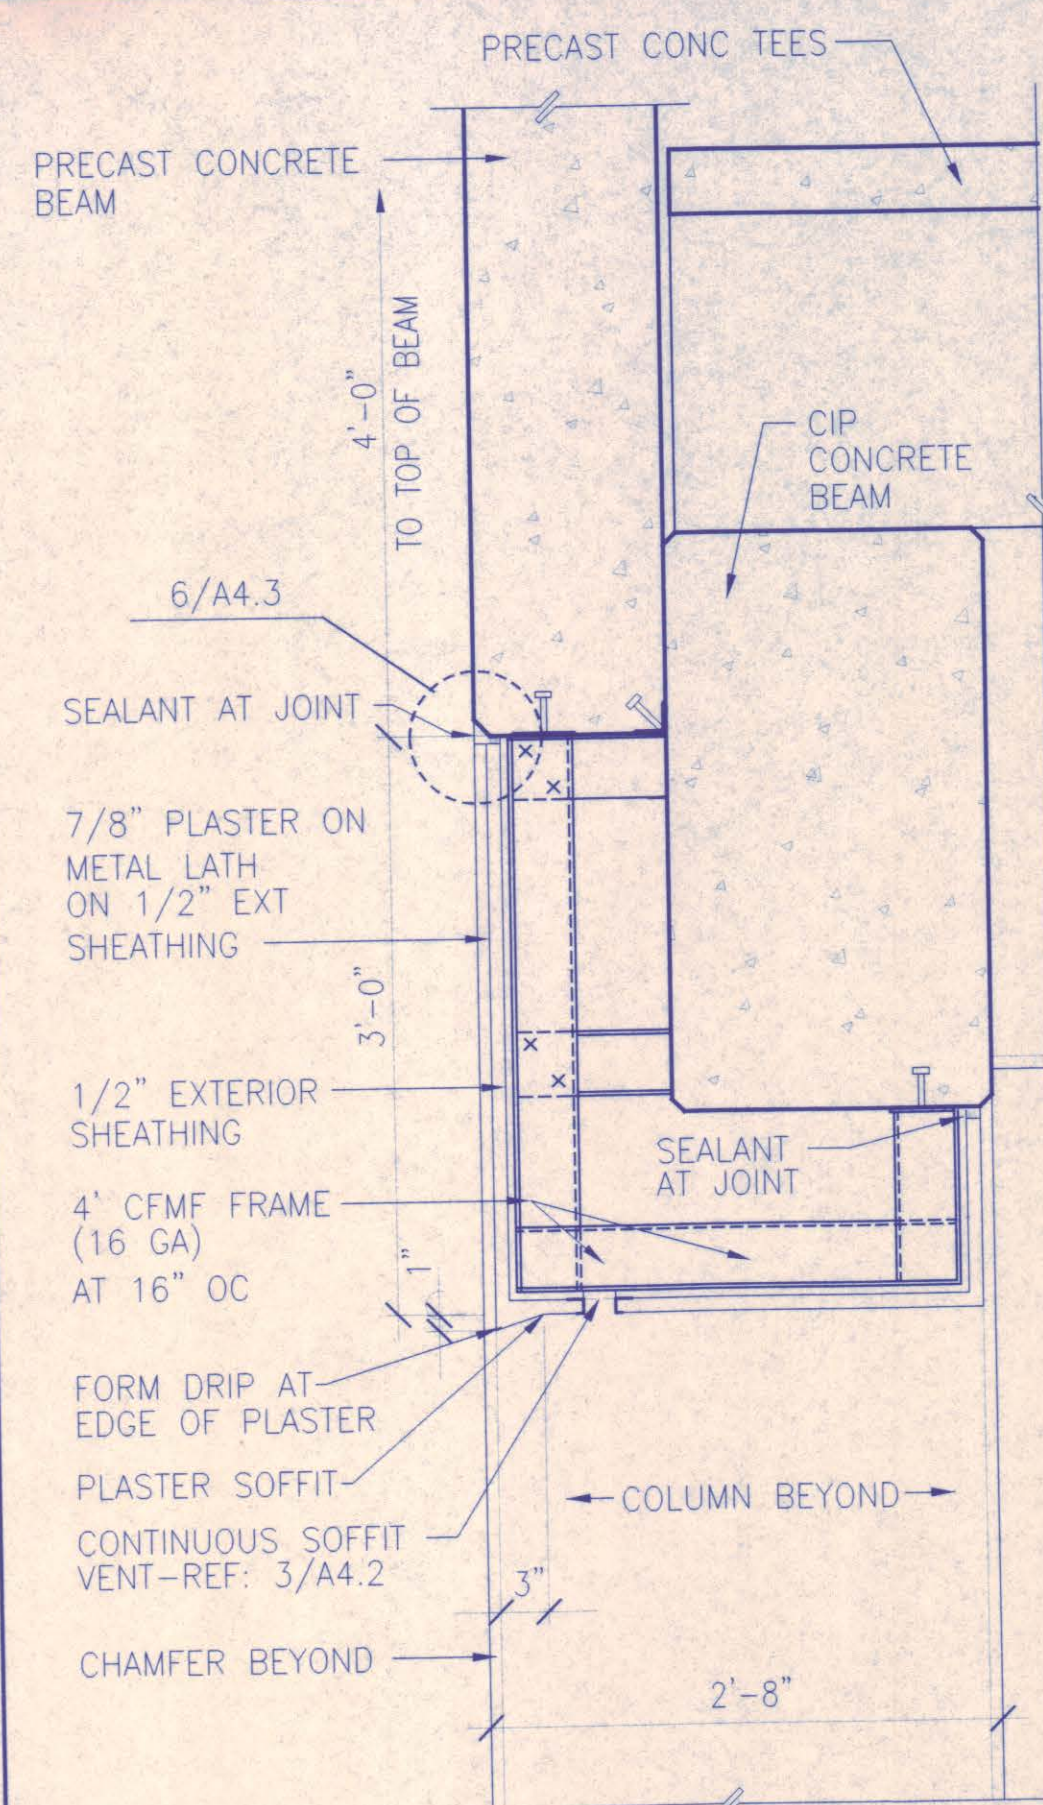


7 SECTION AT SIDE WALL
1"=1'-0"

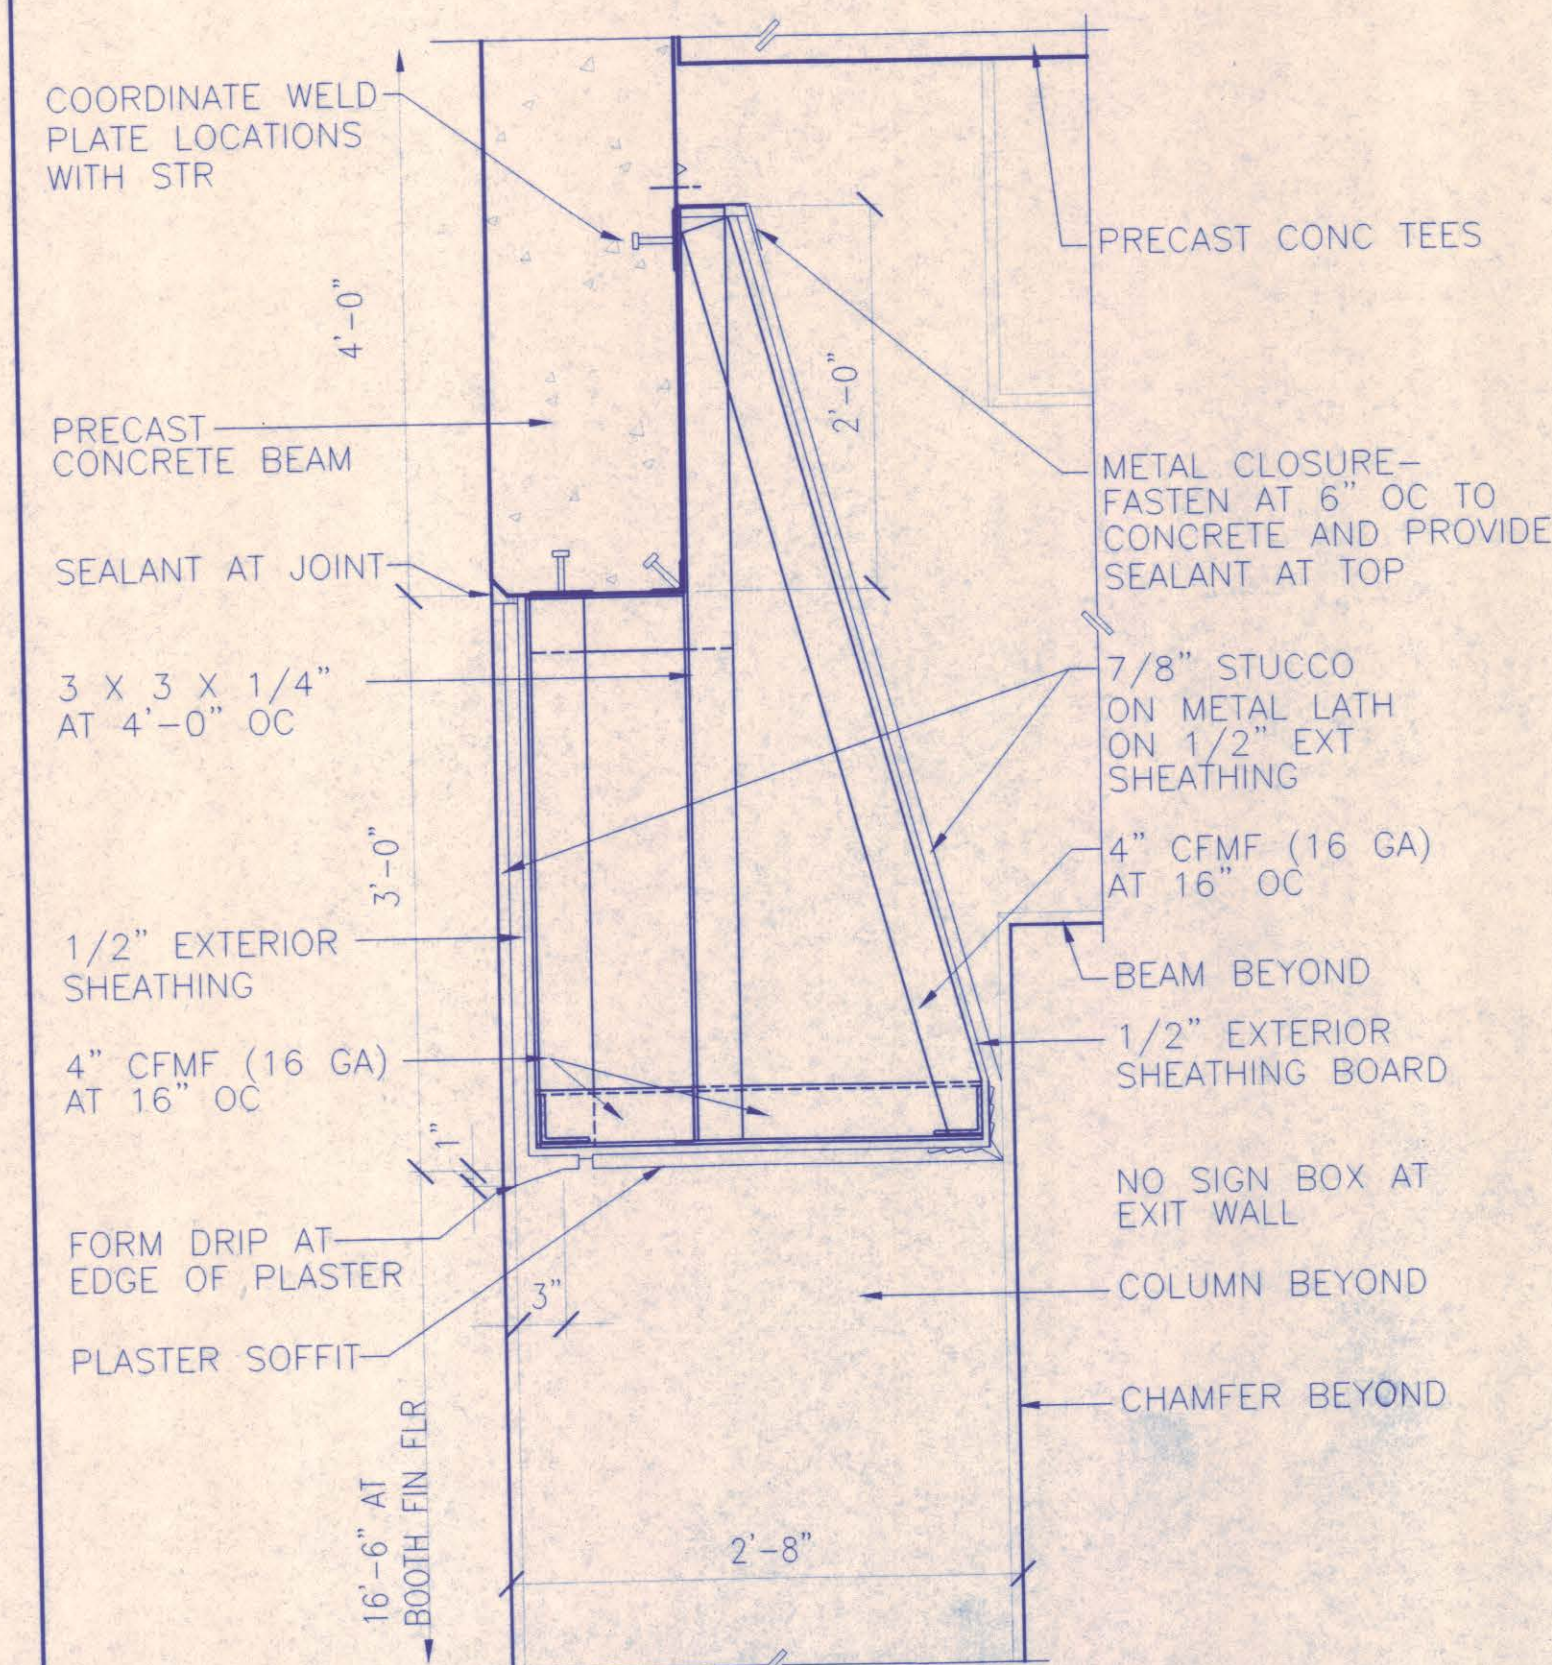


5 SECTION AT EXIT WALL
1"=1'-0"

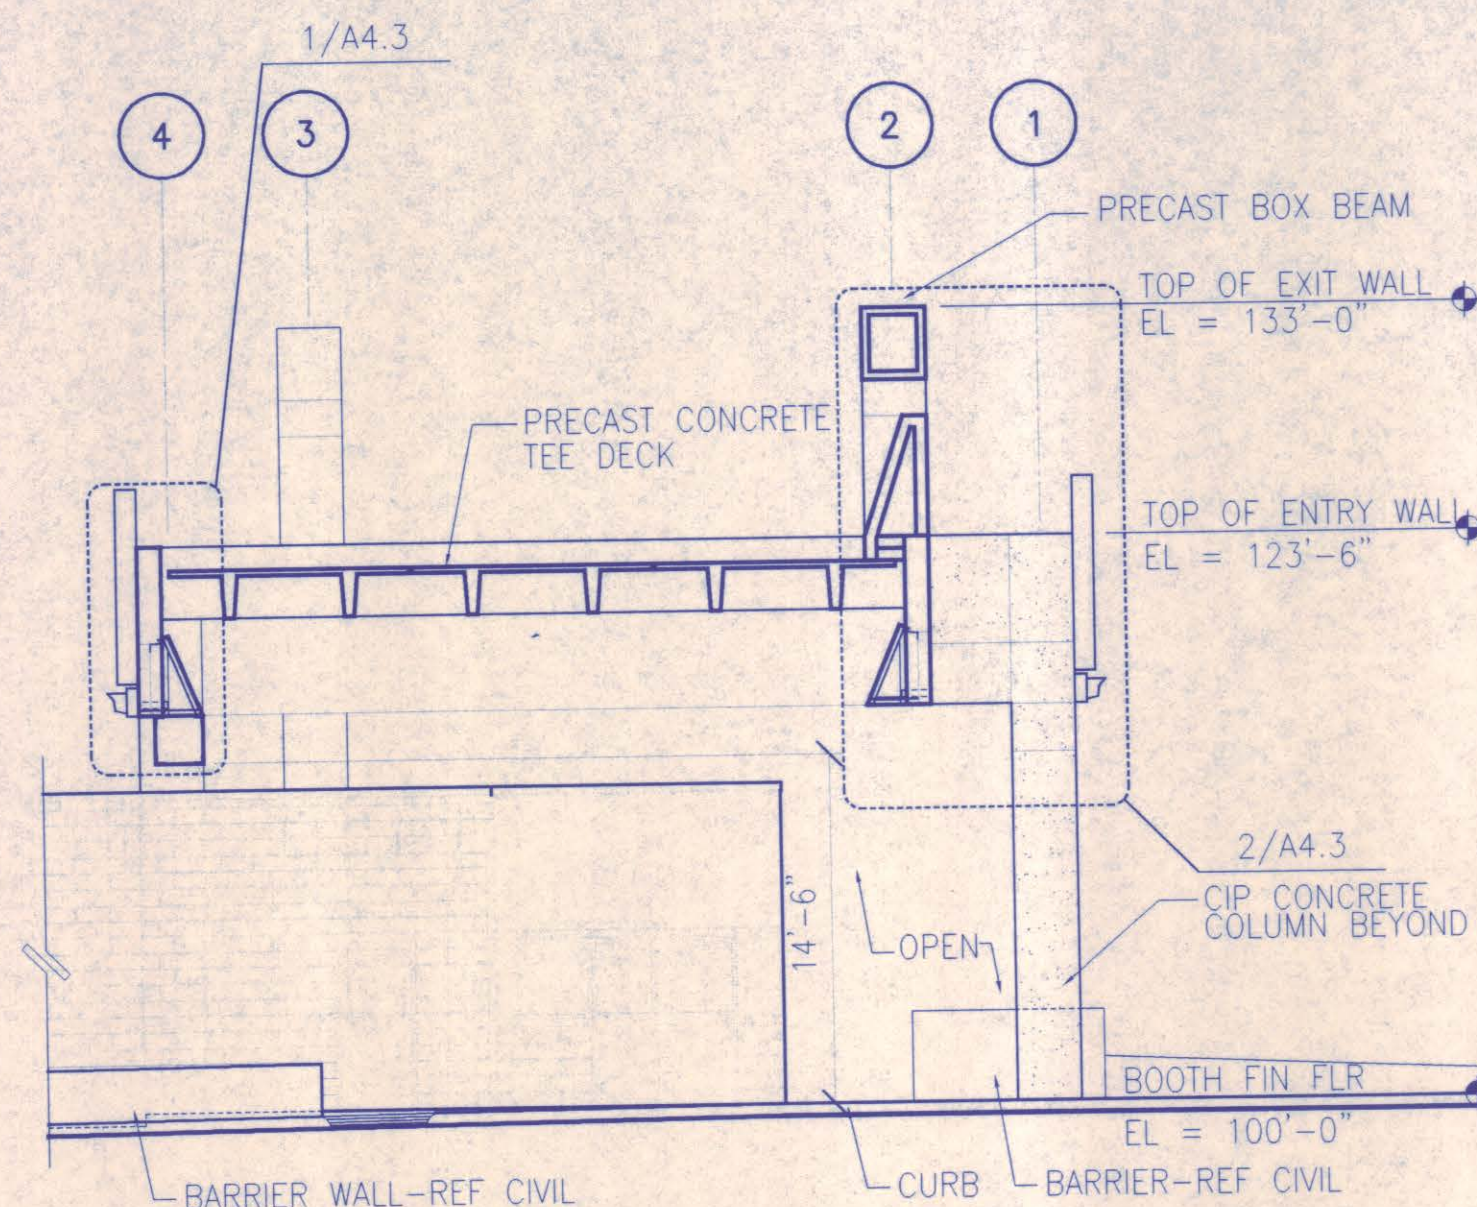


2 CANOPY SECTION
1/8"=1'-0"

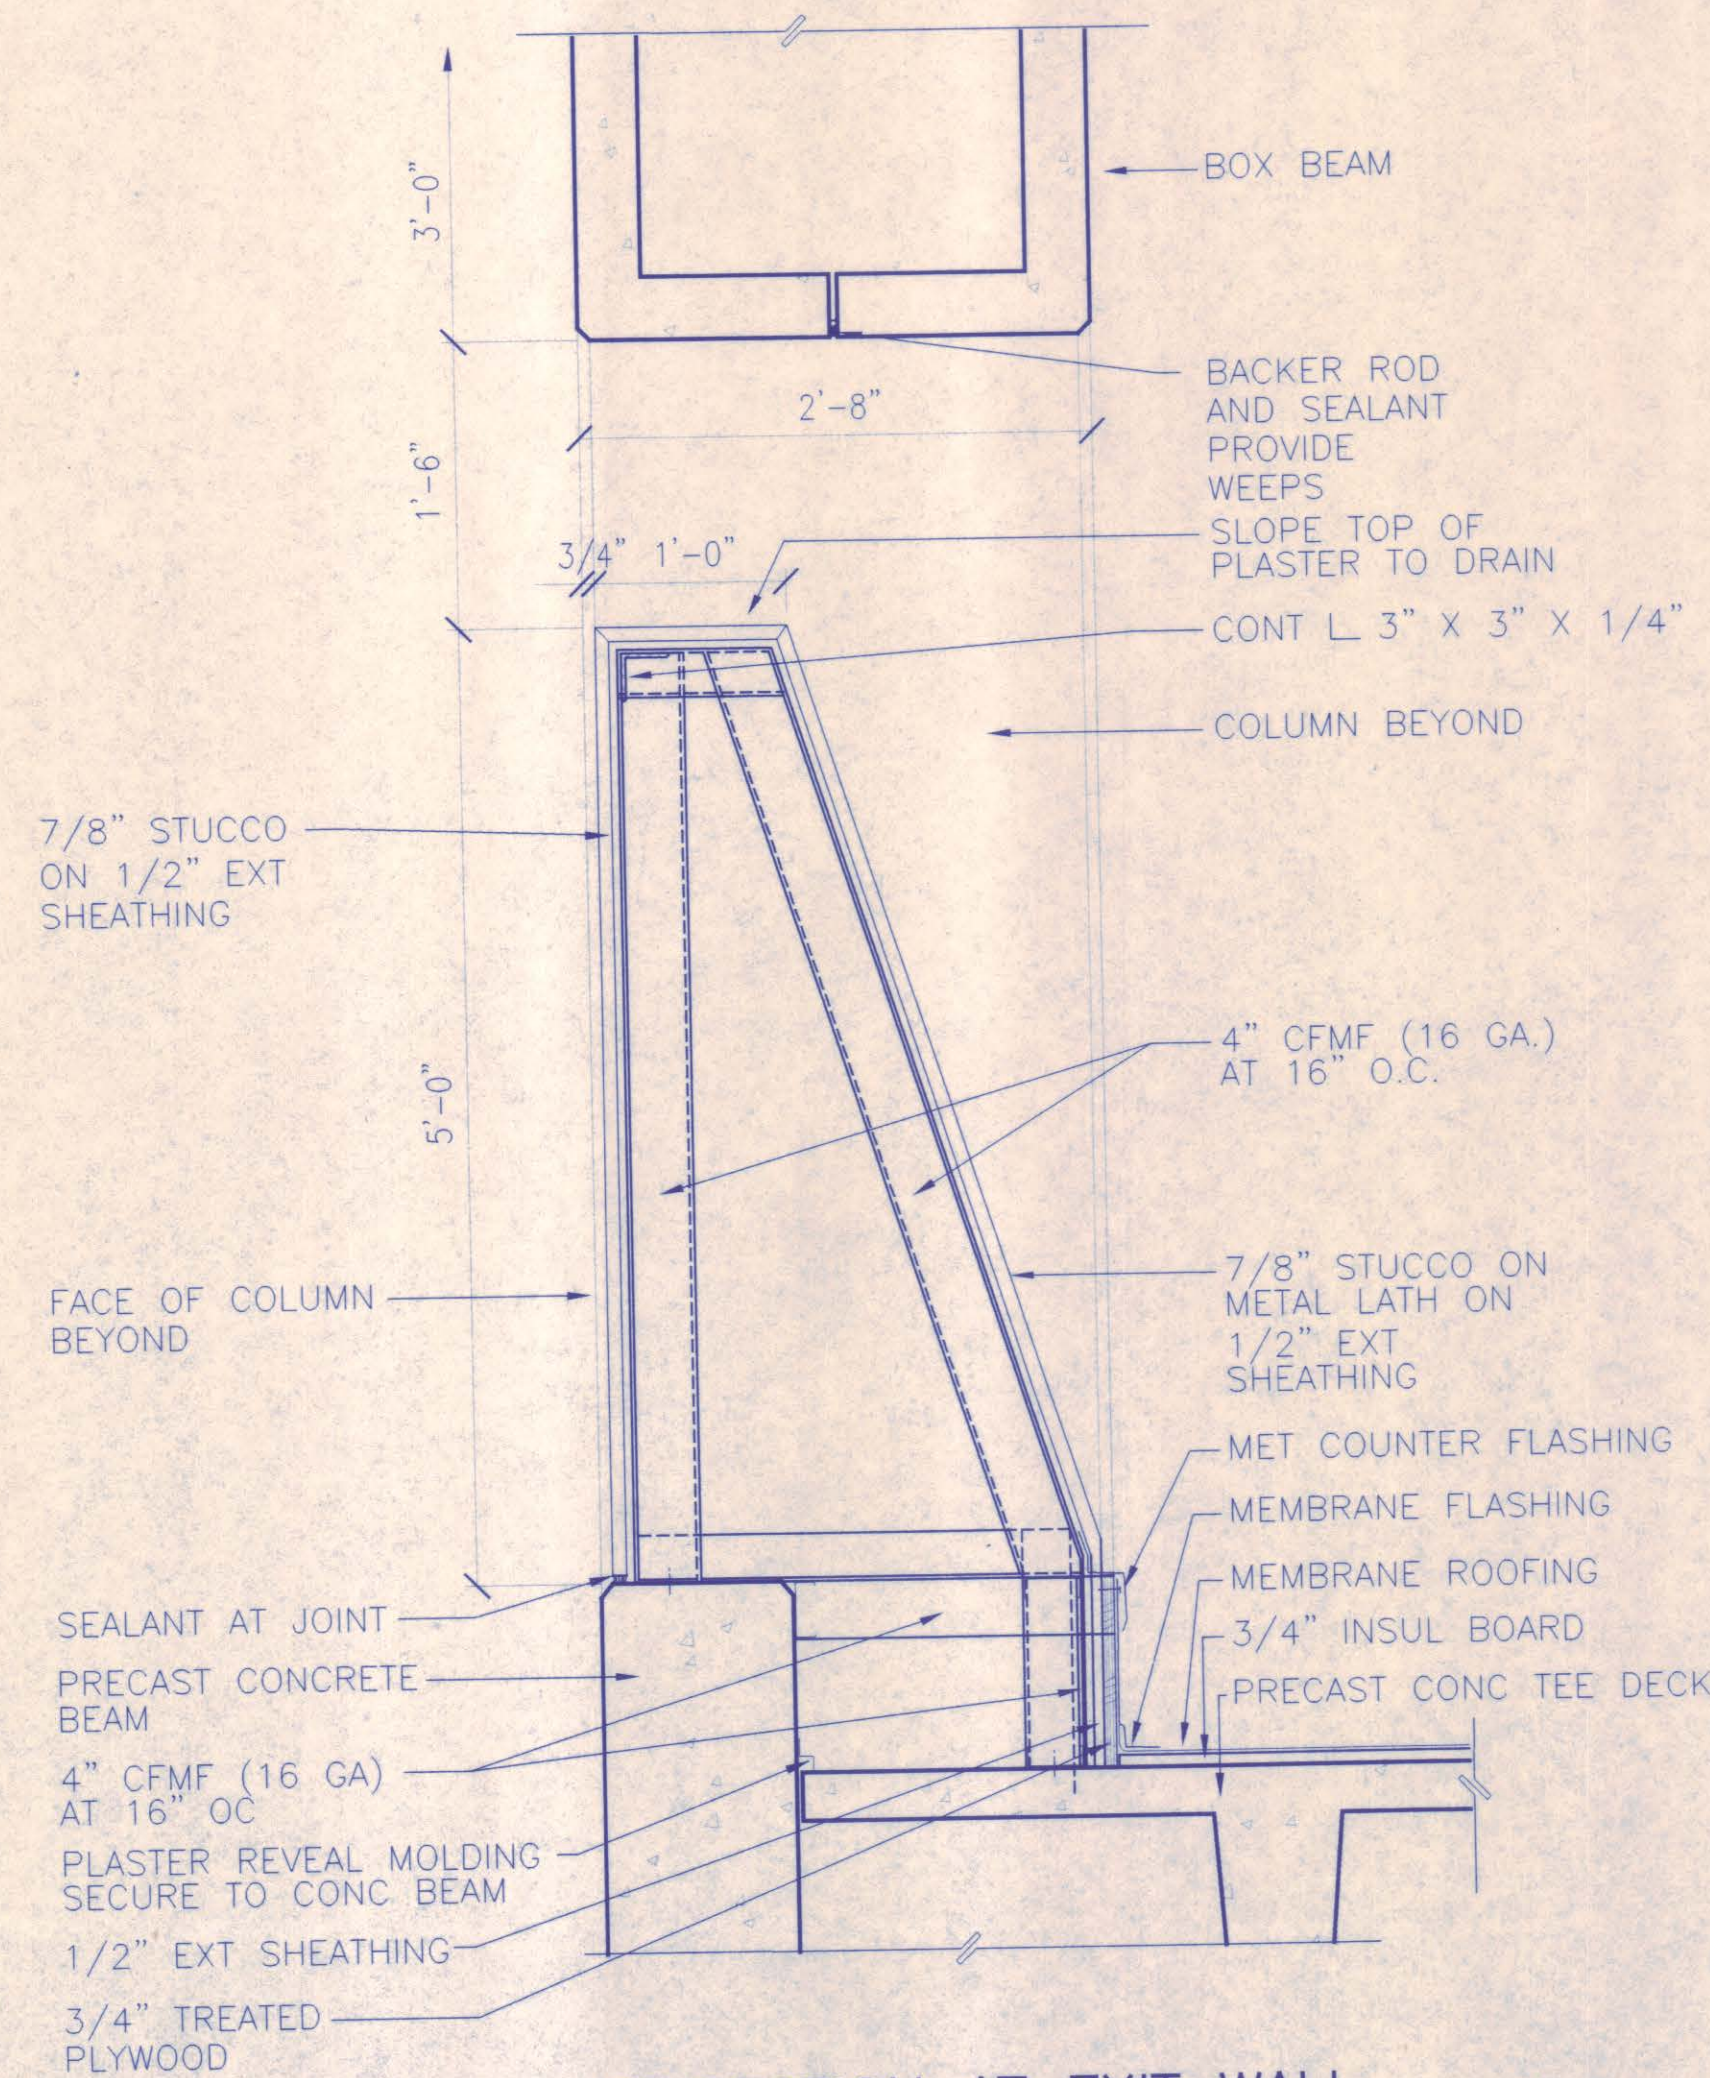


4 SECTION AT EXIT WALL
1"=1'-0"

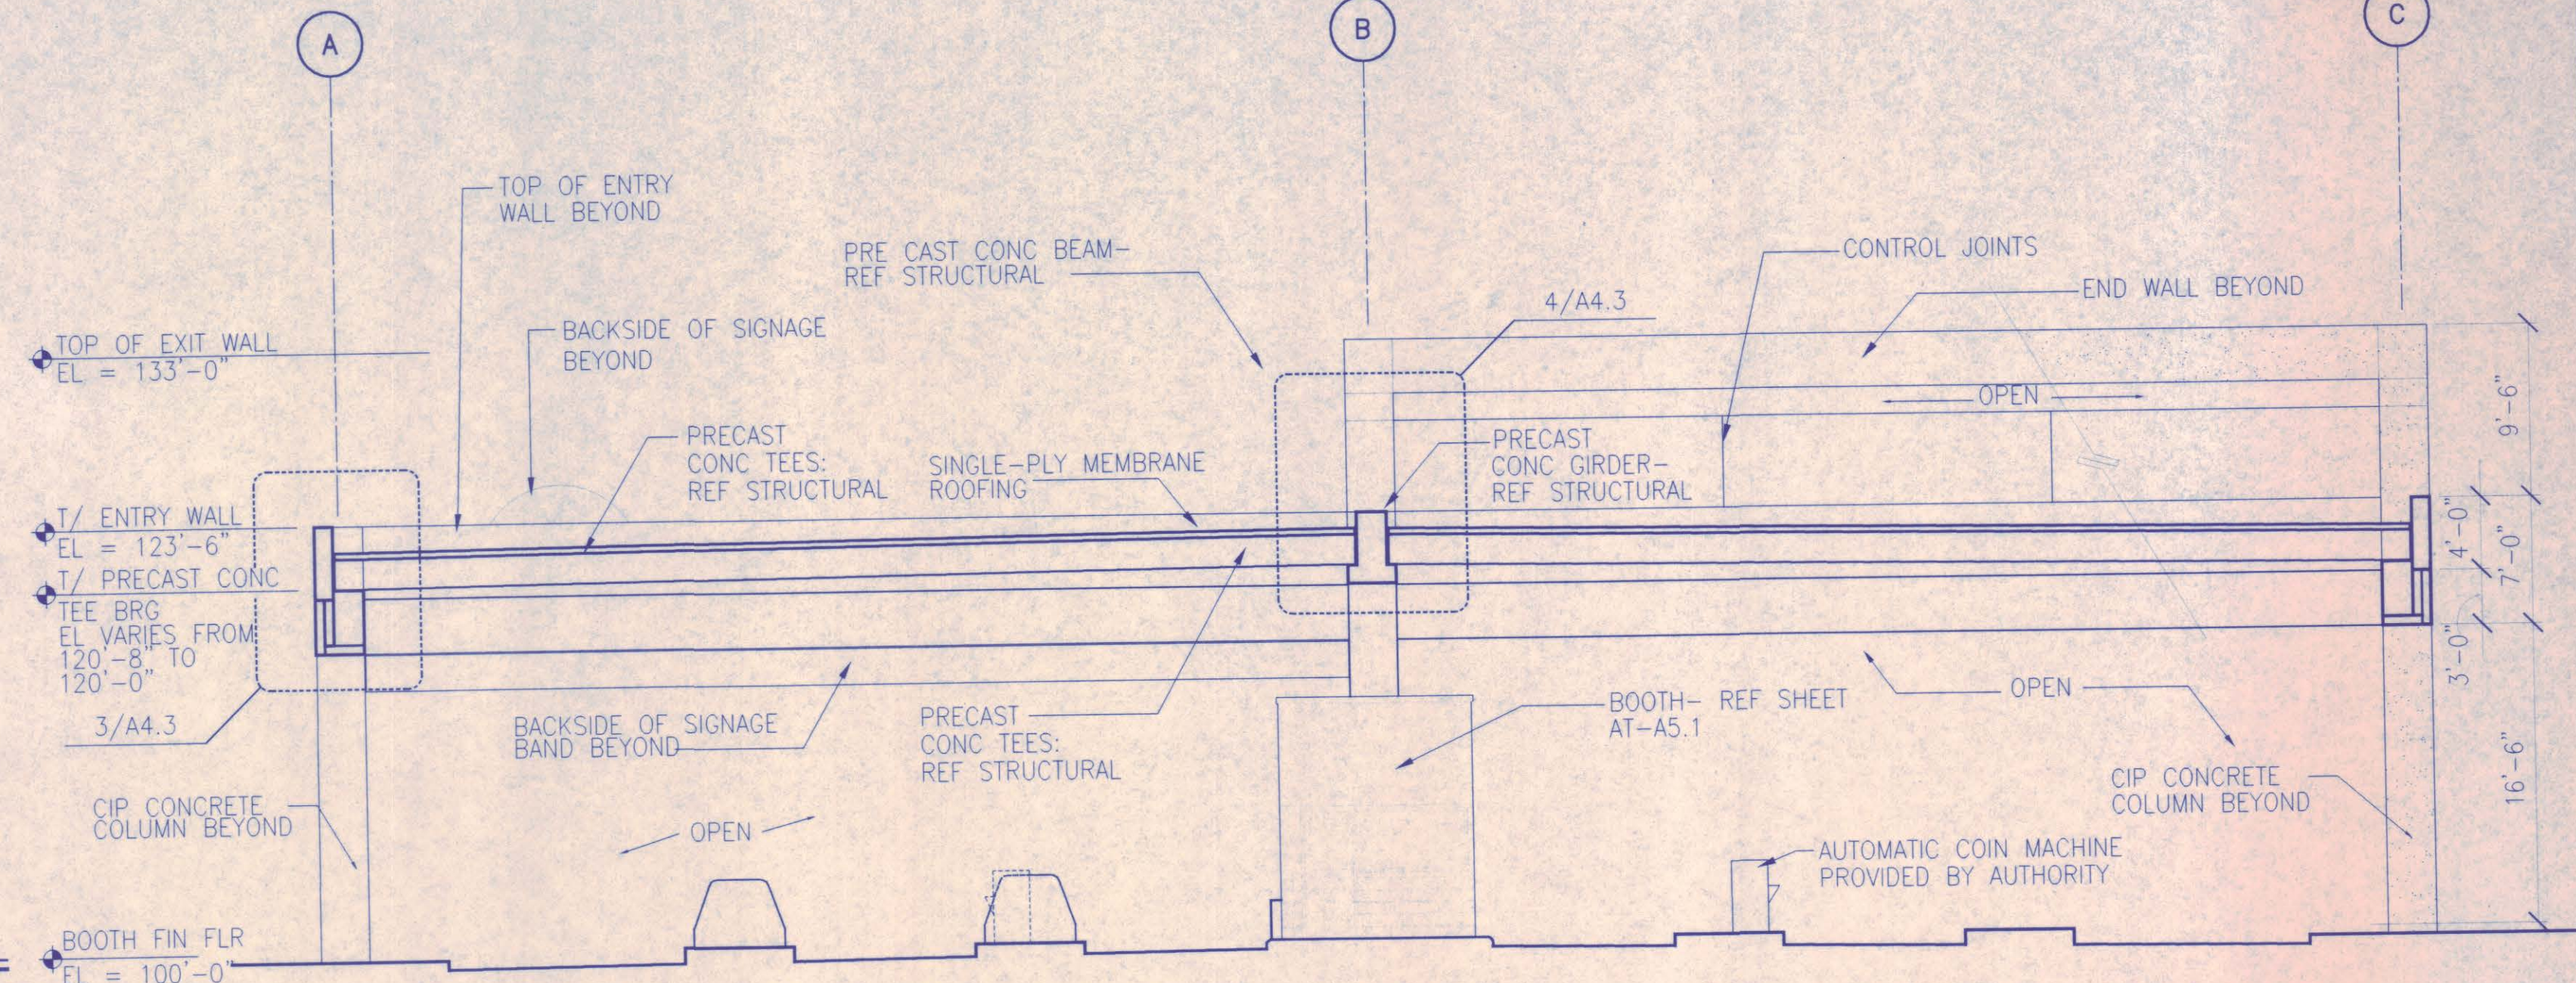

1 CANOPY SECTION
1/8"=1'-0"

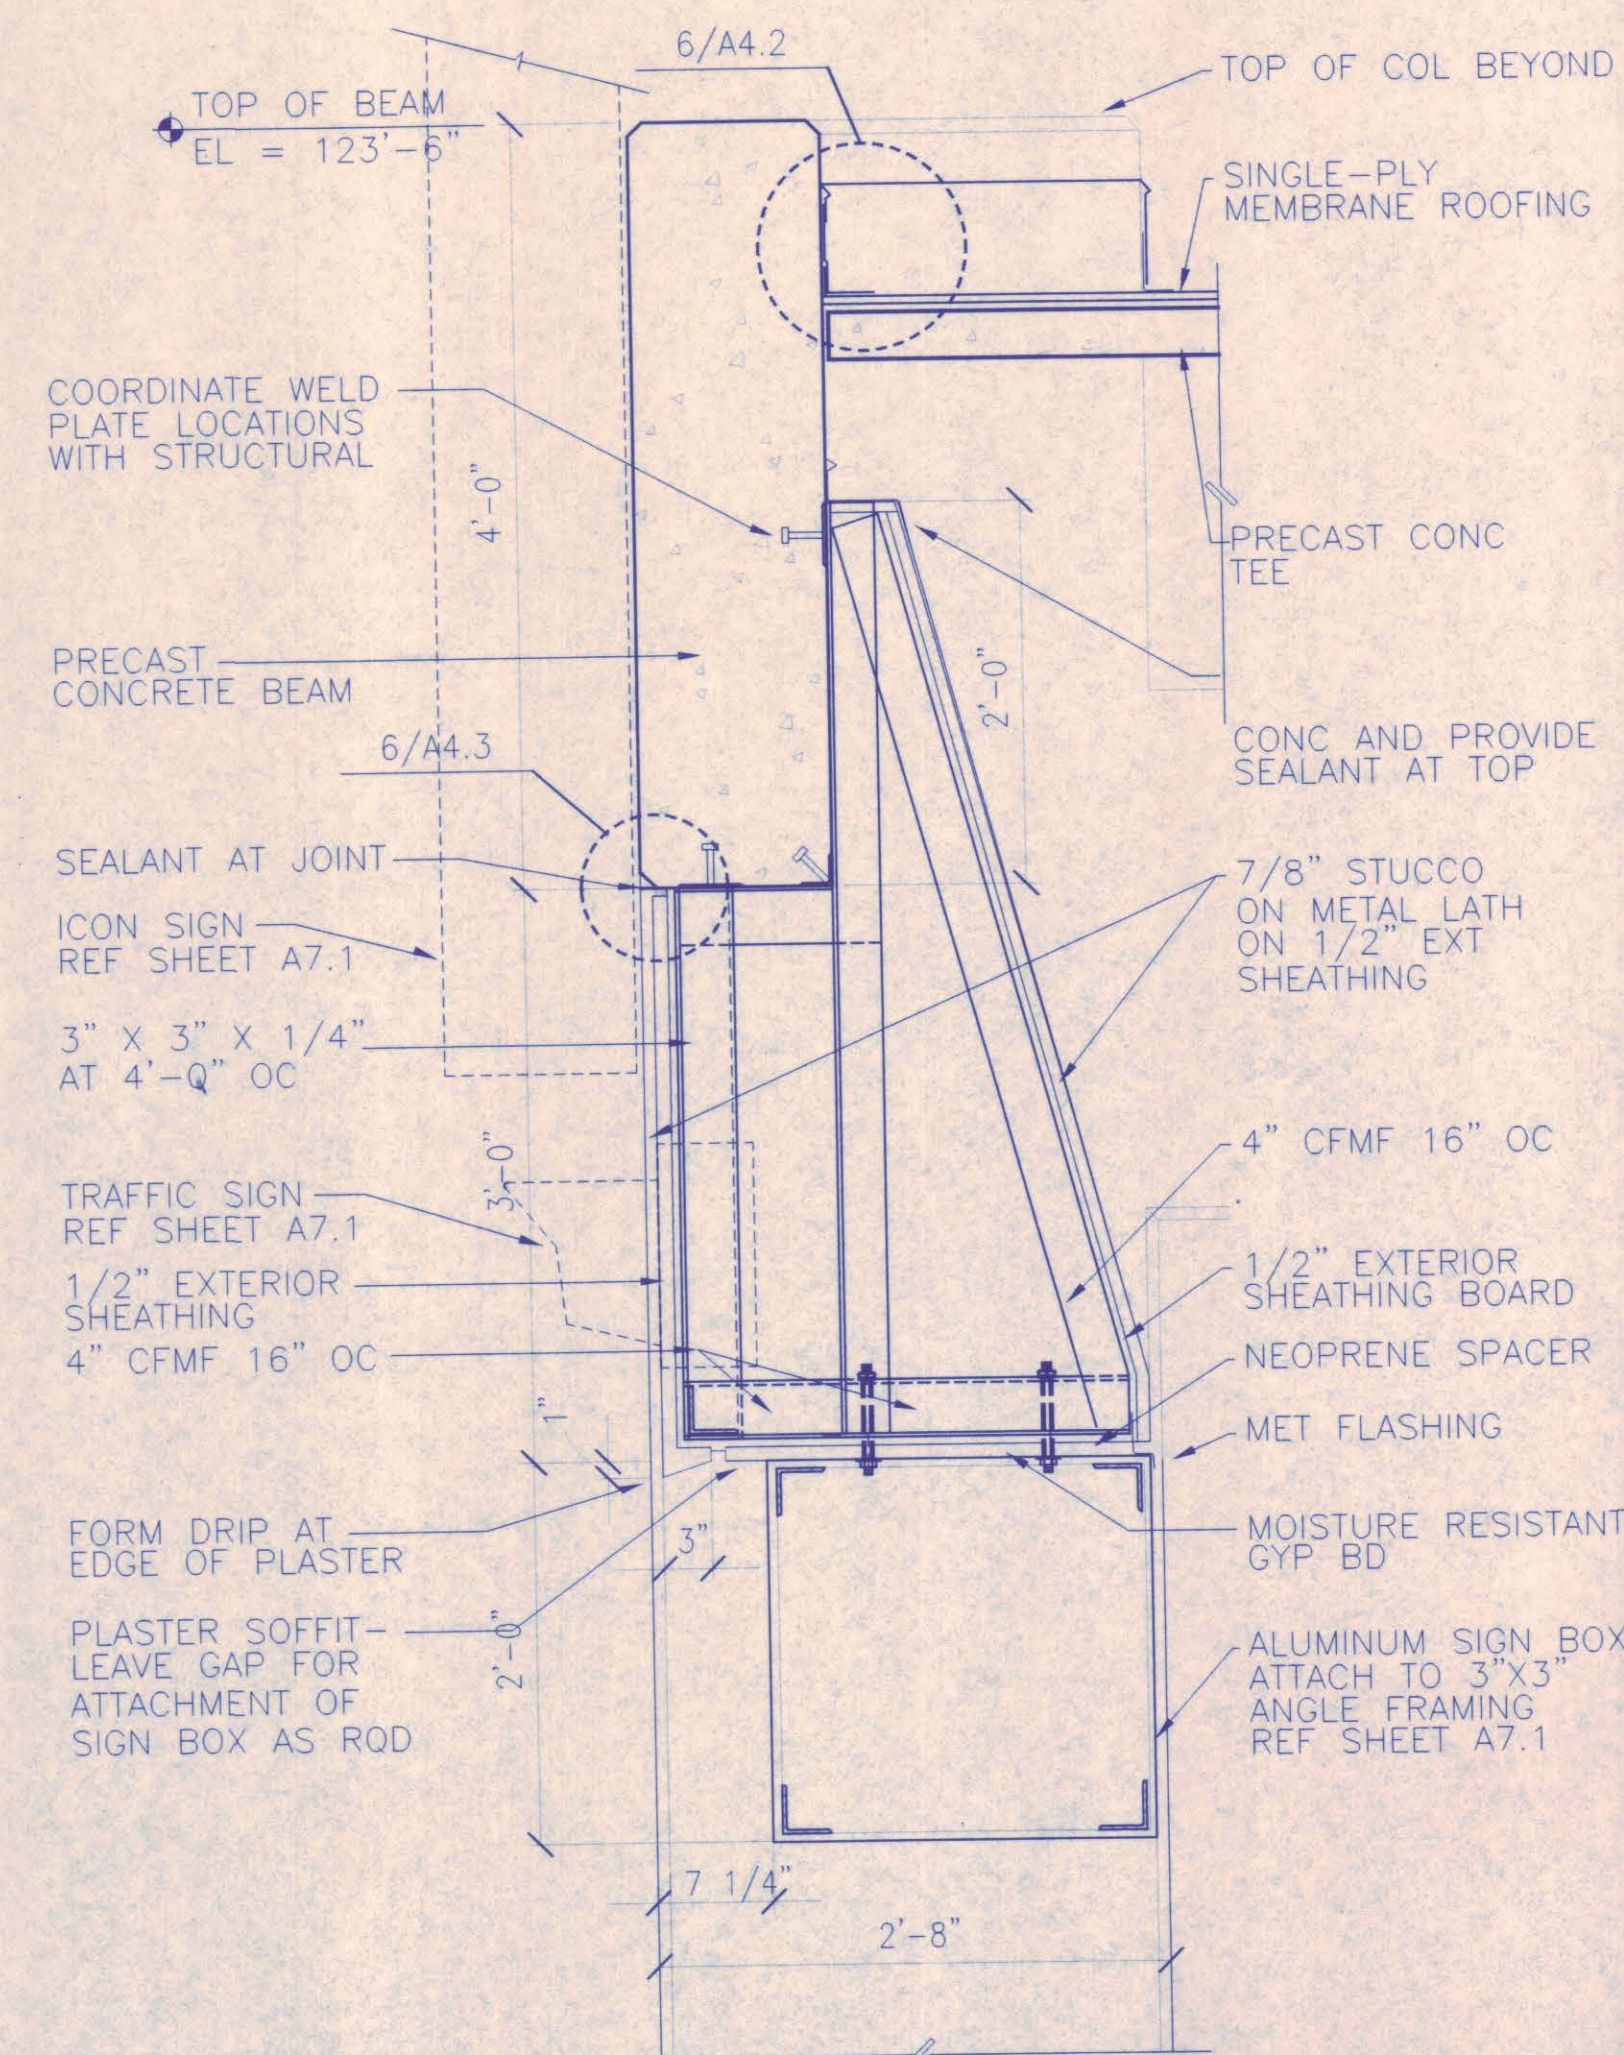

3 SECTION AT ENTRY WALL
1"=1'-0"

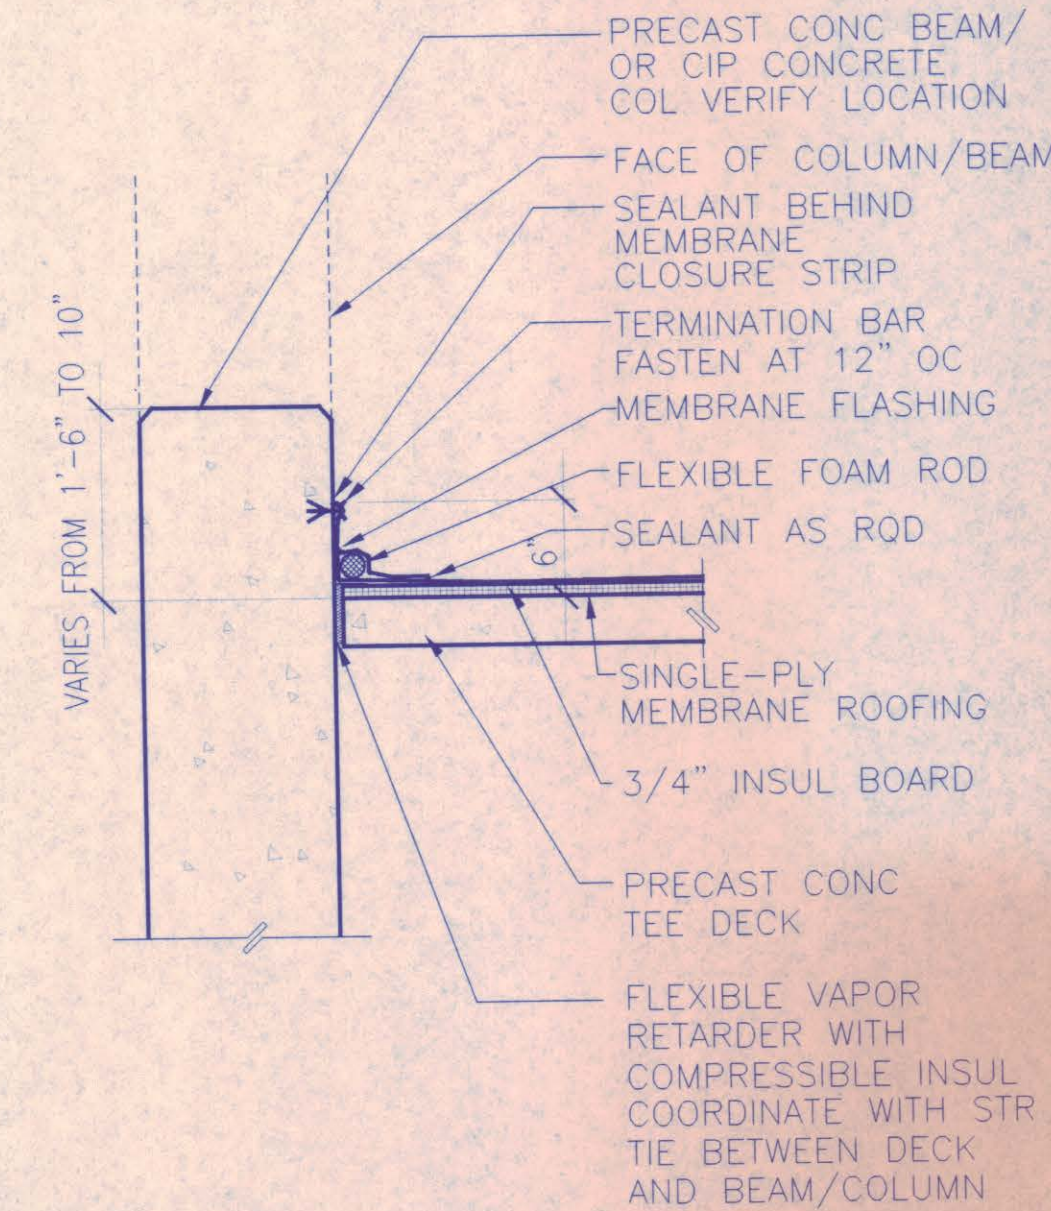


6 ROOF FLASHING DETAIL
1"=1'-0"


NO.	REVISION	BY	DATE
NORTH TEXAS TOLLWAY AUTHORITY			
ADDISON AIRPORT TUNNEL			
BARRIER TOLL PLAZA			
TUNNEL PLAZA			
CANOPY SECTIONS			
AGUIRRE Corporation 2700 PARK CENTRAL DRIVE 40 TH FLOOR DALLAS TEXAS 75201 TEL 972 788-1008			SECTION XIII
CHECKED <i>MM</i>	DATE 12/18/97	DESIGNED <i>MM</i>	DATE 8/15/96
CHECKED <i>MM</i>	DATE 12/18/97	SCALE AS SHOWN	
CONTRACT NO. DNT-290	SHEET 24	OF 53	

GENERAL NOTES


1. ALL EXPOSED CAST IN PLACE CONCRETE COLUMNS TO RECEIVE SANDBLAST FINISH AND SEALER.
2. ALL EXPOSED PRECAST SPANDREL AND BOX BEAMS TO RECEIVE SANDBLAST FINISH AND SEALER.

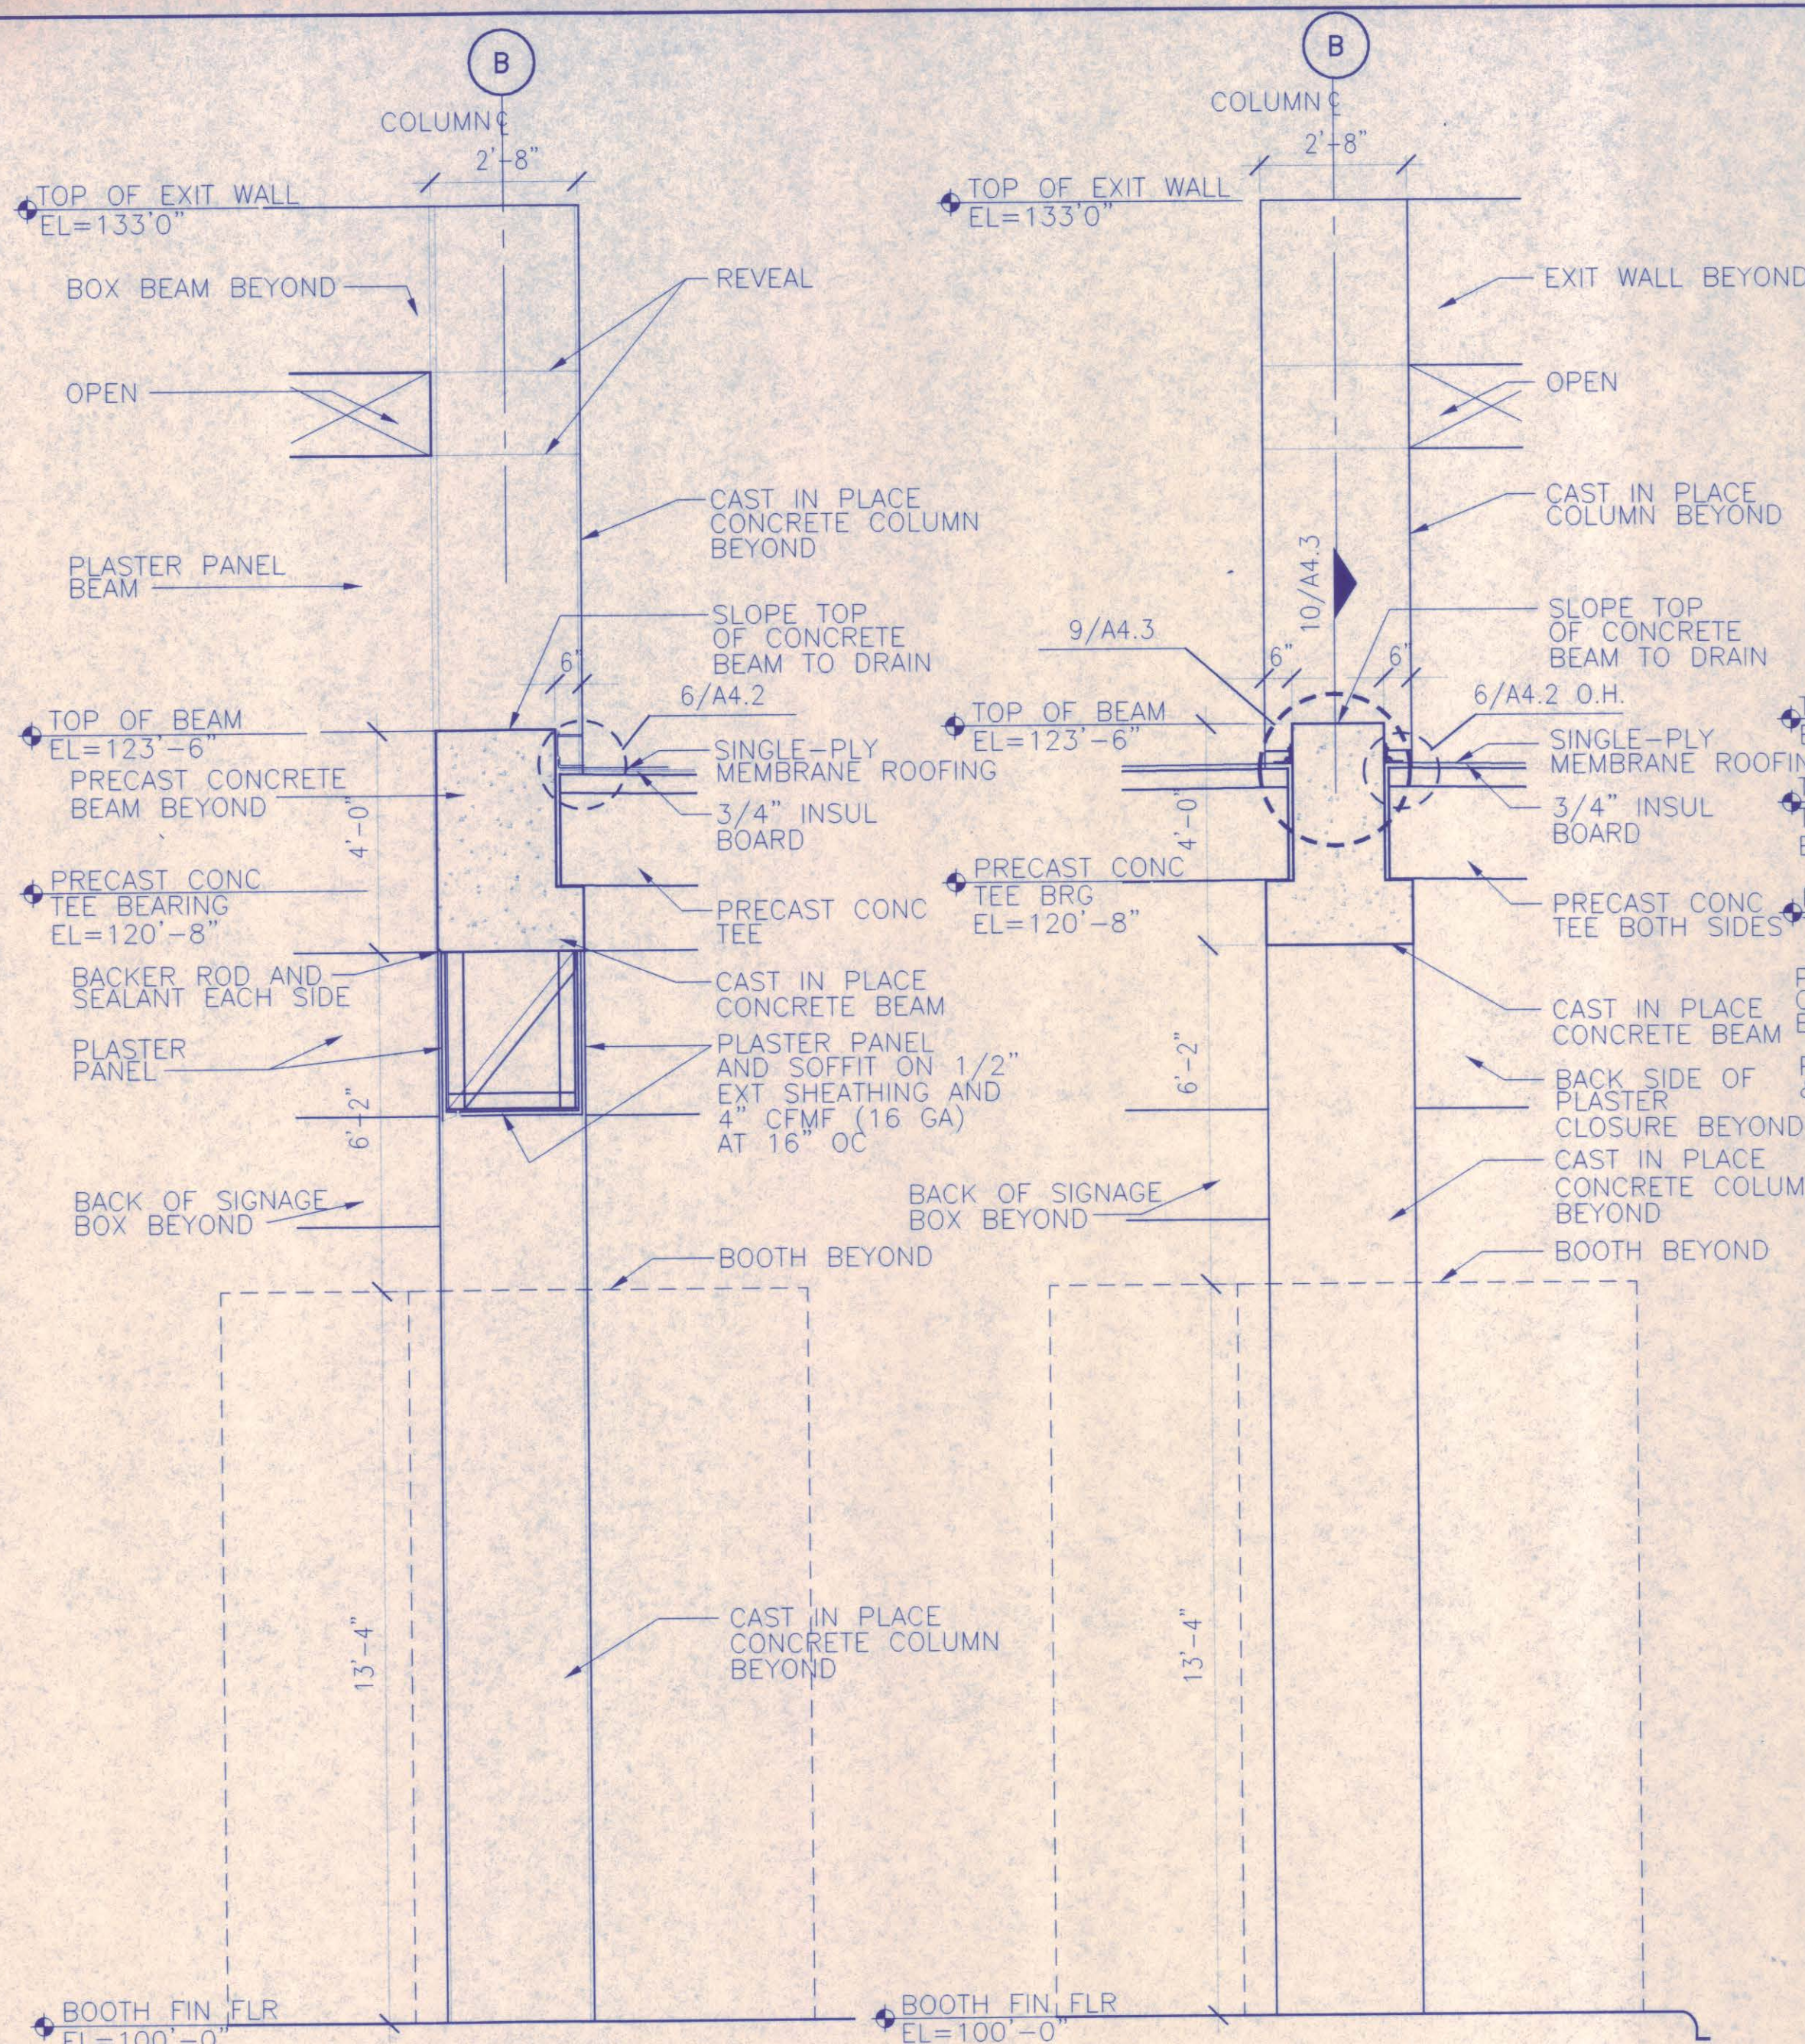


5 CANOPY SECTION-TRANSITION WALL
3/8"=1'-0"

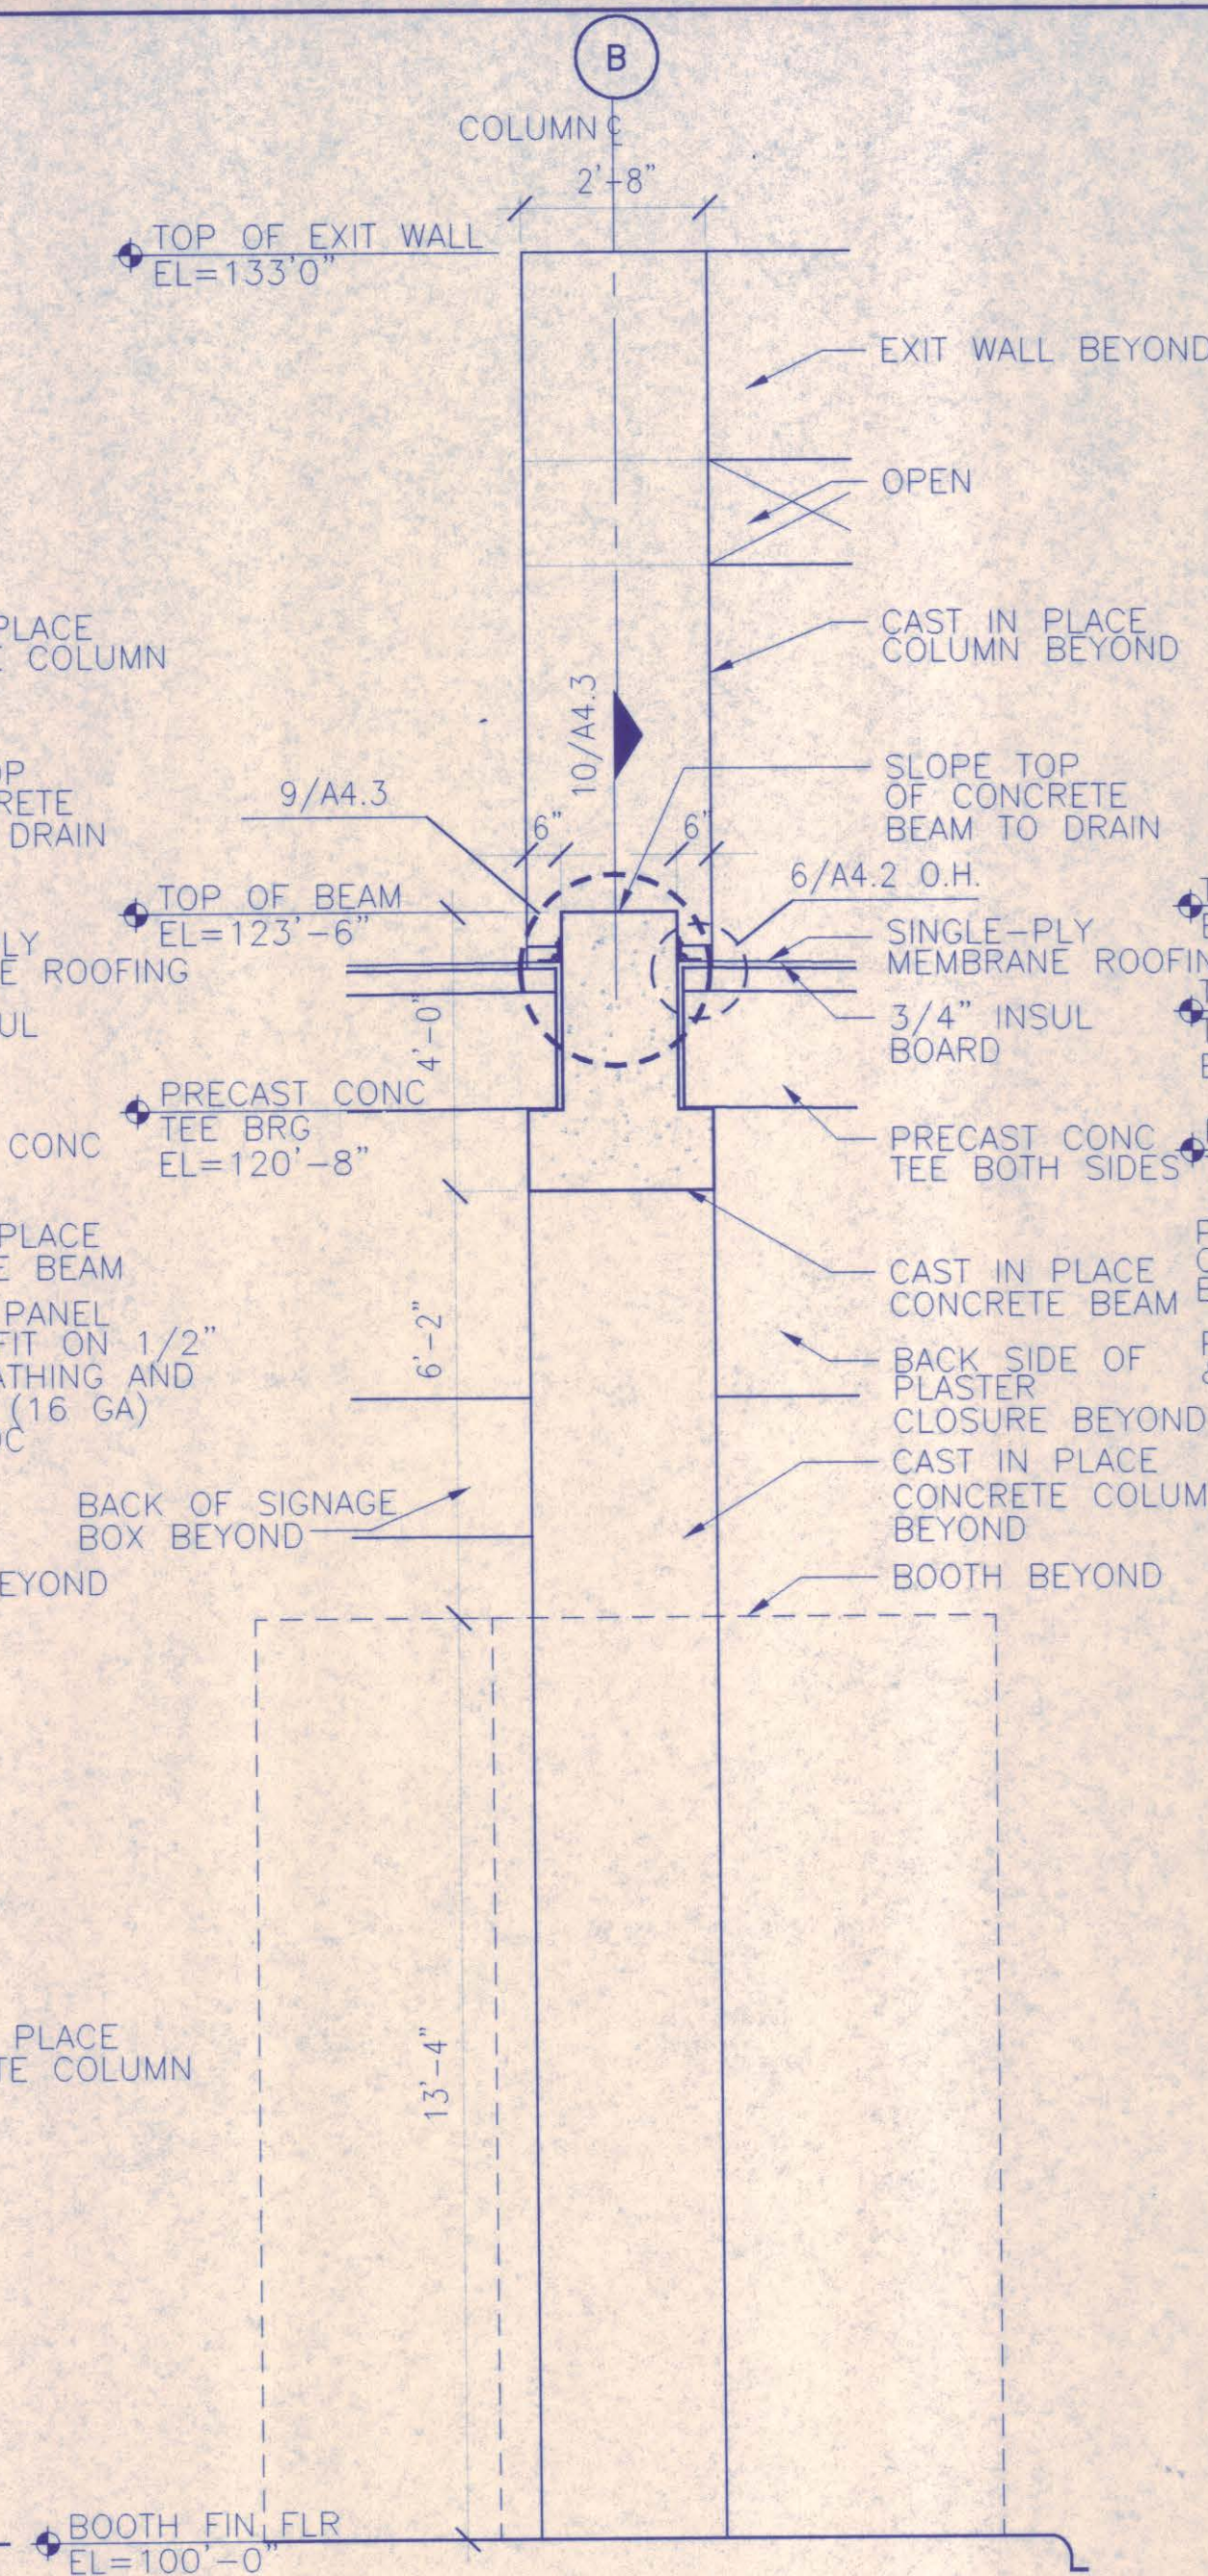


4 CANOPY SECTION-MID BEAM
3/8"=1'-0"

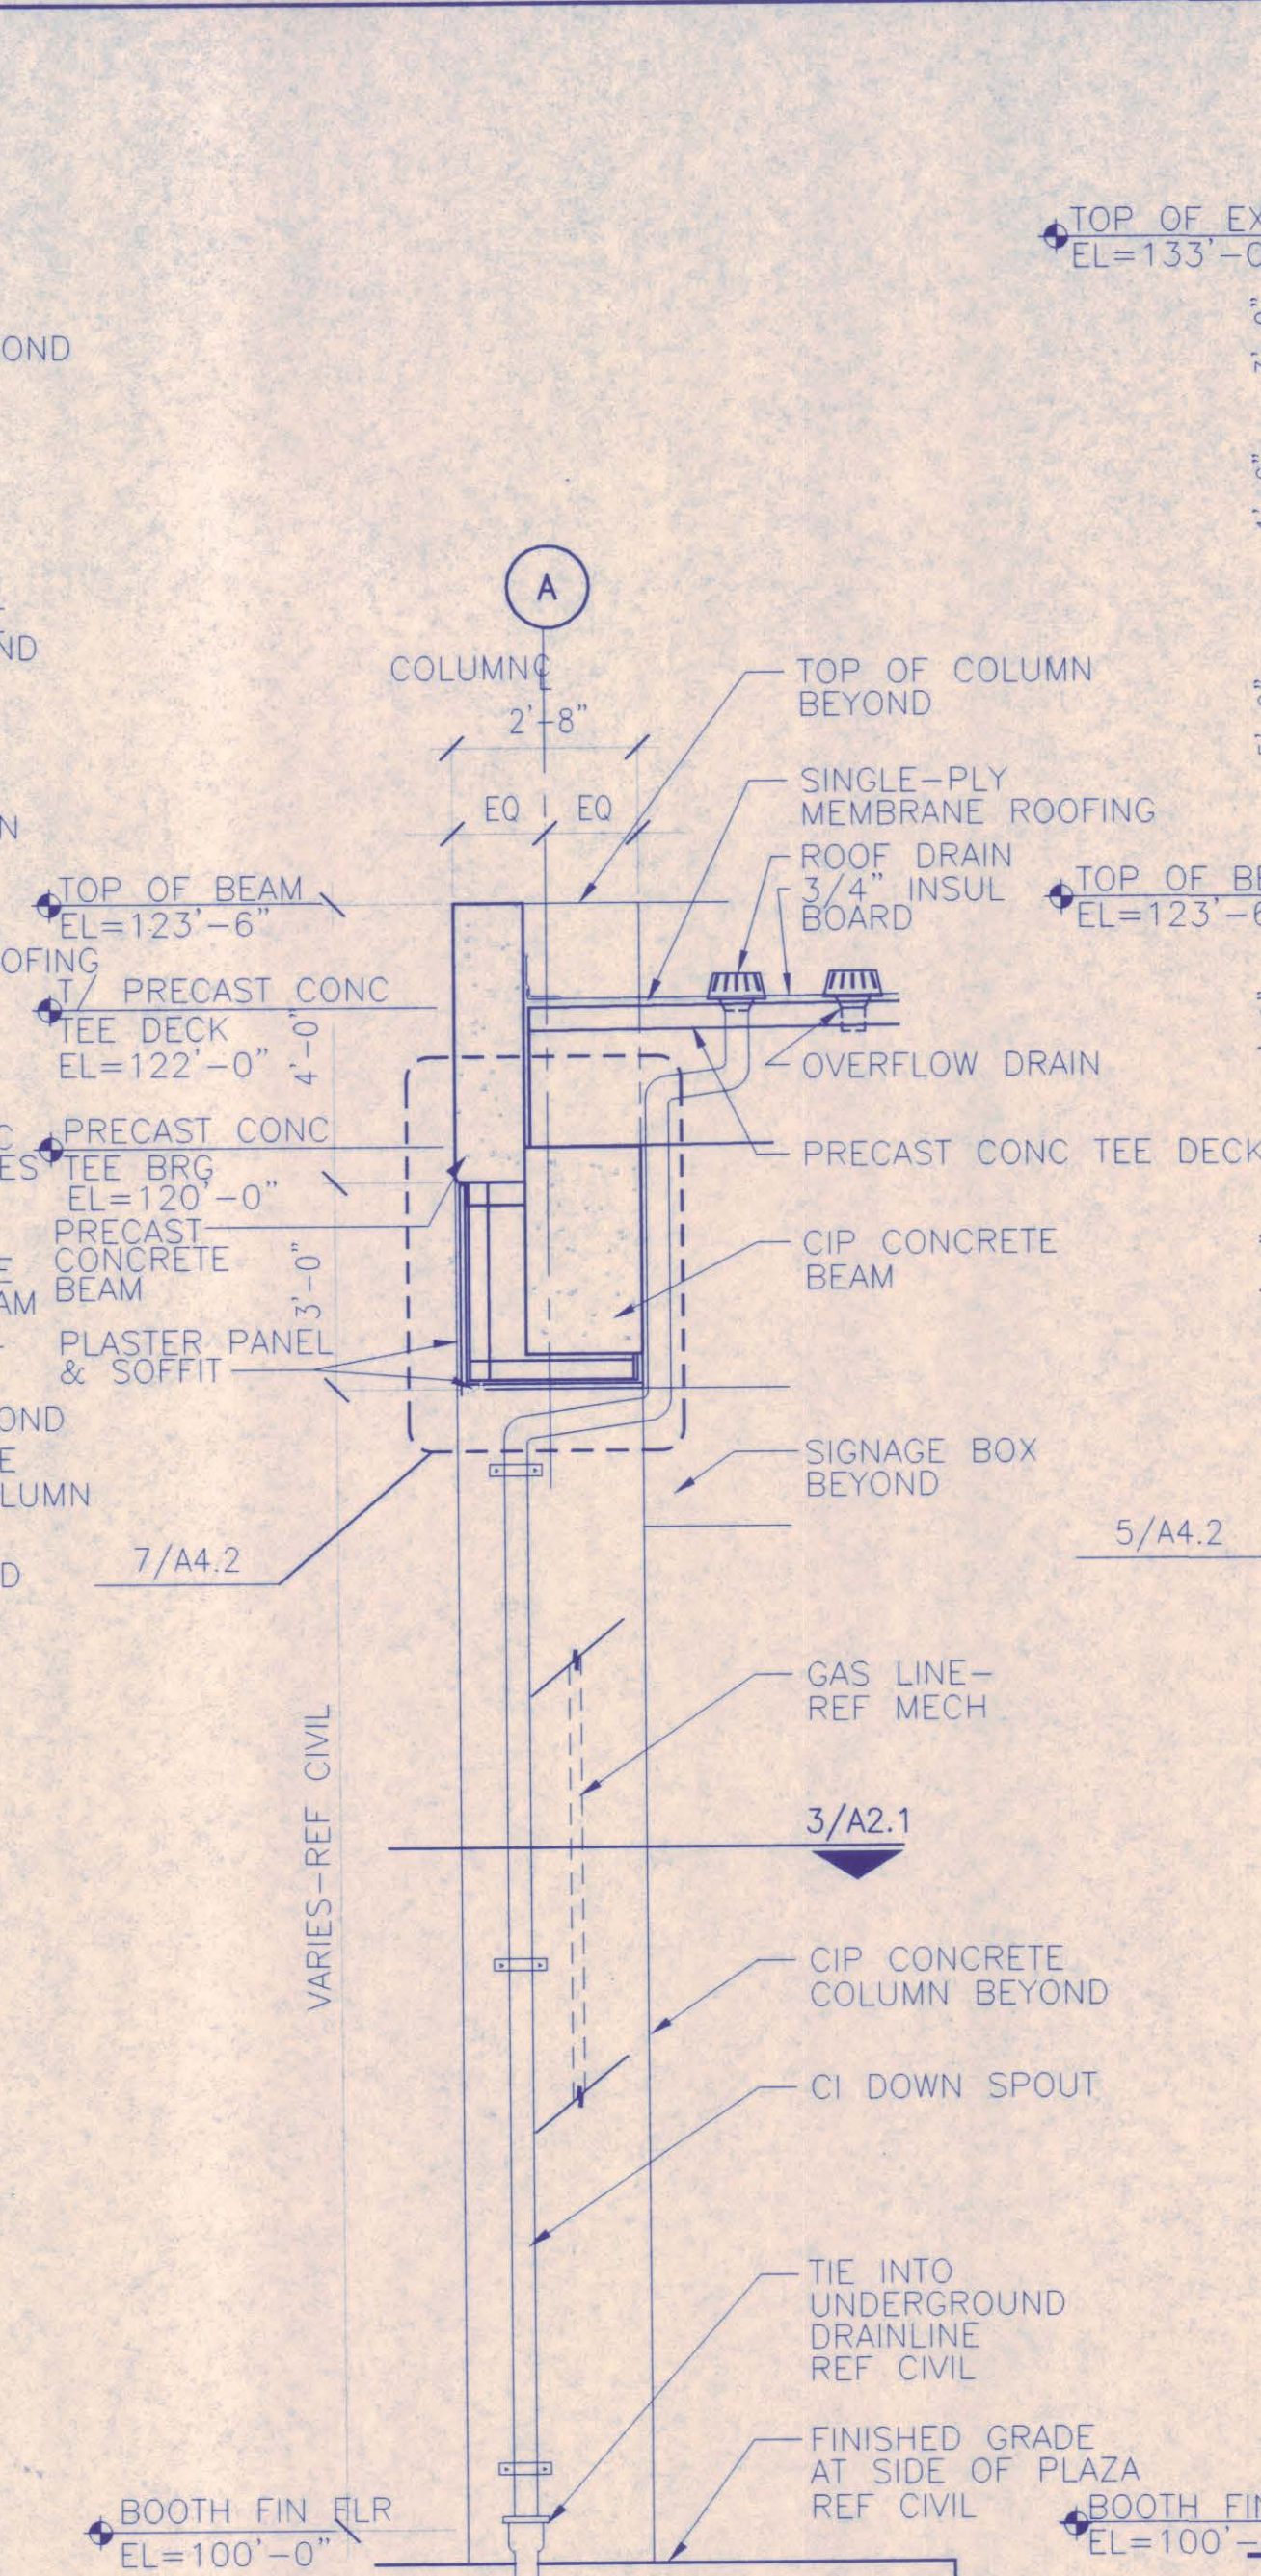


3 CANOPY SECTION-SIDE WALL
3/8"=1'-0"

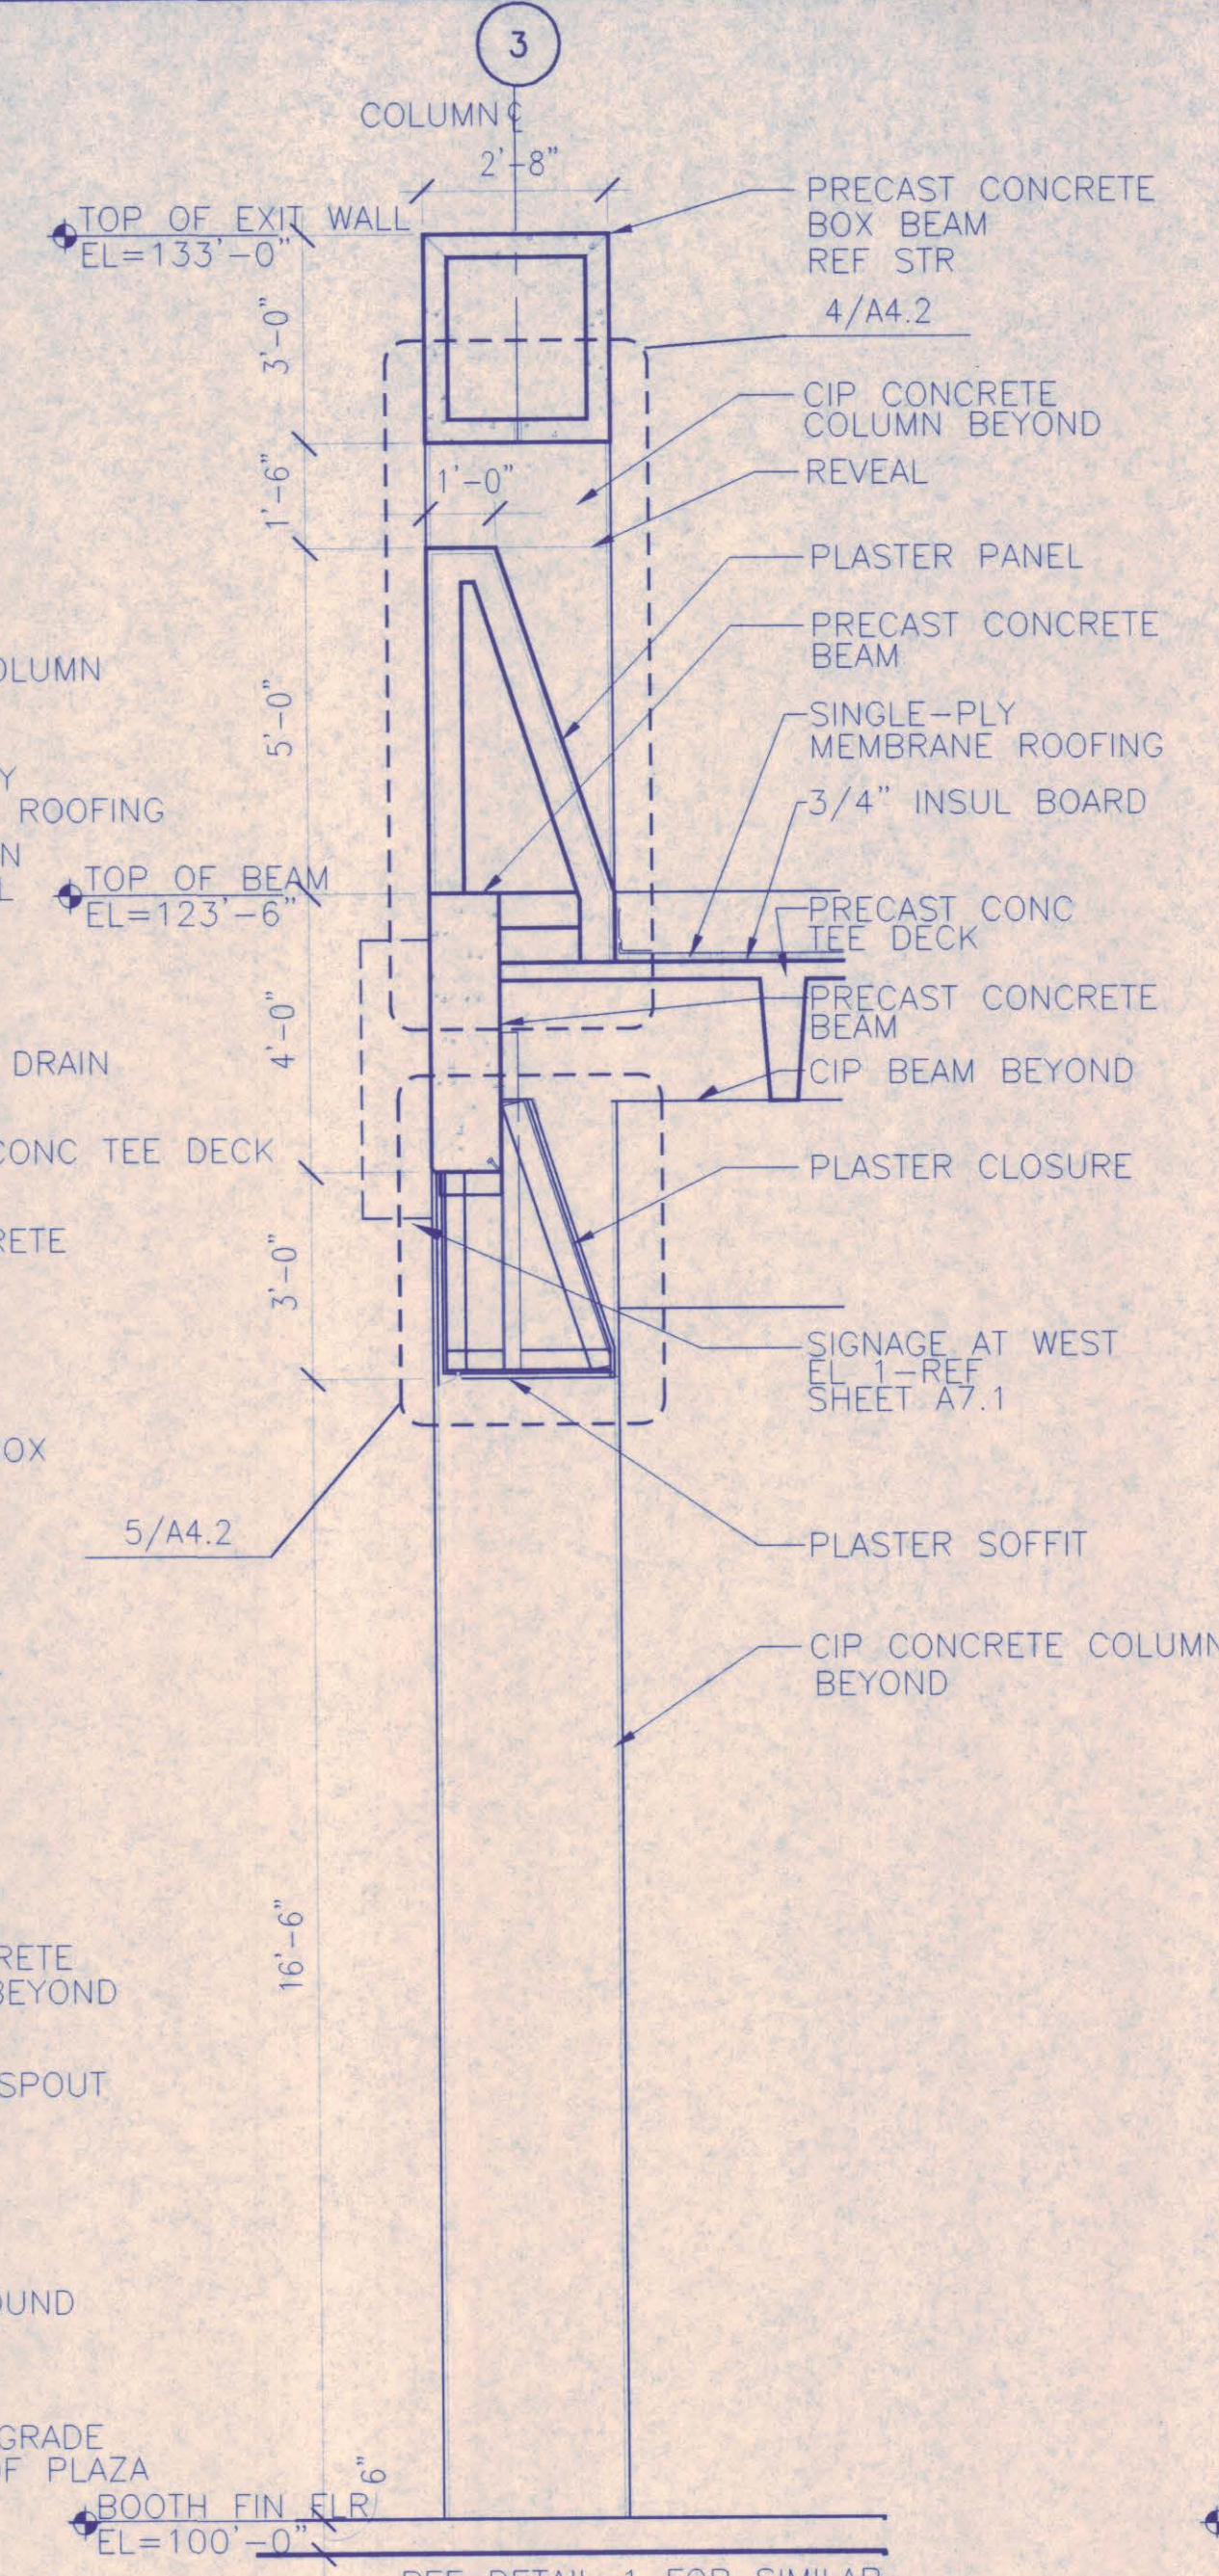


2 CANOPY SECTION-EXIT WALL
3/8"=1'-0"

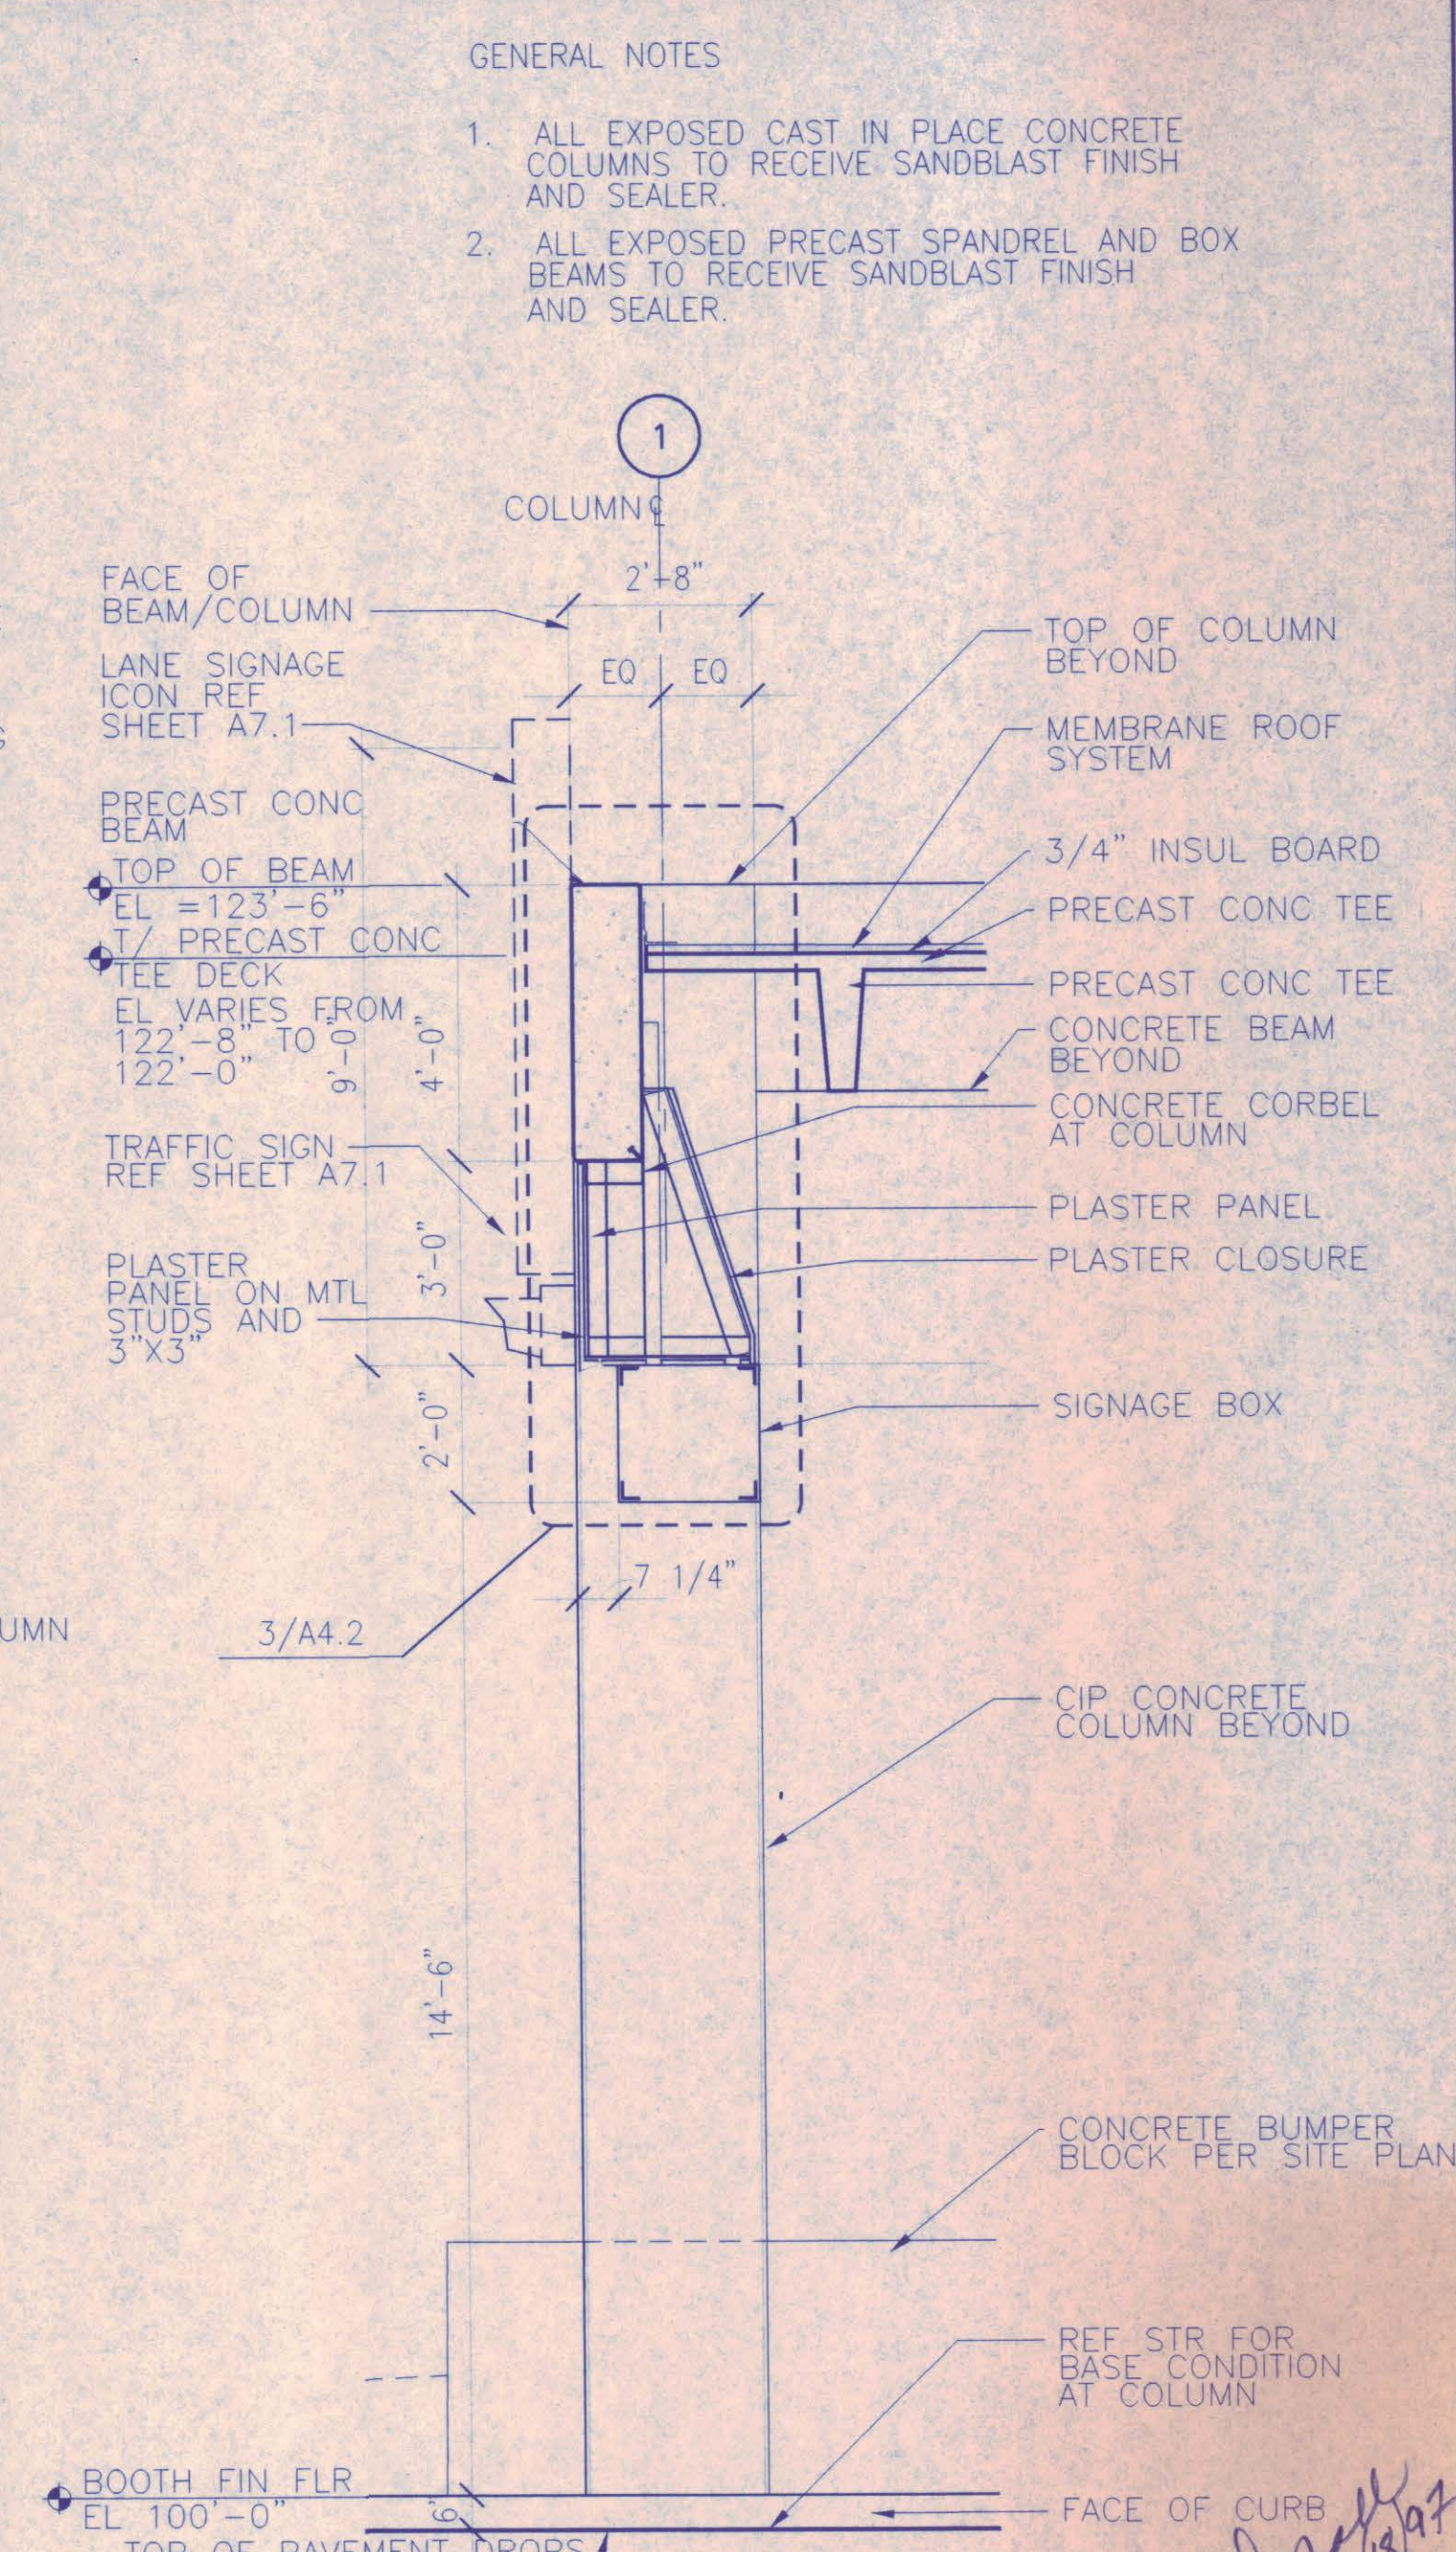


1 CANOPY SECTION-ENTRY WALL
3/8"=1'-0"

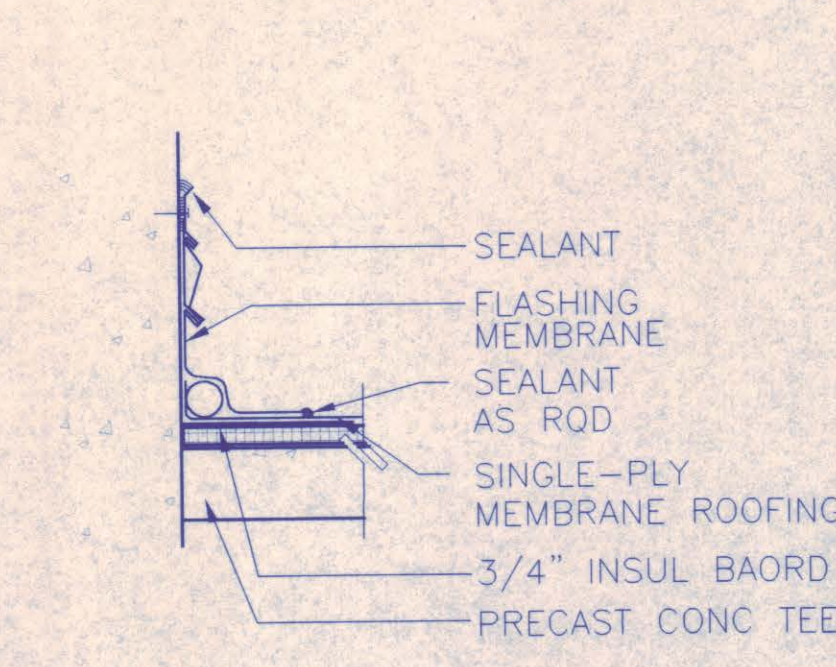


10 FLASHING @ COLUMN
1 1/2"=1'-0"

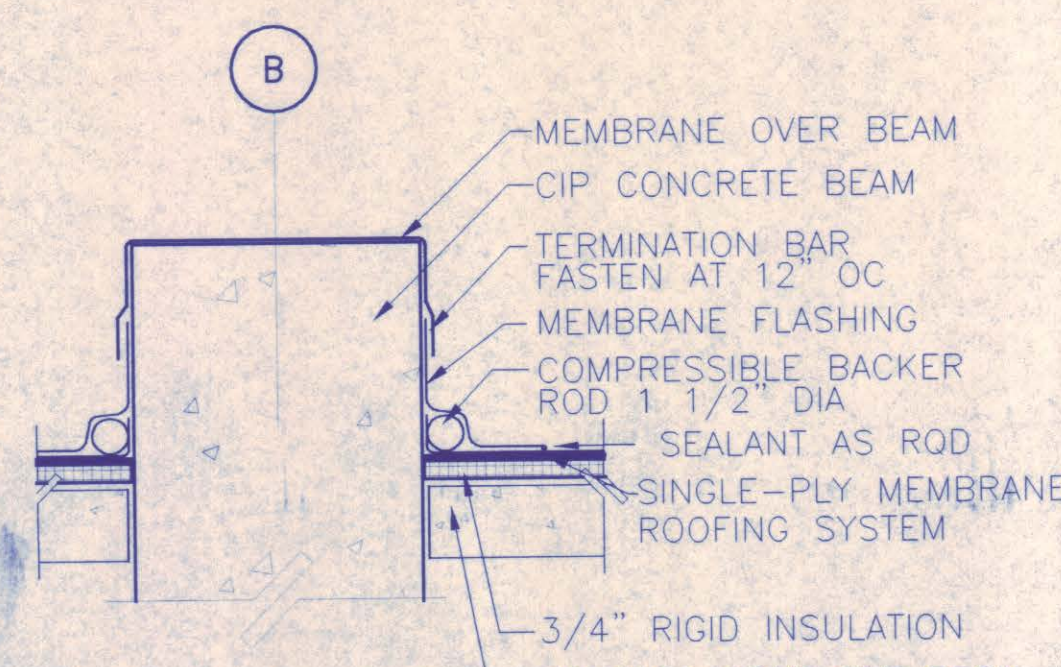


9 MEMBRANE @ BEAM
1 1/2"=1'-0"

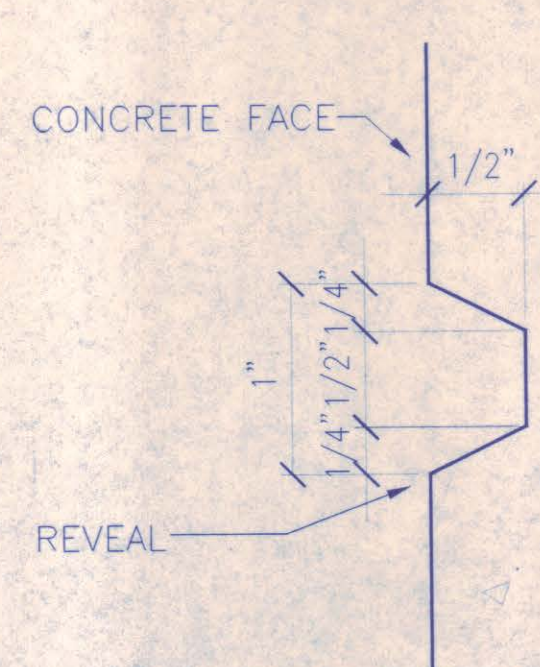

8 REVEAL AT CONCRETE
FULLSIZE

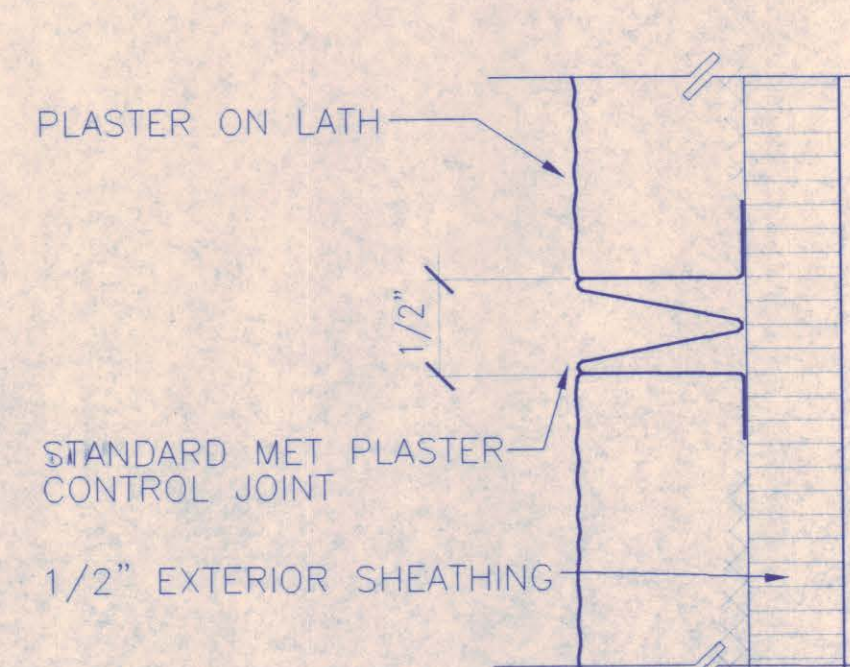



7 CONTROL JT AT PLASTER
FULLSIZE

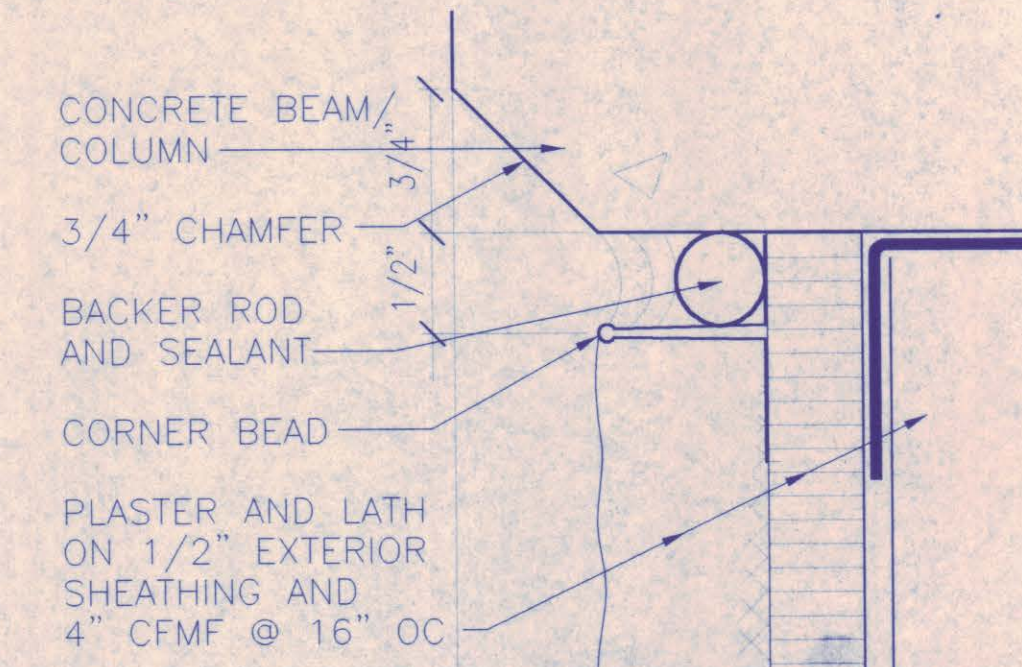


6 DETAIL AT JOINT
FULLSIZE

AT-A4.3


NO.	REVISION	BY	DATE
NORTH TEXAS TOLLWAY AUTHORITY			
ADDISON AIRPORT TUNNEL			
BARRIER TOLL PLAZA			
TUNNEL PLAZA CANOPY			
WALL SECTIONS			
SECTION XIII			
AGUIRRE Corporation 5700 PARK CENTRAL DRIVE 15 TH FLOOR DALLAS TEXAS 75201 TEL. 972.755-1505			
CHECKED	DATE 12/18/97	DESIGNED MM	DATE 8/15/96
CHECKED	DATE 12/18/97	SCALE AS SHOWN	
CONTRACT NO. DNT-290		SHEET 25 OF 53	

  


H:\aai-proj\9603-01\dwg\ADDISON\TAAT_A44.dwg
Tue Dec 16 15:24:47 1997

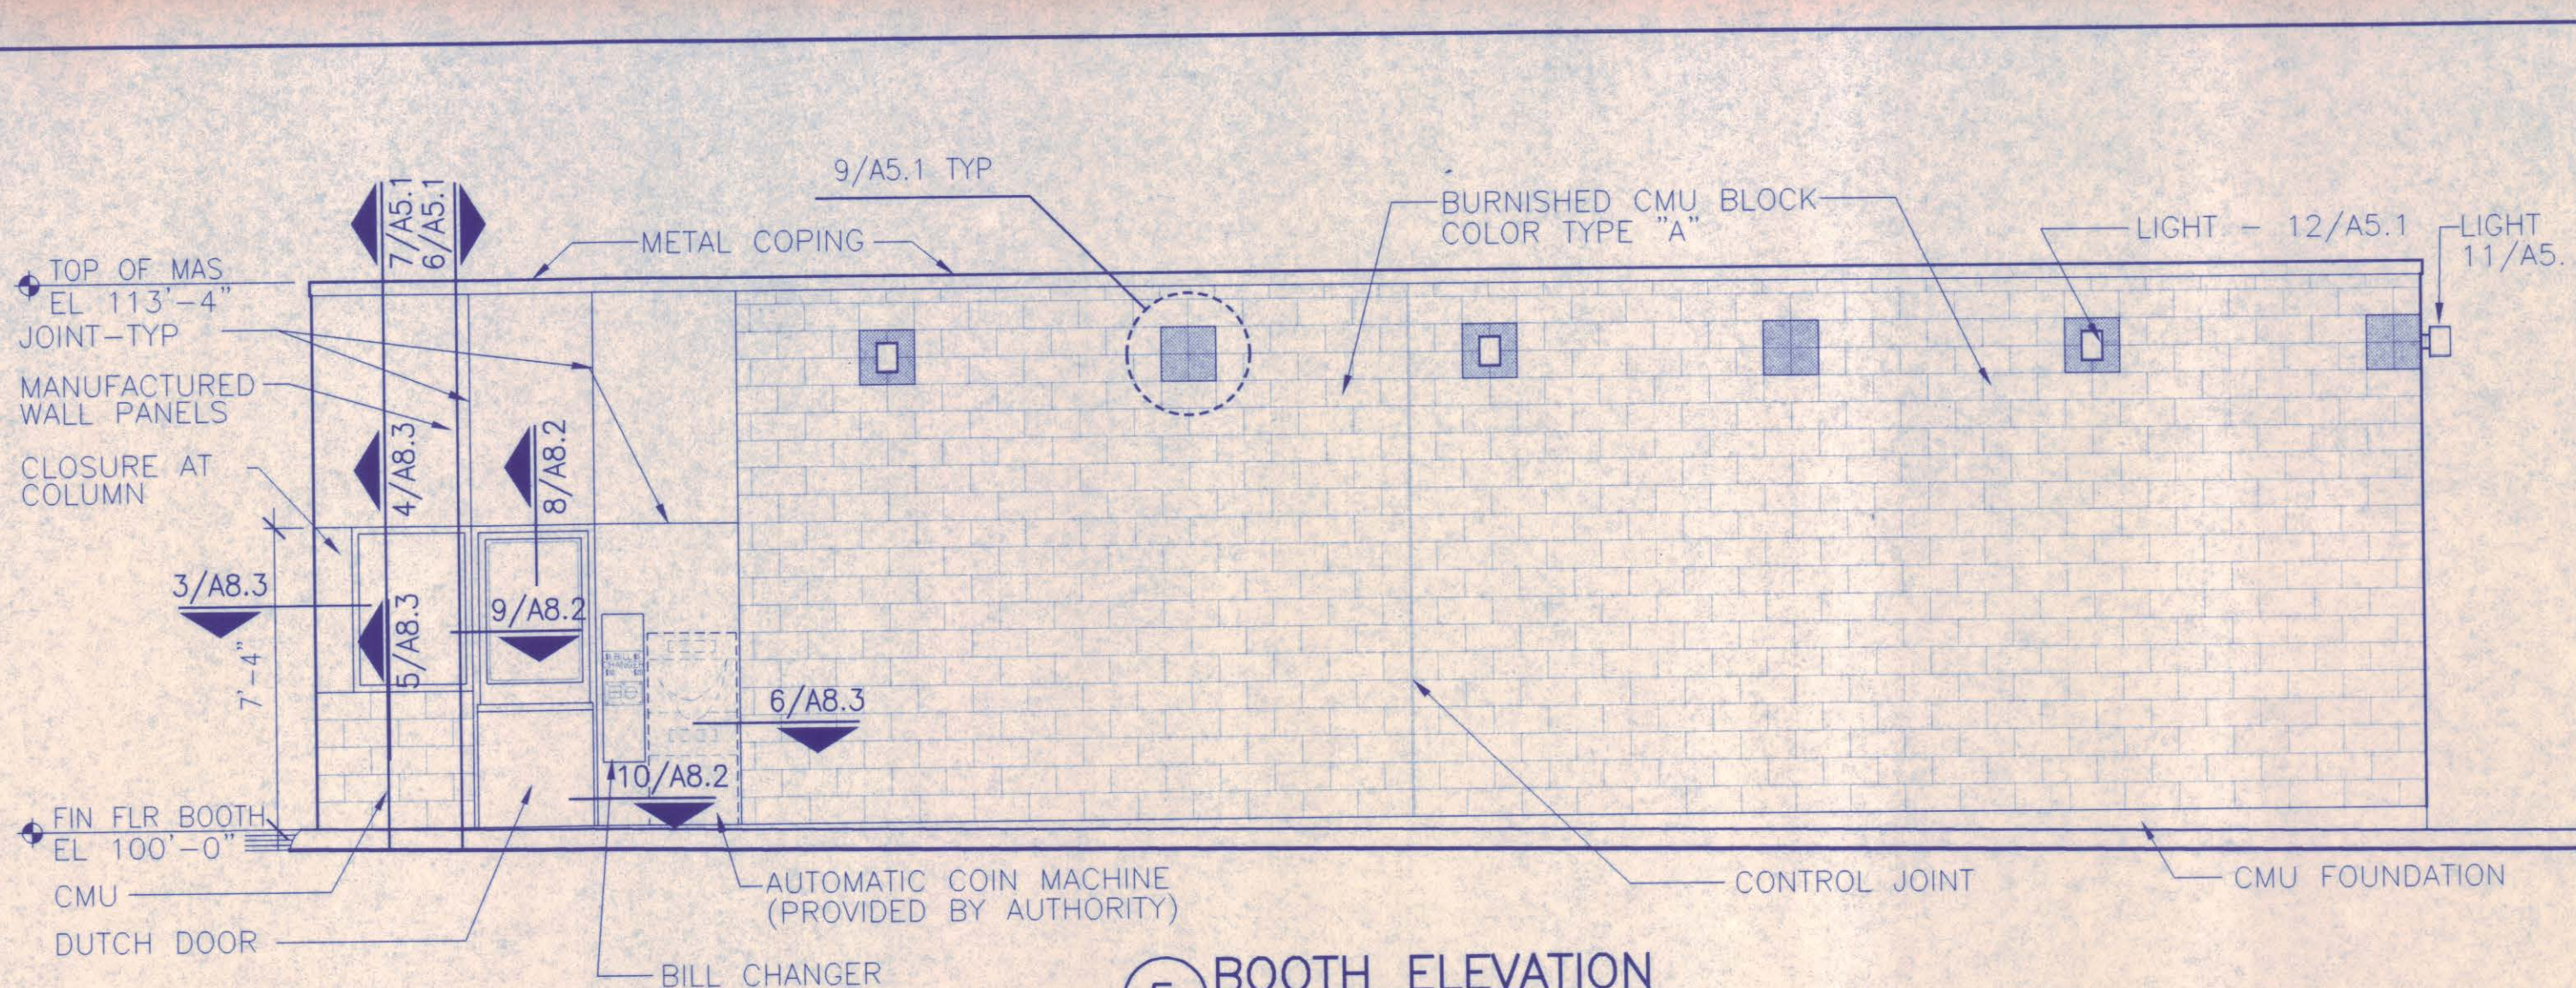


5 BOOTH ELEVATION
1/4"=1'-0"

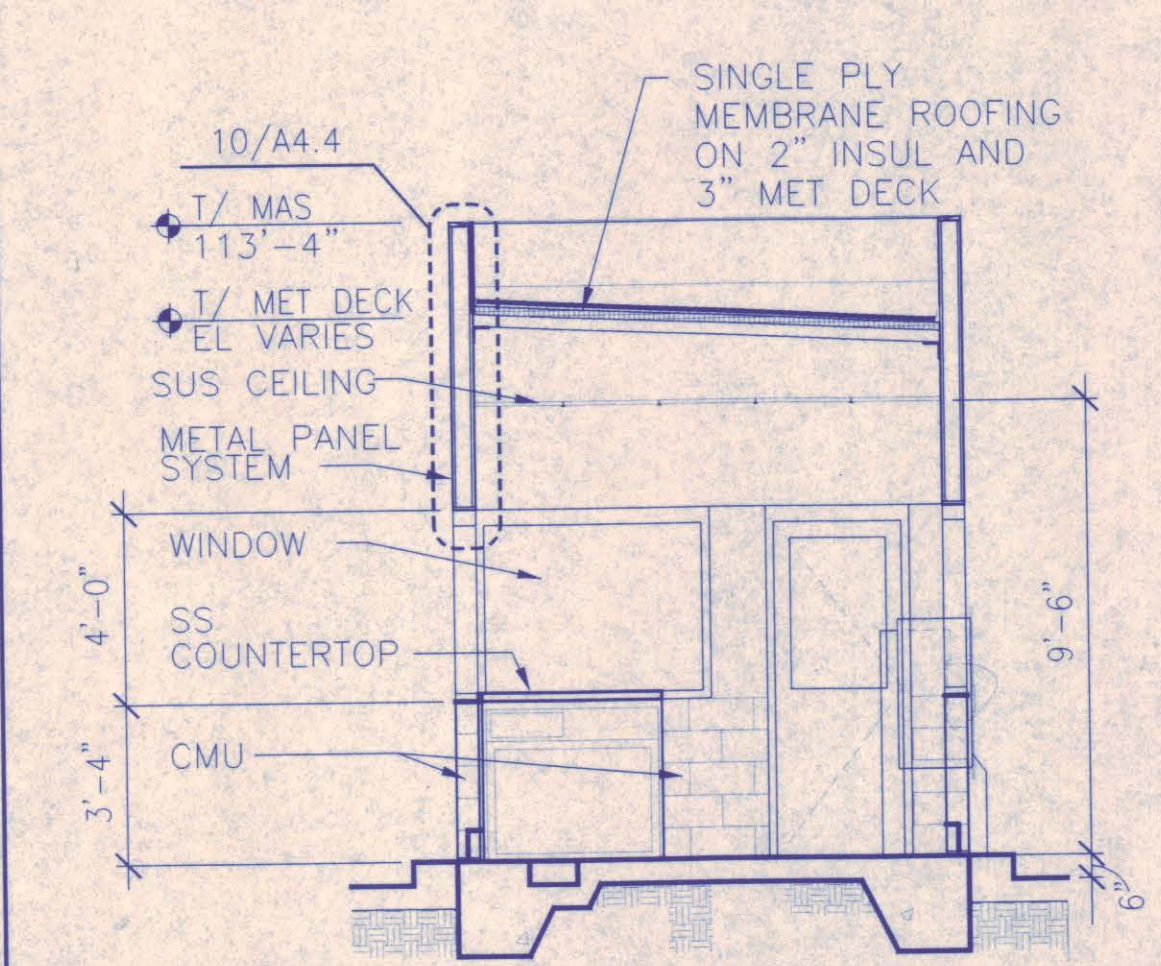


7 BOOTH SECTION
1/4"=1'-0"

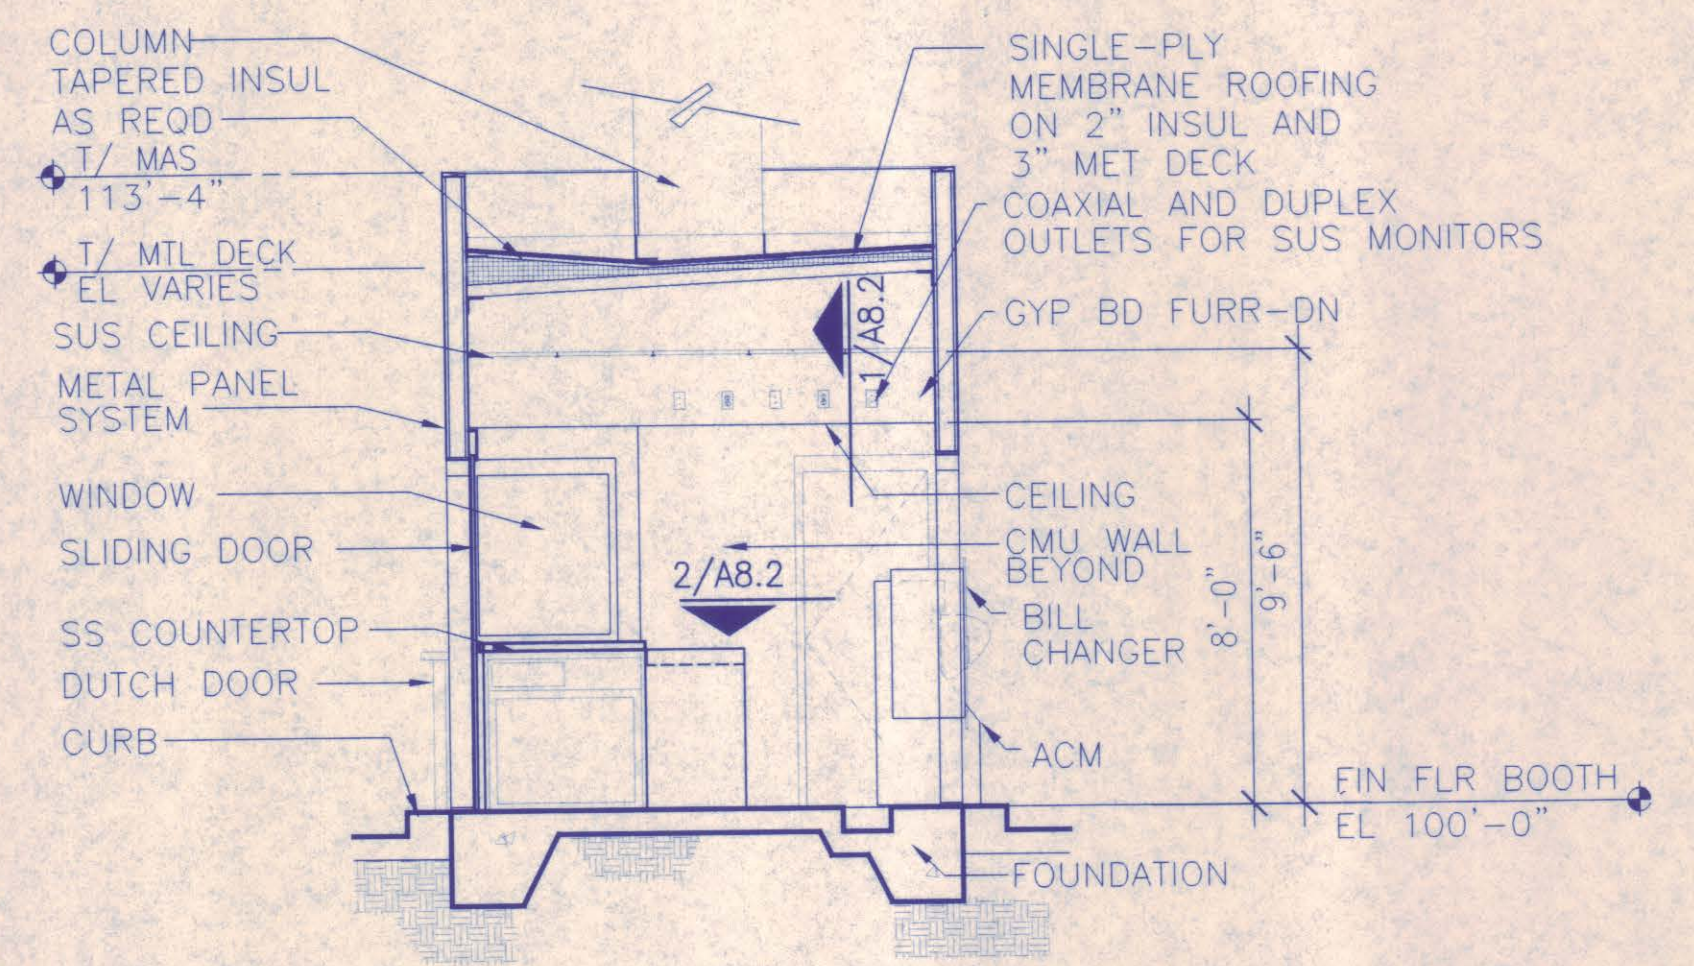


6 BOOTH SECTION
1/4"=1'-0"

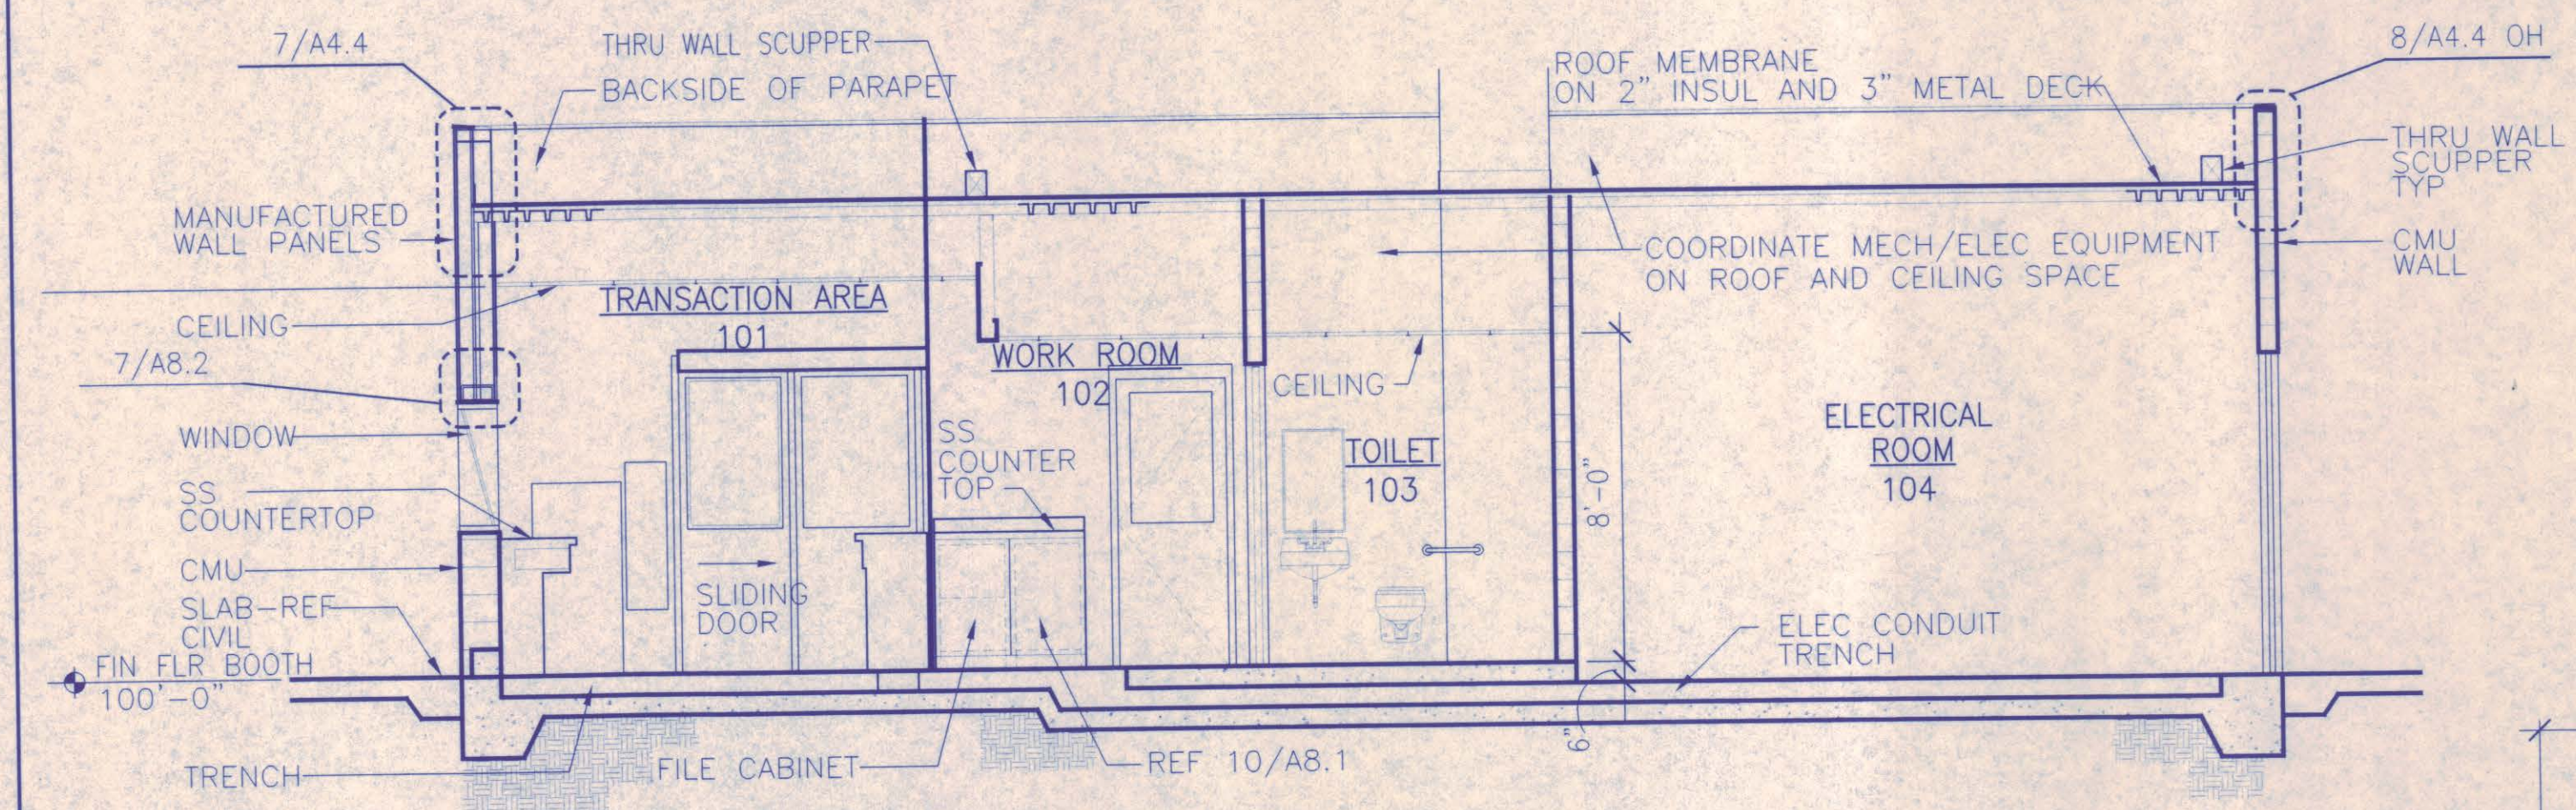


3 BOOTH SECTION
1/4"=1'-0"

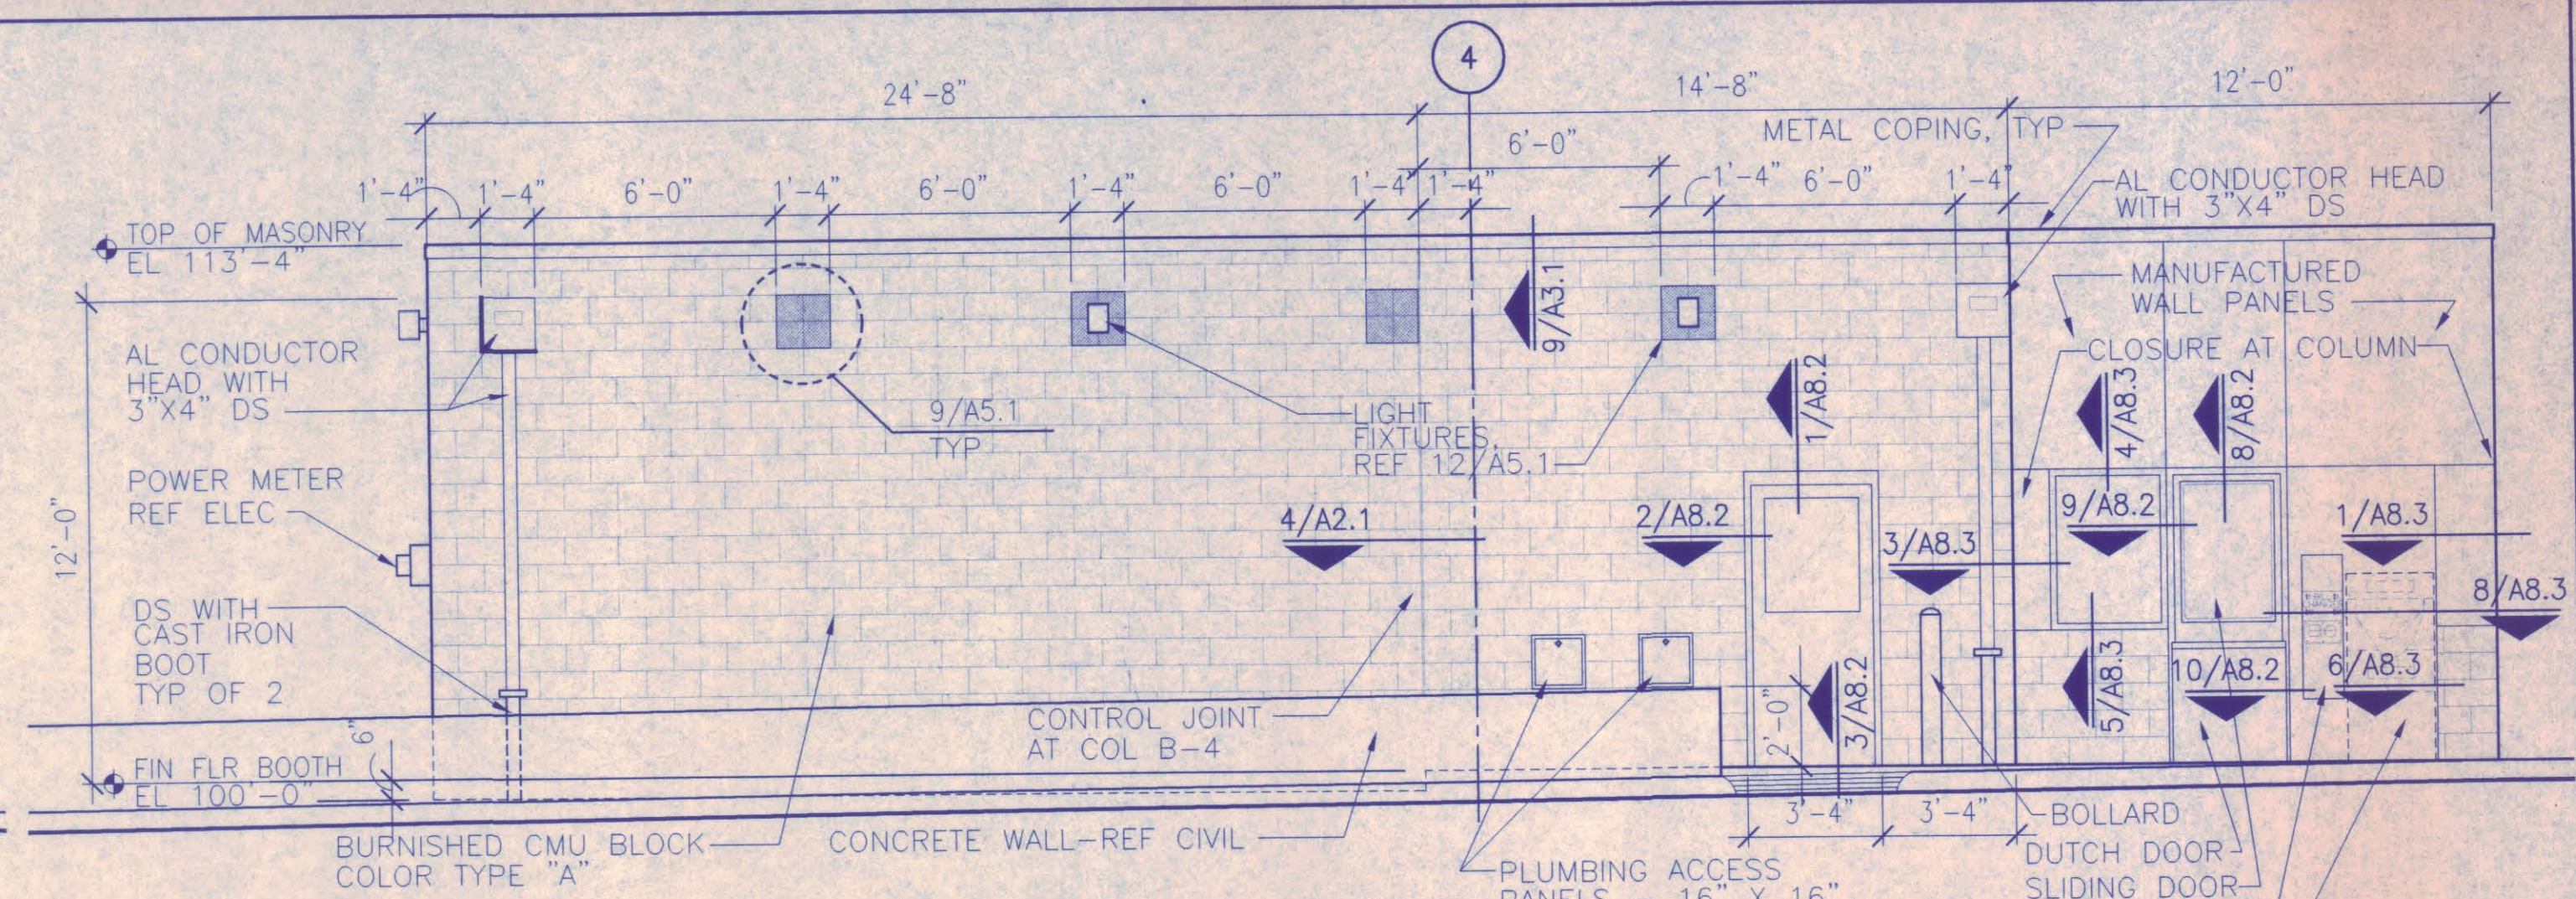


1 BOOTH ELEVATION
1/4"=1'-0"

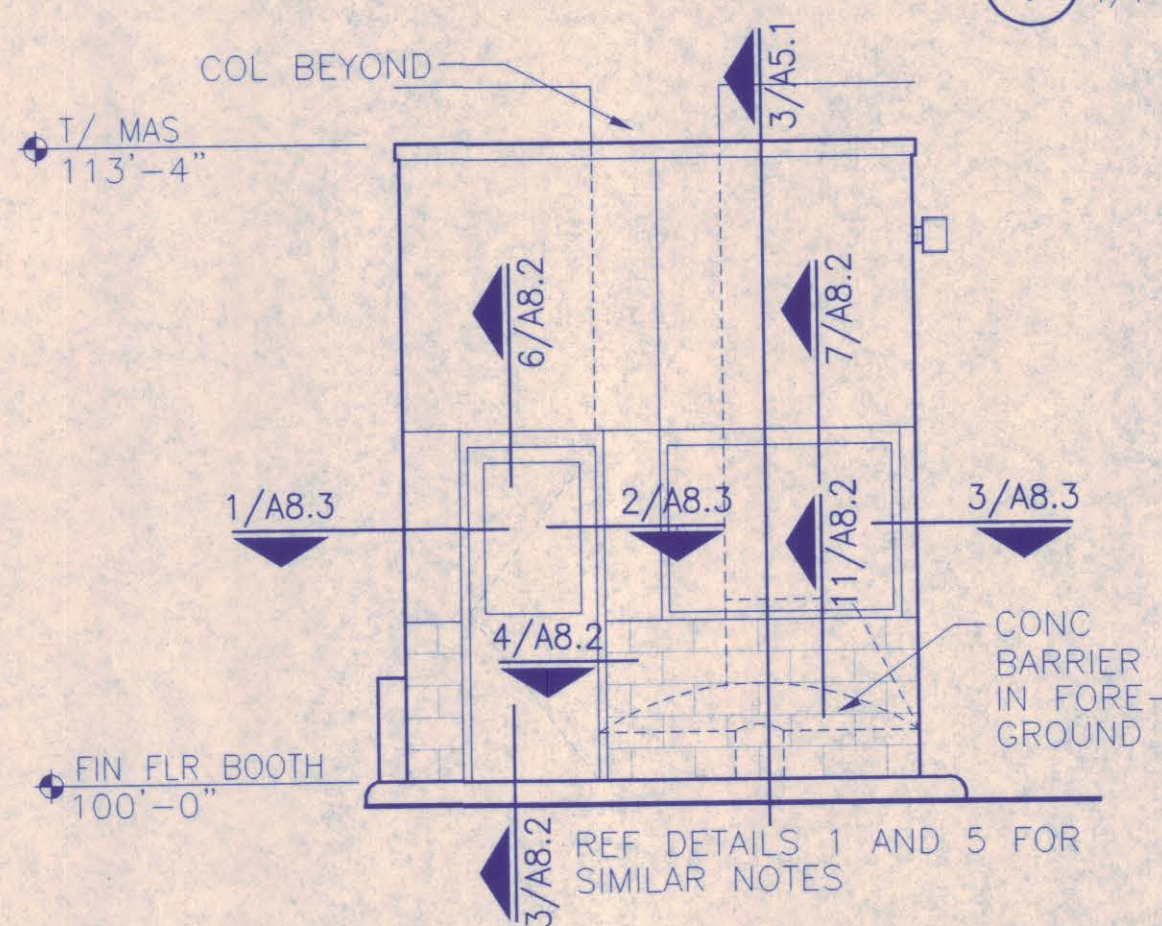


4 BOOTH ELEVATION
1/4"=1'-0"

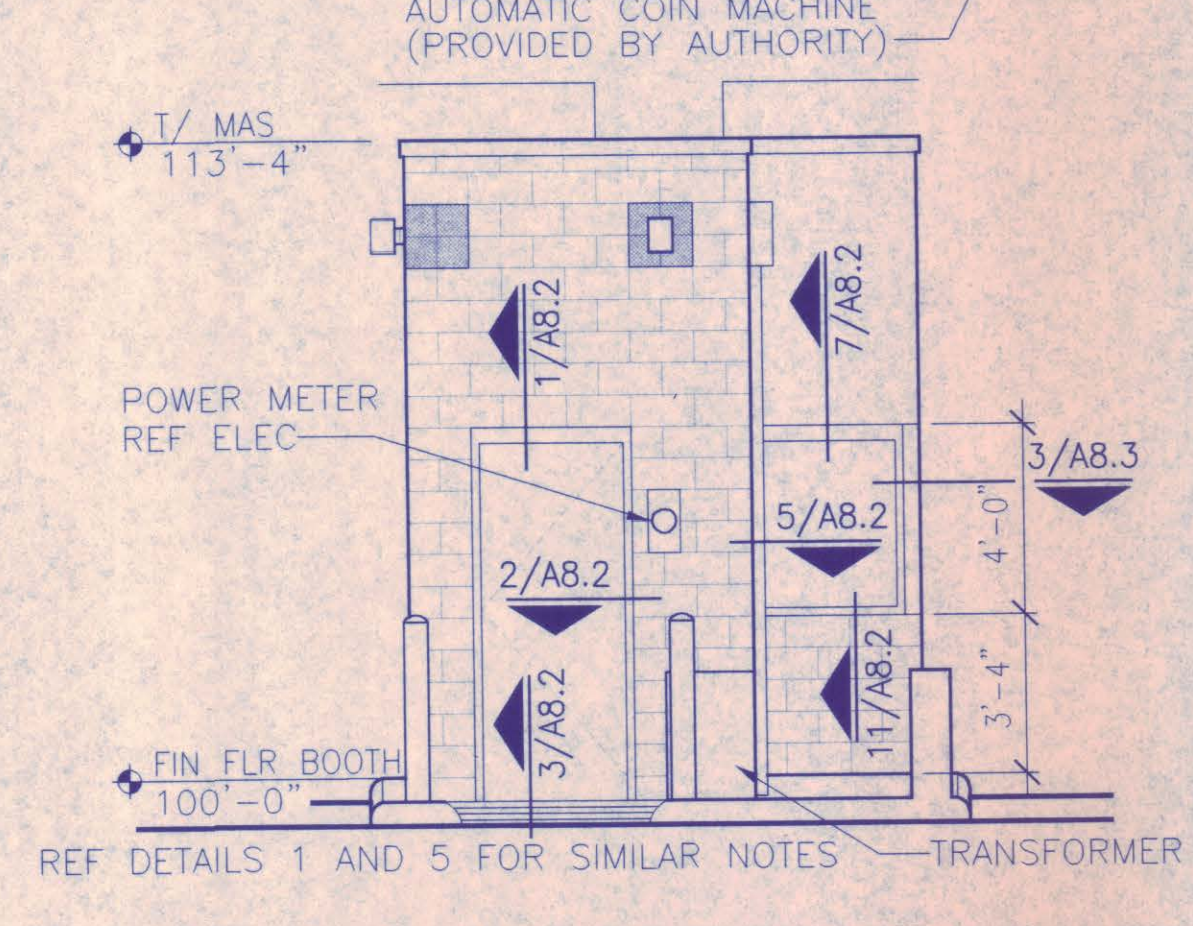


2 BOOTH ELEVATION
1/4"=1'-0"

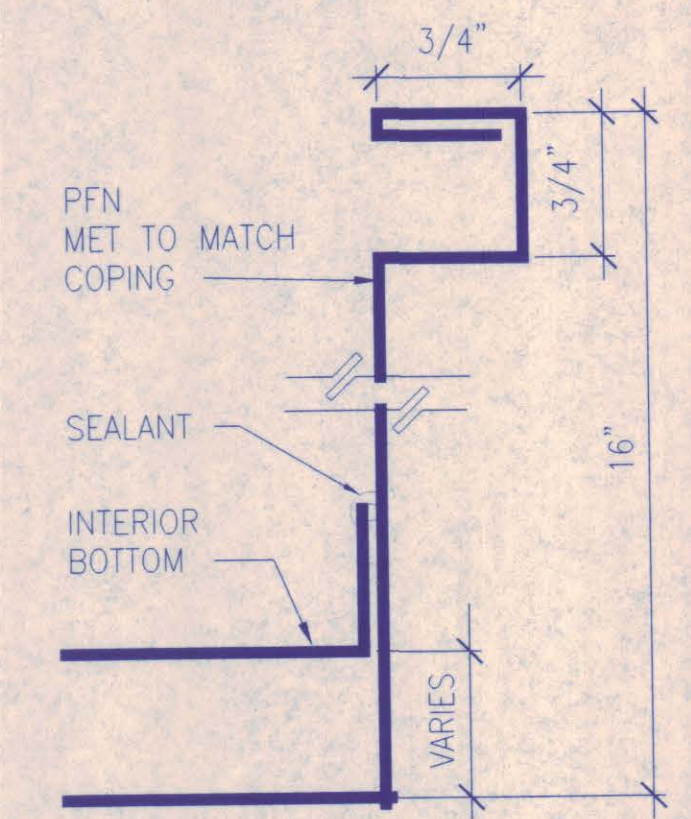


8 CONDUCTOR HEAD
FULL SIZE

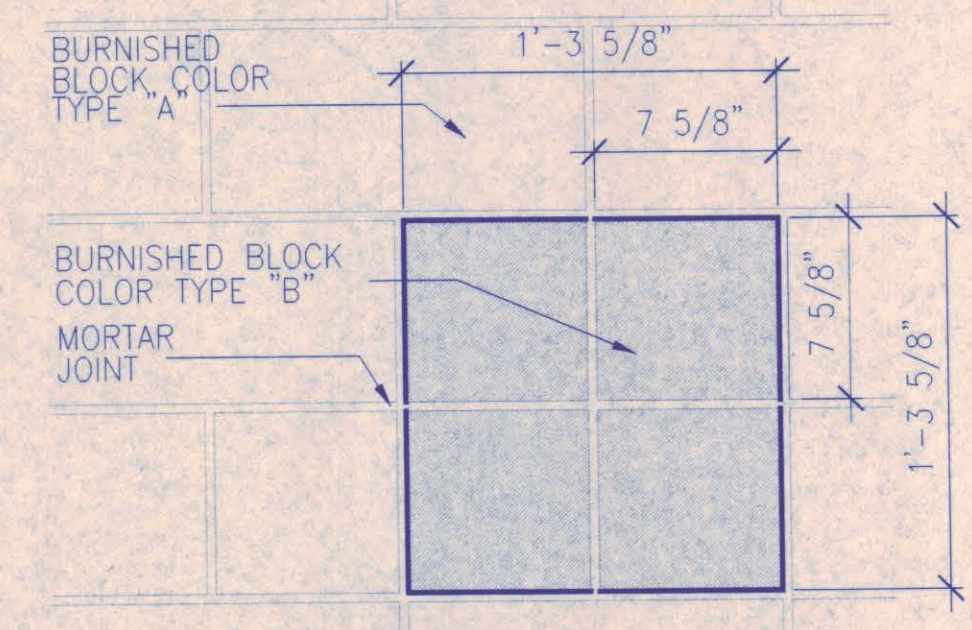


9 DETAIL
1 1/2"=1'-0"

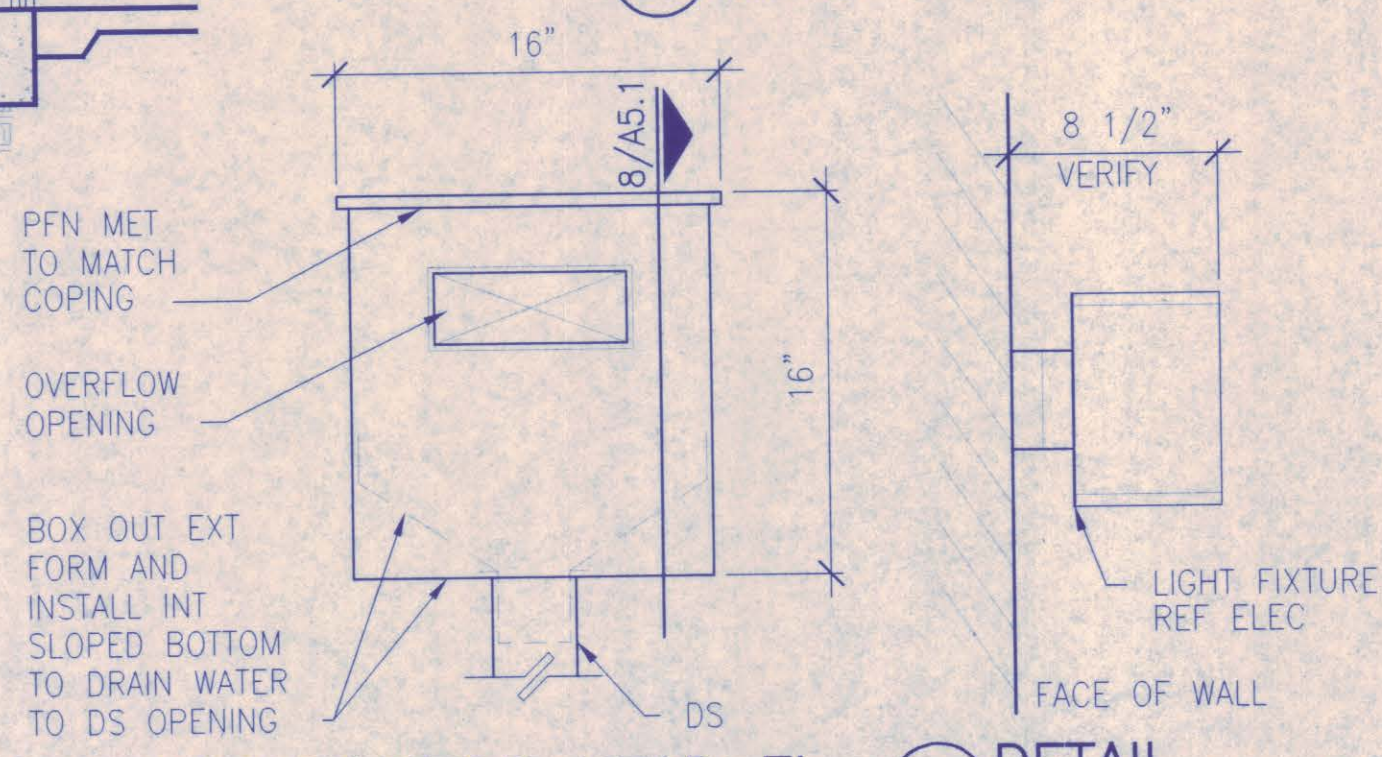

10 CONDUCTOR HEAD EL
1 1/2"=1'-0"

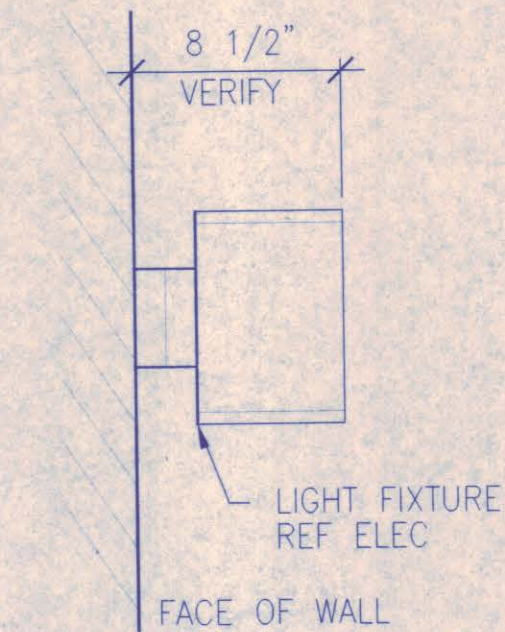


11 DETAIL
1 1/2"=1'-0"

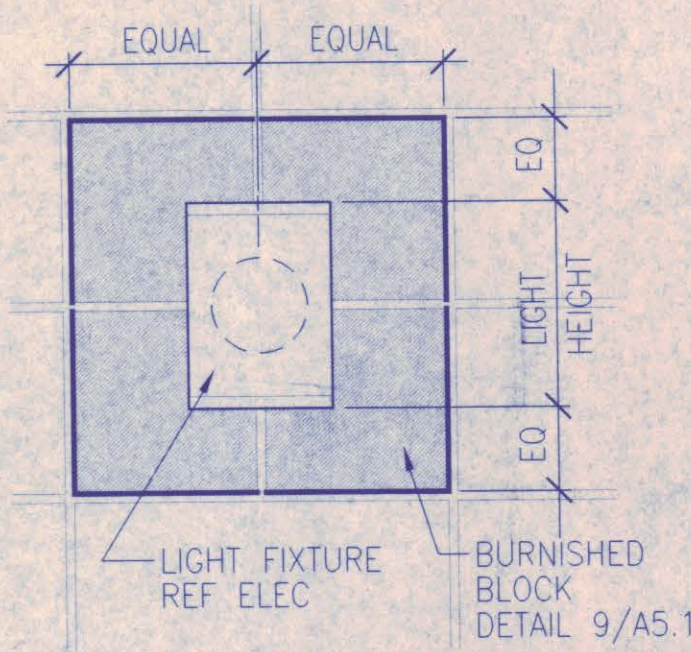


12 DETAIL
1 1/2"=1'-0"


AT-A5.1

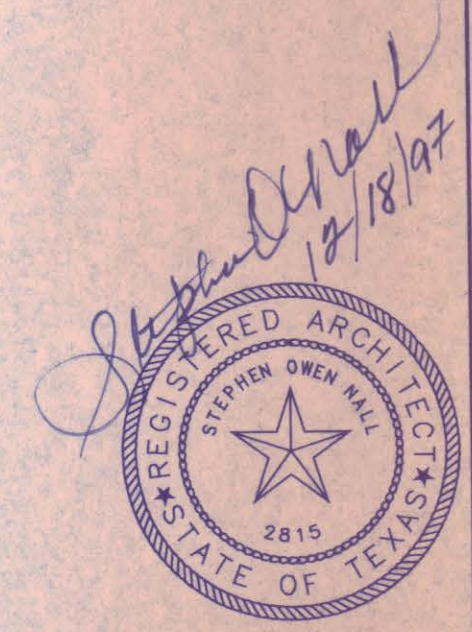


NO.	REVISION	BY	DATE
NORTH TEXAS TOLLWAY AUTHORITY			
ADDISON AIRPORT TUNNEL			
BARRIER TOLL PLAZA			
TUNNEL PLAZA			
BOOTH ELEVATIONS,			
SECTIONS AND DETAILS			
AGUIRRE Corporation 8700 PARK CENTRAL DRIVE 15 TH FLOOR DALLAS TEXAS 75201 TEL. 972-788-9000			SECTION XIII
CHECKED <i>SS</i>	DATE 12/18/97	DESIGNED MM	DATE 8/15/96
CHECKED <i>SS</i>	DATE 12/18/97	SCALE AS SHOWN	
CONTRACT NO. DNT-290		SHEET 27 OF 53	

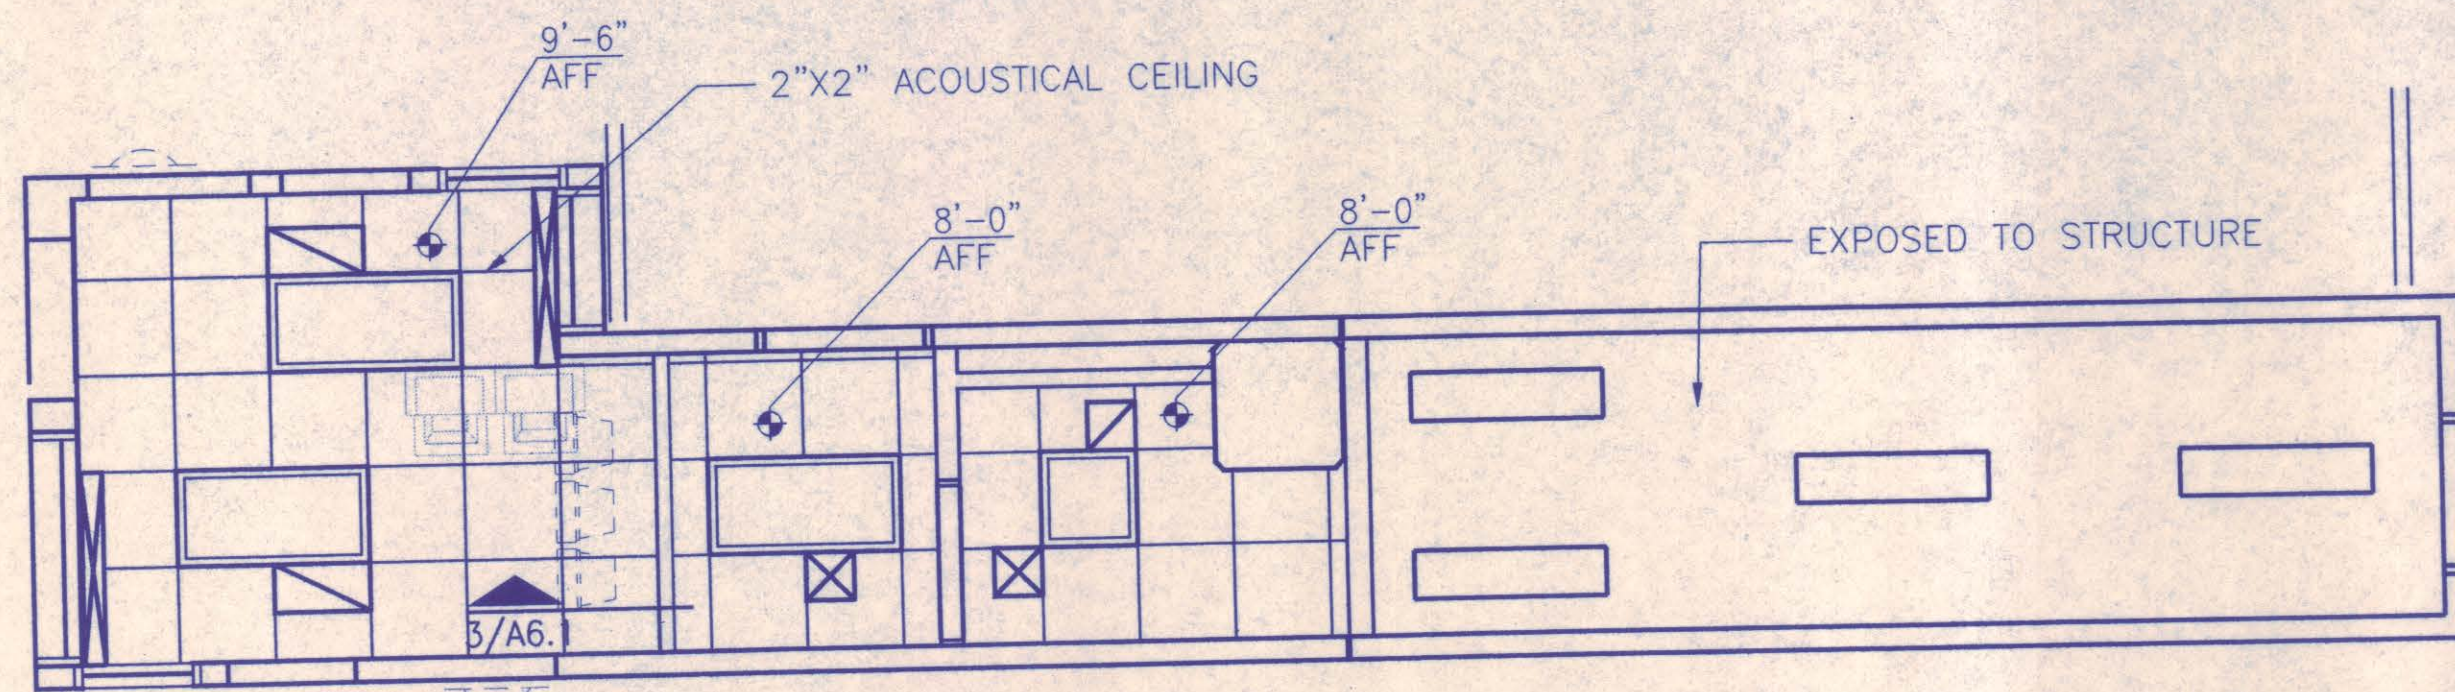

2 BOOTH REFLECTED CEILING PLAN
1/4"=1'-0" TAATAPC2

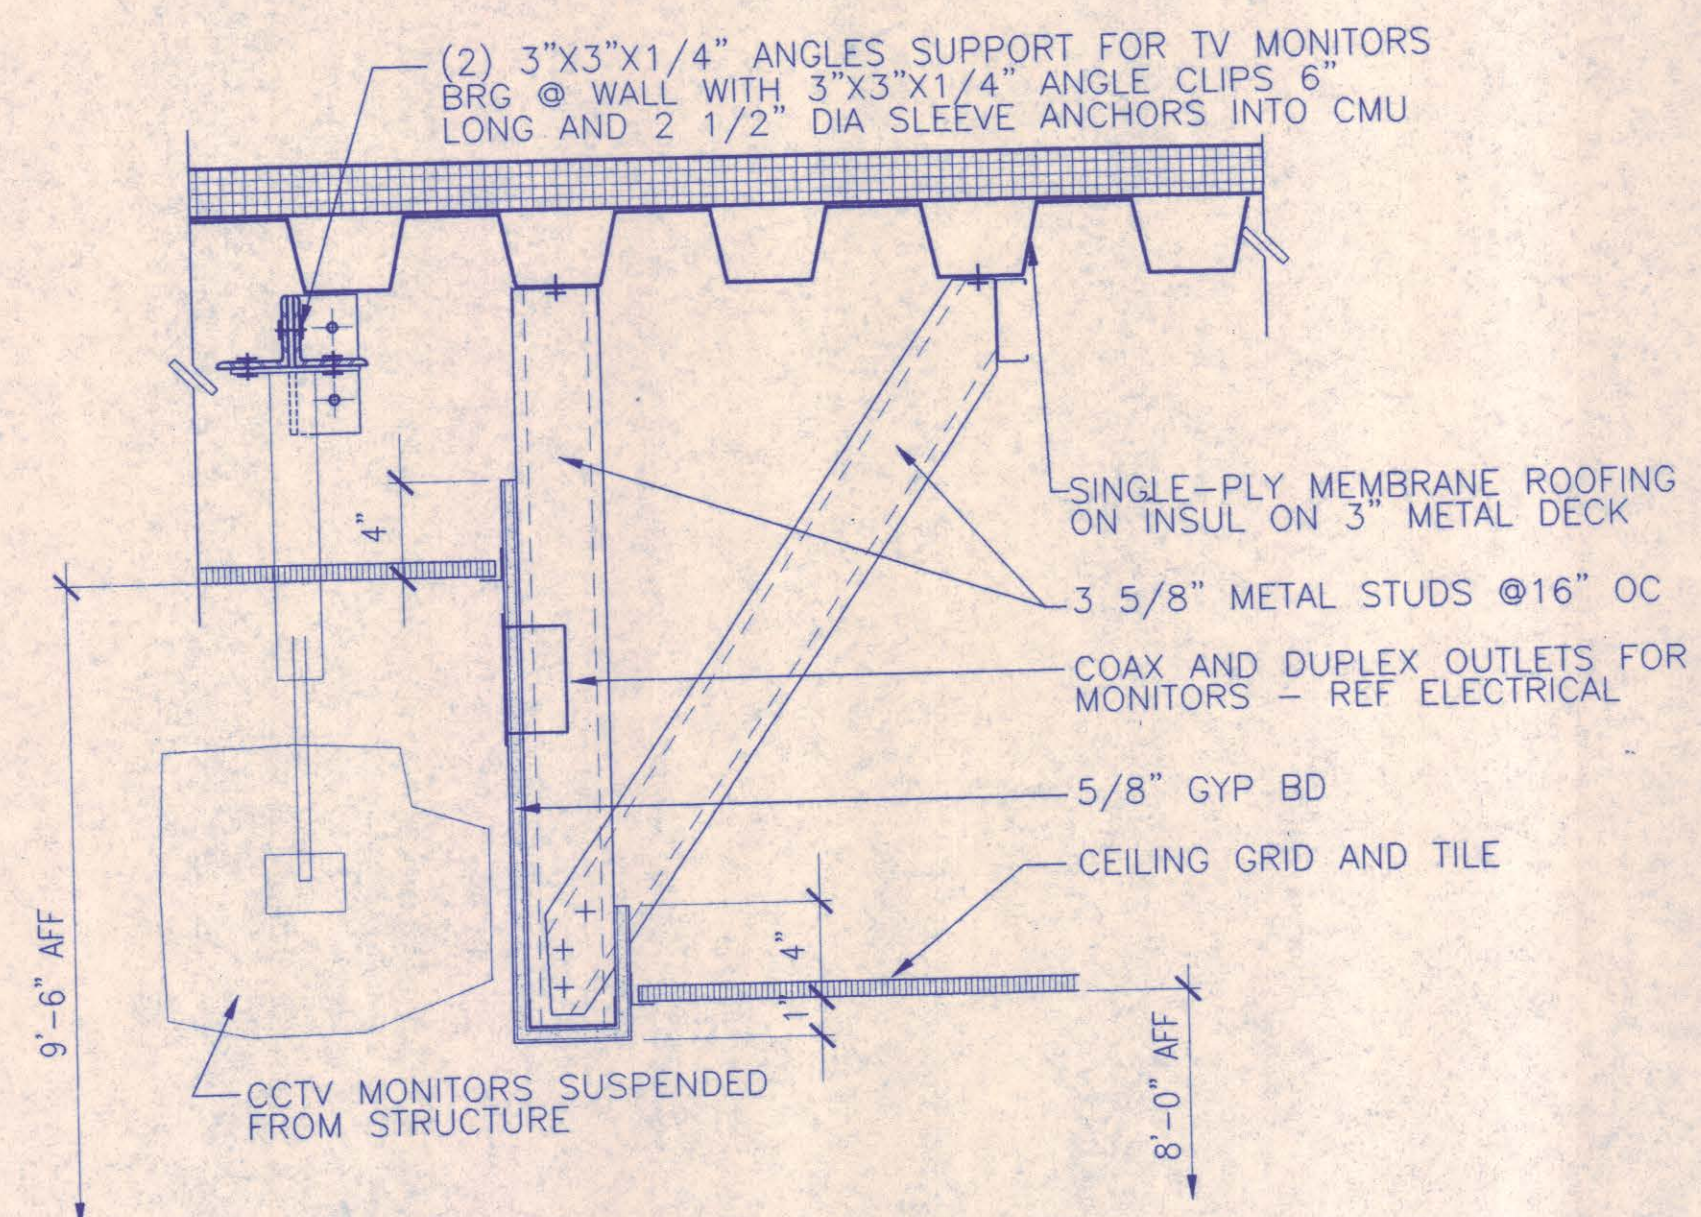

3 FURR-DOWN DETAIL
1 1/2"=1'-0" TAATAD33

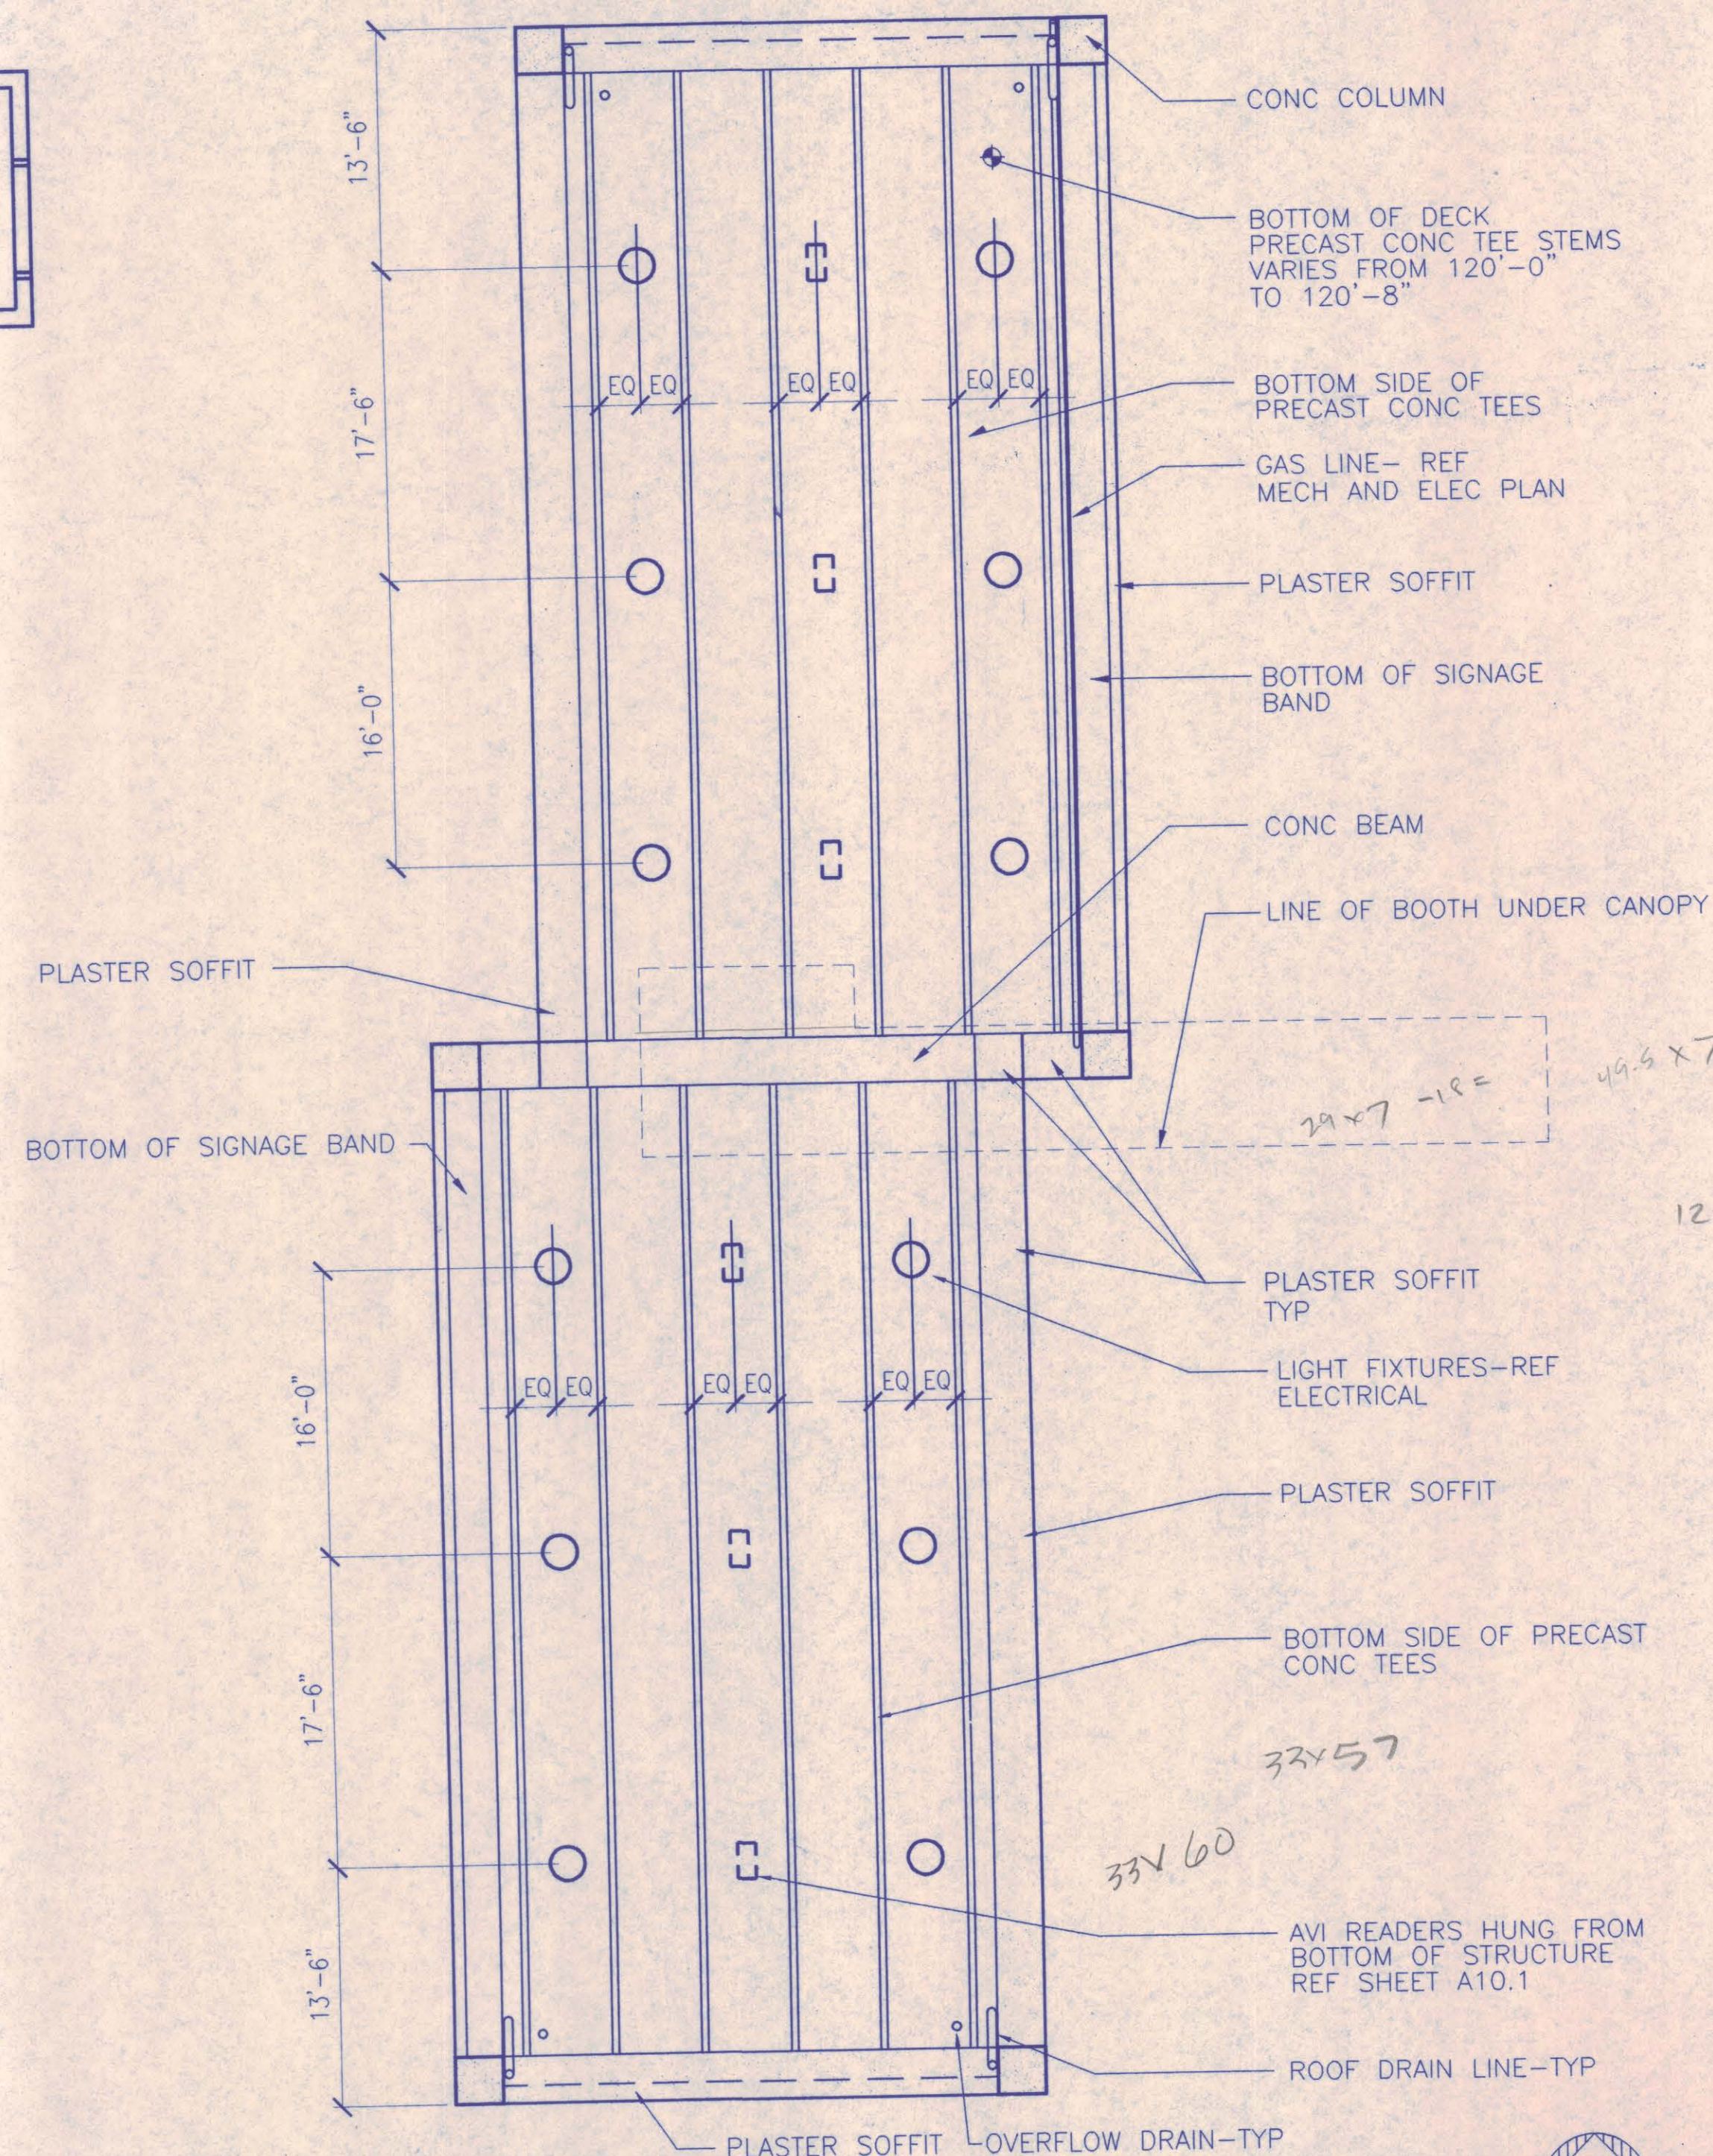

1 CANOPY REFLECTED CEILING PLAN
1/8"=1'-0" TAATAPC1

GENERAL NOTES

1. COORDINATE ALL WORK WITH ELECTRICAL AND MECHANICAL PLANS.

PROVIDE BIRD PREVENTION SYSTEMS AT EACH END OF ALL PRECAST CONCRETE TEES; TO BE MOUNTED ON TOP OF THE SUPPORTING CONCRETE BEAMS

PRECAST CONC TEES

SUPPORTING CONCRETE BEAM

LEGEND

- ## 2 X 2 ACOUSTICAL CLG GRID & TILES
- ☐ RETURN AIR GRILLE
- ☒ SUPPLY AIR GRILLE
- LAY-IN LIGHT FIXTURE
- SURFACE MOUNTED/HUNG LIGHT FIXTURE
- ▭ STRIP LIGHT SURFACE MOUNTED

NO.	REVISION	BY	DATE
NORTH TEXAS TOLLWAY AUTHORITY			
ADDISON AIRPORT TUNNEL			
BARRIER TOLL PLAZA			
TUNNEL PLAZA			
REFLECTED			
CEILING PLANS			
AGUIRRE Corporation 2700 PARK CENTRAL DRIVE 25 TH FLOOR DALLAS TEXAS 75201 Tel. (972) 750-1000			SECTION XIII
CHECKED <i>San</i>	DATE 12/18/97	DESIGNED MM	DATE 8/15/96
CHECKED <i>leg</i>	DATE 12/18/97	SCALE AS SHOWN	
CONTRACT NO. DNT-290	SHEET 28	OF 53	

H:\aai-proj\9603-01\DWG\ADDISON\TAAT_A61.dwg
Wed Dec 10 13:41:40 1997


AT-A6.1




10 SIGNAGE TYPE 3 ELEVATION
1/4"=1'-0" TAATAD66




9 SIGNAGE TYPE 4 ELEVATION
1/4"=1'-0" TAATAD66

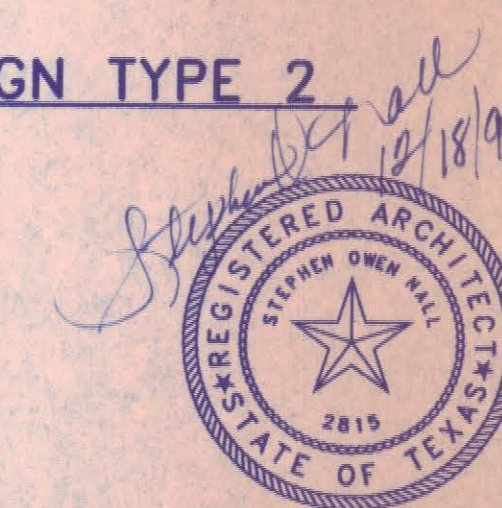


H:\aai-proj\9603-01\DWG\ADDISON\TAAT_A71.dwg
Wed, Dec 16, 13:13:11, 1998

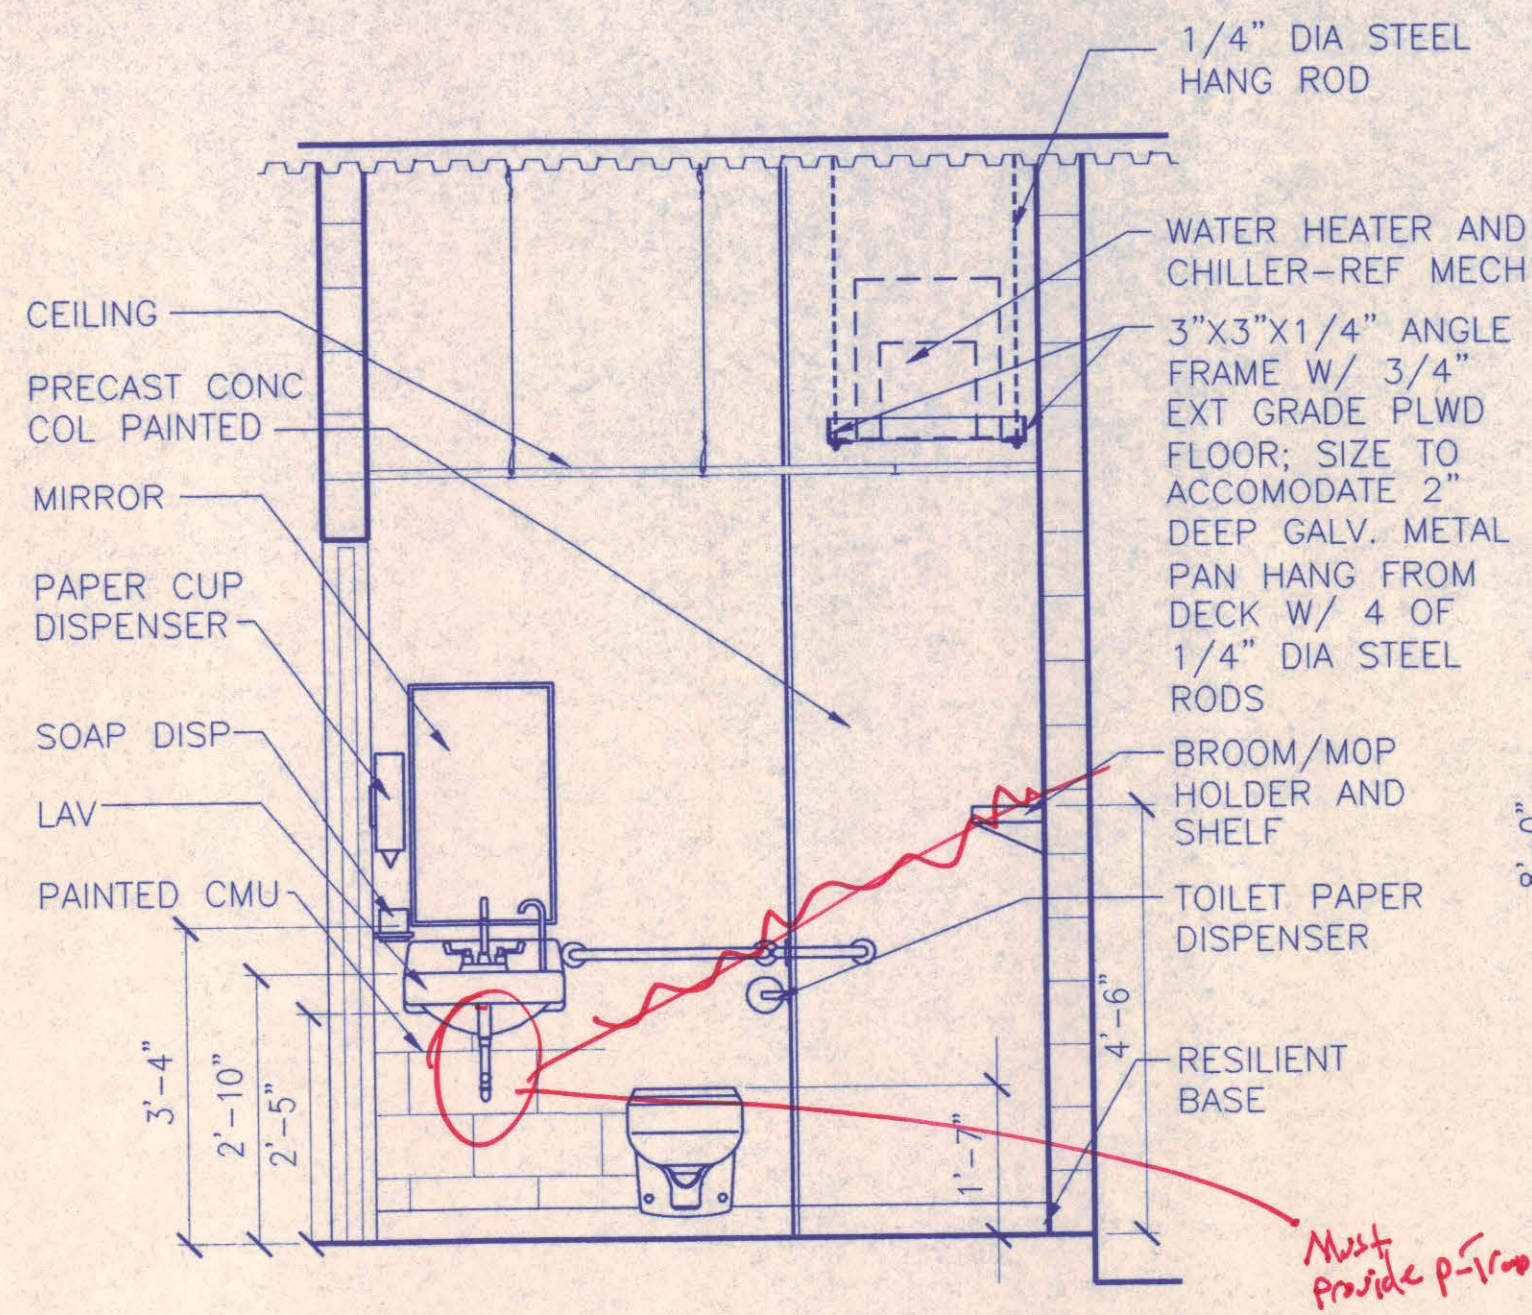


1 TOILET ELEVATION
1/2"=1'-0" TAATATE1

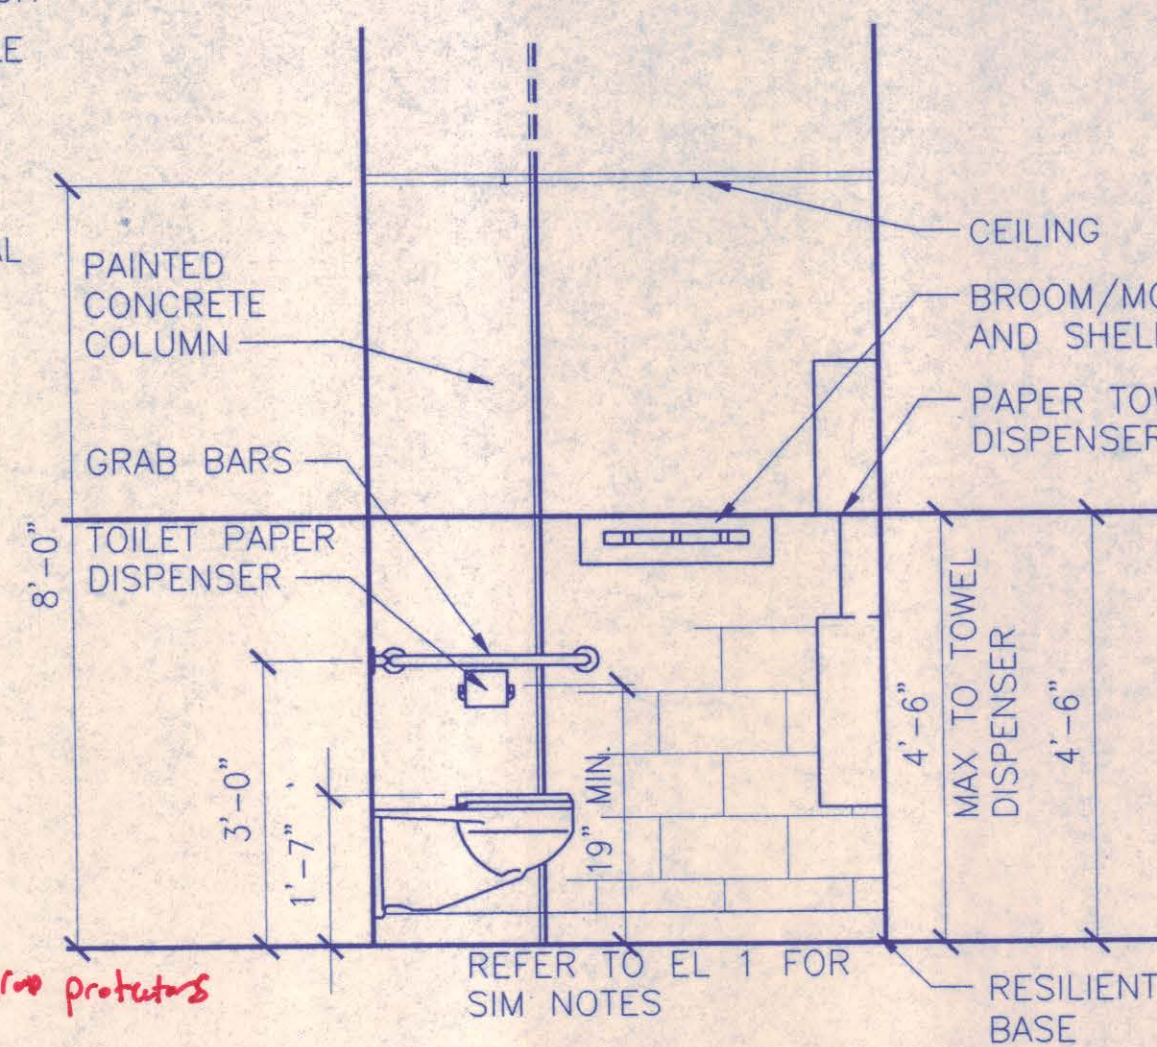


2 TOILET ELEVATION
1/2"=1'-0" TAATATE1

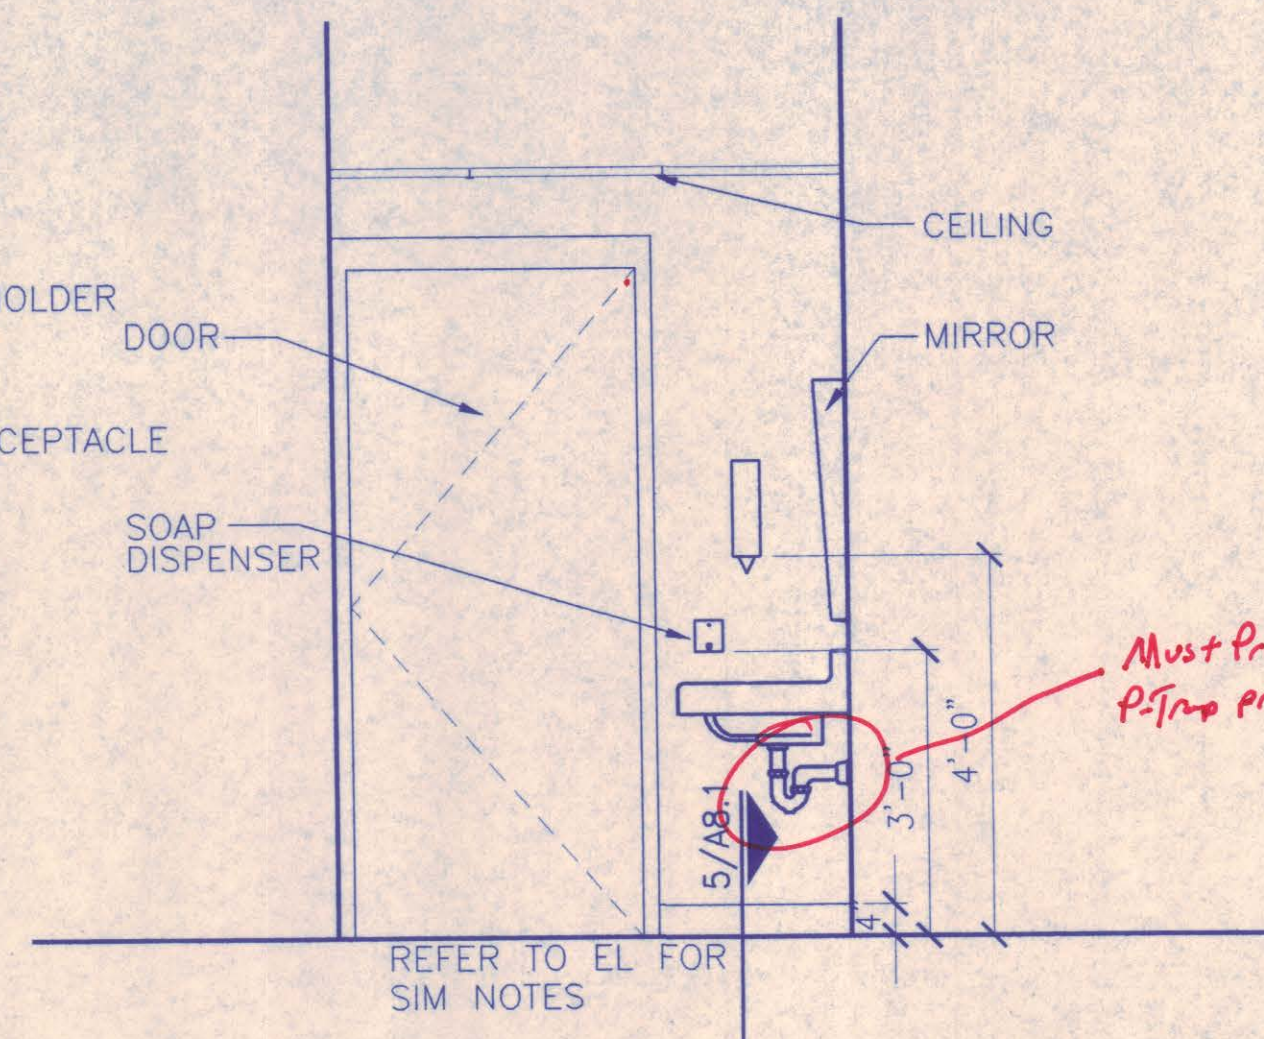


3 TOILET ELEVATION
1/2"=1'-0" TAATATE1

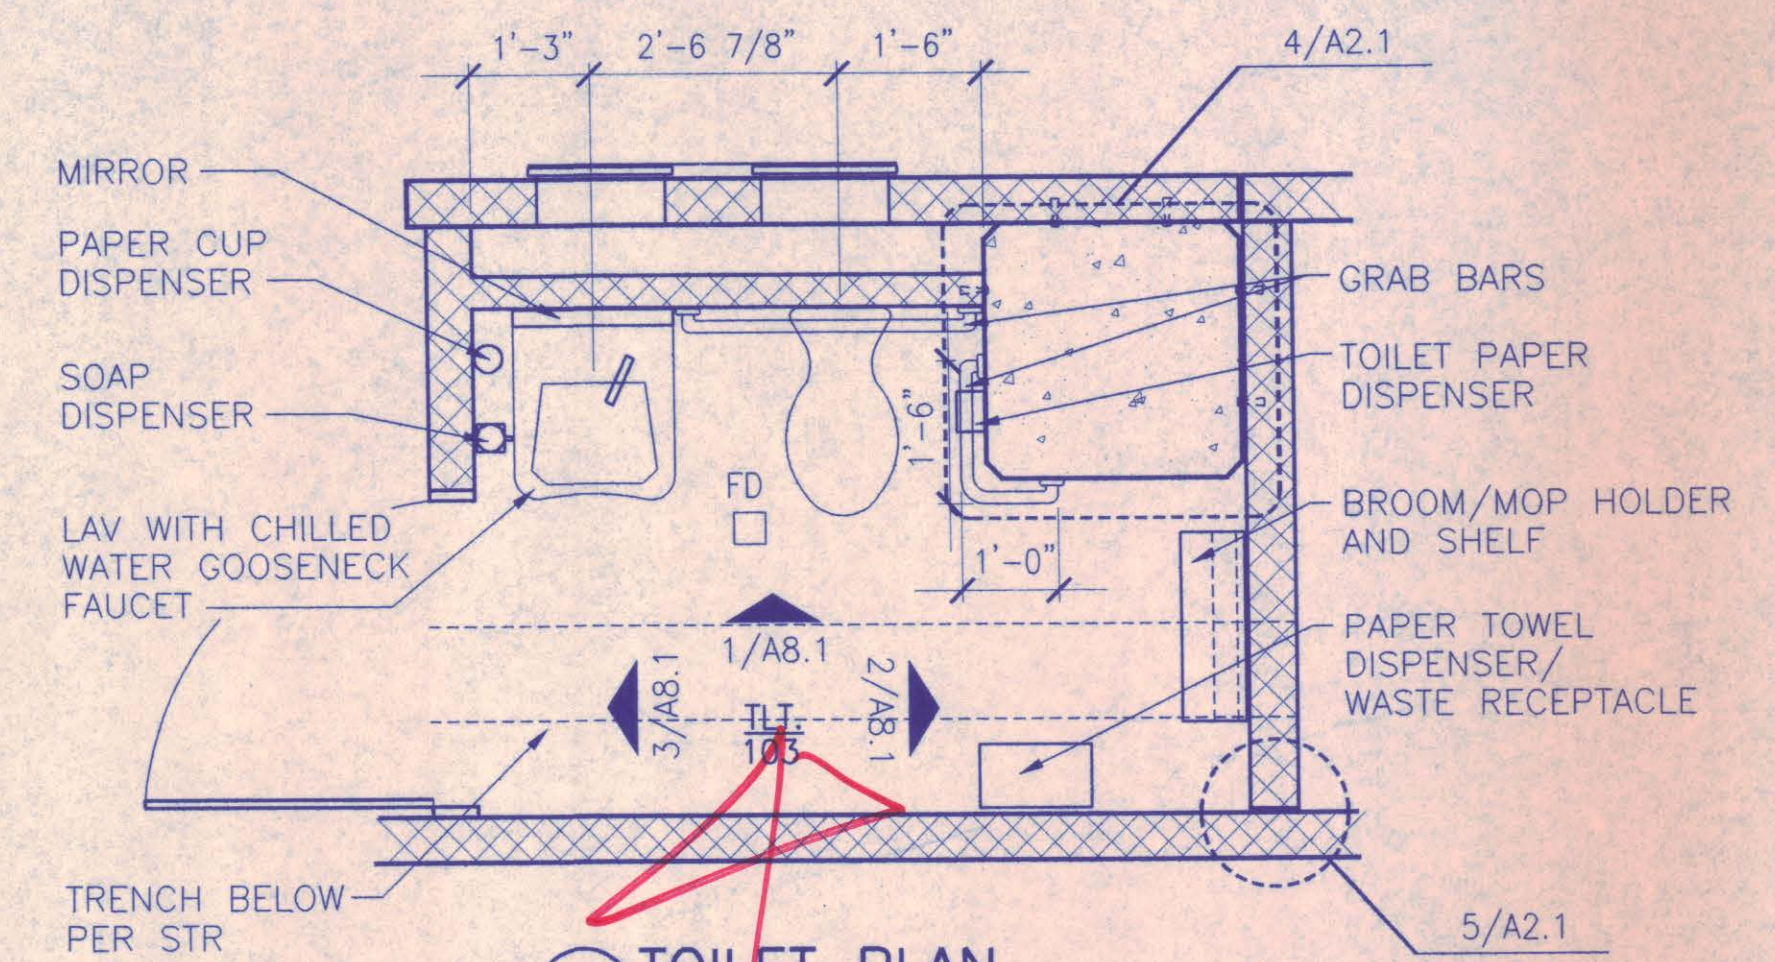


4 TOILET PLAN
1/2"=1'-0" TAATAPN3

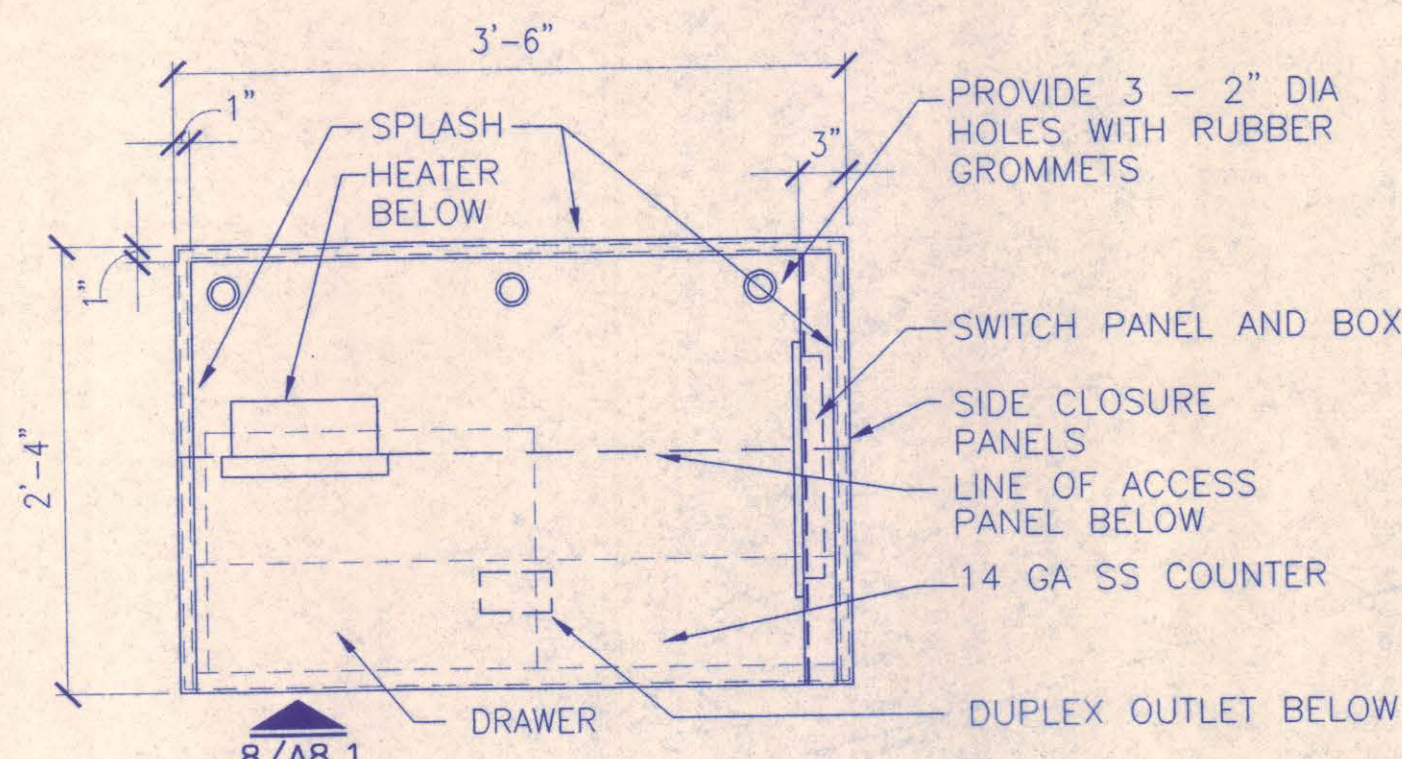


7 COUNTERTOP AT ATTENDANT
1"=1'-0" TAATAEQ1

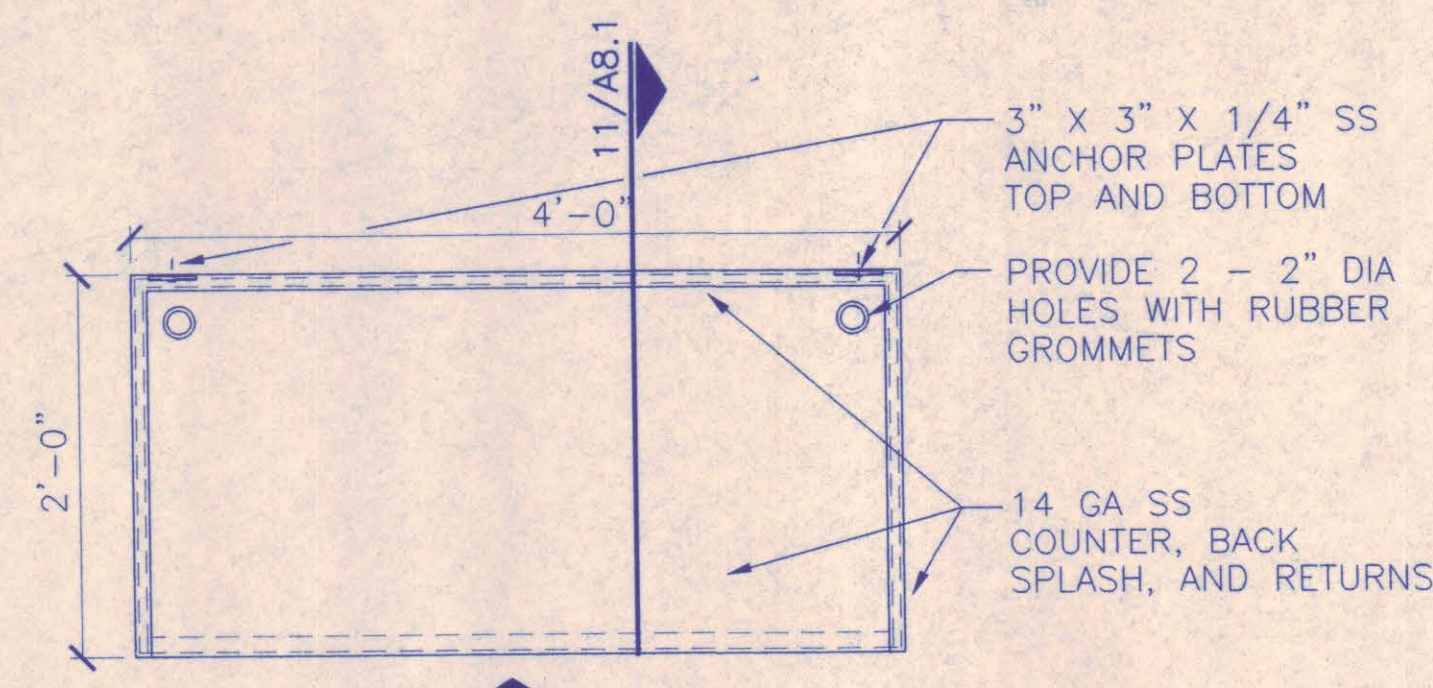


6 COUNTER TOP AT WORK AREA
1"=1'-0" TAATAEQ2

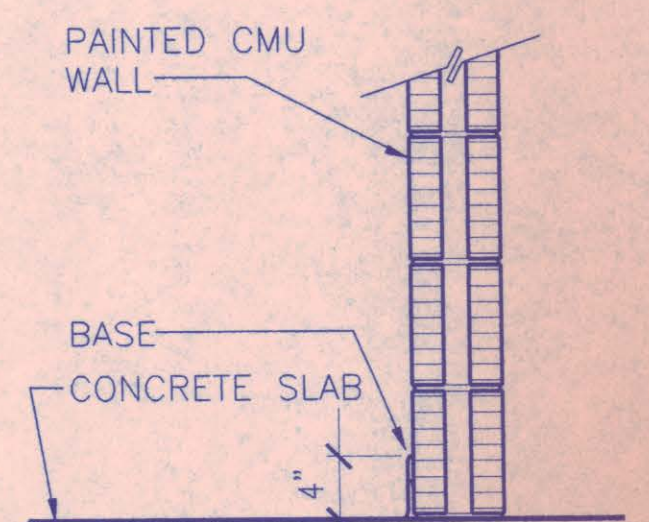


5 DETAIL
1"=1'-0" TAATAD34

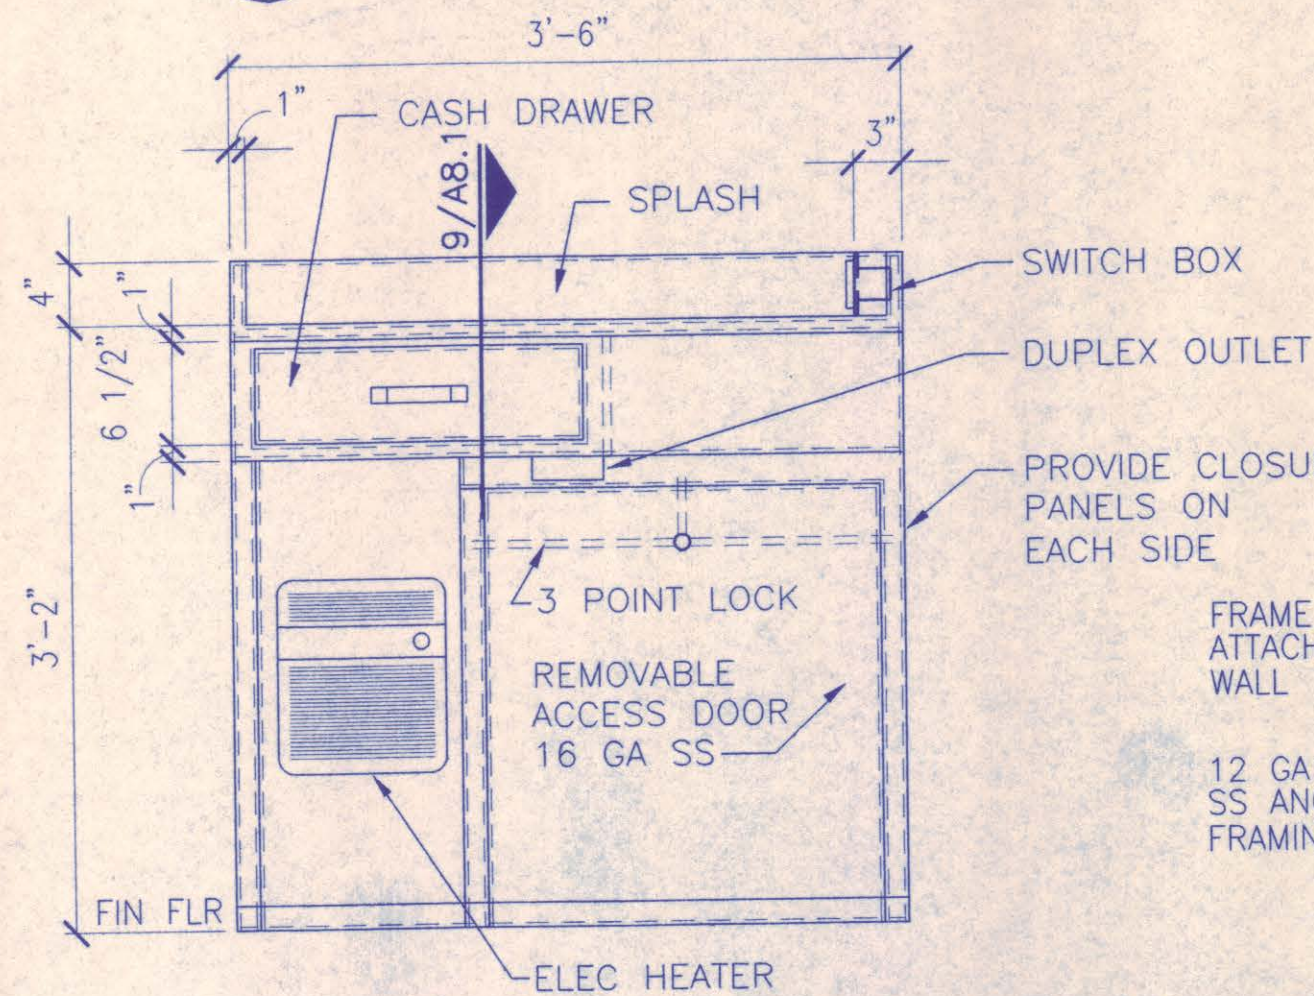

8 FRONT
1"=1'-0" TAATAEQ1

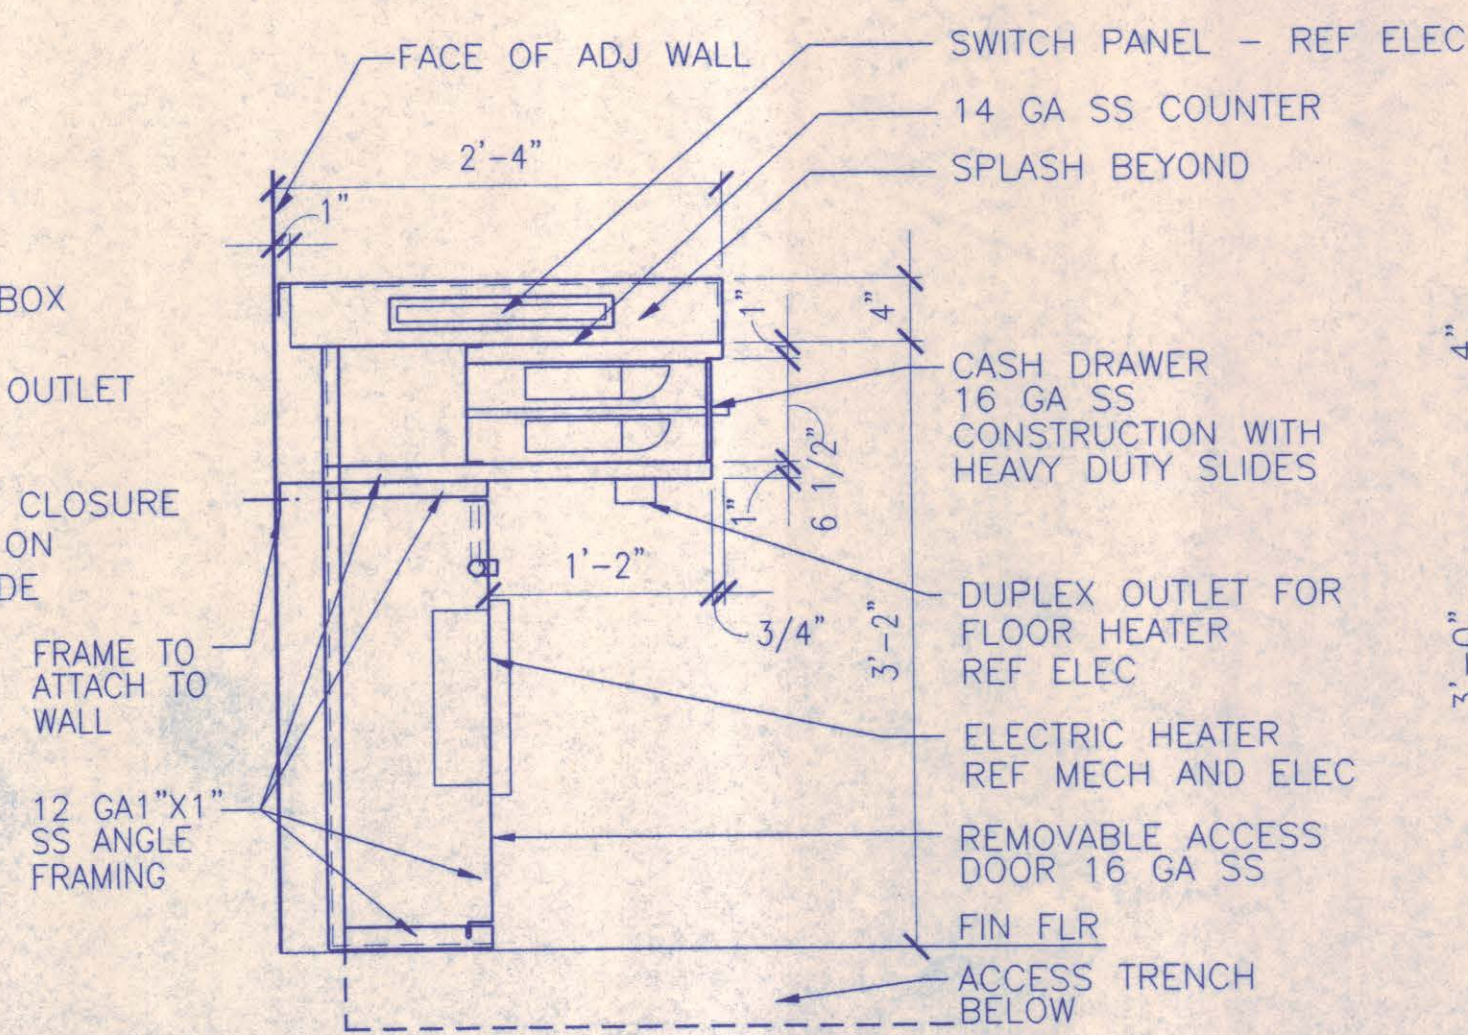


9 SECTION
1"=1'-0" TAATAEQ1

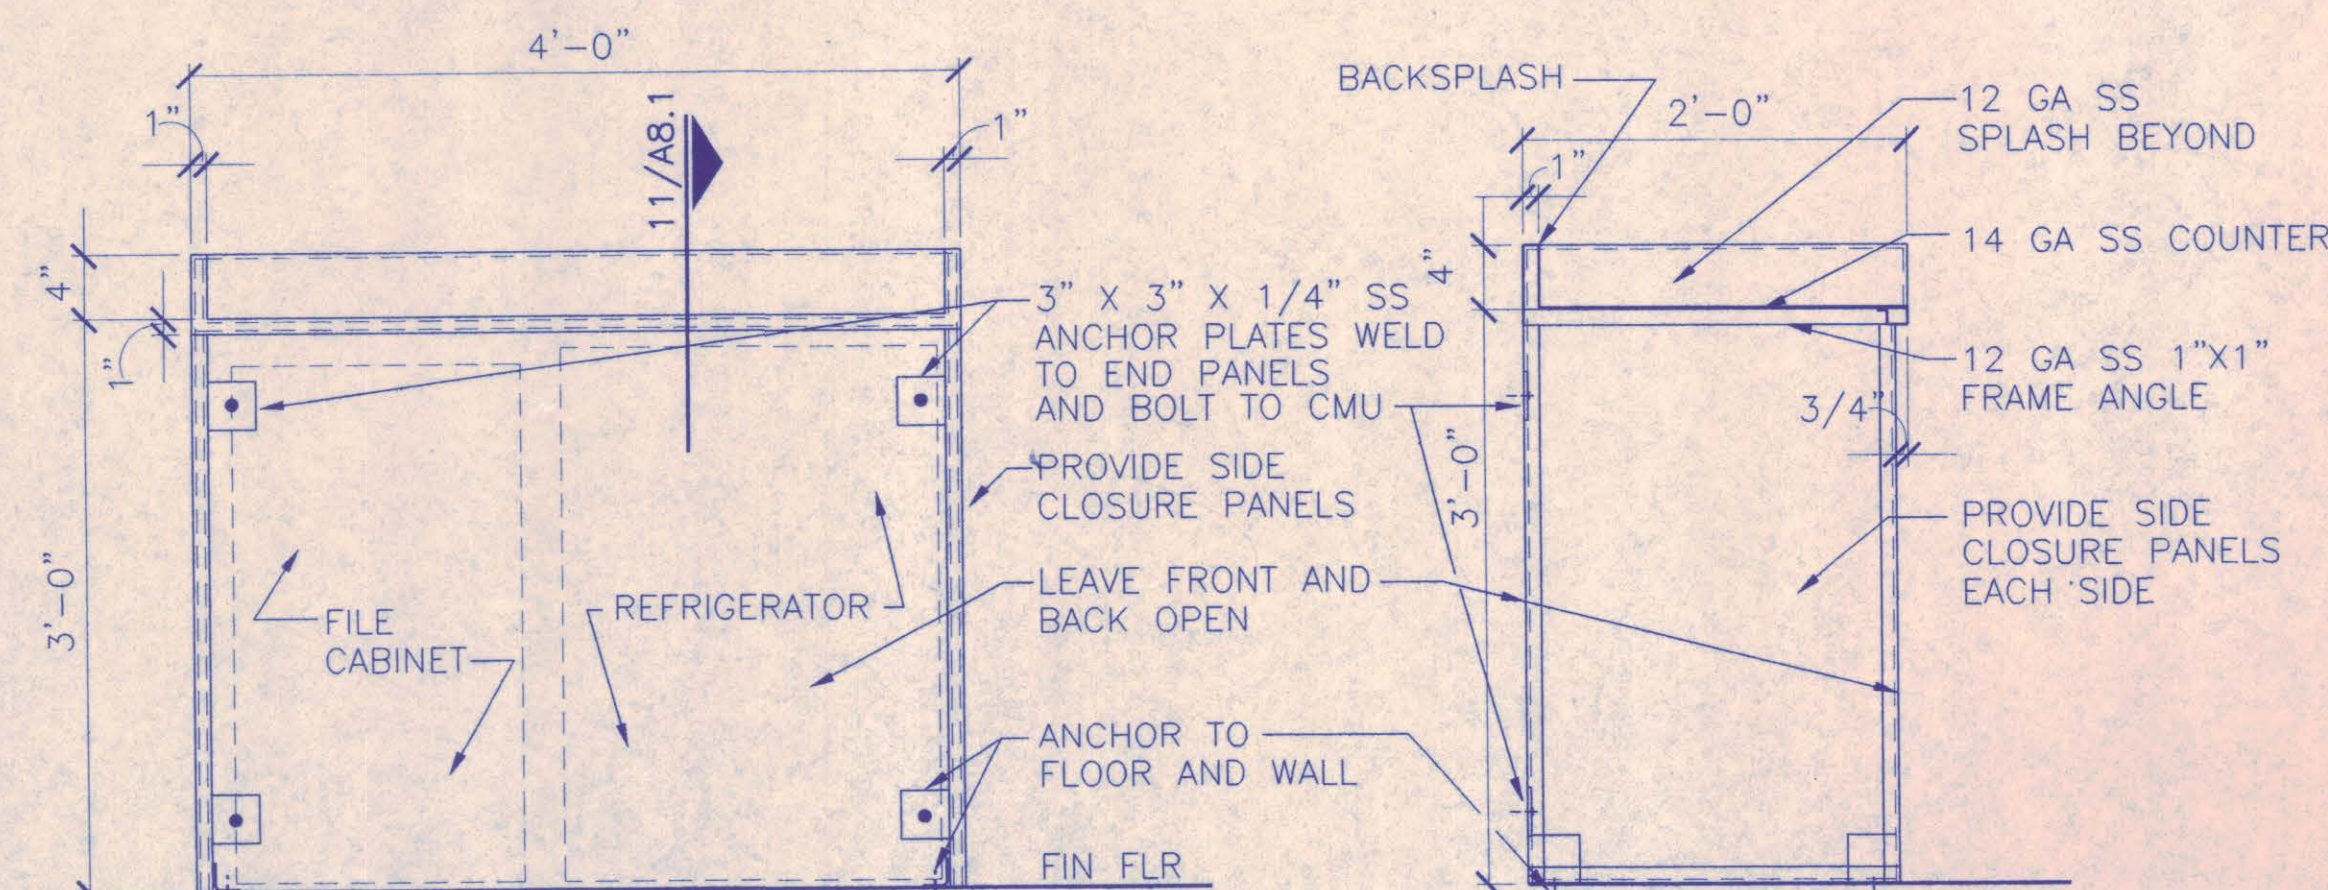


10 FRONT
1"=1'-0" TAATAEQ2

11 SECTION
1"=1'-0" TAATAEQ2


AT-A8.1

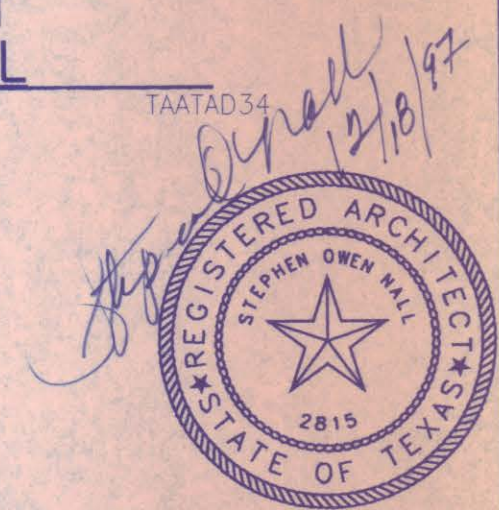


NO.	REVISION	BY	DATE
NORTH TEXAS TOLLWAY AUTHORITY			
ADDISON AIRPORT TUNNEL			
BARRIER TOLL PLAZA			
TUNNEL PLAZA			
BOOTH INTERIOR			
ELEVATIONS AND DETAILS			
ACQUIRE Corporation 22700 PARK CENTRAL DRIVE 10 TH FLOOR DALLAS TEXAS 75241 TEL: (972) 798-1608		SECTION XIII	
CHECKED <i>[Signature]</i>	DATE 12/18/97	DESIGNED MM	DATE 8/15/96
CHECKED <i>[Signature]</i>	DATE 12/18/97	SCALE AS SHOWN	
CONTRACT NO. DNT-290	SHEET 30	OF 53	

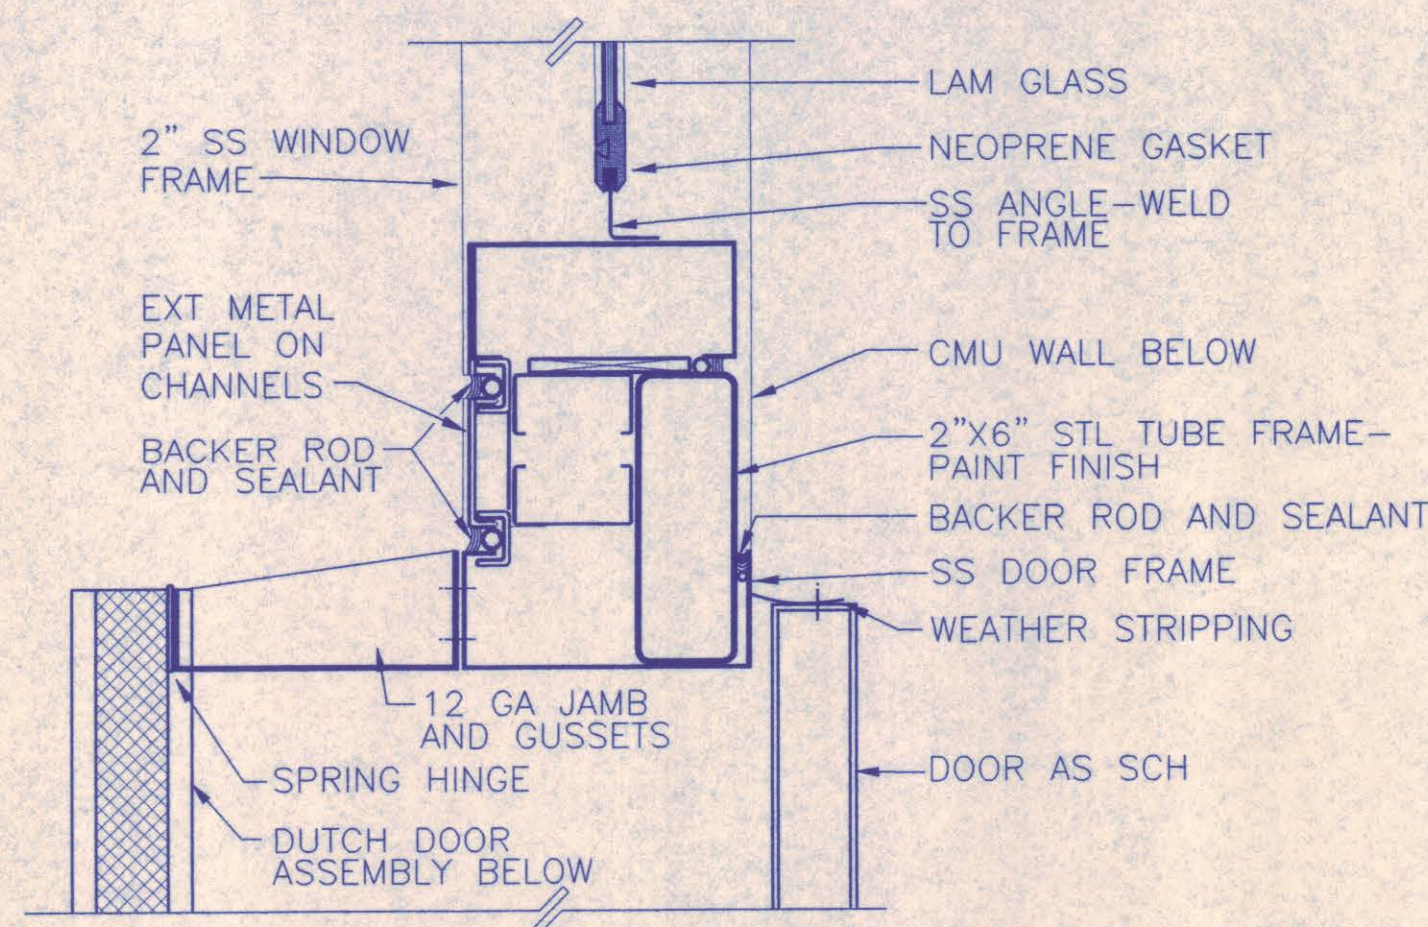


9 SLIDING DOOR JAMB
3'-1'-0" TAATAD40

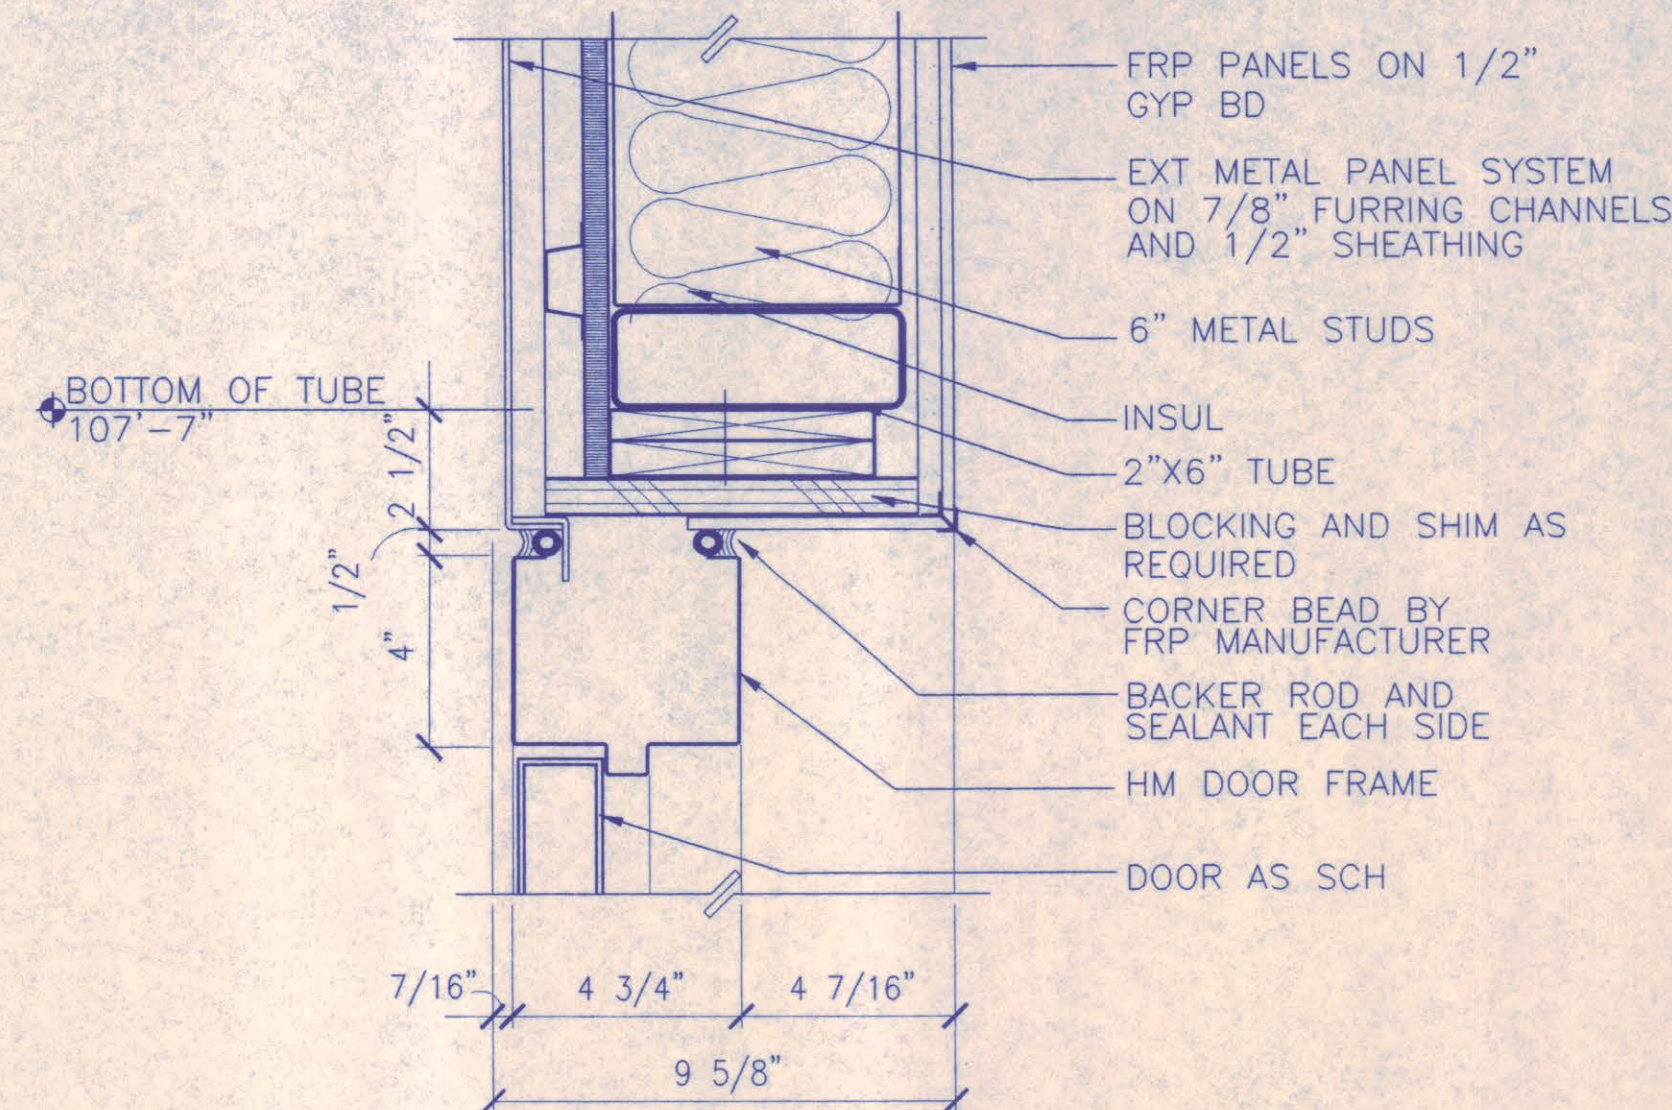


6 DOOR HEAD
3'-1'-0" TAATAD26

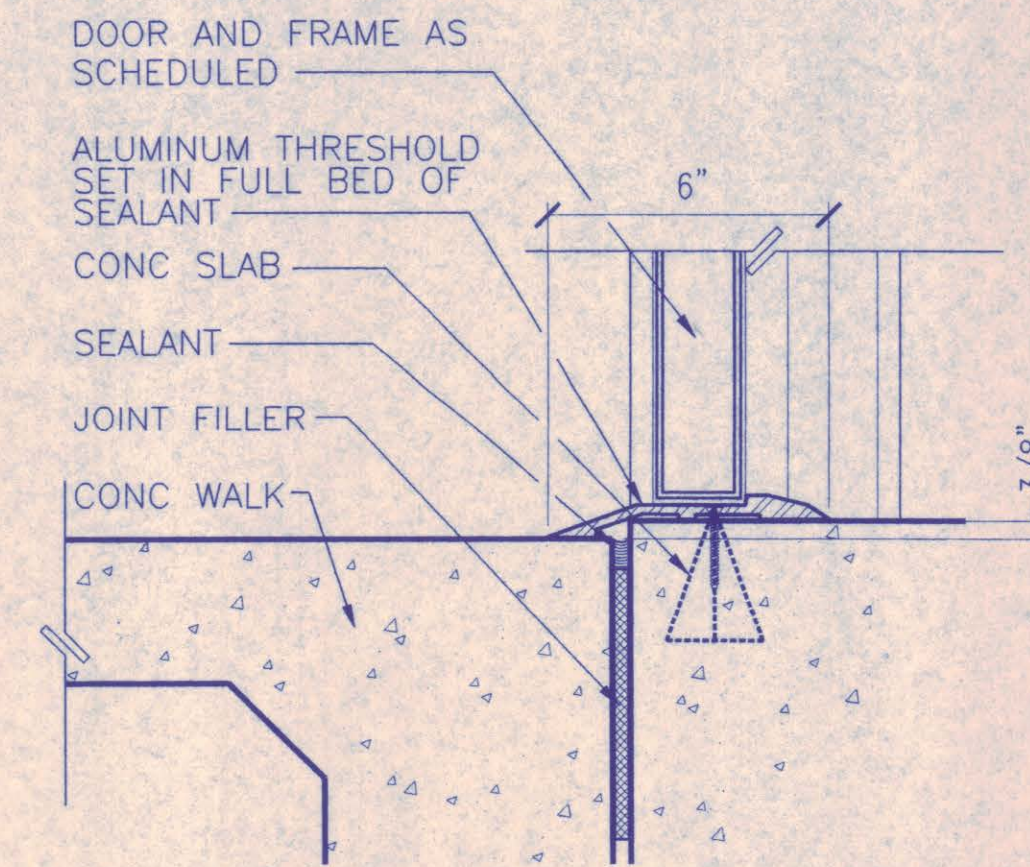


3 DOOR SILL
3'-1'-0" TAATAD23

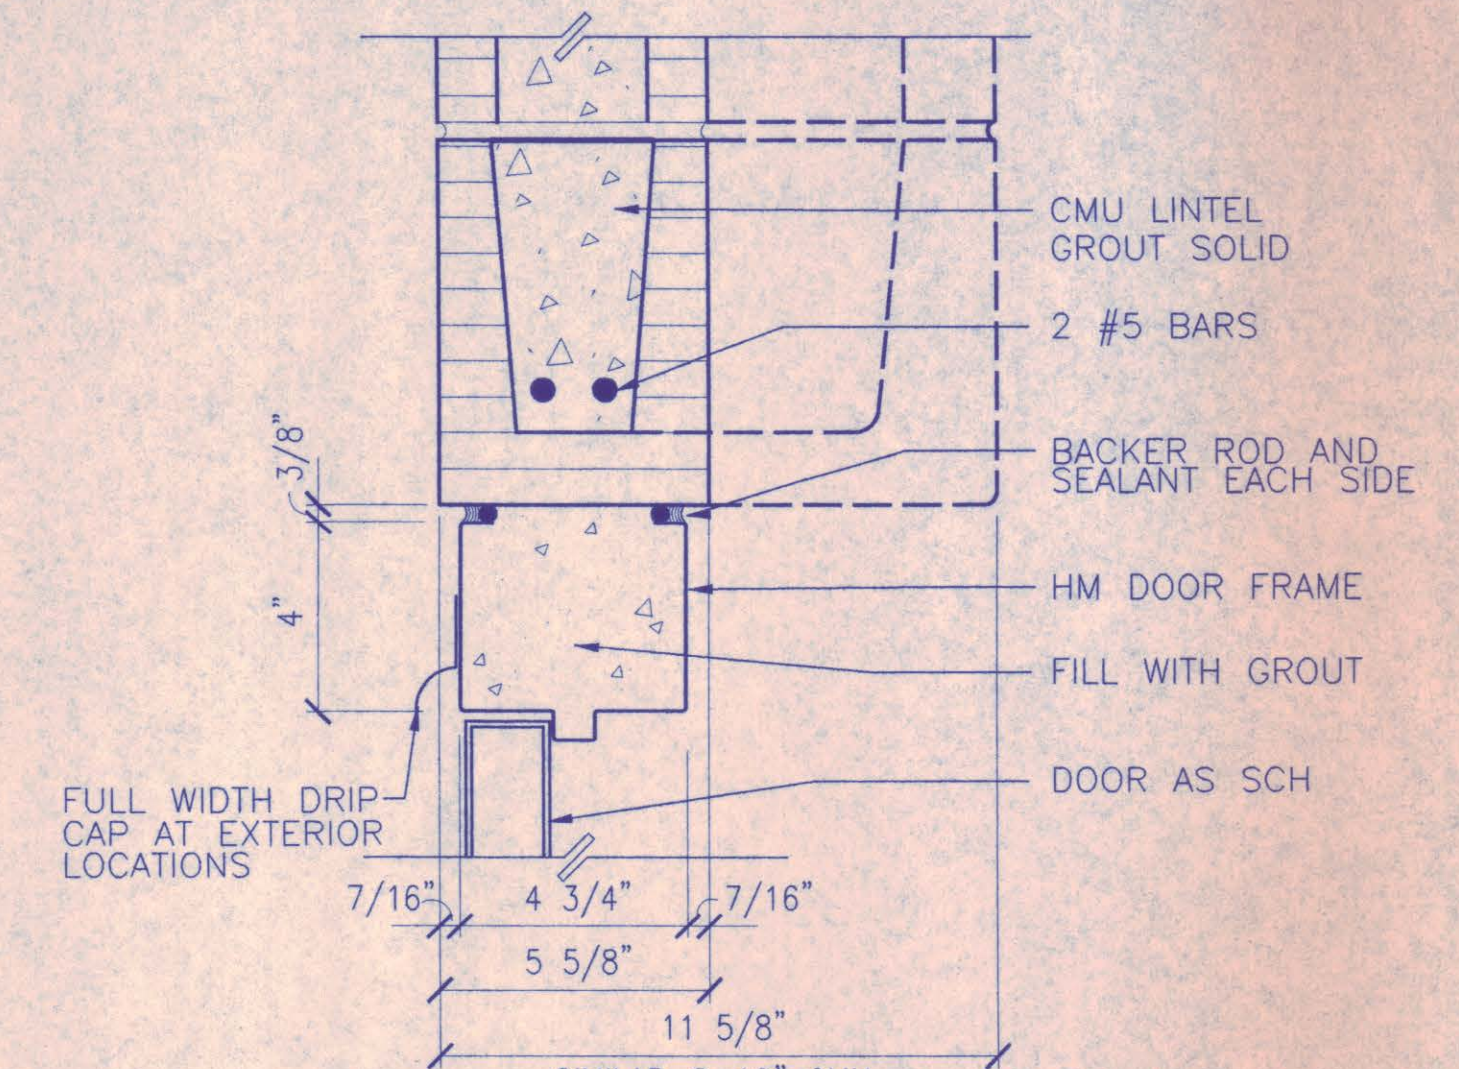


1 DOOR HEAD
3'-1'-0" TAATAD21

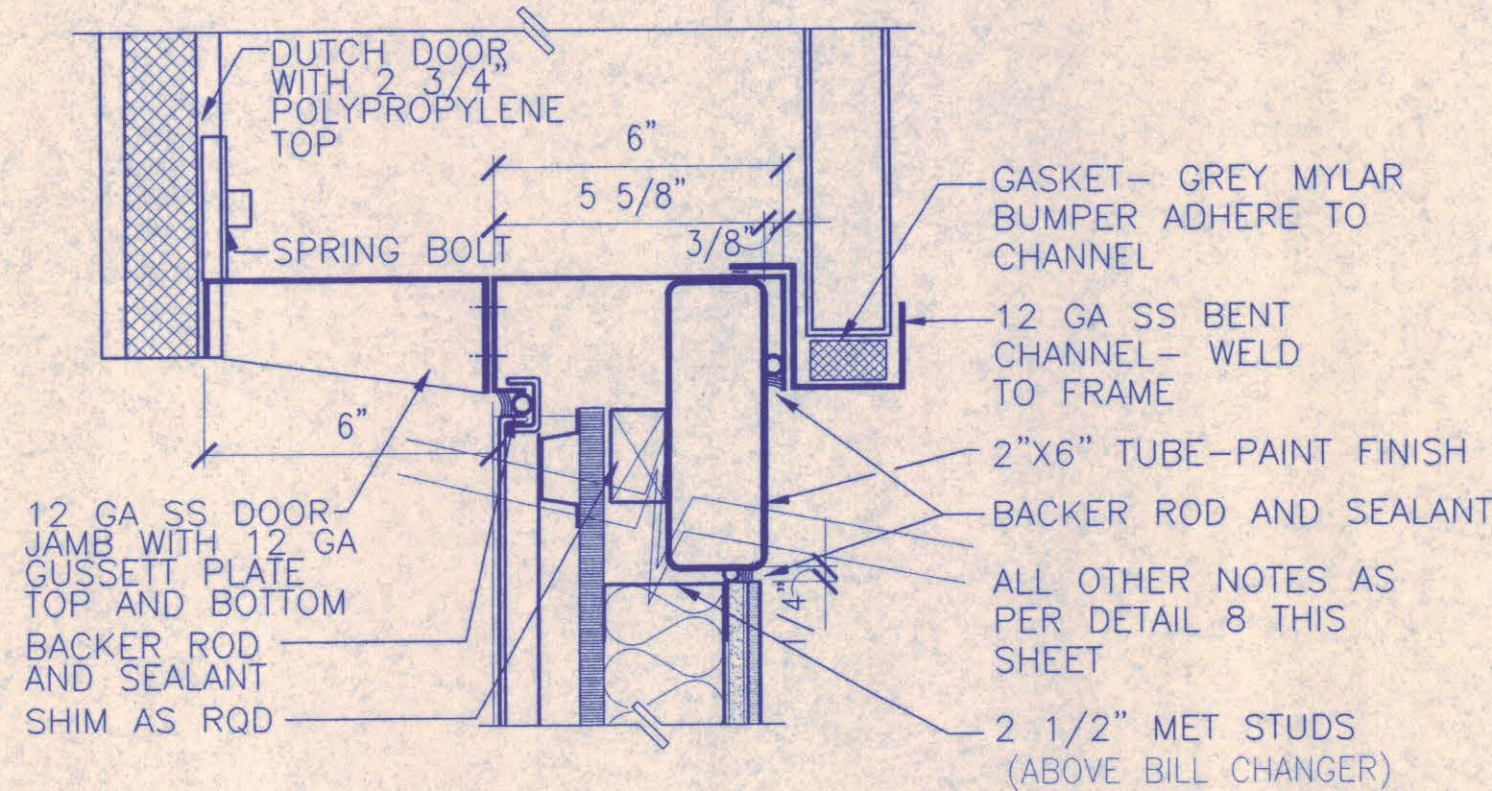


10 SLIDING DOOR JAMB
3'-1'-0" TAATAD29

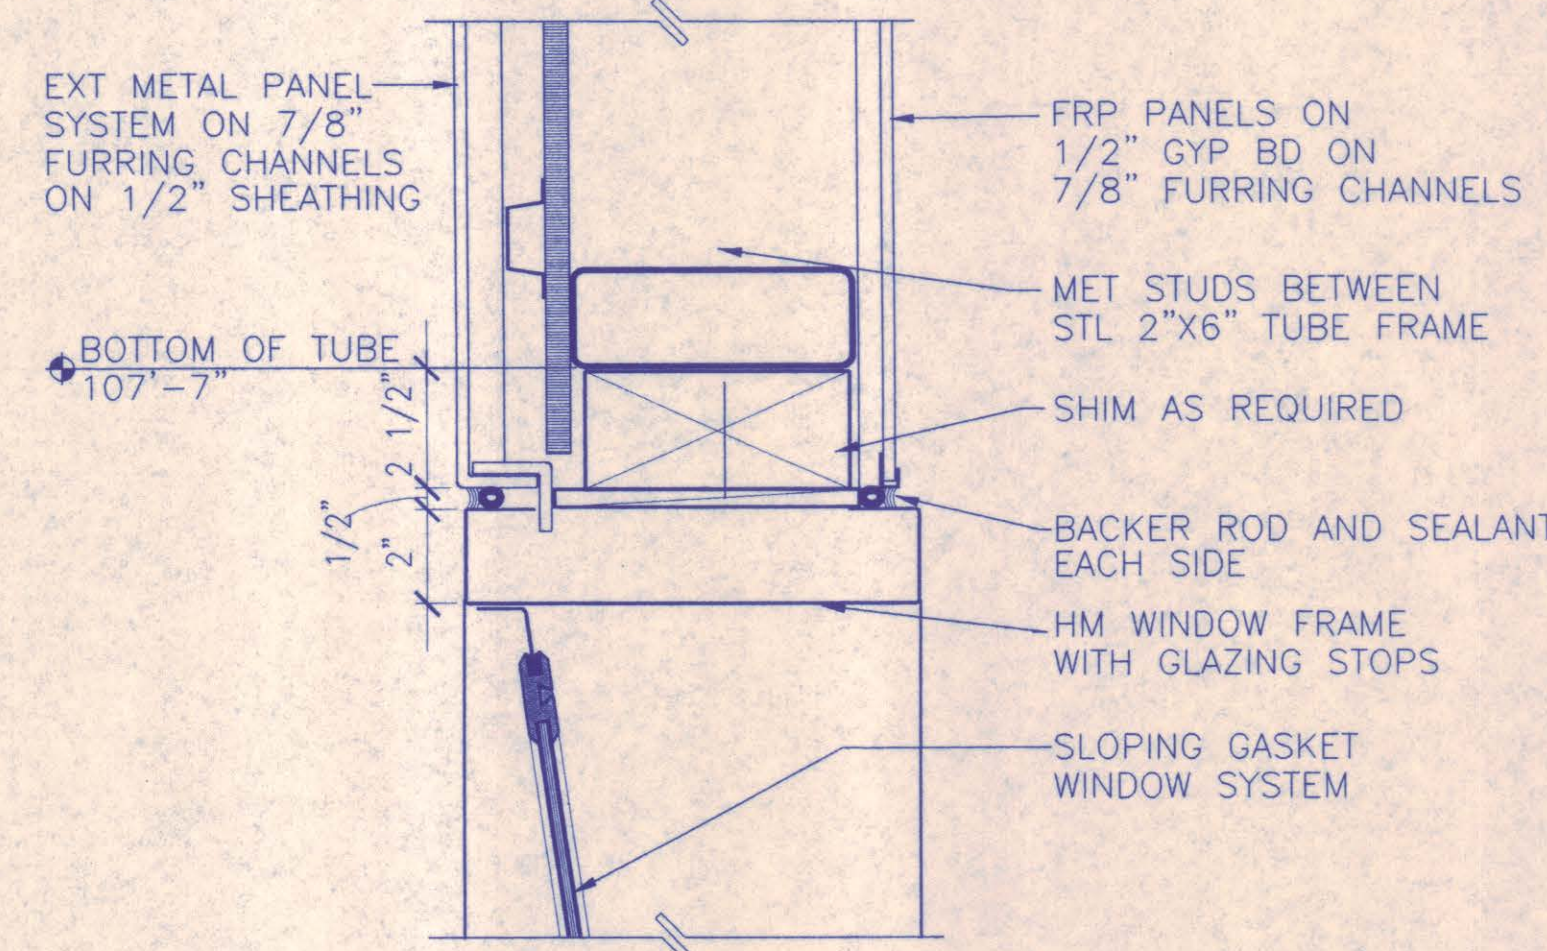


7 WINDOW HEAD
3'-1'-0" TAATAD48

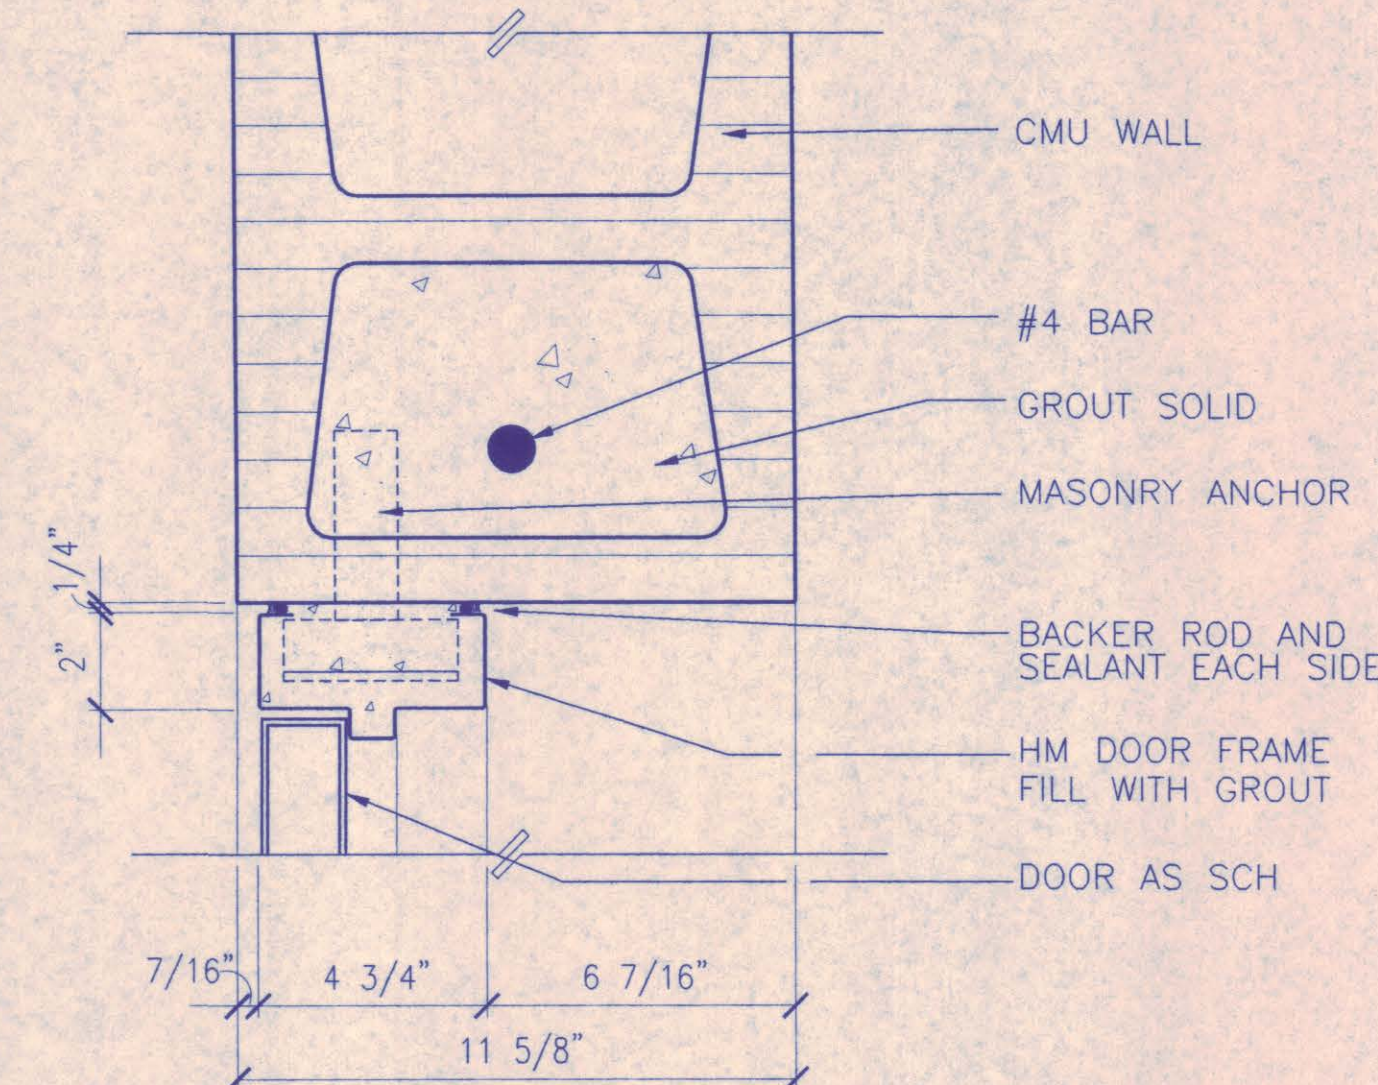


4 DOOR JAMB
3'-1'-0" TAATAD25

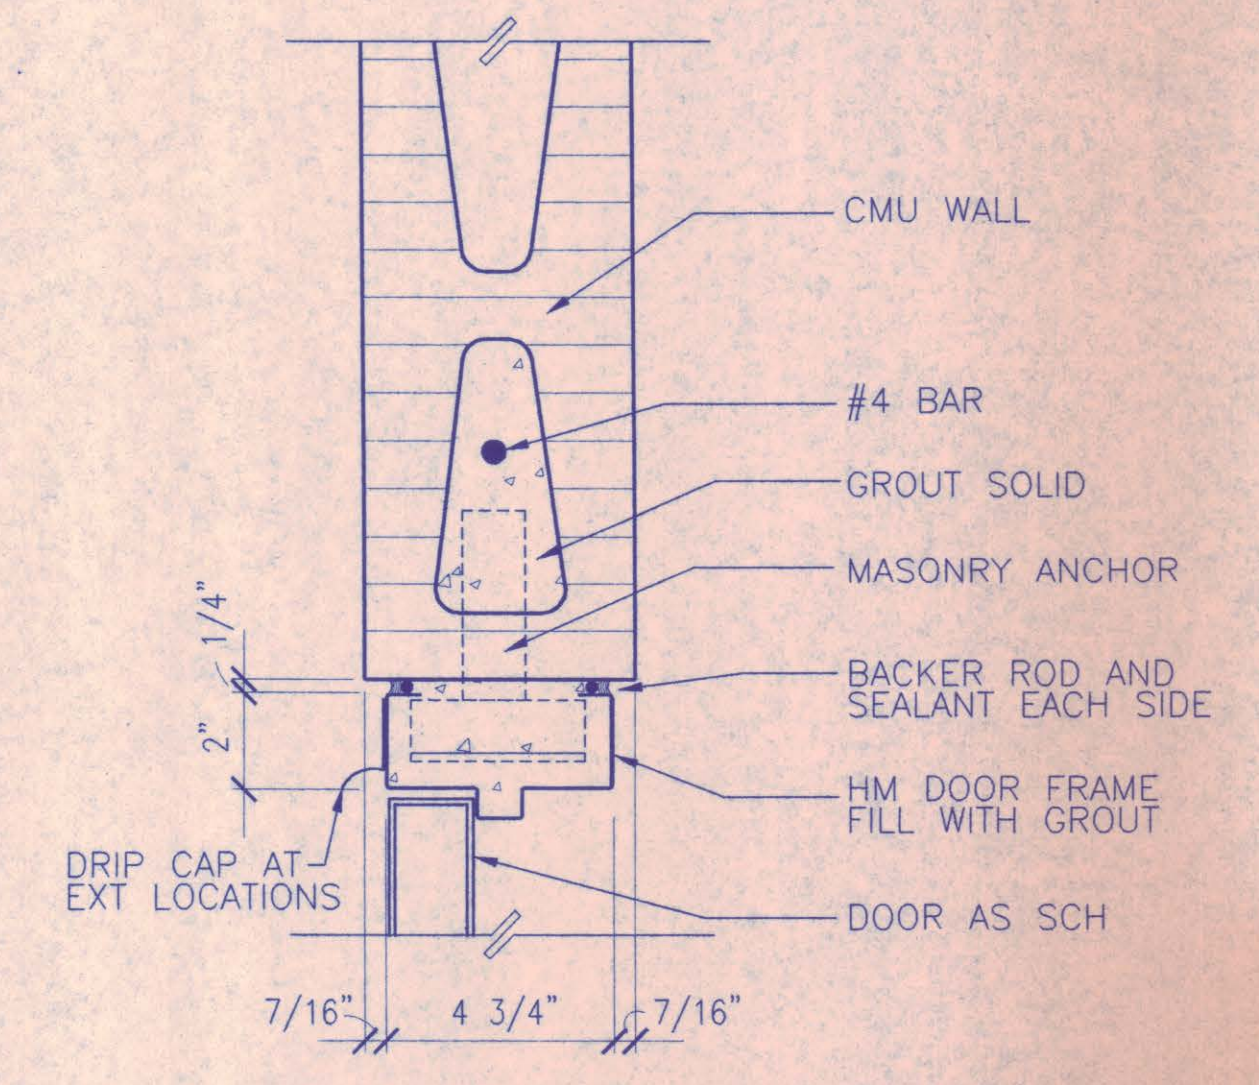


2 DOOR JAMB
3'-1'-0" TAATAD22

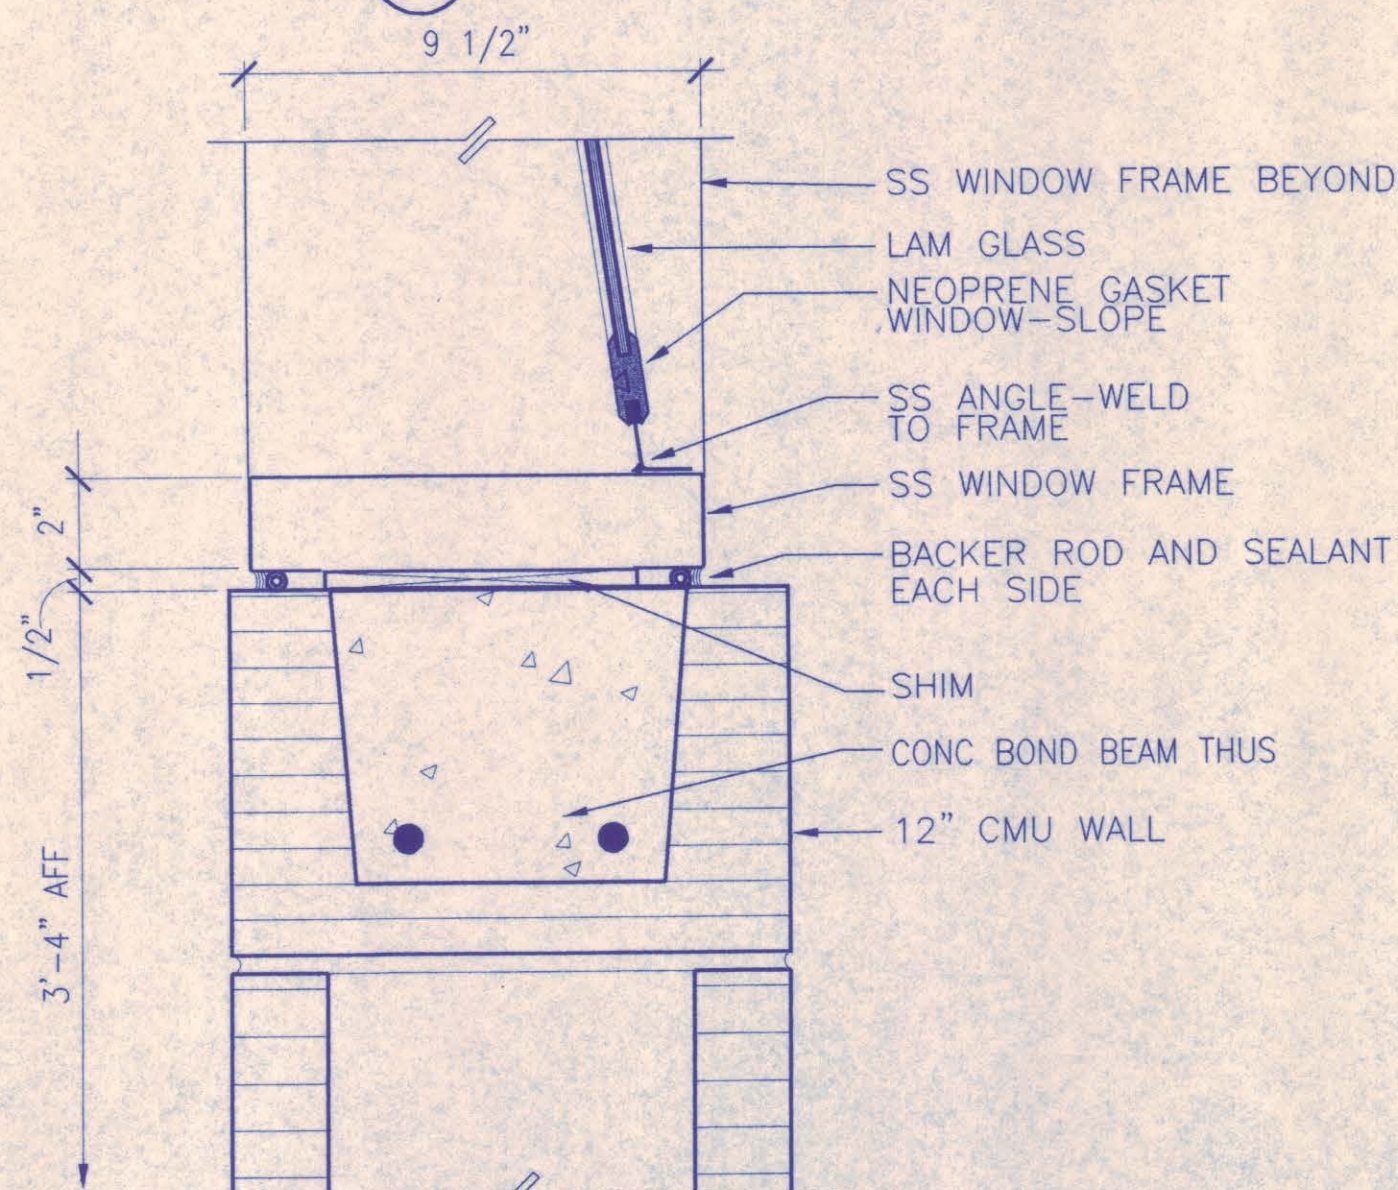


11 WINDOW SILL
3'-1'-0" TAATAD41

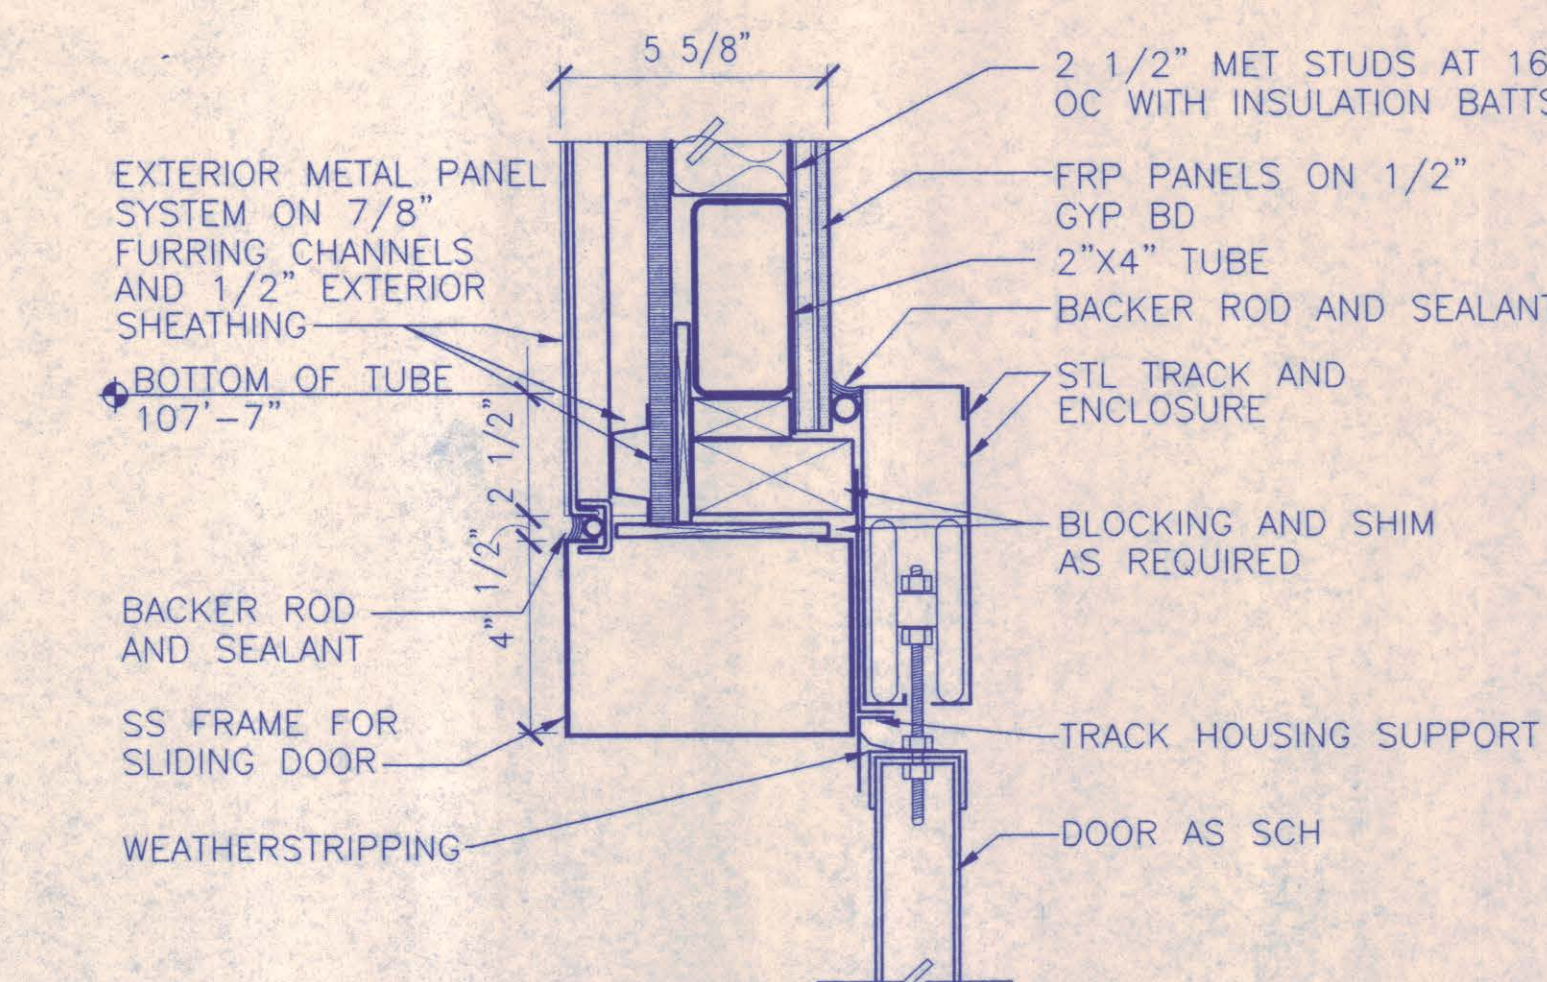

8 DOOR HEAD
3'-1'-0" TAATAD28

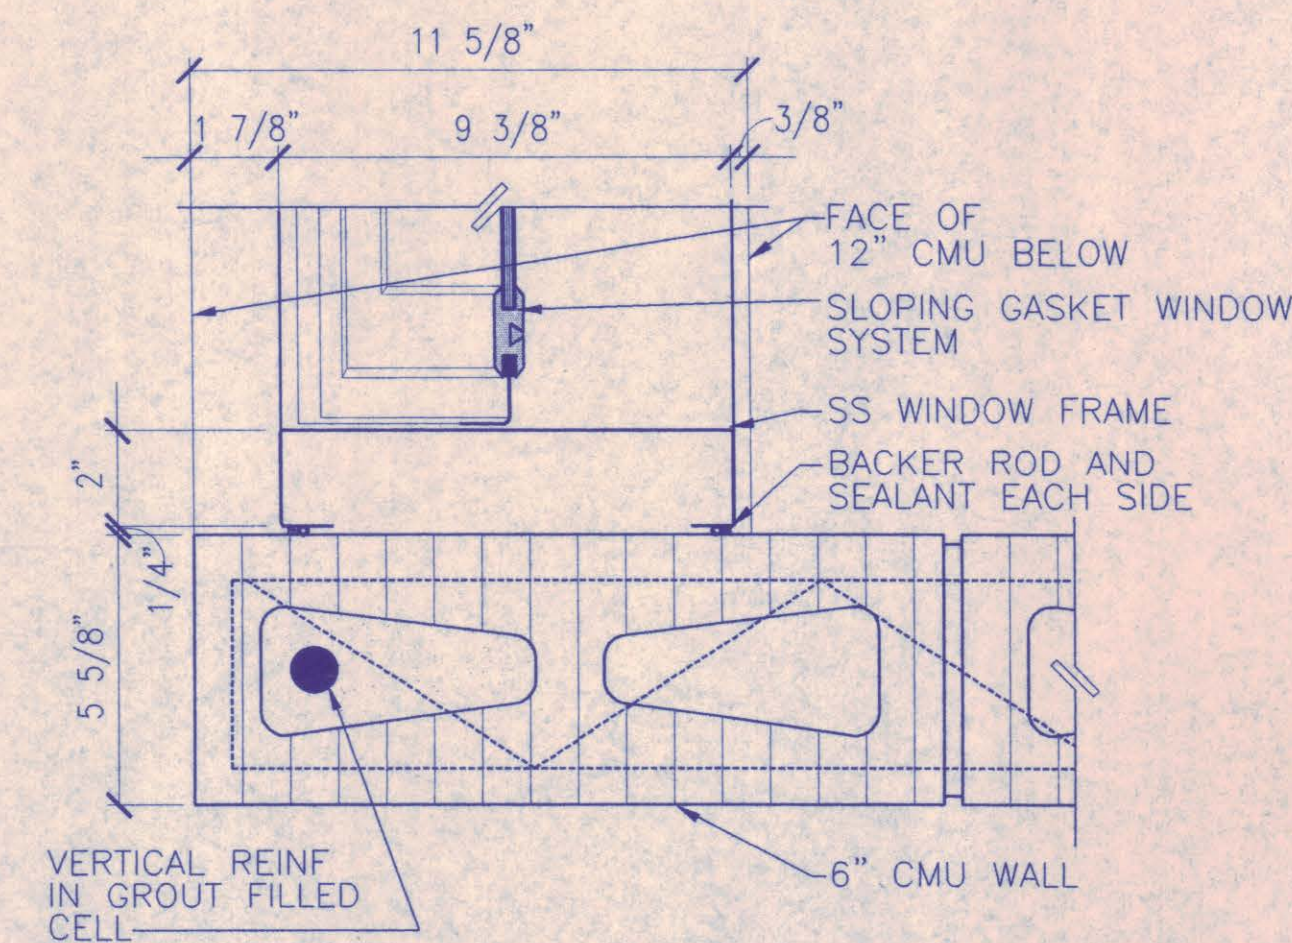


5 WINDOW JAMB
3'-1'-0" TAATAD50

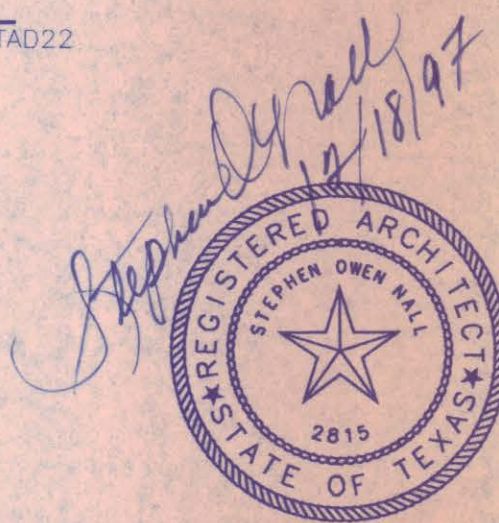


NO.	REVISION	BY	DATE
NORTH TEXAS TOLLWAY AUTHORITY ADDISON AIRPORT TUNNEL BARRIER TOLL PLAZA			
INTERIOR DETAILS			
AGUIRRE Corporation 3200 PARK CENTRAL DRIVE 15 TH FLOOR DALLAS TEXAS 75201 TEL: 972 788-1808			SECTION XIII
CHECKED <i>[Signature]</i>	DATE 12/18/97	DESIGNED MM	DATE 8/15/96
CHECKED <i>[Signature]</i>	DATE 12/18/97	SCALE AS SHOWN	
CONTRACT NO. DNT-290		SHEET 31 OF 53	


AT-A8.2

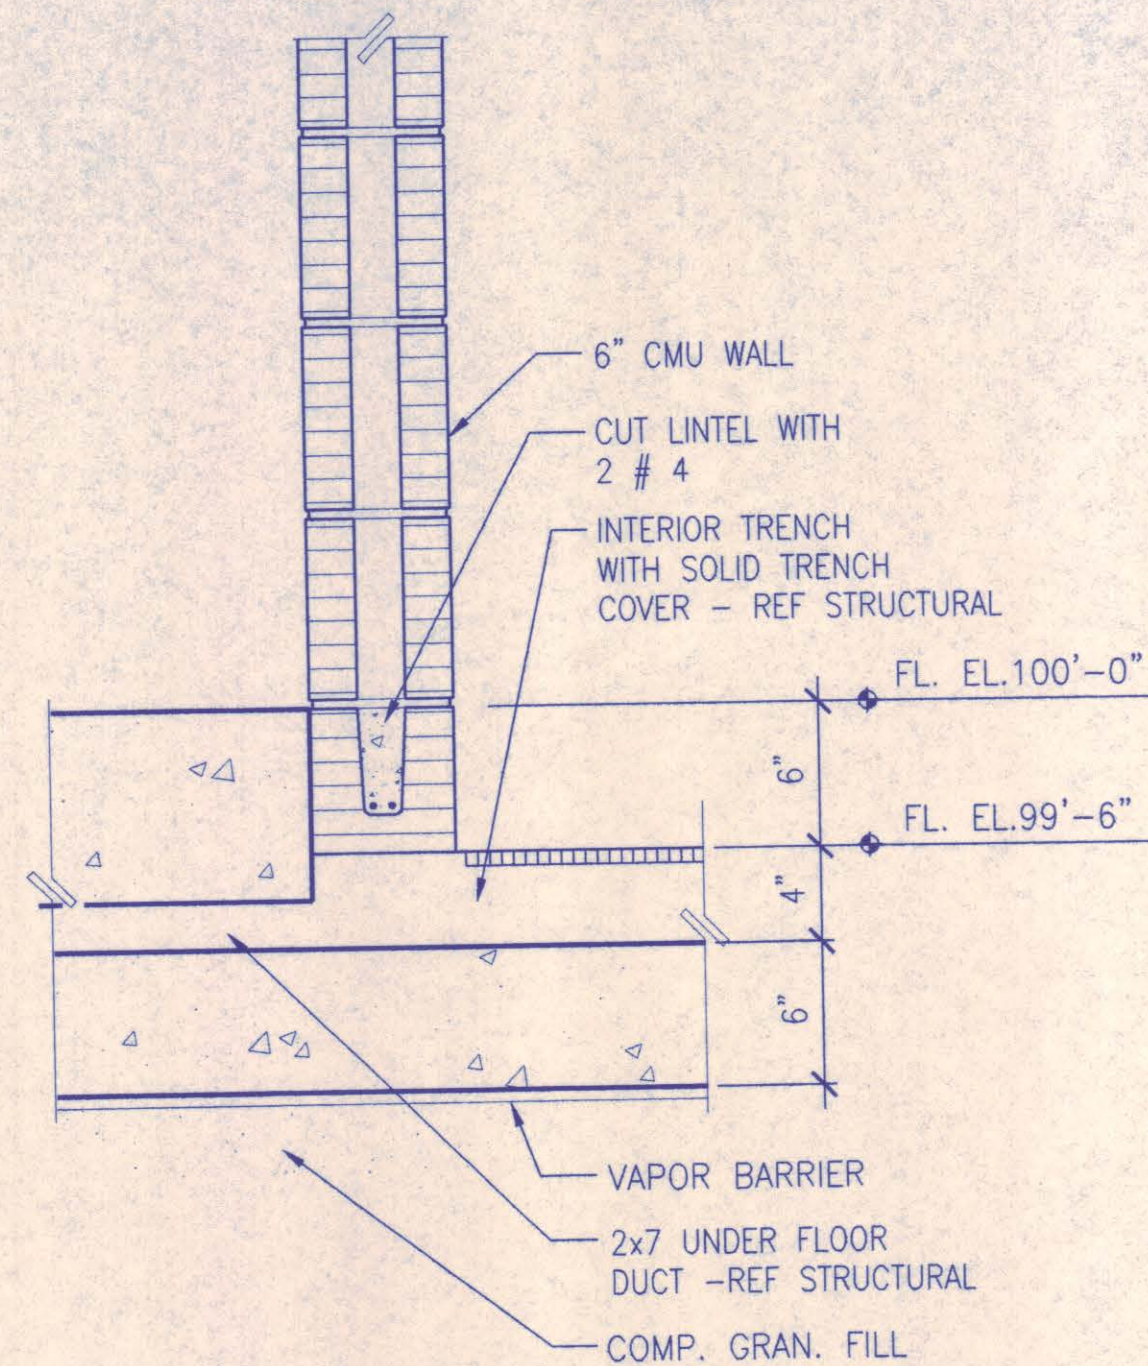


7 TRENCH TRANSITION
1 1/2"=1'-0" TAATAD68

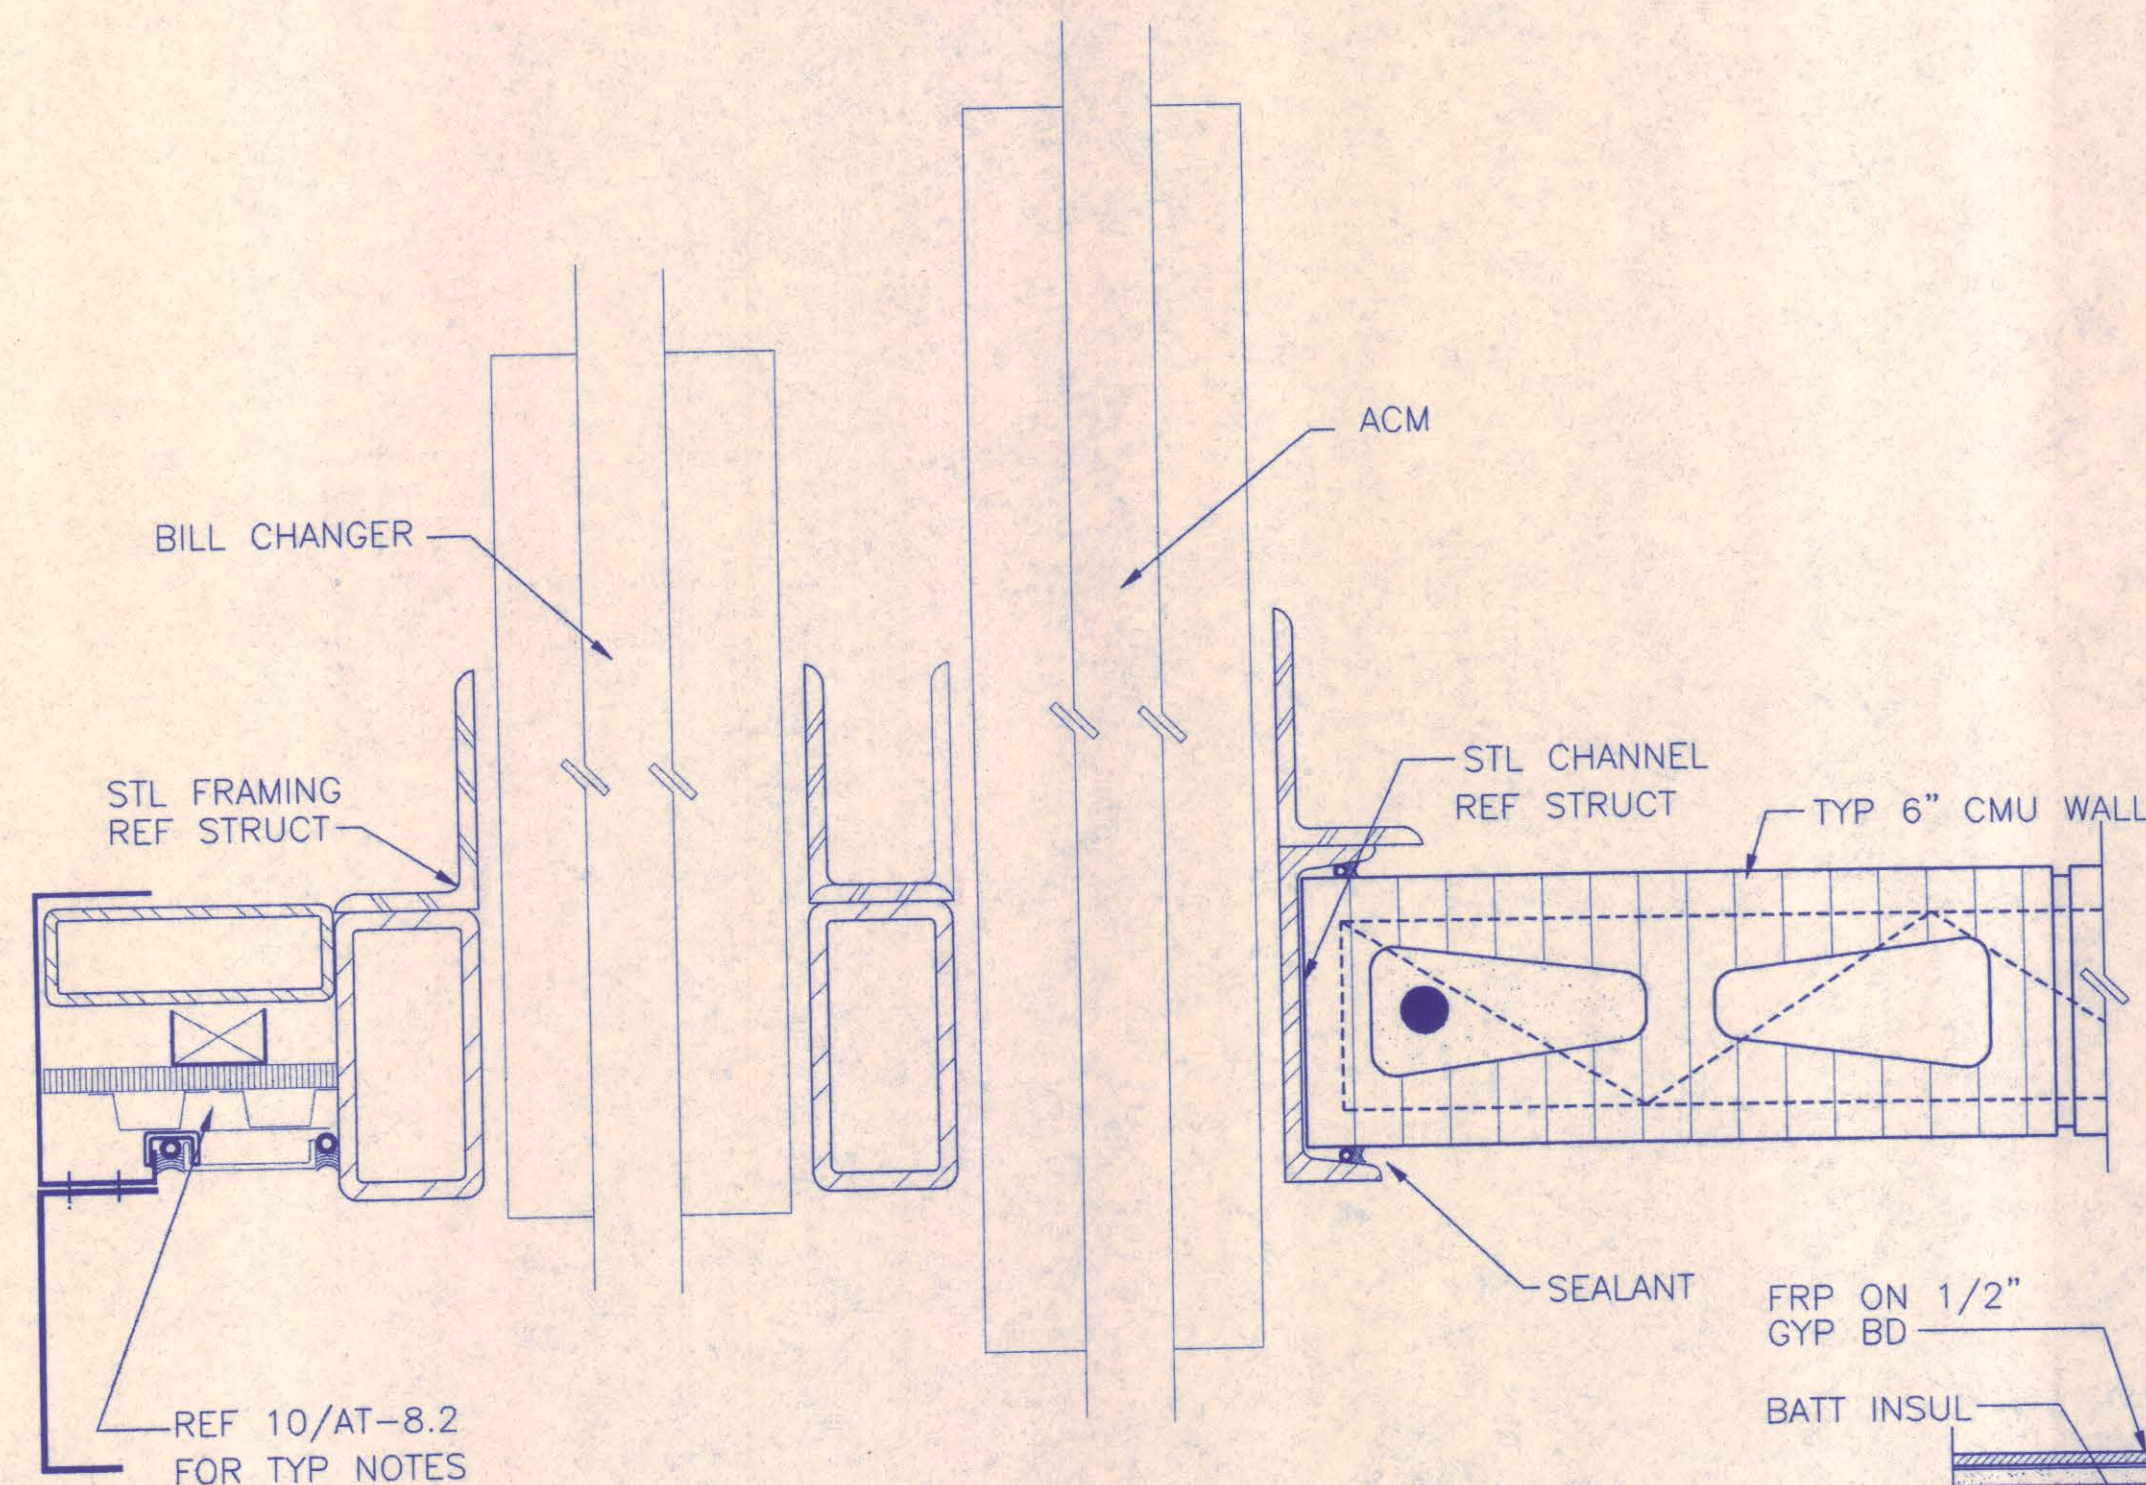

8 DTL AT ACM / BILL CHANGER
3"=1'-0" TAATAD61

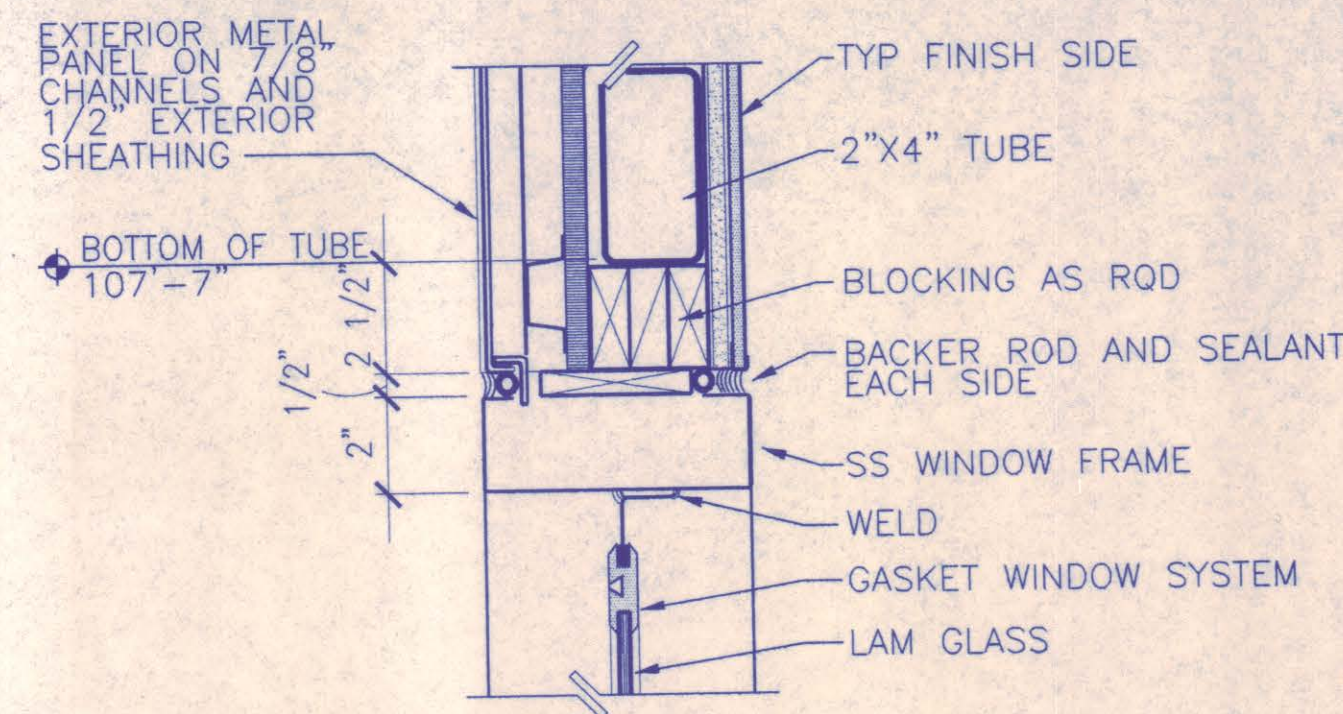


4 HEAD AT SIDE WINDOWS
3"=1'-0" TAATAD53

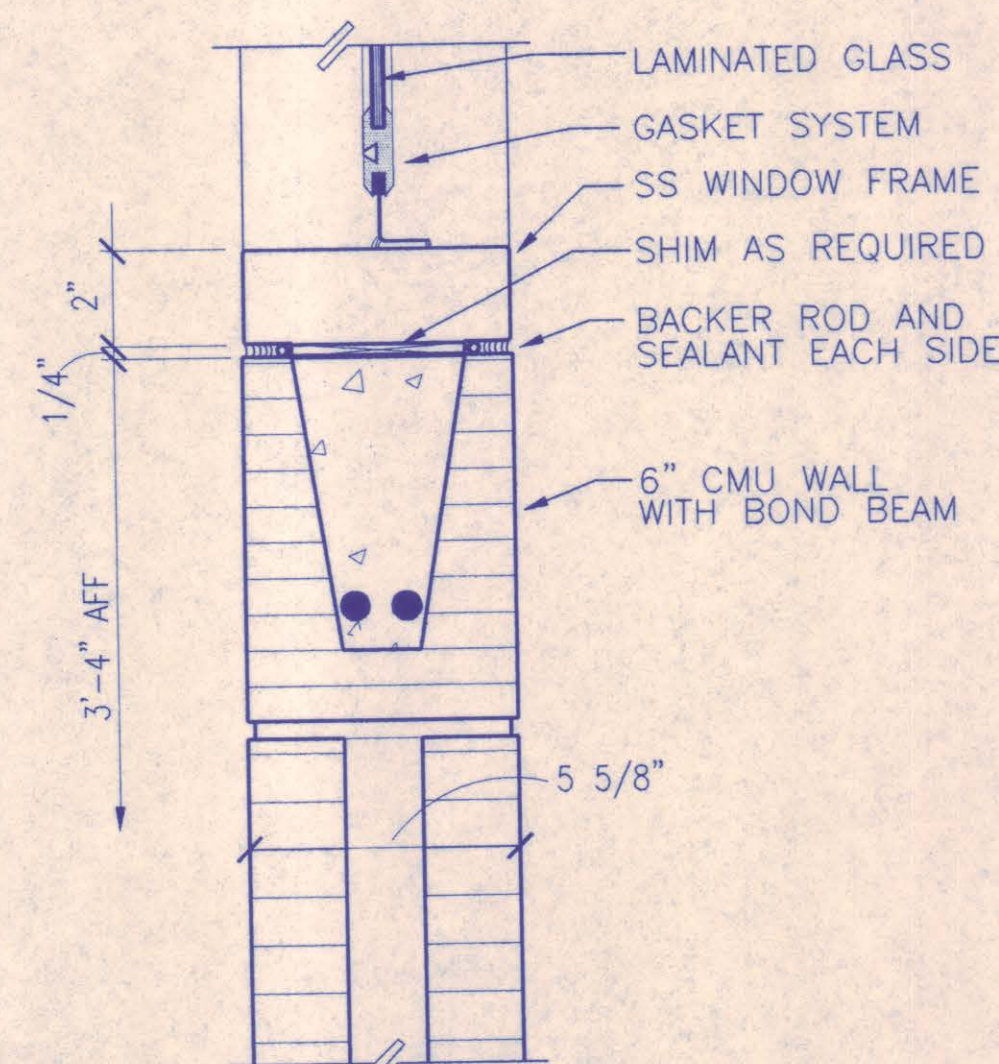


5 SILL AT SIDE WINDOWS
3"=1'-0" TAATAD52


6 DETAIL THRU ACM
3"=1'-0" TAATAD51

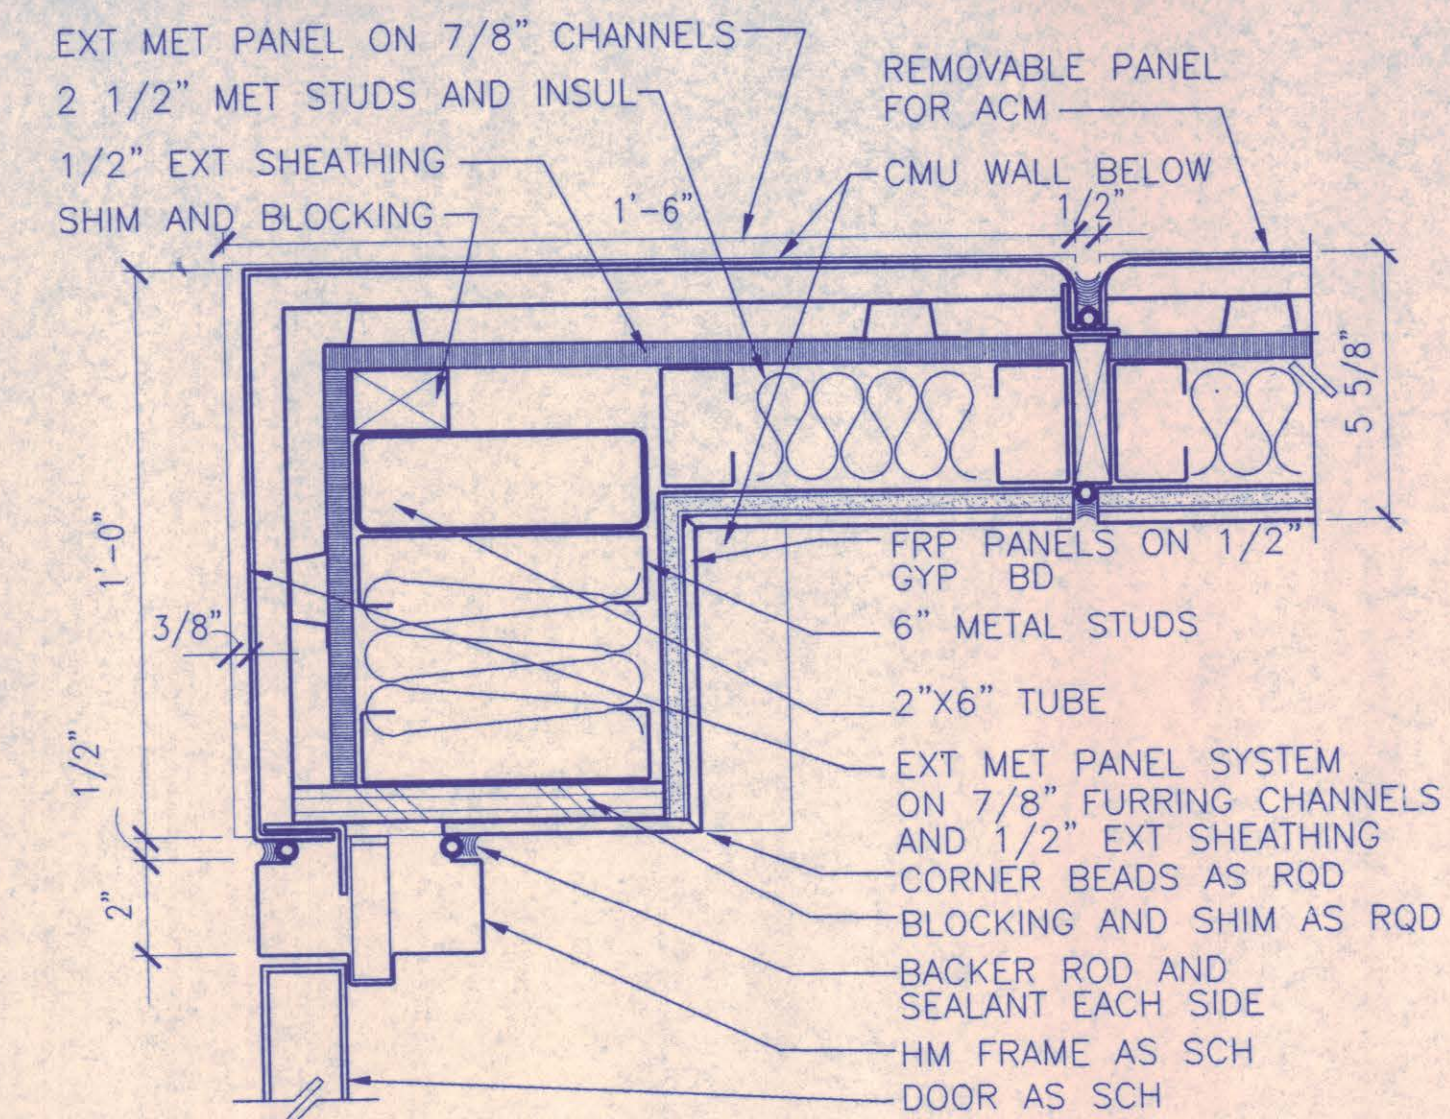

1 DOOR JAMB
3"=1'-0" TAATAD27

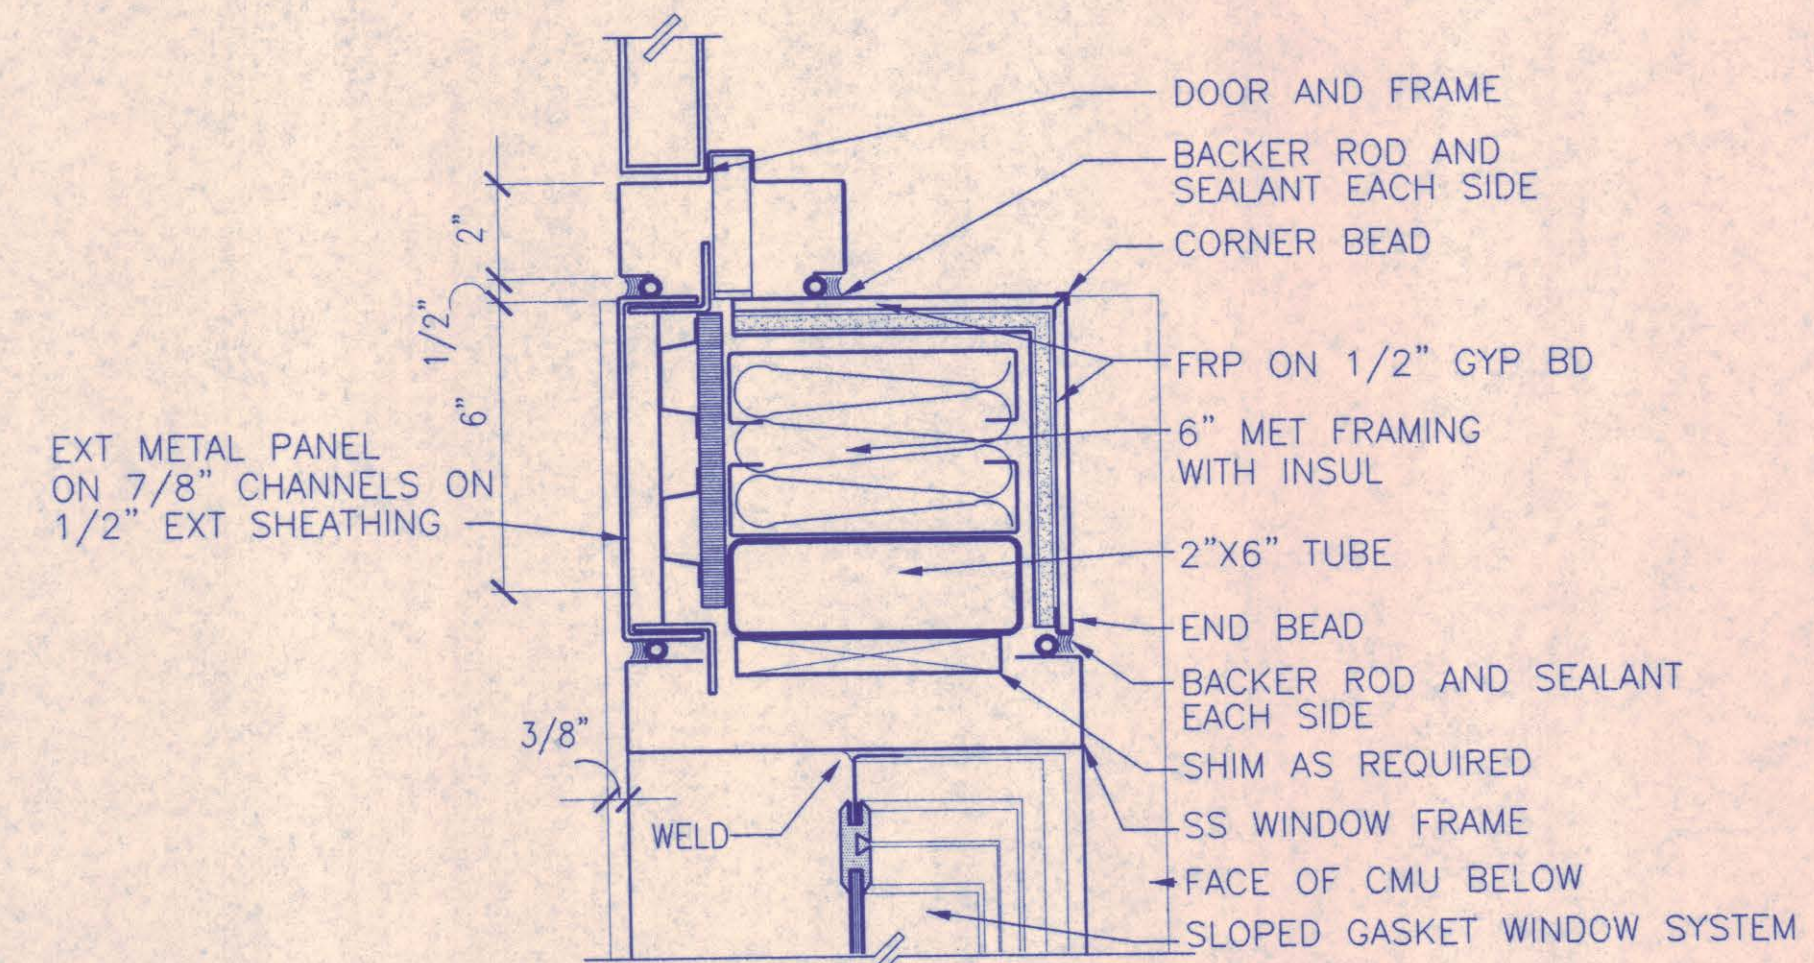

2 DOOR JAMB
3"=1'-0" TAATAD49

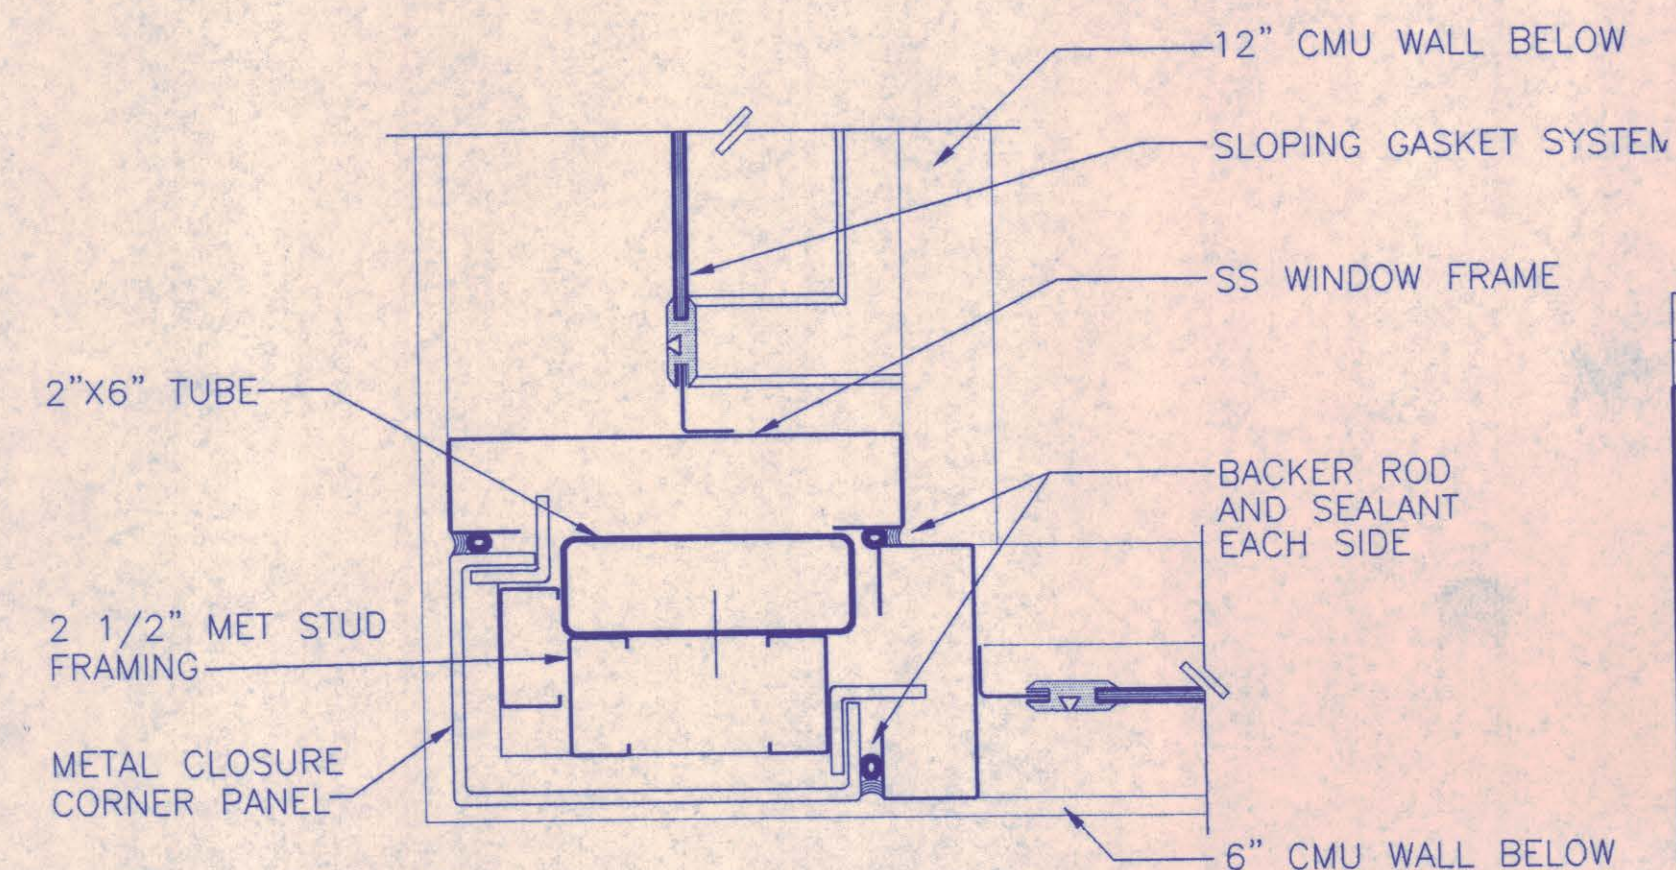

3 WINDOW JAMB
3"=1'-0" TAATAD42

AT-A8.3


NO.	REVISION	BY	DATE
NORTH TEXAS TOLLWAY AUTHORITY ADDISON AIRPORT TUNNEL BARRIER TOLL PLAZA			
INTERIOR DETAILS			
AGUIRRE Corporation 18700 PARK CENTRAL DRIVE 18 TH FLOOR DALLAS TEXAS 75241 TEL. 972 758-9005			SECTION XIII
CHECKED <i>[Signature]</i>	DATE 12/18/97	DESIGNED MM	DATE 8/15/96
CHECKED <i>[Signature]</i>	DATE 12/18/97	SCALE AS SHOWN	
CONTRACT NO. DNT-290		SHEET 32 OF 53	

V.I.V.I.D. SCHEDULE

		SIZE			REMARKS	PROVIDED BY V.I.V.I.D. CONTRACT	PROVIDED BY G.C.
		W	D	H			
1.	CRT STAND	14"	12 1/2"	4 3/4"	SETS LOOSE ON COUNTERTOP	X	
2.	MONITOR	14"	15"	15"	SETS LOOSE ON COUNTERTOP	X	
3.	KEYBOARD	13"	7 1/2"	2"	SETS LOOSE ON COUNTERTOP	X	
4.	RECEIPT PRINTER	6 1/4"	16 1/2"	9 1/4"	SETS LOOSE ON COUNTERTOP	X	
5.	TELEPHONE	8 1/2"	7 1/2"	12"	MOUNTED ON COUNTERTOP	X	
6.	EMERGENCY FOOT ALARM	18"	4 3/4"	4 3/4"	SETS LOOSE ON FLOOR	X	
7.	COIN VENDING MACHINE	22"	12"	27"	MOUNTED ON STEEL FRAME	X	
8.	CASH DROP BOX VAULT HOUSING	16 1/2"	16"	21"	BOLTED TO FLOOR	X	
9.	AUTOMATIC COIN MACHINE	26"	26"	56"	FRAME IN BOOTH WALL	X	
10.	CLOSED CIRCUIT TV MONITOR	15"	15"	15"	HUNG FROM STRUCTURE	X	
11.	EMERGENCY HAND ALARM	3"	1 1/8"	4"	MOUNTED ON WALL	X	
12.	FARE INDICATOR	15"	8"	6"	MOUNTED 46" AFF ON EXTERIOR WALL	X	
13.	IN LANE PROCESSOR	24"	16"	30"	MOUNTED ON WALL	X	
14.	AVI CONTROLLER	20"	11"	24"	MOUNTED ABOVE ILP	X	
15.	AUTOMATIC COIN MACHINE	26"	24"	57"	MOUNTED ON ISLAND	X	
16.	BILL CHANGER	12 1/4"	18"	38 5/8"	FRAME IN BOOTH WALL		X
17.	TREADLE	12"	84"	8"	SET IN PAVEMENT, COORDINATE W/CIVIL	X	
18.	LOOP DETECTORS	42"	108"	-	INSTALLED IN SAWCUT IN PAVEMENT	X	
19.	AVI READERS	28"	28"	28"	HUNG FROM STRUCTURE	X	
20.	TOLL COLLECTION LIGHT	10"	10"	48"	PEDESTAL MOUNTED	X	
21.	VIOLATION DETECTION CAMERA	8"	24"	8"	PEDESTAL MOUNTED MOUNTED ON WALL OR CEILING AS REQ. COORDINATE LOCATION WITH SECURITY.	X	
22.	SECURITY CAMERA	6"	18"	6"			X

GENERAL NOTES


- ALL LOCATIONS ARE APPROXIMATE. EQUIPMENT SHOWN FOR INFORMATIONAL PURPOSE.
- COORDINATE ALL EQUIPMENT WITH ELECTRICAL DRAWINGS FOR CONDUIT (POWER AND CONTROLS) LOCATIONS.
- V.I.V.I.D. - VIDIO INTEGRATED VOICE AND AND INTEGRATED DATA EQUIPMENT TO BE PROVIDED AND INSTALLED BY OTHERS, WITH EXCEPTION OF BILL CHANGER AND SECURITY CAMERAS REFER TO ITEMS 16 AND 22.

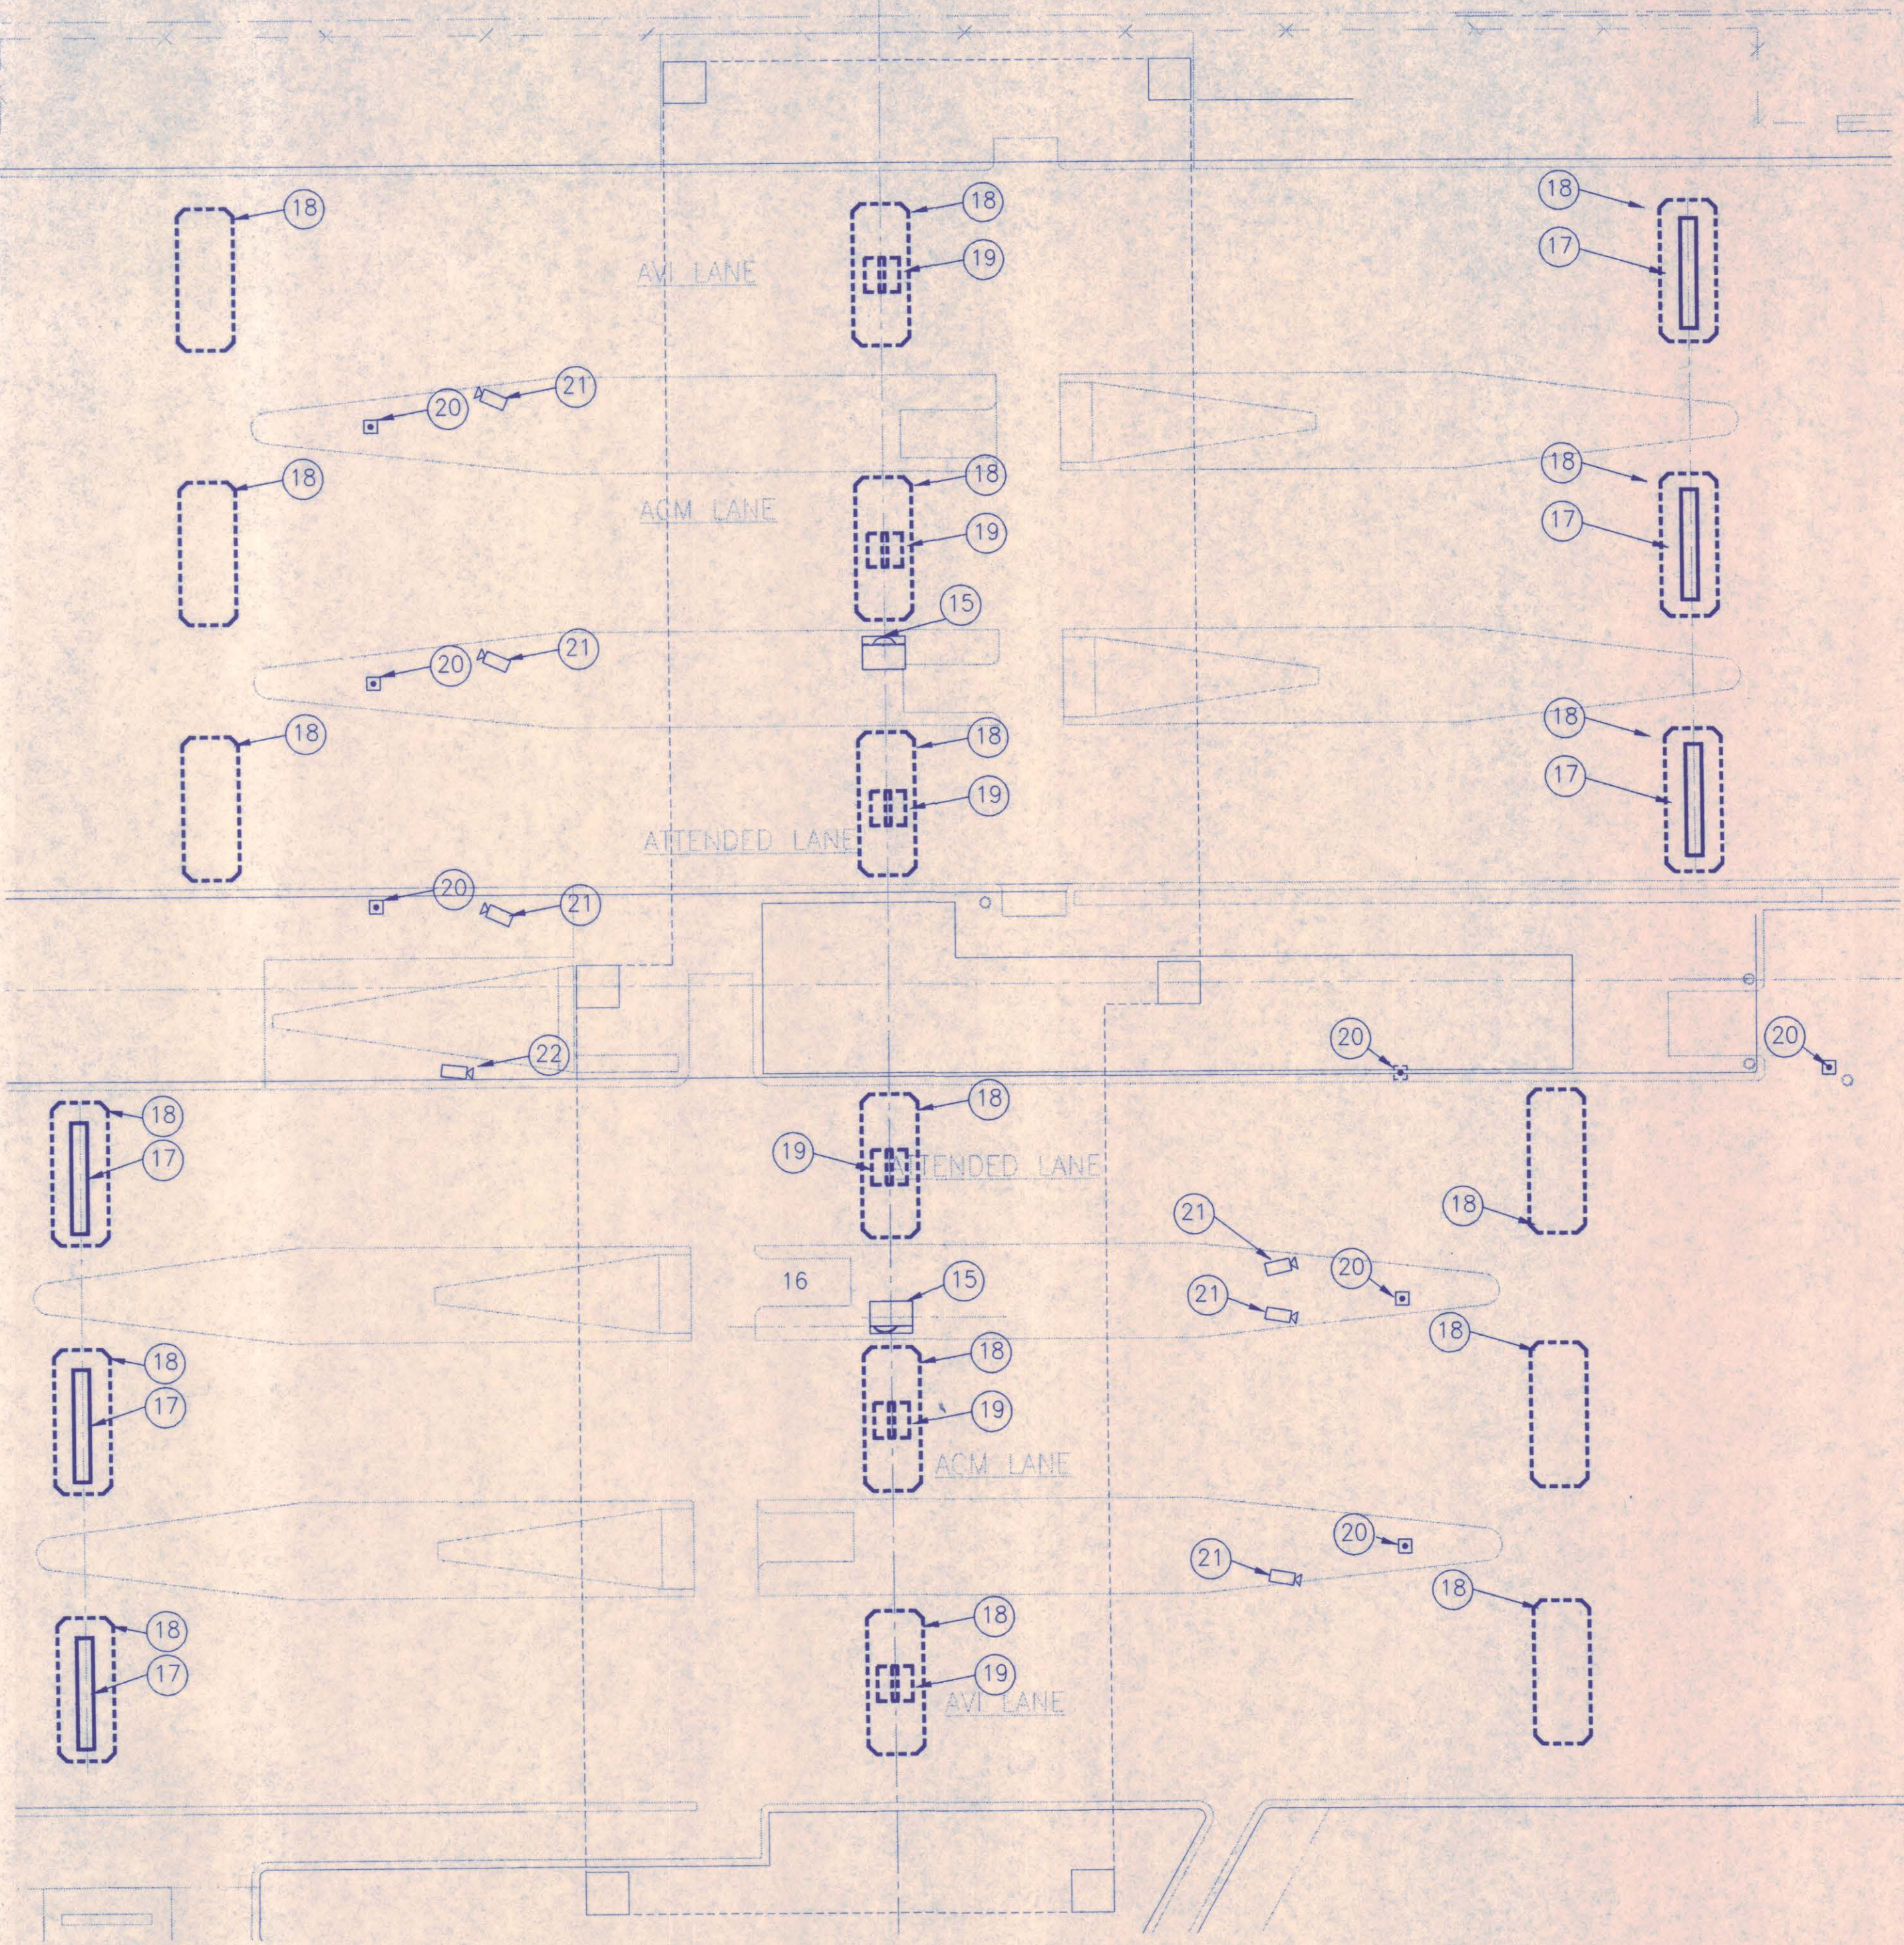


1 V.I.V.I.D. CANOPY PLAN
1/8"=1'-0" TAATAP1.DWG



N.I.C. - V.I.V.I.D. DRAWINGS
ARE FOR INFORMATION
PURPOSES ONLY

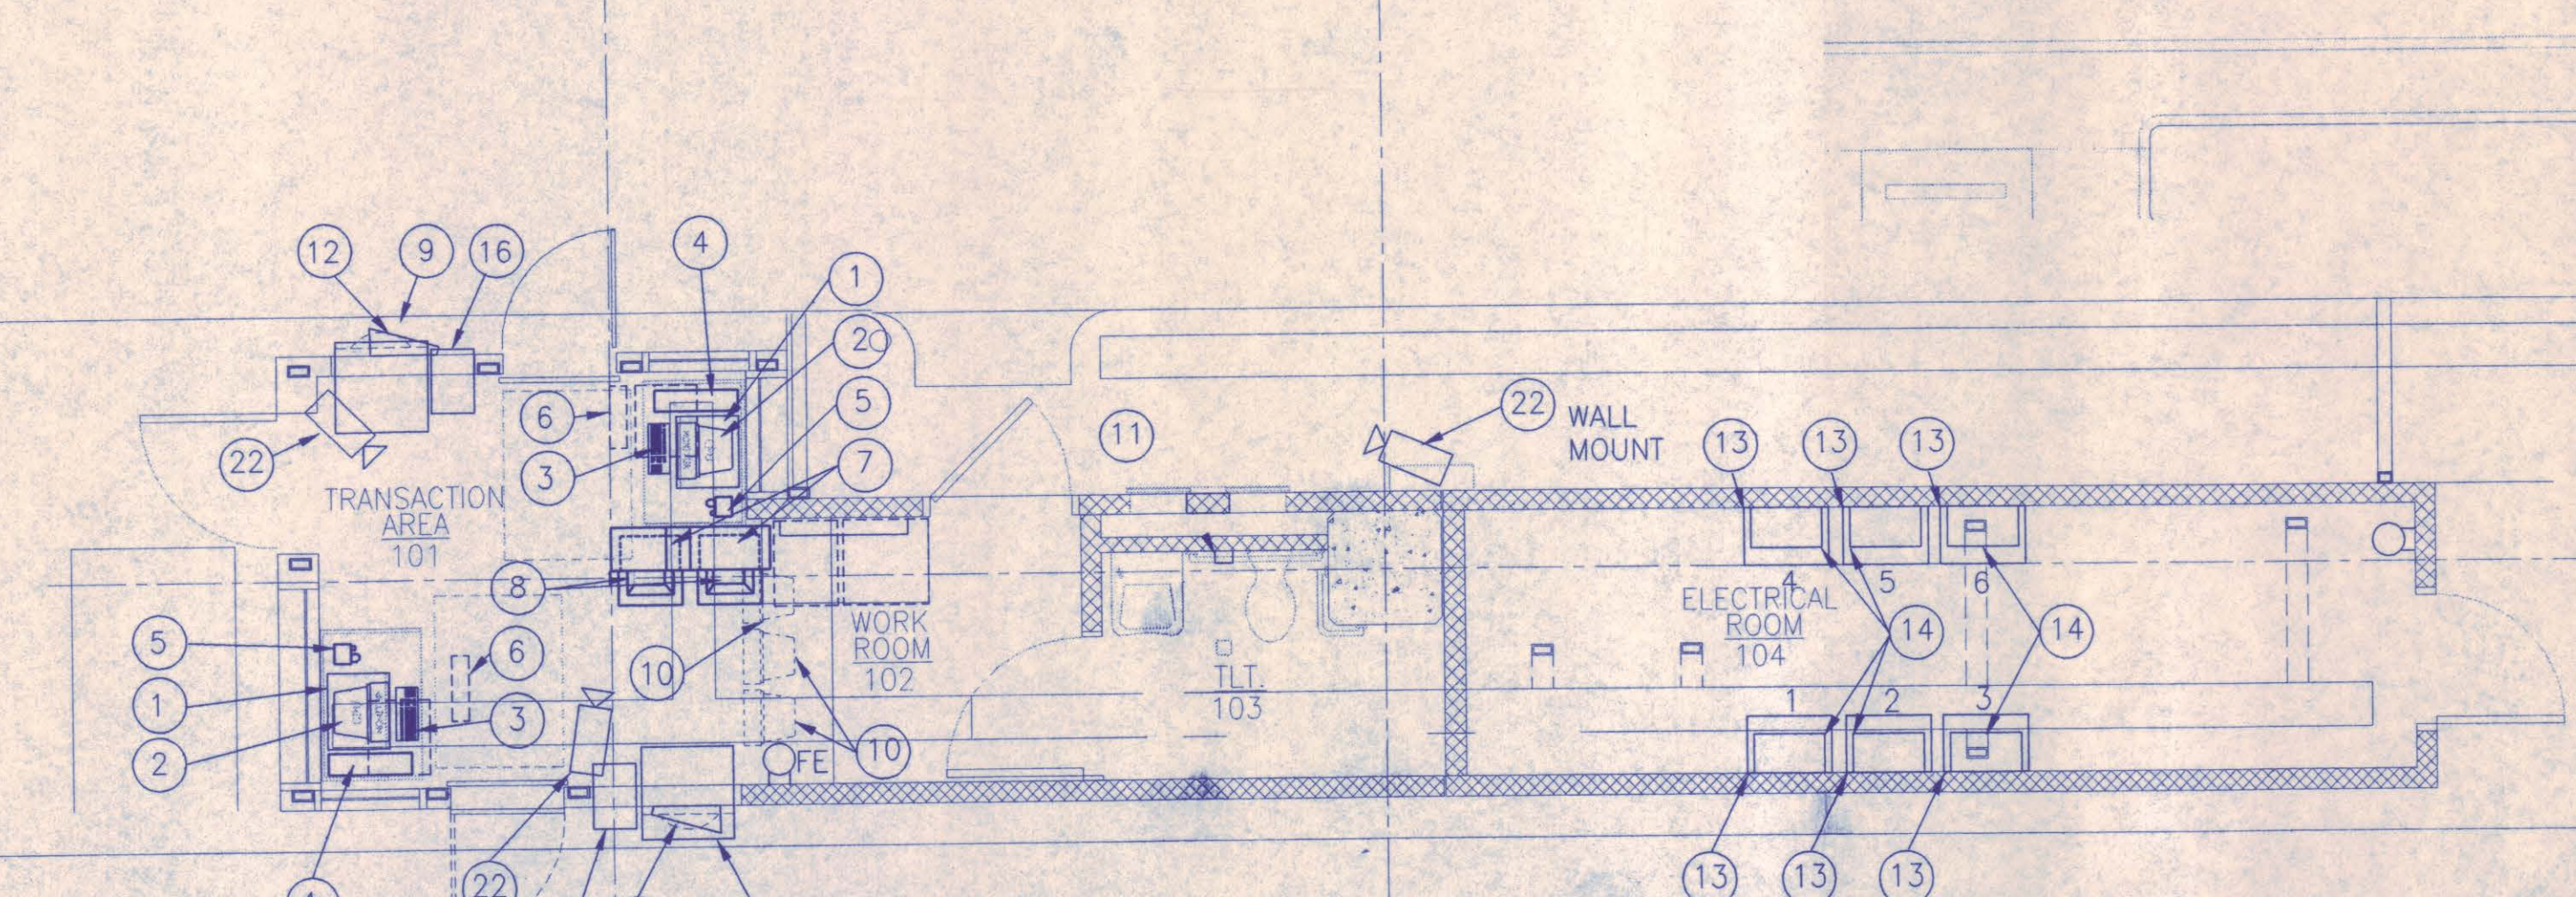

2 V.I.V.I.D. BOOTH PLAN
1/4"=1'-0" TAATAP2

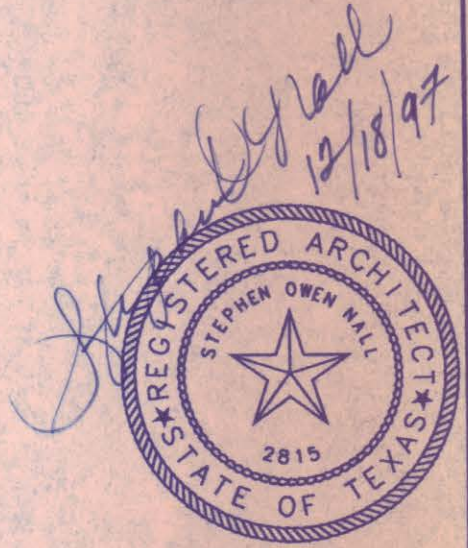

NO.	REVISION	BY	DATE
NORTH TEXAS TOLLWAY AUTHORITY ADDISON AIRPORT TUNNEL BARRIER TOLL PLAZA			
V.I.V.I.D. EQUIPMENT COORDINATION DRAWINGS			
AGUIRRE CORPORATION 3700 PARK CENTRAL DRIVE 15 TH FLOOR DALLAS TEXAS 75201 TEL. (972) 750-9008			SECTION XIII
CHECKED <i>[Signature]</i>	DATE 12/18/97	DESIGNED MM	DATE 8/15/96
CHECKED <i>[Signature]</i>	DATE 12/18/97	SCALE AS SHOWN	
CONTRACT NO. DNT-290		SHEET 33 OF 53	

AT-A10.1

GENERAL STRUCTURAL NOTES

GENERAL CONSTRUCTION:

1. ALL DETAILS AND SECTIONS SHOWN ON THE DRAWINGS ARE INTENDED TO BE TYPICAL AND SHALL BE CONSTRUED TO APPLY TO SIMILAR CONDITIONS ELSEWHERE.
2. THE CONTRACTOR SHALL FIELD CHECK AND VERIFY ALL EXISTING CONDITIONS INCLUDING ANY EXISTING CONSTRUCTION AND REPORT ANY DISCREPANCIES BEFORE PROCEEDING WITH THE WORK.
3. THE CONTRACTOR SHALL BE FAMILIAR WITH THE SCOPE OF THE WORK AND SOIL AND WATER CONDITIONS BEFORE PROCEEDING WITH THE WORK. SOIL BORING LOCATIONS AND SOIL BORING LOGS ARE INCLUDED IN THE SPECIFICATIONS. SOIL INFORMATION RELEASED IN THE SPECIFICATIONS IS FOR GENERAL INFORMATION ONLY, THE ACTUAL CONDITIONS MAY VARY AT THE SITE.
4. THE CONTRACTOR SHALL NOTIFY THE ENGINEER IMMEDIATELY OF ANY DISCREPANCIES BETWEEN CONSTRUCTION DOCUMENTS AND ACTUAL FIELD CONDITIONS.
5. THE CONTRACTOR SHALL VERIFY THE SIZE AND LOCATION OF HOLES AND SLEEVES THROUGH ALL WALLS AND SLABS WITH MECHANICAL AND PLUMBING CONTRACTORS.
6. ALL STEEL BUILDING FRAMES, UNLESS OTHERWISE NOTED , ARE NON-SELF SUPPORTING STEEL FRAMES AS DEFINED IN THE "CODE OF STANDARD PRACTICE FOR STEEL BUILDINGS AND BRIDGES" (AISC 986), SECTION [7.9.3]. THE CONTRACTOR SHALL PROVIDE TEMPORARY LATERAL BRACING FOR STEEL FRAMES UNTIL ALL BEAM-COLUMN CONNECTIONS ARE COMPLETE AND THE FLOOR AND ROOF DIAPHRAGMS ARE INSTALLED AND OF ADEQUATE STRENGTH.
7. THE STRUCTURE HAS BEEN DESIGNED FOR THE IN-SERVICE LOADS ONLY. THE METHODS, PROCEDURES AND SEQUENCES OF CONSTRUCTION ARE THE RESPONSIBILITY OF THE CONTRACTOR. THE CONTRACTOR SHALL TAKE ALL NECESSARY PRECAUTIONS TO MAINTAIN AND ENSURE INTEGRITY OF THE STRUCTURE AT ALL STAGES OF CONSTRUCTION.

FOUNDATIONS:

1. FOUNDATION DESIGN IS BASED UPON A SOILS REPORT PREPARED BY LACHEL AND ASSOCIATES, GOLDEN, COLORADO. DATED JUNE, 1996.
2. ALL PIERS SHALL BEAR ON FRESH (UNWEATHERED) AUSTIN LIMESTONE WITH A BEARING CAPACITY 30 KSF.
3. ALL PIERS SHALL BE CENTERED ON BUILDING COLUMN REFERENCE LINES UNLESS INDICATED BY AN OFFSET DIMENSION OR OTHERWISE DETAILED.

CAISSONS:

1. INSPECTION AGENCY SHALL INSPECT BOTTOM OF CAISSON SO THAT CAISSON DIAMETER AND CLEANLINESS CAN BE VERIFIED.

CONCRETE:

1. ALL REINFORCED CONCRETE SHALL BE DESIGNED AND CONSTRUCTED IN ACCORDANCE WITH THE "BUILDING CODE REQUIREMENTS FOR REINFORCED CONCRETE" (ACI 318-95) AND COMMENTARY (ACI 318R-95) BY THE AMERICAN CONCRETE INSTITUTE.
2. REINFORCING BAR DETAILING, FABRICATING, AND PLACING SHALL CONFORM TO THE "ACI STANDARD: DETAILS AND DETAILING OF CONCRETE REINFORCEMENT" (ACI 315-80, REVISED 1986) AND THE "MANUAL OF ENGINEERING AND PLACING DRAWINGS FOR REINFORCED CONCRETE STRUCTURES" (ACI 315R-80, REVISED 1988) BY THE AMERICAN CONCRETE INSTITUTE. THE MOST CURRENT EDITIONS OF CONCRETE REINFORCING STEEL INSTITUTE'S "REINFORCING BAR DETAILING" AND "PLACING REINFORCING BARS" MAY ALSO BE USED.
3. MINIMUM CONCRETE COMPRESSIVE STRENGTH (f'c) AT 28 DAYS:
FOOTINGS 3600 PSI - CLASS C
DRILLED PIERS. 3600 PSI - CLASS C
ALL OTHER CONCRETE 4000 PSI
4. CONCRETE REINFORCEMENT MATERIAL SHALL BE AS FOLLOWS:

DEFORMED BARS - COMPLYING WITH ASTM A615-87 (GRADE 60) AND HAVING A MINIMUM YIELD STRENGTH OF 60,000 PSI.

WELDED WIRE FABRIC - SMOOTH WIRE FABRIC COMPLYING WITH ASTM A185-85 (SHEETS ONLY).
5. CONCRETE PROTECTION FOR REINFORCEMENT SHALL BE AS FOLLOWS:

UNLESS OTHERWISE SHOWN THE CLEAR DISTANCE FROM THE FACE OF CONCRETE TO THE REINFORCING STEEL SHALL BE:

CONCRETE CAST AGAINST EARTH OR WATER (NOTE A) . . . 3"

CONCRETE CAST TO FORMS EXPOSED TO EARTH, WATER OR WEATHER:
#6 BARS OR LARGER 2"
SMALLER THAN #6 BARS 1 1/2"

CONCRETE CAST TO FORMS NOT EXPOSED TO EARTH, WATER OR WEATHER:
SLAB, JOISTS:
#11 BARS AND SMALLER 1"

BEAMS, COLUMNS, WALLS:
PRIMARY REINFORCEMENT, TIES,
STIRRUPS, SPIRALS 1 1/2"

SLABS POURED ON GRADE:
FROM BOTTOM SURFACE 2"
TROWELED SURFACE (NOTE B) 1"
SCREEDED SURFACE FOR APPLIED TOPPING 3/4"

(NOTE A) EXCLUDING SLABS POURED ON GRADE.
(NOTE B) INCREASE BY 1/2" IF SURFACE IS TO BE IN PERMANENT CONTACT WITH GROUND OR WATER.
6. UNLESS OTHERWISE SHOWN OR NOTED, SPlicing OF REINFORCING BARS SHALL CONFORM TO THE REQUIREMENTS OF ACI 318-95 BUILDING CODE.
7. UNLESS OTHERWISE SHOWN OR NOTED, TOP AND BOTTOM BARS FOR CONTINUOUS BEAMS SHALL BE OF MAXIMUM LENGTH WITH SPLICES LOCATED AT MIDSPAN FOR TOP BARS AND AT SUPPORTS FOR BOTTOM BARS.
8. ALL HORIZONTAL BARS IN WALLS OR GRADE BEAMS SHALL BE BENT AT CORNERS AND INTERSECTIONS IN SUCH A WAY THAT CONTINUITY IS PROVIDED THROUGH THE JOINT. SEPARATE CORNER BARS OF THE SAME SIZE AND SPACING AS THE HORIZONTAL REINFORCING MAY BE SUBSTITUTED FOR THE BENT PORTION OF THE CONTINUOUS BARS.
9. ALL REINFORCING BAR SPLICES SHALL BE CLASS 'B' TENSION LAP SPLICES UNLESS OTHERWISE SHOWN ON THE DRAWINGS.
10. ALL REINFORCING FOR SLABS ON GRADE SHALL BE CHAIRED WITH SLAB BOLSTERS DESIGNED FOR SUPPORT ON SOIL TO PROVIDE SPECIFIED COVER TO REINFORCING STEEL.

PRECAST/PRESTRESSED CONCRETE:

1. PRECAST/PRESTRESSED CONCRETE SHALL BE DESIGNED IN ACCORDANCE WITH THE "BUILDING CODE REQUIREMENTS FOR REINFORCED CONCRETE" (ACI 318-95) BY THE AMERICAN CONCRETE INSTITUTE.
2. PRECAST/PRESTRESSED CONCRETE SHALL COMPLY WITH RECOMMENDED PRACTICES AND PROCEDURES IN THE "MANUAL FOR QUALITY CONTROL FOR PLANTS AND PRODUCTION OF PRECAST AND PRESTRESSED CONCRETE PRODUCTS" (PCI MNL-116-85) BY THE PRESTRESSED CONCRETE INSTITUTE.
3. UNLESS NOTED OTHERWISE ALL PRECAST/PRESTRESSED CONCRETE SHALL BE SUPPLIED BY A "PCI CERTIFIED PLANT."
4. ALL PRECAST MEMBERS SHALL BE OF SIZE, SHAPE, AND MODULE INDICATED ON THE DRAWINGS. ALL UNITS SHALL BE CAPABLE OF SUPPORTING SUPERIMPOSED DEAD LOADS AND LIVE LOADS AS SCHEDULED PLUS DEAD WEIGHT OF PRECAST. SUBMIT FOR REVIEW, MANUFACTURER'S COMPLETE DESIGN CALCULATIONS PREPARED AND SEALED BY A REGISTERED TEXAS PROFESSIONAL ENGINEER QUALIFIED IN THE DESIGN OF PRECAST AND PRESTRESSED CONCRETE.
5. FIELD CUT HOLES FOR OPENINGS WITHOUT DISTURBING PRESTRESSING STRANDS IN ACCORDANCE WITH PRESTRESSED UNIT MANUFACTURER'S INSTRUCTIONS. VERIFY SIZE AND LOCATION OF HOLES AND SLEEVES WITH OTHER TRADES.
6. PRECAST/PRESTRESSED CONCRETE SHALL HAVE A MINIMUM COMPRESSIVE STRENGTH (f'c) OF 5,000 PSI IN 28 DAYS AND A MINIMUM RELEASE STRENGTH OF 3,500 PSI UNLESS OTHERWISE SPECIFIED.
7. WIRE AND STRANDS FOR TENDONS IN PRESTRESSED CONCRETE SHALL COMPLY WITH ASTM A416-87A.
8. DEFORMED REINFORCING BARS SHALL COMPLY WITH ASTM A615-87
9. WELDED WIRE FABRIC SHALL COMPLY WITH ASTM A185-85.
10. COLD DRAWN STEEL WIRE SHALL COMPLY WITH ASTM A82-85.
11. ANCHORS AND INSERTS FOR PRECAST/PRESTRESSED SHALL BE STRUCTURAL STEEL AND COMPLY WITH ASTM A36.
12. THE PRECAST CONCRETE MANUFACTURER SHALL SUBMIT SHOP DRAWINGS FOR A/E REVIEW WHICH WILL INCLUDE, BUT NOT BE LIMITED TO THE FOLLOWING:

A. DETAILED LAYOUT DRAWING SHOWING ALL PANEL DIMENSIONS AND JOINT LAYOUT.

B. INDIVIDUAL MEMBER LOADING, DESIGN AND REINFORCING REQUIREMENTS.

C. DETAIL ALL REQUIRED BLOCKOUTS, INSERTS AND ANCHORAGE DEVICES AND BEARING PADS.

D. PROVIDE INFORMATION ON PROCEDURES FOR LEVELING AND ALIGNING PLANKS DUE TO DIFFERENT CAMBER CONDITIONS FOR INDIVIDUAL PLANKS PRIOR TO GROUTING THE JOINTS.
13. ALL BEARING PADS SHALL BE 3/8" THICK MIN. OR AS REQUIRED CONFORM TO THEBY PRECAST SUPPLIER.

POST INSTALLED ANCHORS

1. ALL BOLTS INDICATED AS CONCRETE EXPANSION ANCHORS (C.E.A.) SHALL HAVE THE FOLLOWING AS THE MINIMUM ACCEPTABLE CRITERIA:

SIZE	MIN EMBEDMENT	ULTIMATE TENSILE LOAD	ULTIMATE SHEAR LOAD
1/2" DIA	3 1/2"	6500 LBS	8340 LBS
3/4" DIA	4 3/4"	12200 LBS	17450 LBS

* THE ABOVE ULTIMATE LOADS ARE FOR 3000 PSI CONCRETE. ALLOWABLE LOADS ARE SIGNIFICANTLY REDUCED.
2. ALL CONCRETE EXPANSION ANCHORS SHALL BE GALVANIZED.



NO.	REVISION	BY	DATE
NORTH TEXAS TOLLWAY AUTHORITY ADDISON AIRPORT TUNNEL BARRIER TOLL PLAZA			
STRUCTURAL			
GENERAL NOTES			
AGUIRRE Corporation 12700 PARK CENTRAL DRIVE 15 TH FLOOR DALLAS TEXAS 75201 TEL. (972) 788-9555			SECTION XIII
CHECKED <i>Shane</i>	DATE 12/18/97	DESIGNED SHJ	DATE 8/15/96
CHECKED <i>John</i>	DATE 12/18/97	SCALE NONE	
CONTRACT NO. DNT-290 SHEET 34 OF 53			

AT S0.1

GENERAL STRUCTURAL NOTES - CONT'D

MASONRY:

- ENGINEERED MASONRY SHALL BE DESIGNED AND CONSTRUCTED IN ACCORDANCE WITH THE FOLLOWING:

"BUILDING CODE REQUIREMENTS FOR MASONRY STRUCTURES" (ACI 530-88/ASCE 5-88) BY THE AMERICAN CONCRETE INSTITUTE.

"TECHNICAL NOTES ON BRICK CONSTRUCTION" BY THE BRICK INSTITUTE OF AMERICA.
- MINIMUM COMPRESSIVE STRENGTH OF MASONRY UNITS:

HOLLOW CONCRETE MASONRY . . . ASTM C90 . . . 1900 PSI
SOLID CONCRETE MASONRY . . . ASTM C145 . . . 2000 PSI
- MINIMUM COMPRESSIVE STRENGTH (F'C) AT 28 DAYS:

TYPE S MORTAR ASTM C270 . . . 1800 PSI
TYPE M MORTAR ASTM C270 . . . 2500 PSI
GROUT ASTM C476 . . . 2500 PSI
- THE DESIGN COMPRESSIVE STRENGTH OF MASONRY (f'm) BASED ON THE COMPRESSIVE STRENGTH OF MASONRY UNITS AND MORTAR TO BE USED ARE AS FOLLOWS:

CONCRETE MASONRY f'm = 1500 PSI
CLAY MASONRY f'm = 1500 PSI
- MASONRY REINFORCEMENT SHALL BE AS FOLLOWS:

BOND BEAMS AND ALL VERTICAL REINFORCEMENT:
SHALL COMPLY WITH ASTM A615-87 (GRADE 60)
A MINIMUM YIELD STRENGTH OF 60,000 PSI.

BED JOINT REINFORCEMENT:

CONTINUOUS HORIZONTAL WIRE TIES SHALL BE PLACED SUCH THAT THE DISTANCE BETWEEN THE FACE OF THE MASONRY WALL AND THE PARALLEL WIRE IS NOT MORE THAN ONE INCH. THE PARALLEL WIRES SHALL CONFORM TO ASTM A82 AND HAVE A MINIMUM YIELD STRESS OF 70.0 KSI.

FOR SINGLE WYTHER BLOCK PROVIDE:

(2)#9 GAGE DEFORMED WIRES,(1) AT EACH FACE SHELL, TRUSS TIED.
- UNLESS OTHERWISE SHOWN OR NOTED, REINFORCING STEEL SHALL BE LAPPED 48 BAR DIAMETERS, MINIMUM.
- USE NORMAL WEIGHT CONCRETE MASONRY UNITS BELOW GRADE AND LIGHTWEIGHT CONCRETE MASONRY UNITS ABOVE GRADE UNLESS OTHERWISE SHOWN OR NOTED.
- BEARINGS FOR BEAMS, LINTELS, JOISTS, ETC., SHALL BE SOLID MASONRY UNITS OR HOLLOW MASONRY UNITS WITH CORES SLUSHED SOLID WITH GROUT. SEE TYPICAL DETAILS.
- ALL PRE-INSTALLED AND POST-INSTALLED ANCHORS TO BE PROVIDED IN CMU WALLS SHALL BE ANCHORED INTO FULLY GROUTED CELLS.
- LOCATION OF VERTICAL CONTROL JOINTS IN MASONRY WALLS ARE INDICATED ON THE STRUCTURAL DRAWINGS.
- VERTICAL WALL REINFORCING SHALL BE PROVIDED AND SPACED AS INDICATED ON THE DRAWINGS. ADDITIONAL VERTICAL REINFORCING SHALL BE PROVIDED AT EACH SIDE OF CONTROL JOINTS, CORNERS, INTERSECTIONS, FLANKS OF OPENINGS, AND ENDS OF WALLS.
- PROVIDE LINTELS FOR ALL MASONRY OPENINGS AND RECESSES NOT OTHERWISE DETAILED OR SCHEDULED AS FOLLOWS:

(1) L 5 X 3-1/2 X 5/16 FOR EACH 4" OF MASONRY WIDTH WITH A MAXIMUM SPAN OF 8'-0"
(1) WT 4 X 9 FOR EACH 6" MASONRY WIDTH WITH A MAXIMUM SPAN OF 8'-0"
(1) C 8 X 11.5 WITH PLATE 5/16 X 9 FOR 10" MASONRY WIDTH WITH A MAXIMUM SPAN OF 8'-0"

FOR SPANS OF LESS THAN 2'-0", USE 5/16" PLATE X MASONRY WIDTH LESS 1".
- PROVIDE MINIMUM 8" BEARING FOR BEAMS OR LINTELS WITH SPANS 4'-0" OR LARGER AND 6" BEARING ON SPANS LESS THAN 4'-0", UNLESS OTHERWISE DETAILED ON DRAWINGS.
- ALL BOND BEAMS SHALL HAVE 2 - #5 CONTINUOUS UNLESS NOTED OTHERWISE.

STRUCTURAL STEEL:

- ALL STRUCTURAL STEEL SHALL BE DESIGNED AND CONSTRUCTED IN ACCORDANCE TO AISC "SPECIFICATION FOR THE DESIGN, FABRICATION, AND ERECTION OF STRUCTURAL STEEL FOR BUILDINGS, ALLOWABLE STRESS DESIGN," ASD NINTH EDITION.
- ALL STRUCTURAL STEEL UNLESS OTHERWISE NOTED SHALL CONFORM TO THE FOLLOWING ASTM SPECIFICATIONS:

STRUCTURAL SHAPES A36
PLATE AND BARS A36
STRUCTURAL STEEL PIPE A501
STRUCTURAL STEEL TUBING A500 GRADE B
- ALL BEAM CONNECTIONS NOT OTHERWISE DETAILED OR CALLED OUT SHALL BE STANDARD FRAMED CONNECTIONS DESIGNED TO SUPPORT NOT LESS THAN 50% OF THE TOTAL UNIFORM LOAD FOR THE BEAM SHAPE AND SPAN. PROVIDE A 2 ROW CONNECTION MINIMUM FOR BEAMS OF 10" DEPTH OR LESS AND A 3 ROW CONNECTION MINIMUM FOR BEAMS OF 12" DEPTH OR LARGER.
- SHOP CONNECTIONS MAY BE WELDED OR HIGH STRENGTH BOLTED AT FABRICATOR'S OPTION, SUBJECT TO ENGINEER'S APPROVAL.
- ALL BOLTED CONNECTIONS FOR STRUCTURAL STEEL SHALL CONFORM TO AISC "SPECIFICATION FOR STRUCTURAL JOINTS USING ASTM A325 OR A490 BOLTS," DATED NOV. 13, 1985.
- UNLESS OTHERWISE SHOWN OR NOTED ON THE DRAWINGS, ALL BOLTED CONNECTIONS SHALL BE MADE WITH 3/4" DIAMETER HIGH STRENGTH BOLTS, BEARING TYPE WITH THREADS IN THE SHEAR PLANE, CONFORMING TO ASTM A325-N.
- ALL WELDED CONNECTIONS FOR STRUCTURAL STEEL SHALL CONFORM TO AWS "STRUCTURAL WELDING CODE," D1.1 - 90.
- UNLESS OTHERWISE SHOWN OR NOTED ON THE DRAWINGS, ALL WELDED CONNECTIONS SHALL BE MADE WITH E70-XX ELECTRODES. SHIELDED METAL ARC WELDING PROCESS SHALL USE LOW HYDROGEN ELECTRODES.
- PROVIDE ALL BOLT HOLES, STUDS, ANCHORS, AND CLIP ANGLES REQUIRED TO ATTACH OTHER MATERIALS AS SHOWN ON THE DRAWINGS.
- ANCHOR BOLTS SHALL CONFORM TO ASTM A307 AND SHALL BE PLACED WITHIN THE FOLLOWING TOLERANCES:

TOP OF ANCHOR BOLT ELEVATION (+) 1" TO (-) 3/8"
OUT OF POSITION OF ANCHOR BOLTS (+/-) 1/8"
ELEVATION OF FINISHED CONCRETE SURFACE FOR BEARING (+/-) 1/8"
- ALL GROUT BELOW ALL COLUMN BASE PLATES SHALL BE NON-SHRINK NON-METALLIC GROUT UNLESS OTHERWISE SHOWN OR NOTED.

METAL DECK:

- ALL METAL DECK SHALL BE DETAILED, FABRICATED AND INSTALLED IN ACCORDANCE WITH THE STEEL DECK INSTITUTE SPECIFICATIONS DATED 1987.
- ROOF DECK SHALL BE SCREWED TO SUPPORTS WITH A 36/5 PATTERN AND 3 - #10 SCREW SIDELAPS PER SPAN.
- ALTERNATE FASTENER TYPES MAY BE USED ONLY WITH THE APPROVAL OF THE ENGINEER.

COLD-FORMED METAL FRAMING:

- STRUCTURAL COLD-FORMED METAL (LIGHT-GAGE) FRAMING SHALL BE DESIGNED AND CONSTRUCTED IN ACCORDANCE WITH THE AISI "SPECIFICATION FOR COLD-FORMED STEEL STRUCTURAL MEMBERS," DATED MARCH 1986.
- ALL STRUCTURAL LIGHT-GAGE JOISTS AND STUDS SHALL CONFORM TO THE FOLLOWING MINIMUM YIELD STRENGTH PER ASTM SPECIFICATIONS:

12, 14, 16 GAGE . . . 50,000 PSI
18, 20 GAGE 33,000 PSI
- FULL-HEIGHT DOUBLE STUDS SHALL BE PROVIDED AT THE ENDS OF PARTITIONS, AT ALL WALL OPENINGS AND AT OTHER LOCATIONS SHOWN ON DRAWINGS.
- PROVIDE STUD WALL BRIDGING ACCORDING TO MANUFACTURERS LATEST RECOMMENDATIONS.
- ANCHOR STUD TRACKS TO SUPPORTS WITH LOW - VELOCITY POWER - DRIVEN FASTENERS WITH A MINIMUM SHANK DIAMETER OF 0.145", AND MINIMUM PENETRATION OF 1-1/8". SPACE FASTENERS AT 16" O.C. MAXIMUM.

DESIGN CRITERIA:


- THE STRUCTURAL ENGINEERING DESIGN IS BASED ON AND IN ACCORDANCE WITH THE FOLLOWING CODE(S):

UNIFORM BUILDING CODE - 1991
ASCE 7-95 - "MINIMUM DESIGN LOADS FOR BUILDINGS AND OTHER STRUCTURES"
- LIVE LOADS


A. ROOF LOADS20 PSF
B. WIND LOADS

1.) WIND SPEED (V) 90 MPH
2.) IMPORTANCE FACTOR (I)1.15 CANOPY
3.) EXPOSURE CATEGORYC
- SEISMIC


A. Aa < 0.05
B. Av < 0.05
C SPC A

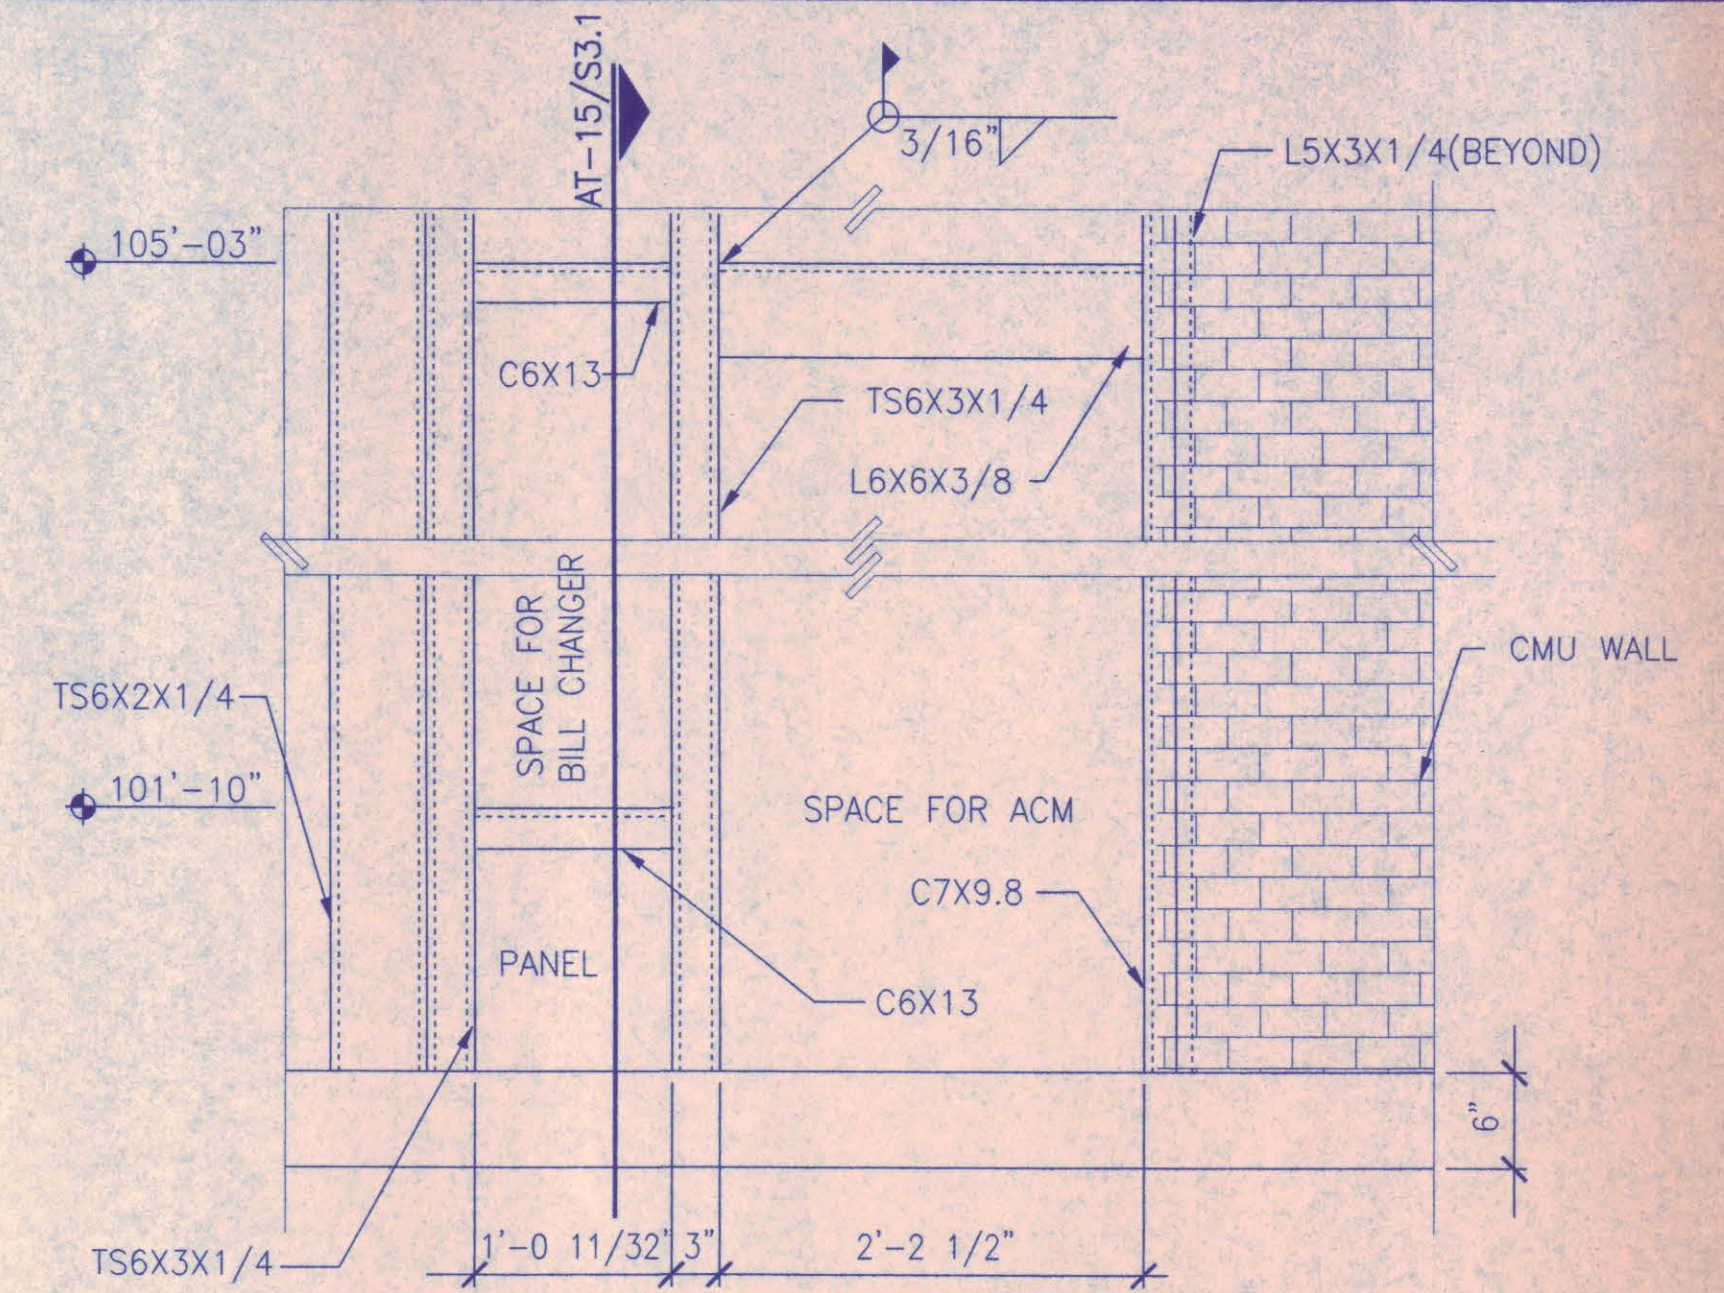


3 FRONT VIEW
SCALE: 1/2" = 1'-0" SXM10

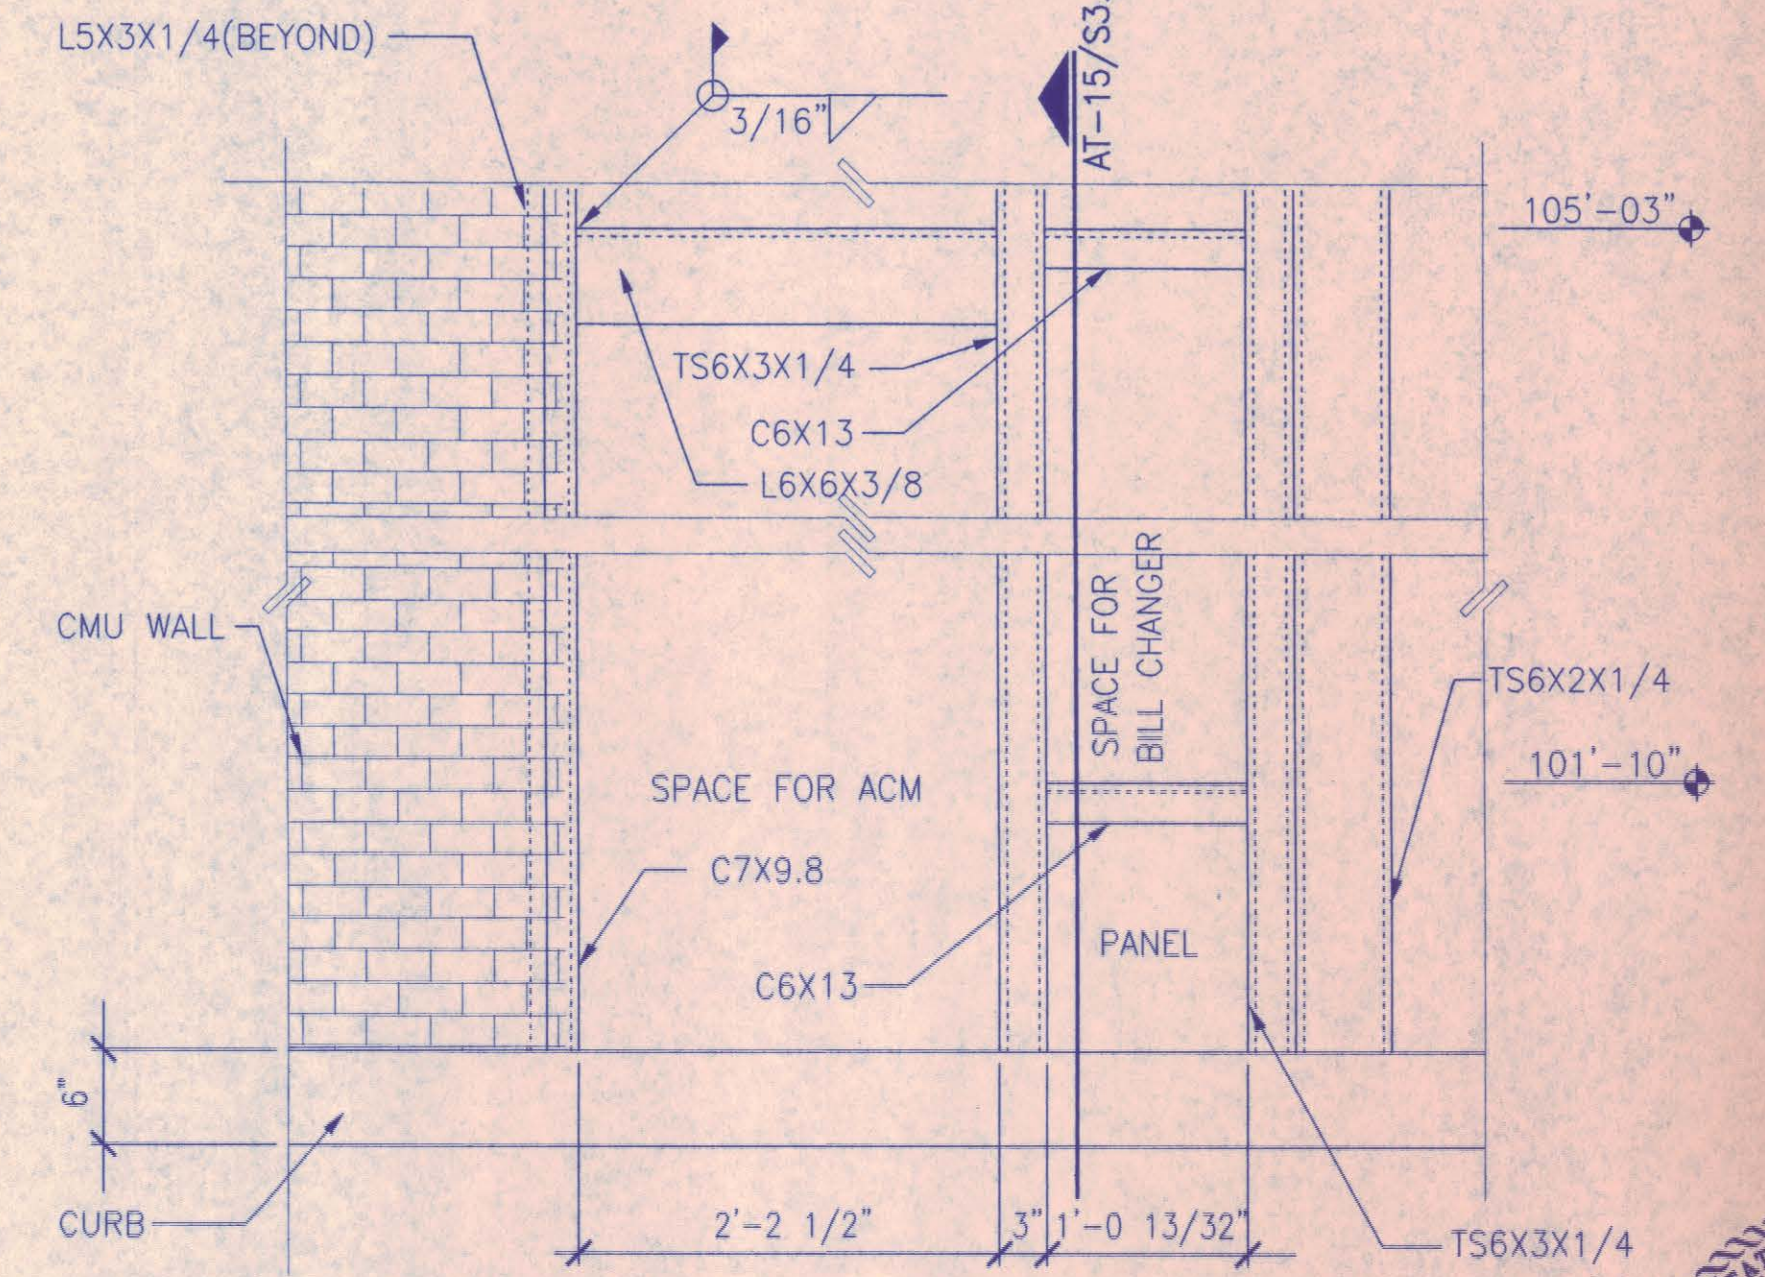

4 FRONT VIEW
SCALE: 1/2" = 1'-0" SXM11

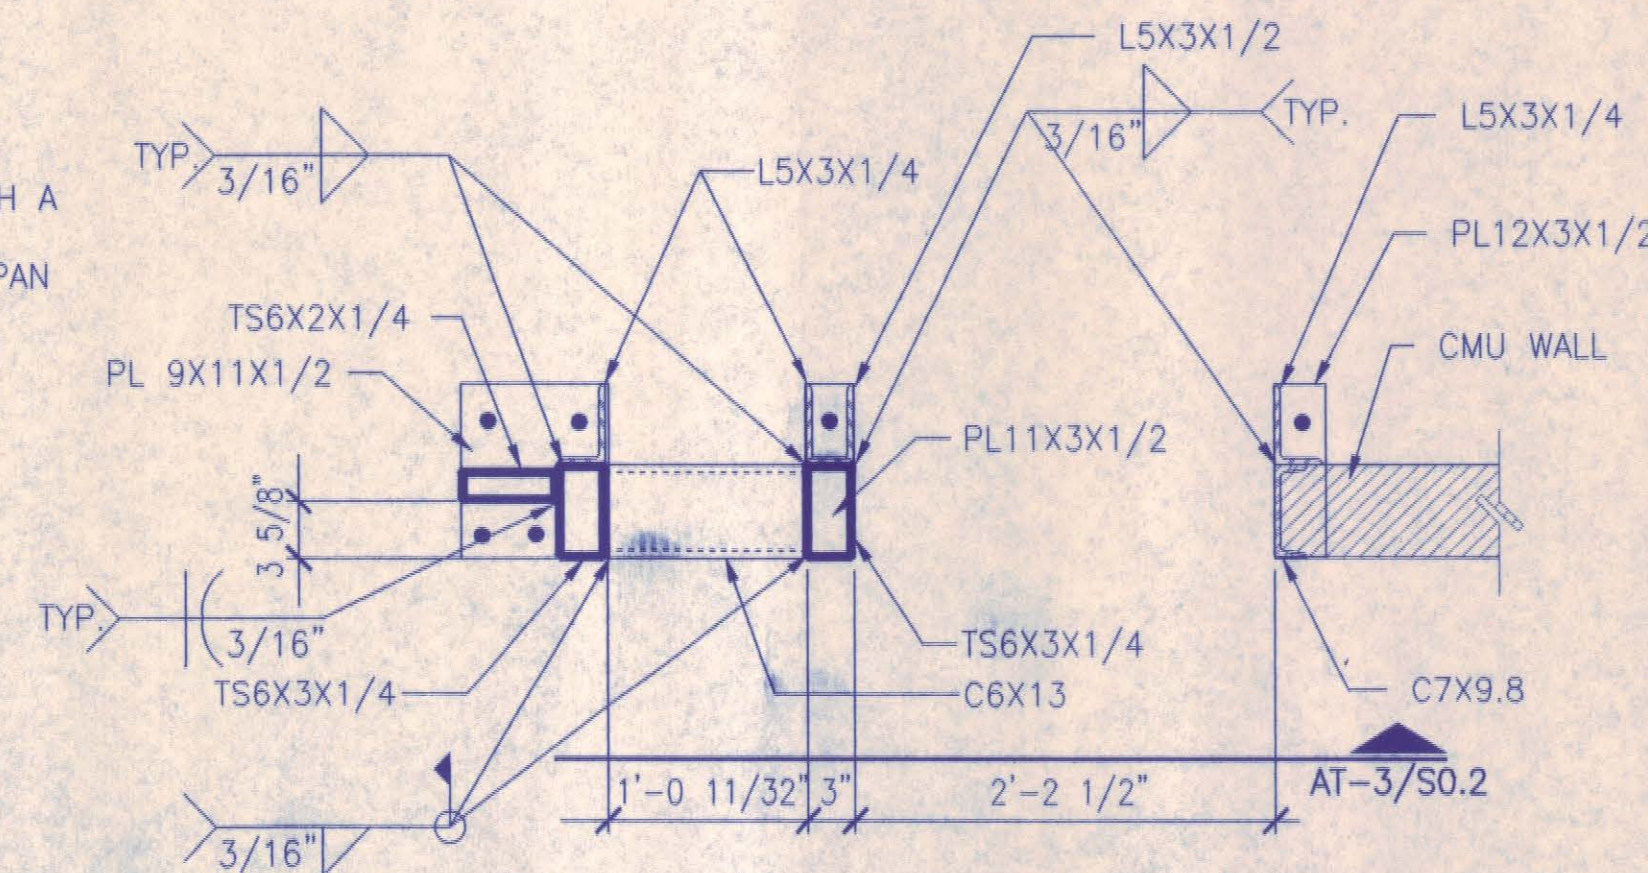


1 PLAN
SCALE: 1/2" = 1'-0" sxm07

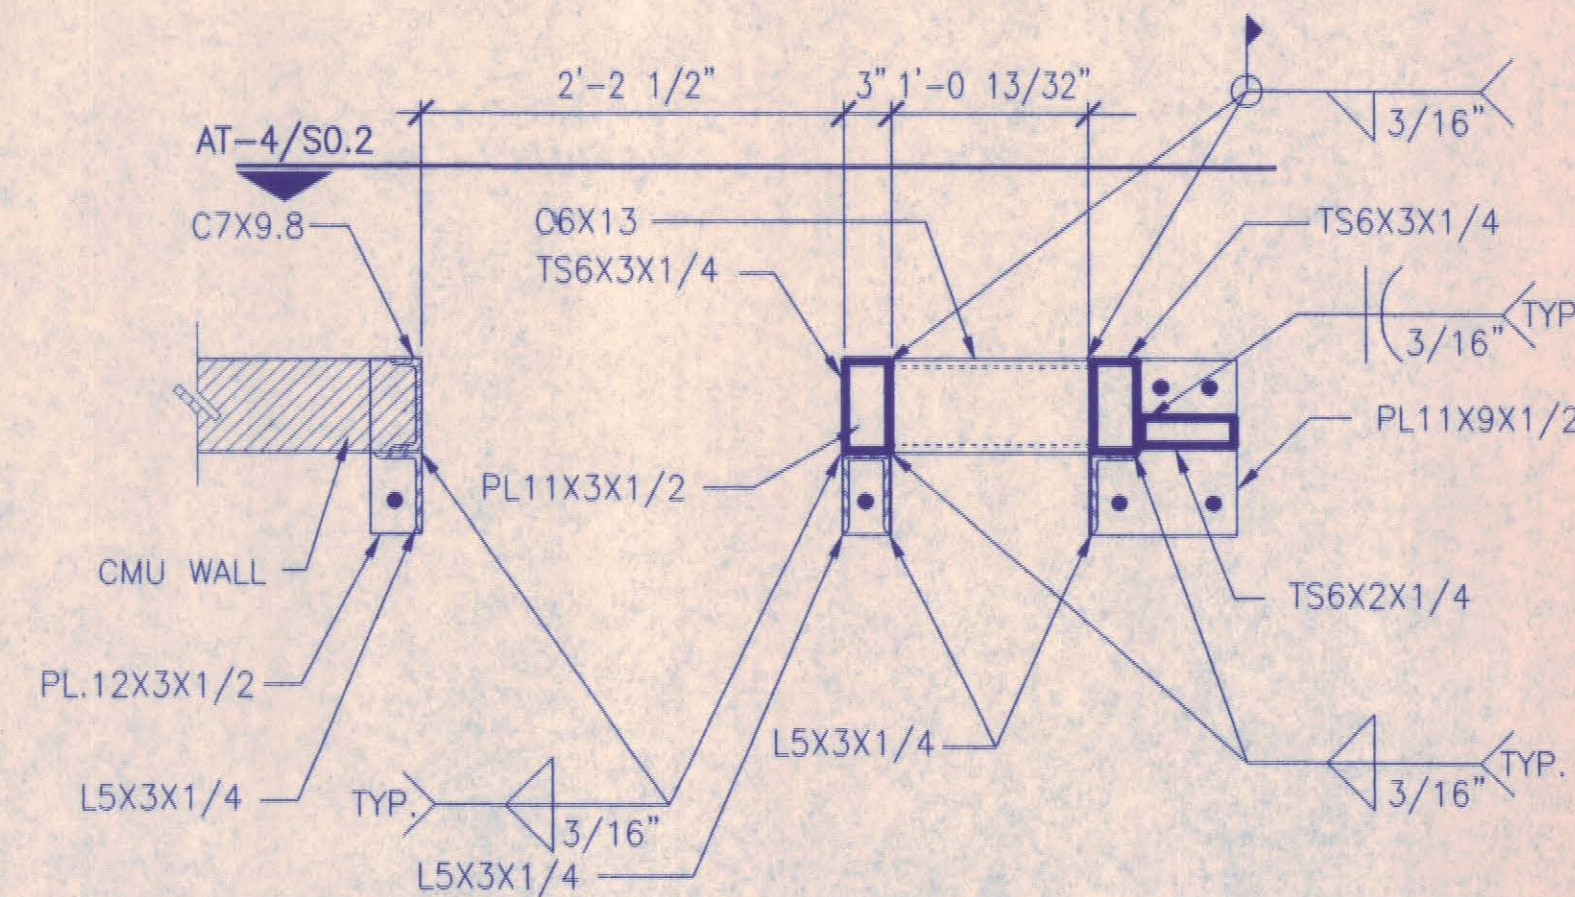


2 PLAN
SCALE: 1/2" = 1'-0" sxm08

AT S0.2


NO.	REVISION	BY	DATE
NORTH TEXAS TOLLWAY AUTHORITY ADDISON AIRPORT TUNNEL BARRIER TOLL PLAZA			
STRUCTURAL GENERAL NOTES - CONT'D			
AGUIRRE AGUIRRE CONSULTING 25700 PARK CENTRAL DRIVE 16 TH FLOOR DALLAS TEXAS 75244 TEL. (972) 790-1908		SECTION XIII	
CHECKED <i>[Signature]</i>	DATE 12/18/97	DESIGNED SHJ	DATE 8/15/96
CHECKED <i>[Signature]</i>	DATE 12/18/97	SCALE NONE	
CONTRACT NO. DNT-290		SHEET 35 OF 53	

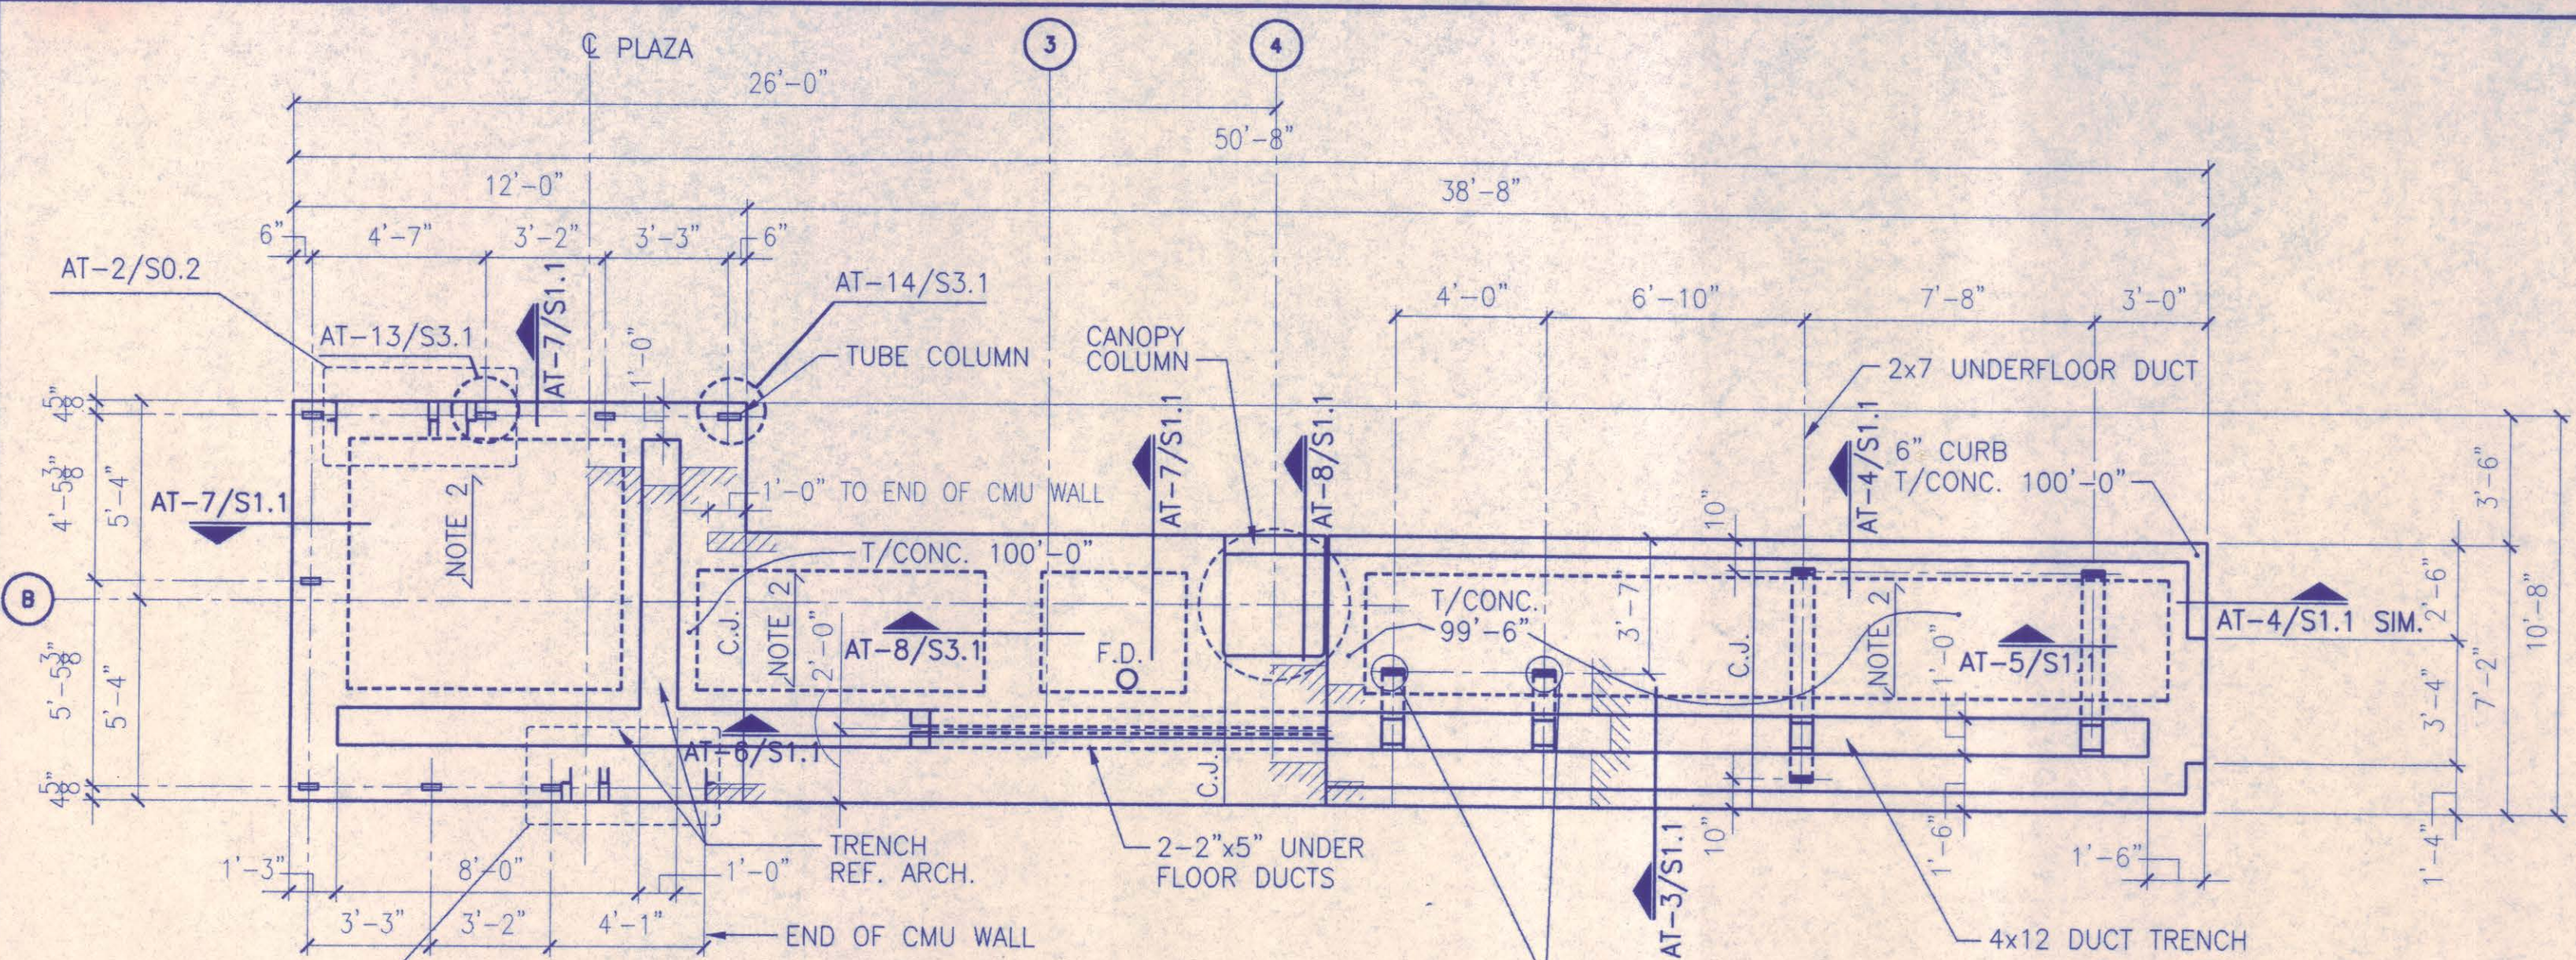


2 BOOTH/BUILDING FOUNDATION PLAN
1/4" = 1'-0" TAATSPF2.DWG

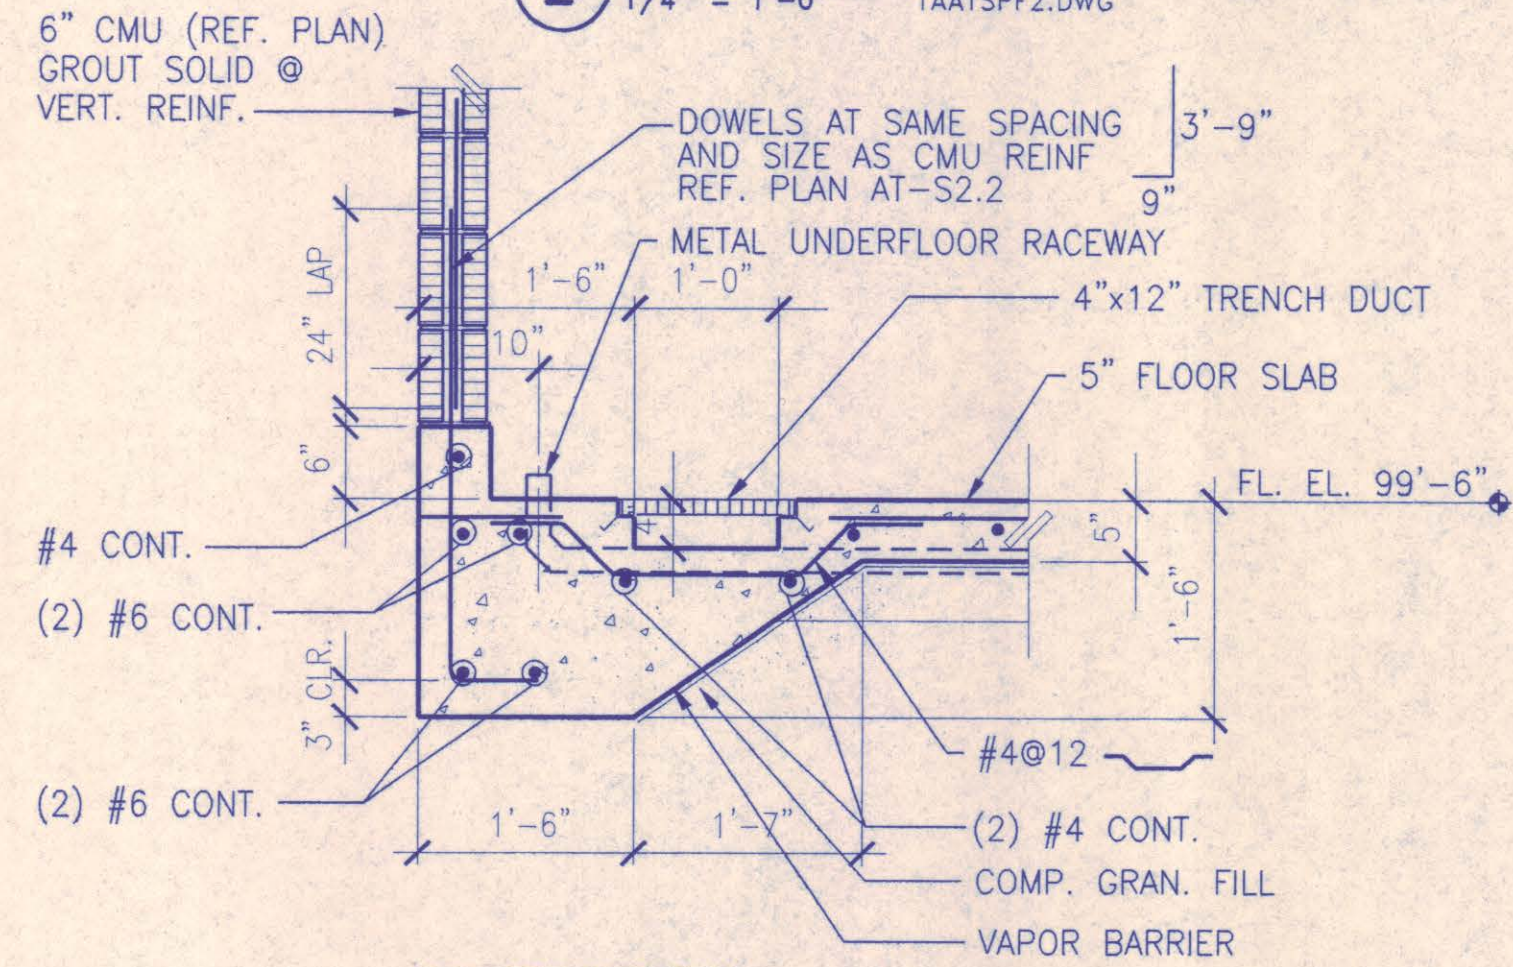


3 SECTION
3/4" = 1'-0" TAATSM5.DWG

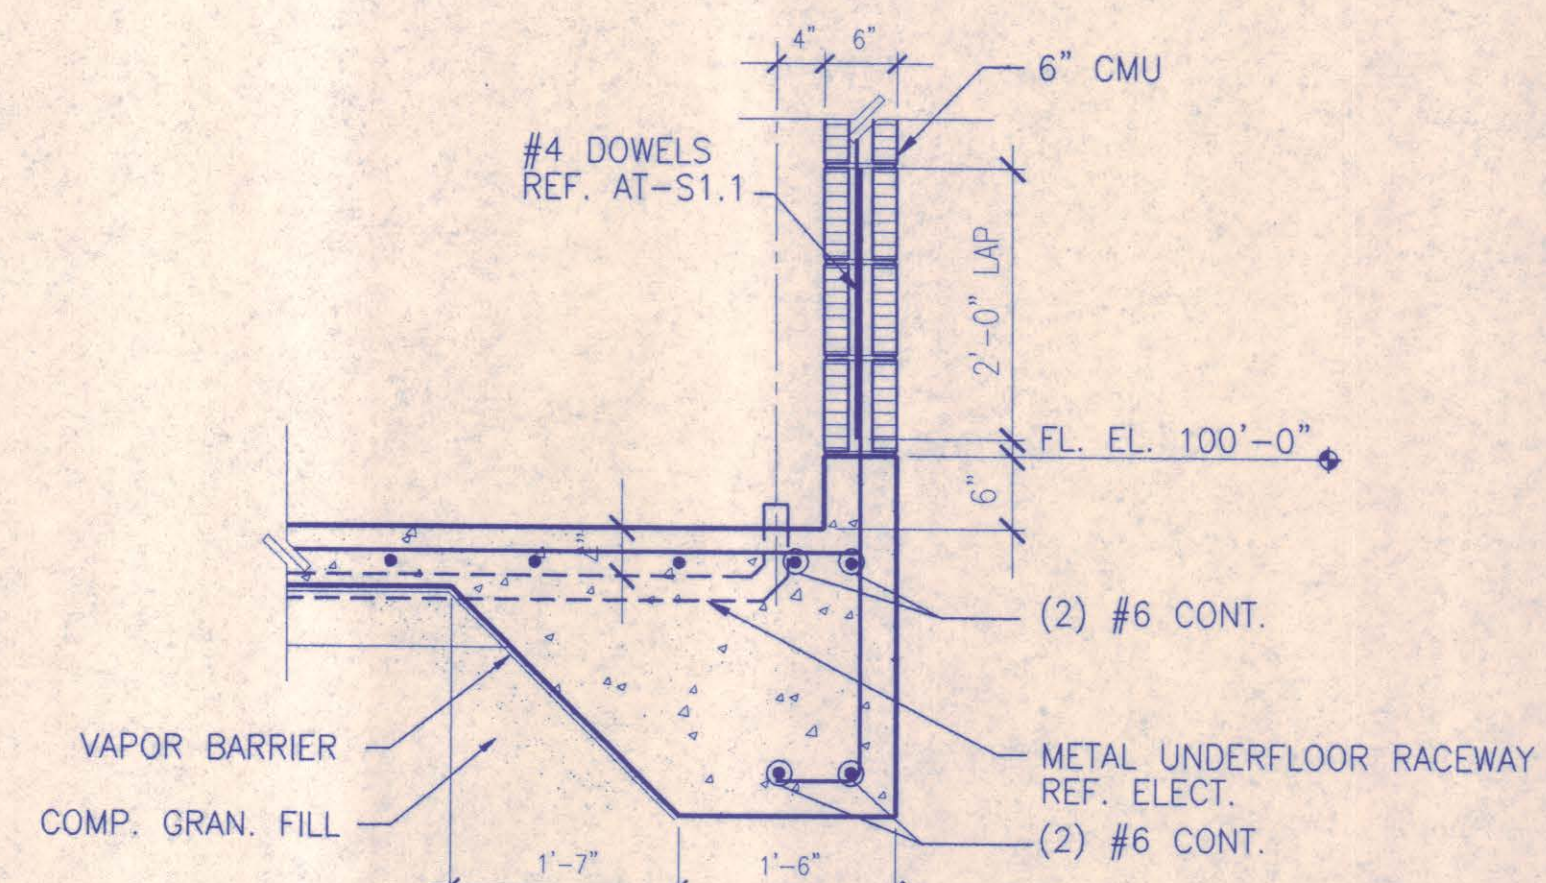


4 SECTION
3/4" = 1'-0" TAATSM5.DWG

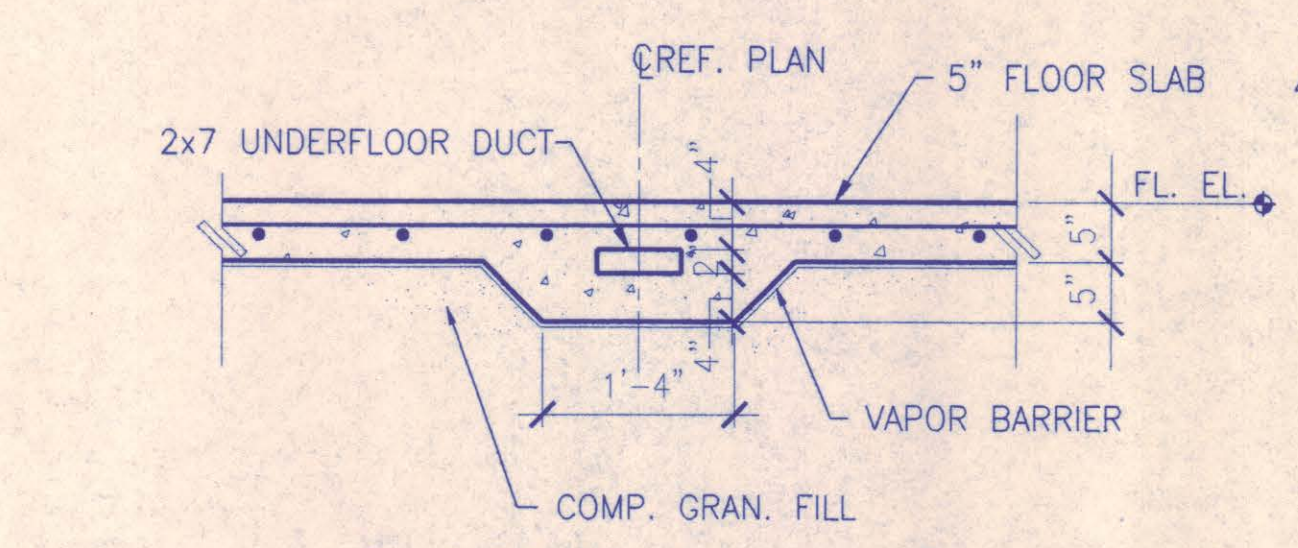


5 SECTION
3/4" = 1'-0" TAATSM5.DWG

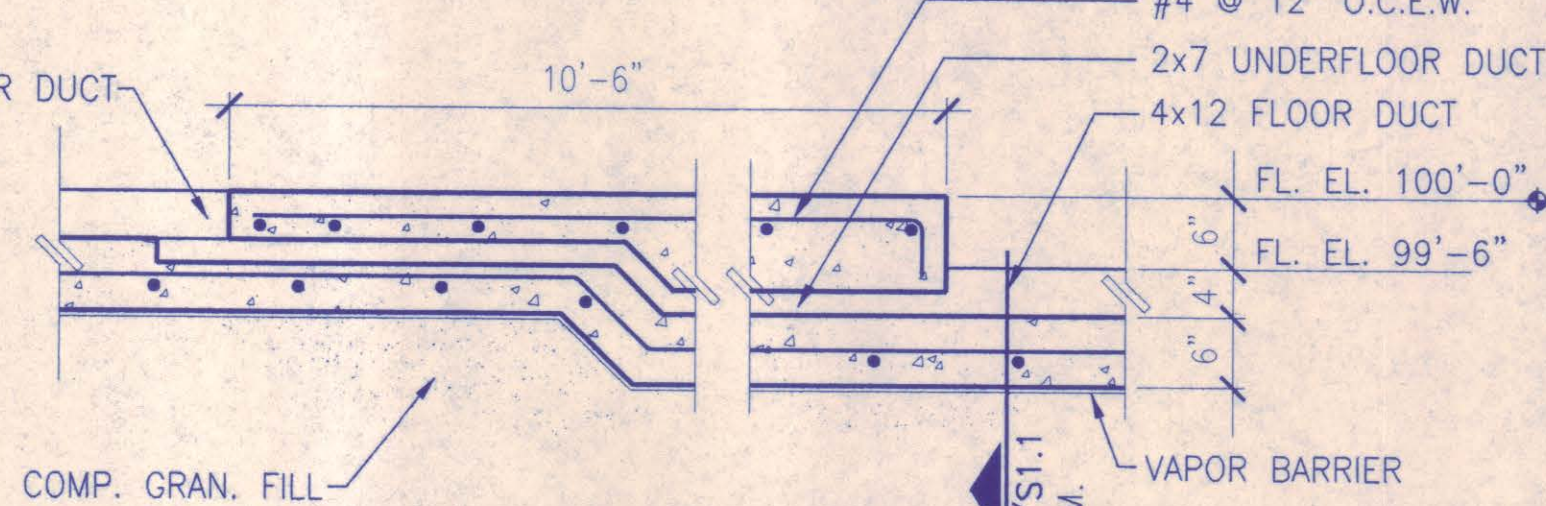


6 SECTION
3/4" = 1'-0" TAATSM5.DWG

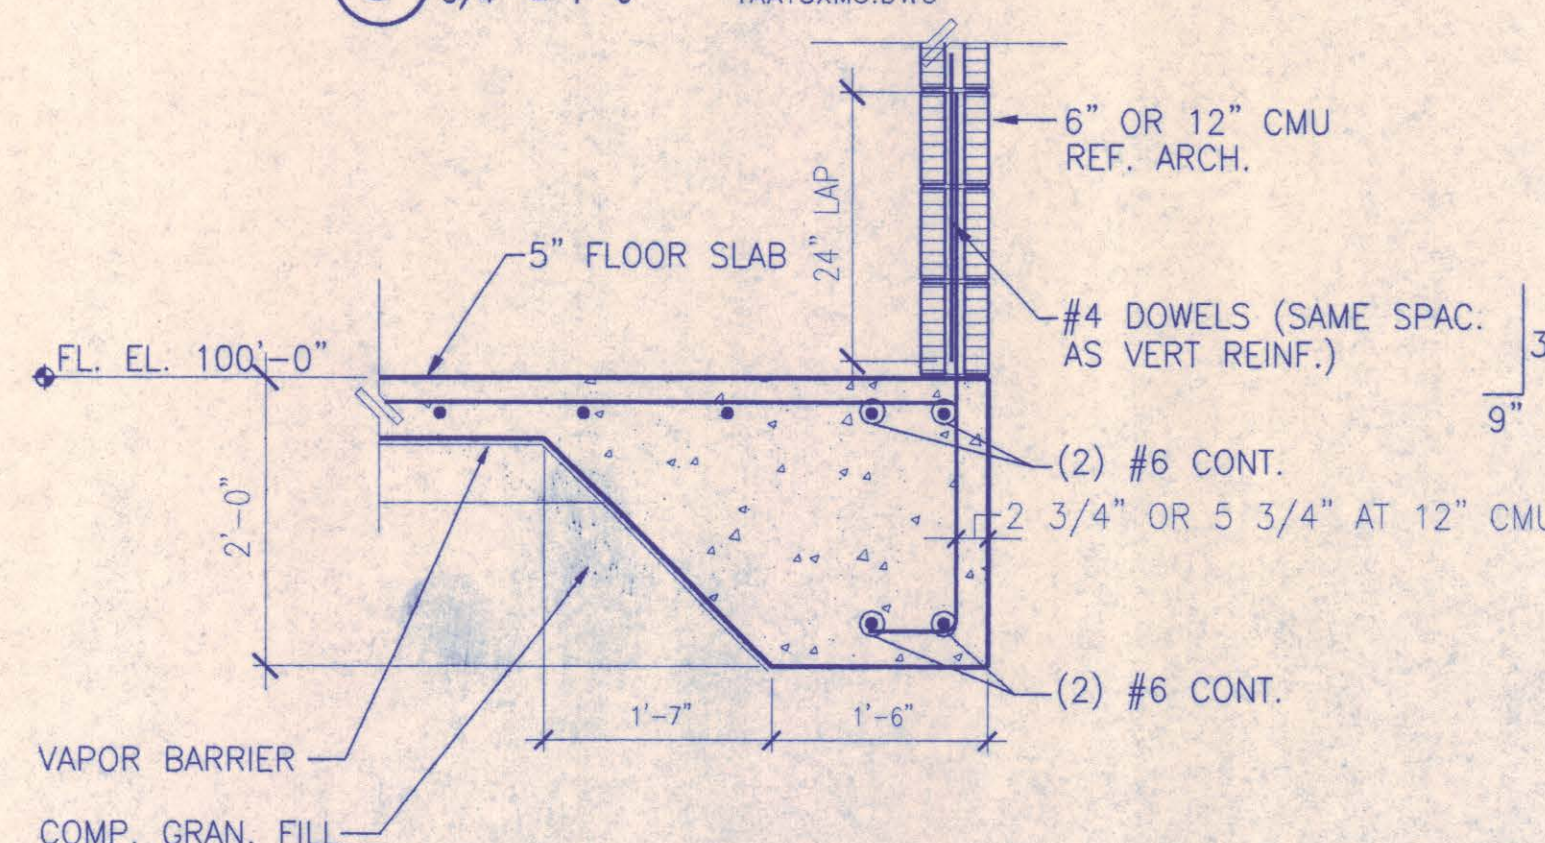

7 SECTION
3/4" = 1'-0" TAATSM5.DWG

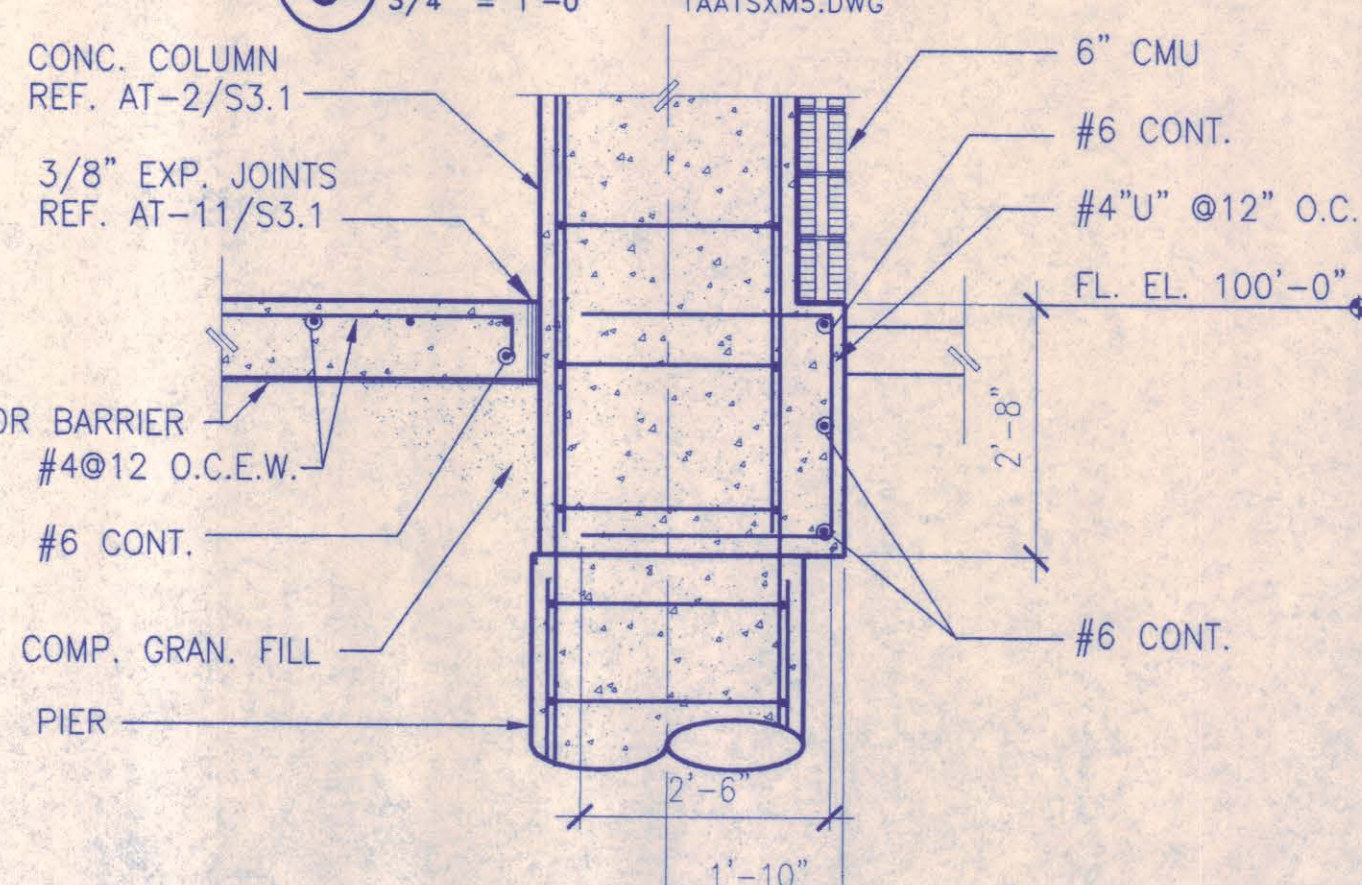


8 SECTION
1/2" = 1'-0" TAATSM6.DWG

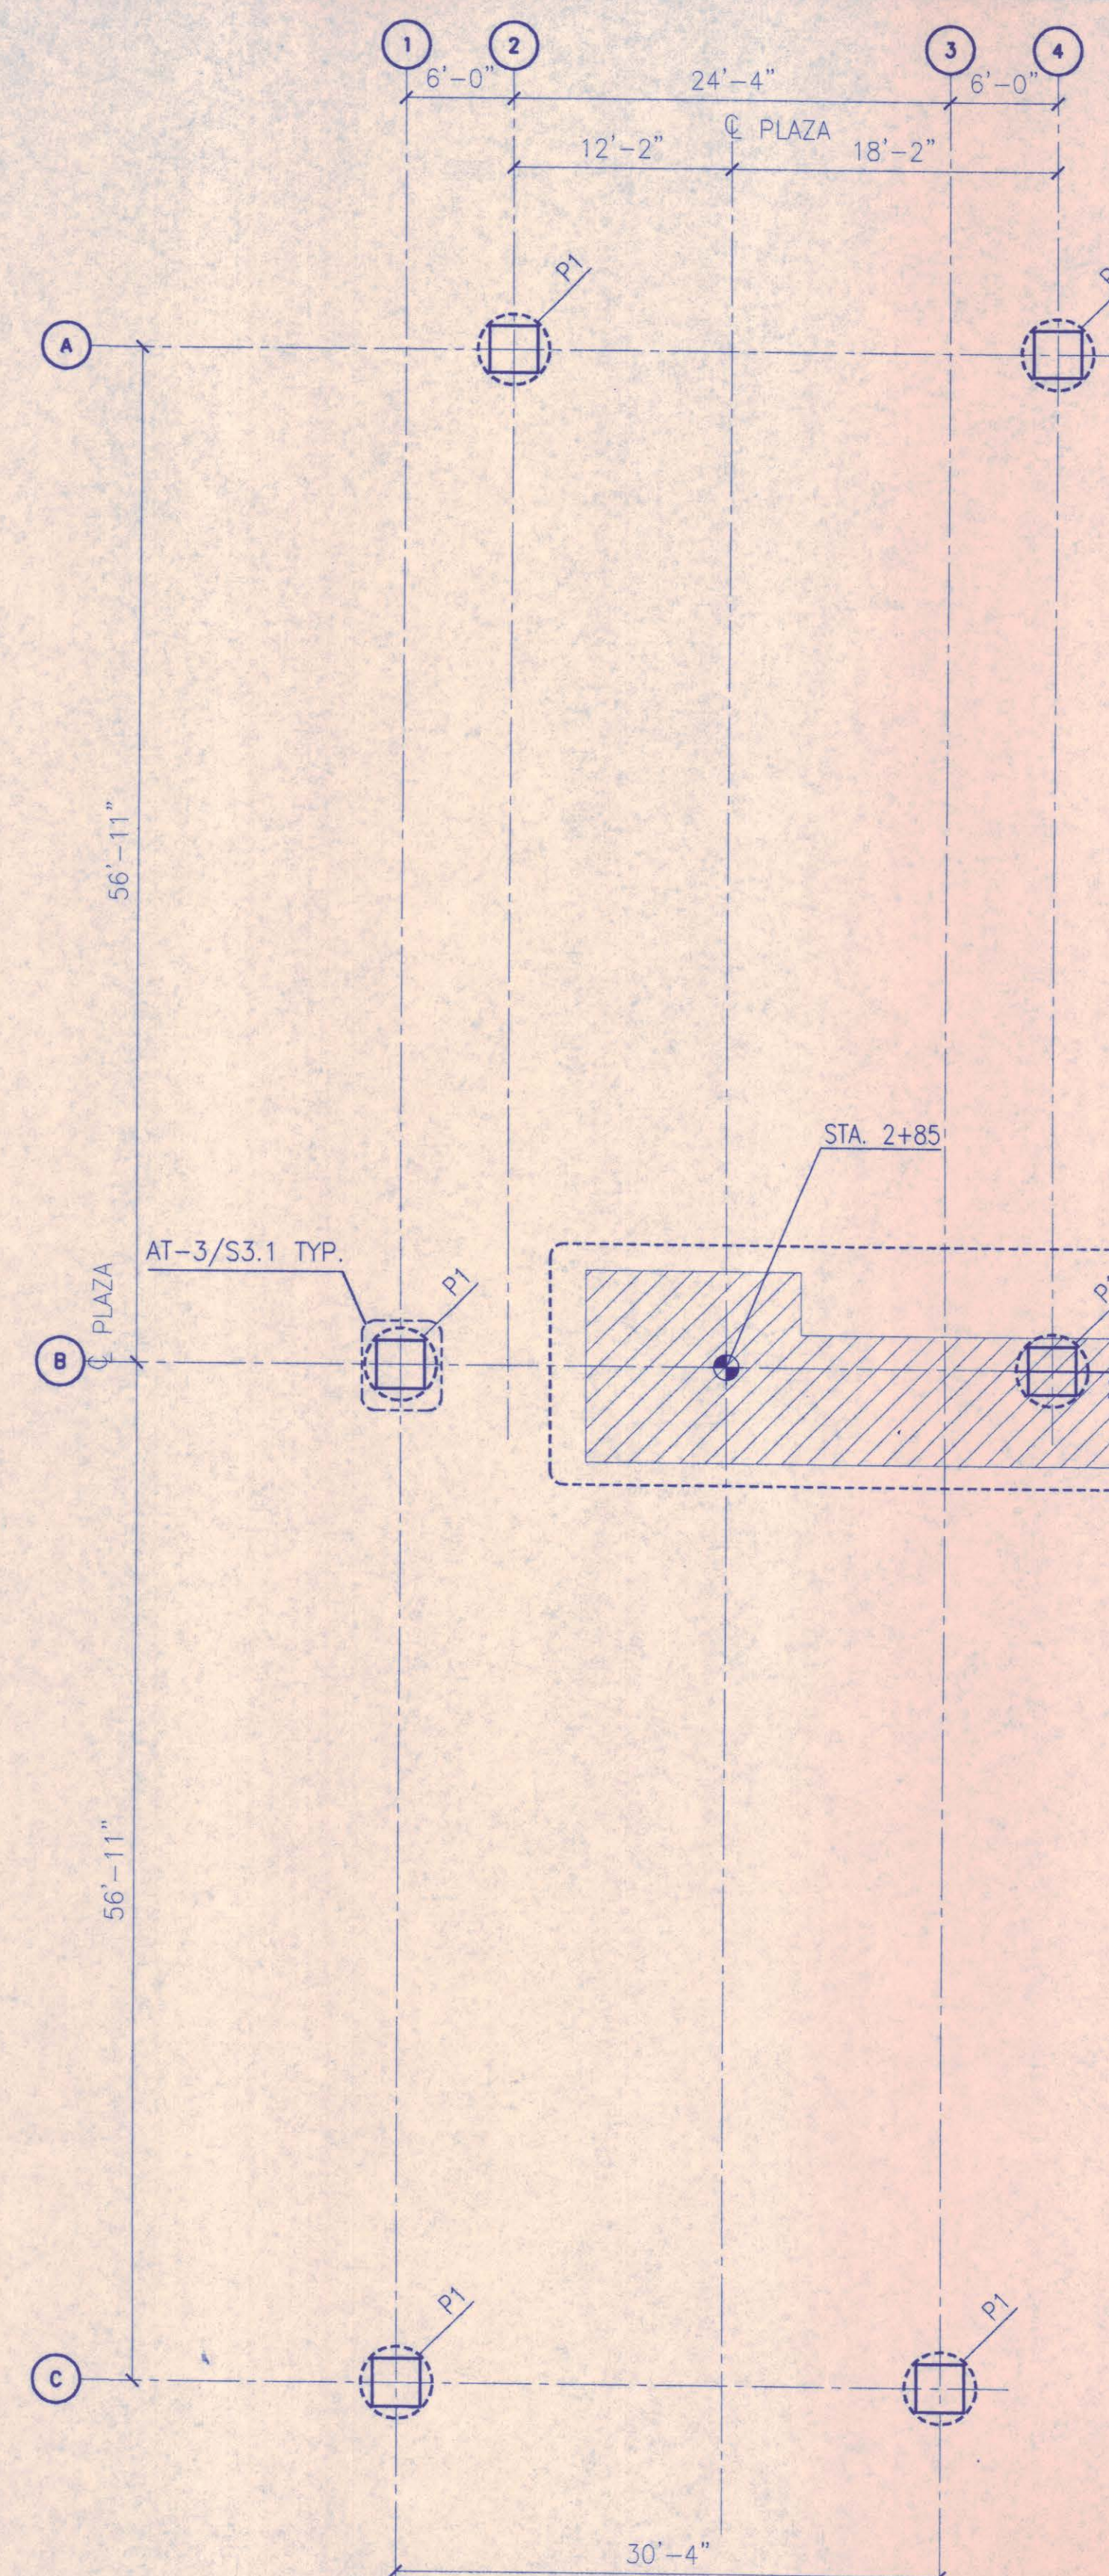

1 CANOPY FOUNDATION PLAN
1/8" = 1'-0" TAATSPF1.DWG


- PLAN NOTES:**
1. REFER DRAWING AT-S0.1 AND AT-S0.2 FOR GENERAL NOTES.
 2. 5" CONC. SLAB W/#4 @ 12" E.W. ON 8 MIL. VAPOR BARRIER ON COMPACTED GRANULAR FILL.
 3. ELEVATIONS ARE REFERENCED TO FINISHED FLOOR ELEVATIONS. (100'-0" = 634.33')
 4. "P1" INDICATES PIER MARK. REFER TO DRAWING AT-S3.1 FOR PIER SCHEDULE.
 5. "C.J." INDICATES SLAB CONTROL JOINT OR CONSTRUCTION JOINT. REF. AT-12/S3.1. TYPE OF JOINT USED IS CONTRACTOR'S OPTION.
 6. REF. CIVIL DRAWINGS FOR CENTERLINES OF PLAZA AND ROADWAY.

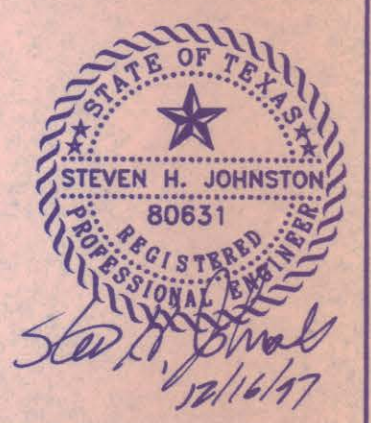


NO.	REVISION	BY	DATE

NORTH TEXAS TOLLWAY AUTHORITY	
ADDISON AIRPORT TUNNEL	
BARRIER TOLL PLAZA	
STRUCTURAL	
FOUNDATION	
PLANS AND DETAILS	
SECTION XIII	
AGUIRRE Corporation 5700 PARK CENTRAL DRIVE 15 TH FLOOR DALLAS TEXAS 75201 TEL. (972) 759-9509	
CHECKED <i>[Signature]</i> DATE 12/18/97	DESIGNED SHJ DATE 8/15/96
CHECKED <i>[Signature]</i> DATE 12/18/97	SCALE AS NOTED
CONTRACT NO. DNT-290 SHEET 36 OF 53	




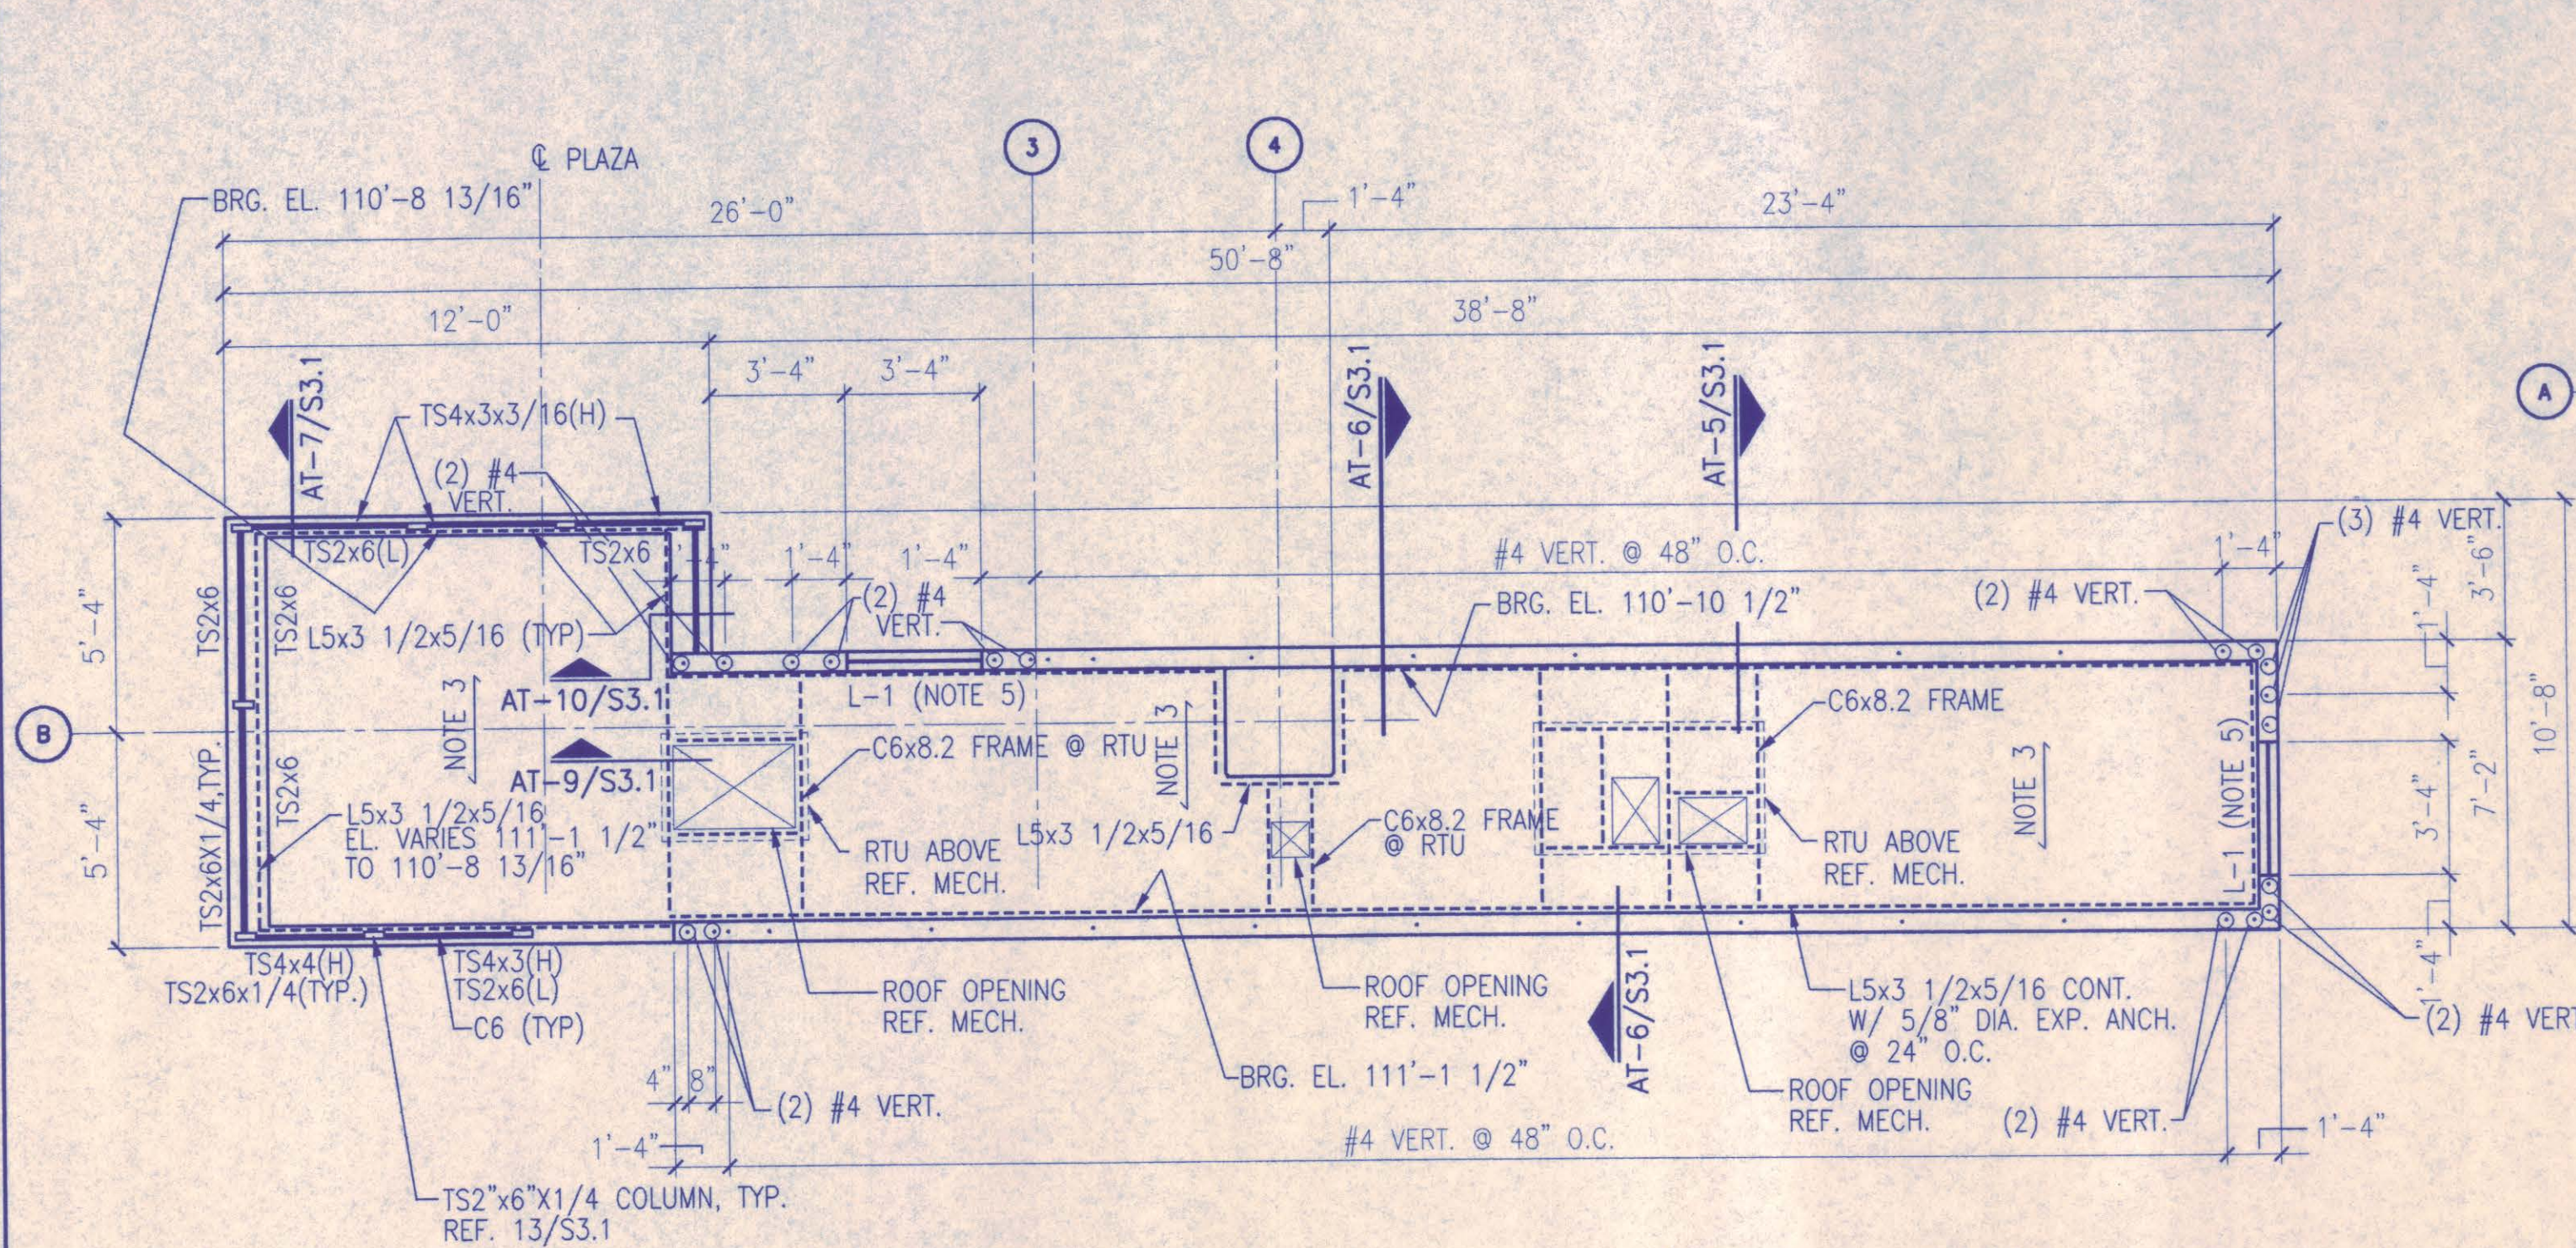

2 BOOTH/BUILDING ROOF FRAMING PLAN
1/4" = 1'-0" TAATSPR2.DWG

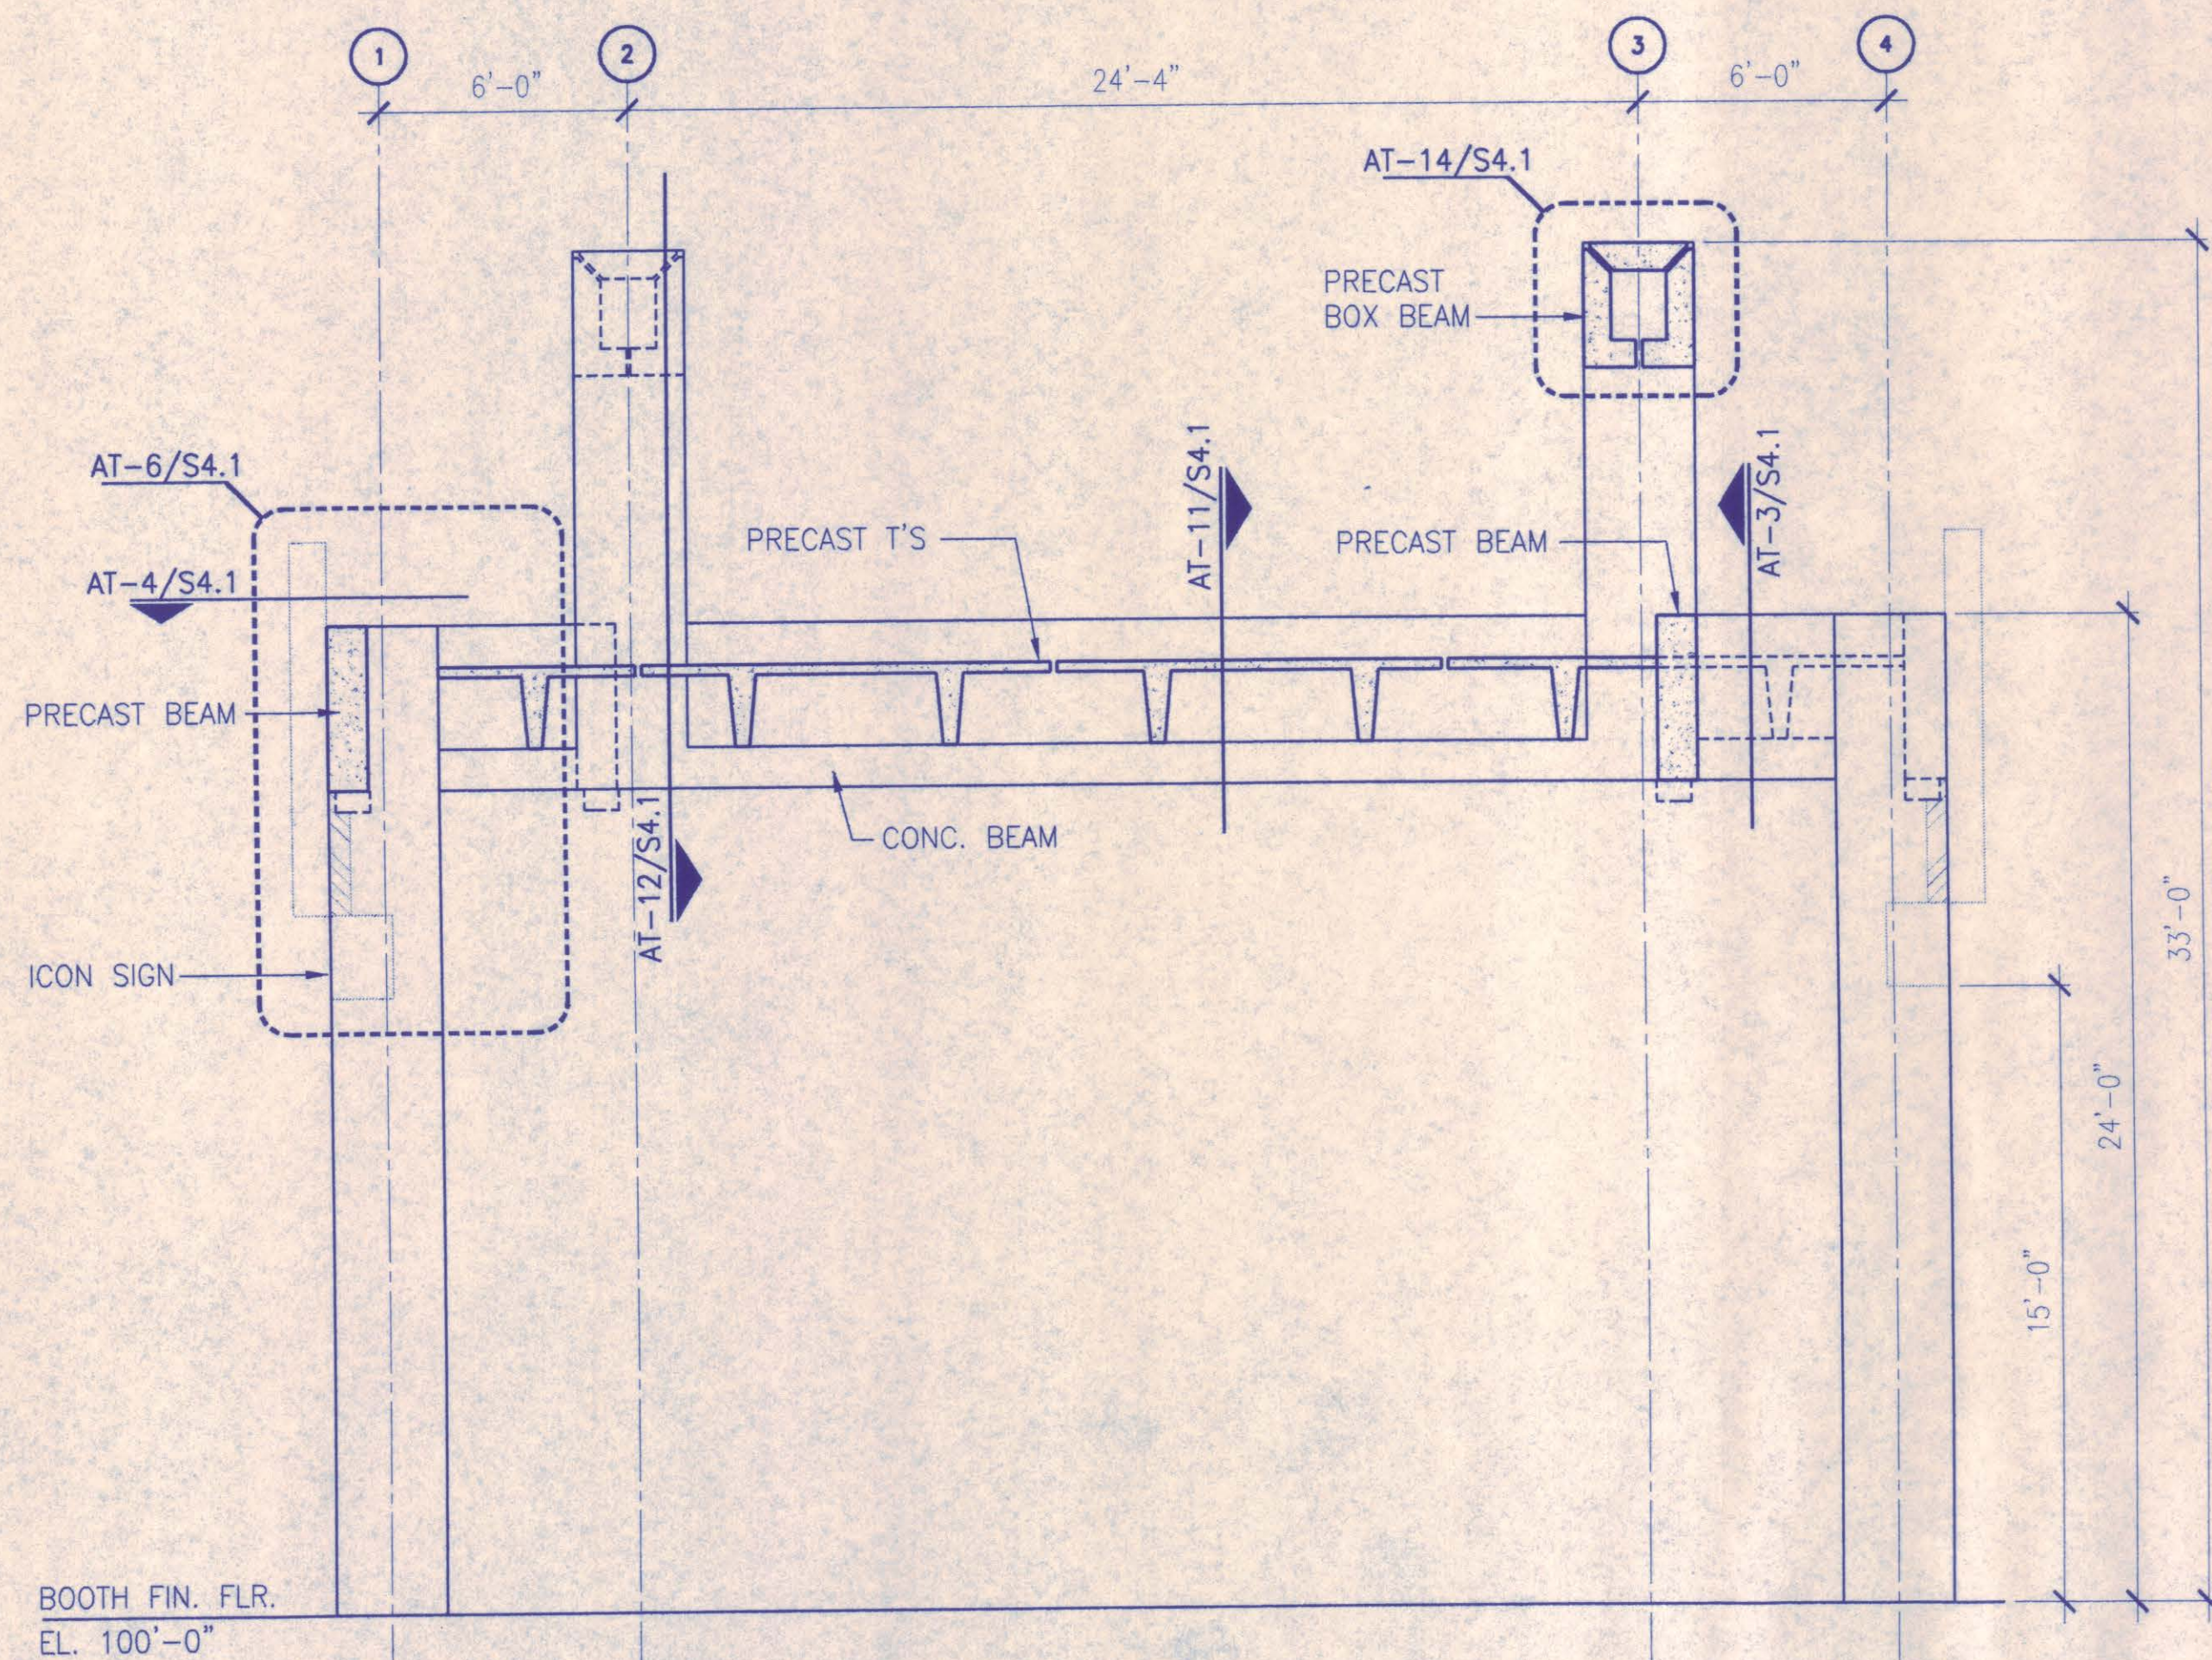


3 SECTION
1/4" = 1'-0" TAATSM4.DWG

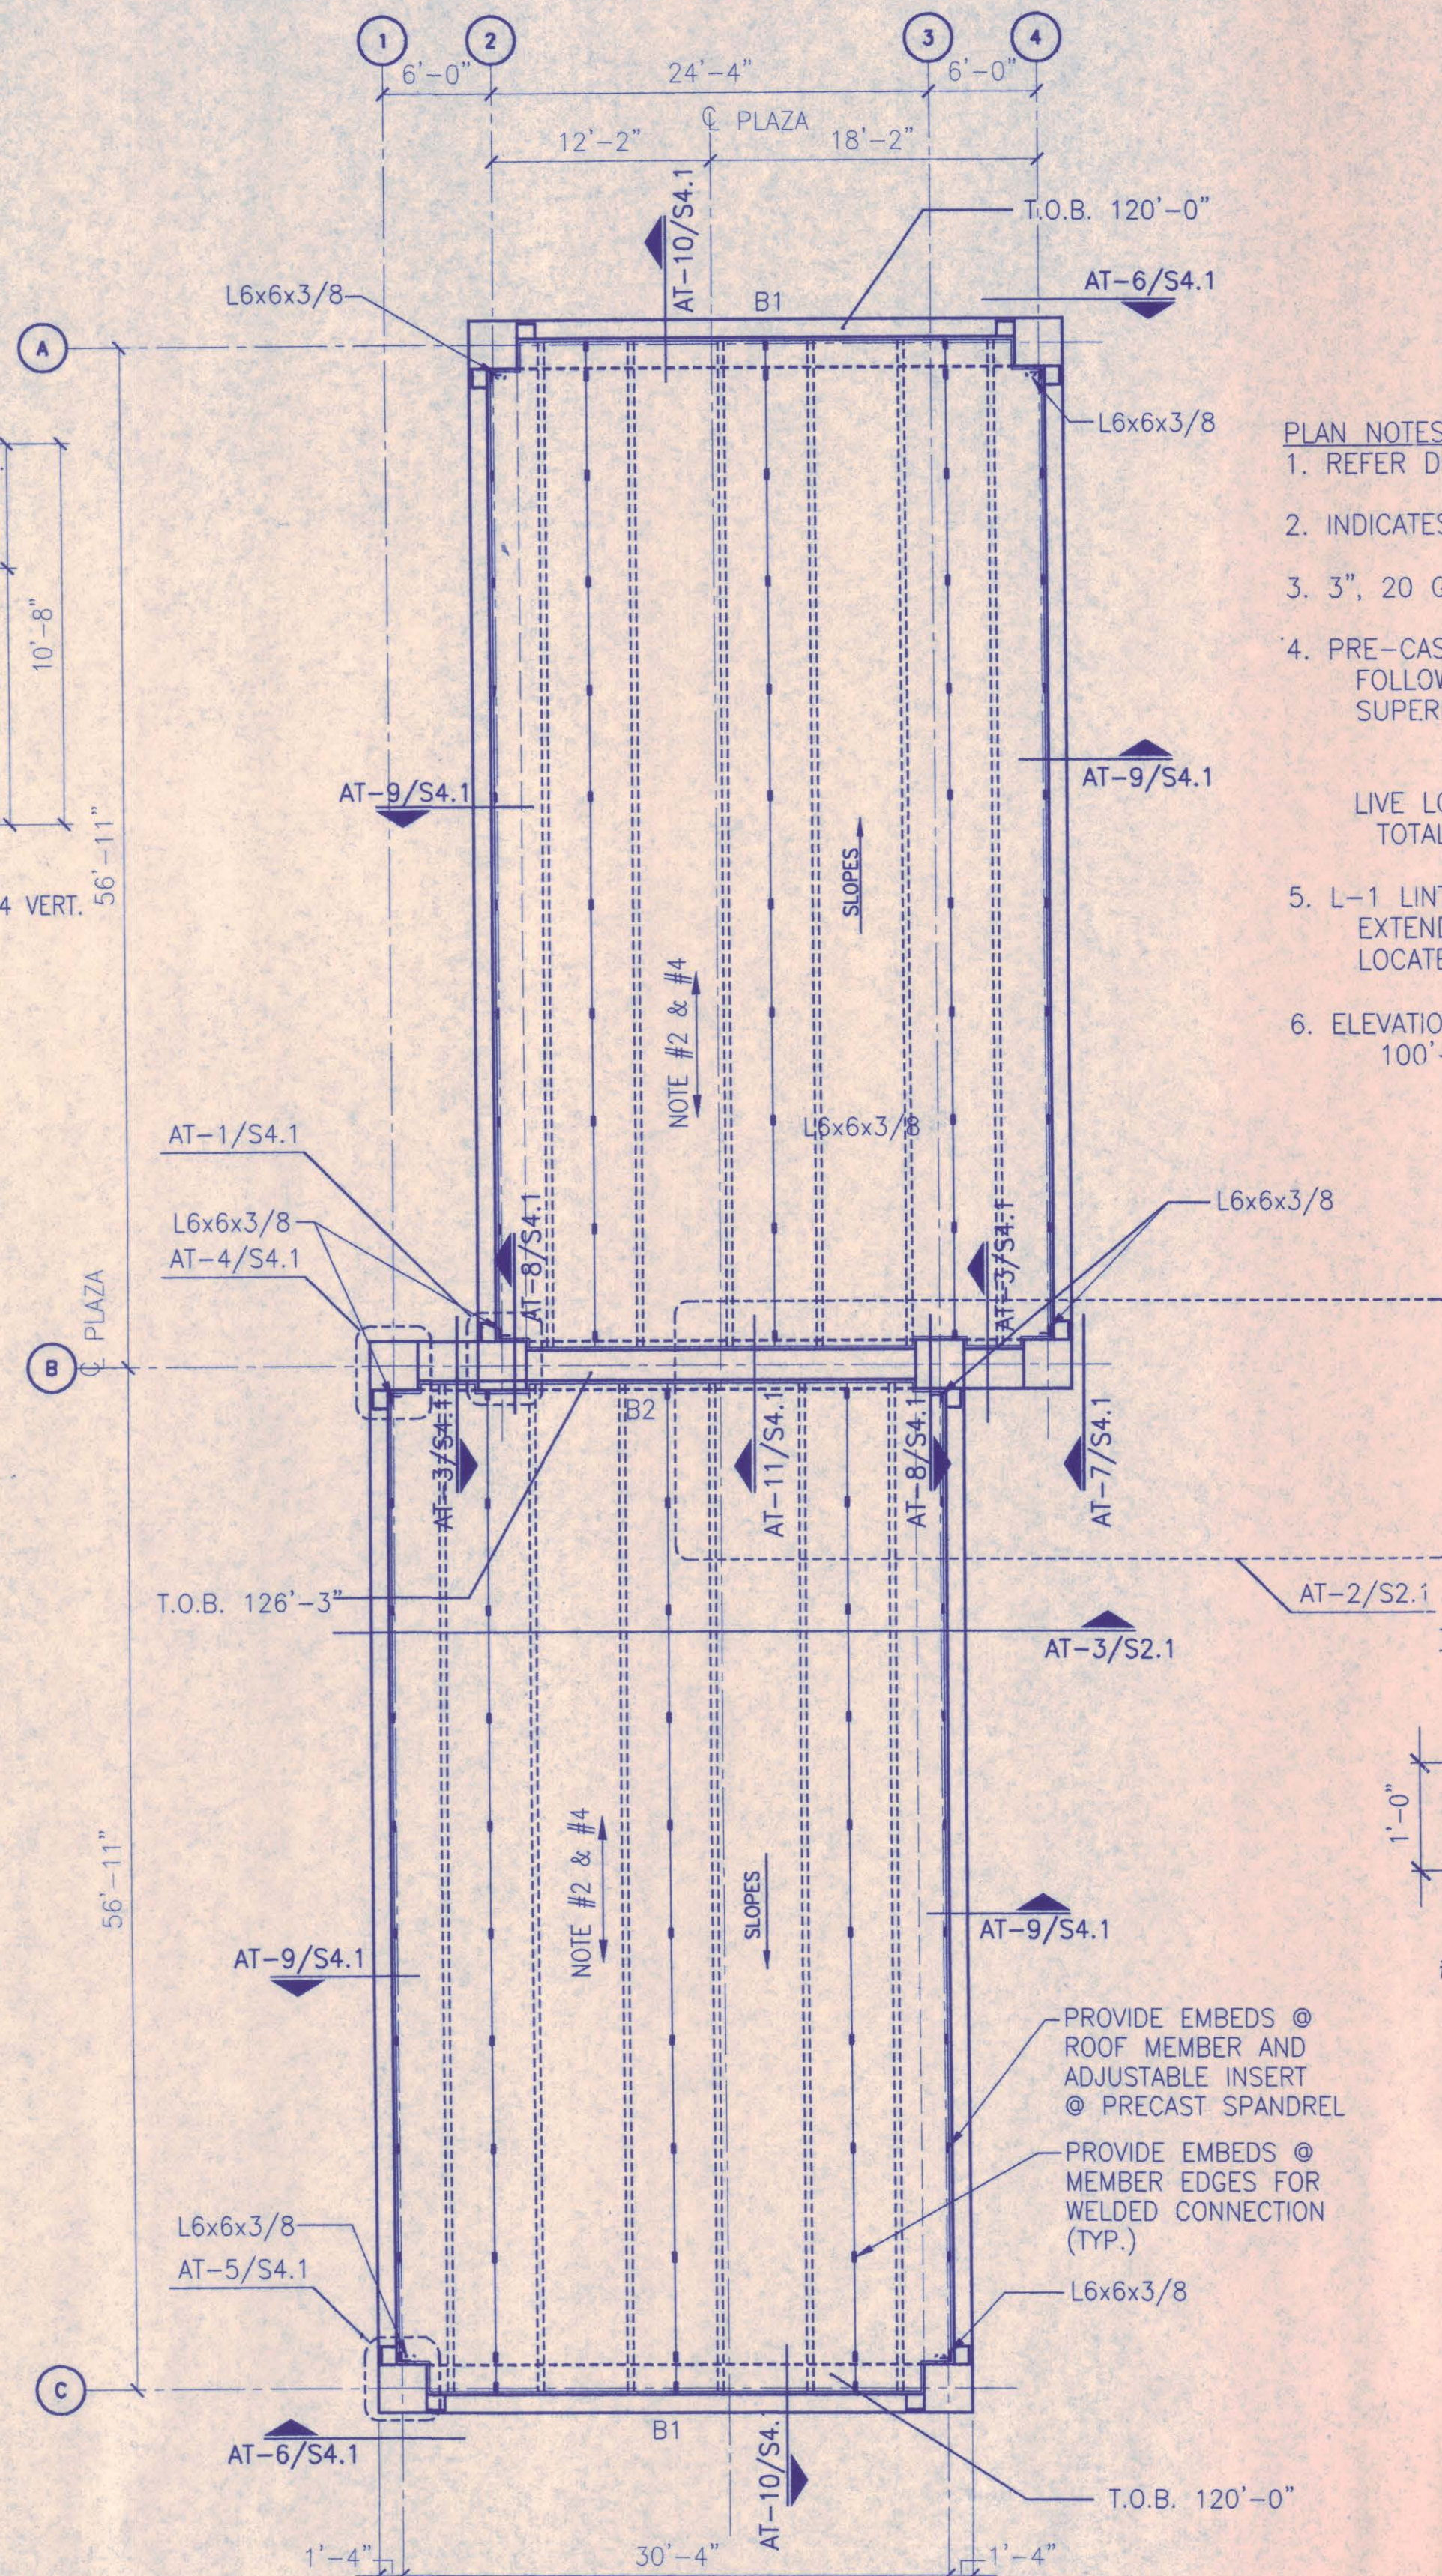

1 CANOPY ROOF FRAMING PLAN
1/8" = 1'-0" TAATSPR1.DWG

- PLAN NOTES:**
1. REFER DRAWINGS AT-S0.1 AND AT-S0.2 FOR GENERAL NOTES.
 2. INDICATES SPAN DIRECTION OF 24" PRECAST CONCRETE DOUBLE TEE.
 3. 3", 20 GA. GALVANIZED METAL ROOF DECK. ARROW INDICATES SPAN.
 4. PRE-CAST DOUBLE TEE'S SHALL BE DESIGNED TO SUPPORT THE FOLLOWING LOADS IN ADDITION TO THE WEIGHT OF THE PRE-CAST:

ROOFING AND INSULATION	10 psf
MECHANICAL	15 psf
LIVE LOAD	25 psf
TOTAL SUPERIMPOSED LOAD	20 psf
	45 psf
 5. L-1 LINTEL SHALL BE A 6" CMU LINTEL x 8" HIGH BLOCK W/1 - #5. EXTEND REINF 8" MIN. PAST OPENING @ EA. SIDE. GROUT LINTEL SOLID. LOCATE REINF 2" FROM BOTTOM EDGE OF CMU LINTEL.
 6. ELEVATIONS GIVEN ARE REFERENCED TO FINISHED FLOOR ELEVATION. 100'-0" (= 634.33')

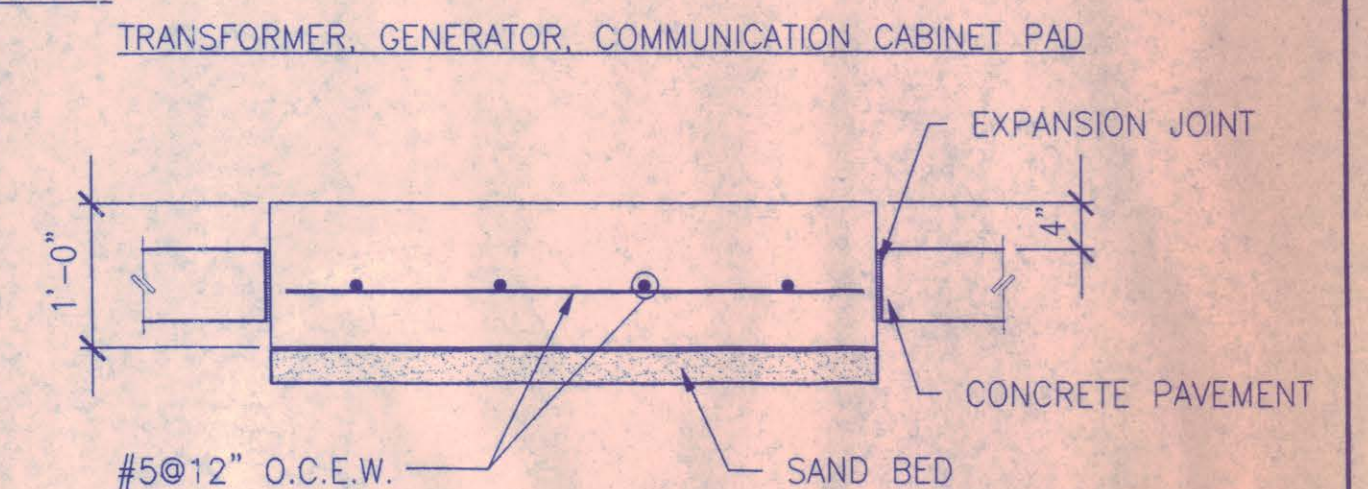


4 SECTION
3/4" = 1'-0" TAATSM13.DWG





NO.	REVISION	BY	DATE
NORTH TEXAS TOLLWAY AUTHORITY ADDISON AIRPORT TUNNEL BARRIER TOLL PLAZA			
STRUCTURAL FRAMING PLANS			
AGUIRRE Corporation 18700 PARK CENTRAL DRIVE 18 TH FLOOR DALLAS TEXAS 75261 TEL. 972 758-6006		SECTION XIII	
CHECKED <i>[Signature]</i>	DATE 12/18/97	DESIGNED SHJ	DATE 8/15/96
CHECKED <i>[Signature]</i>	DATE 12/18/97	SCALE AS NOTED	
CONTRACT NO. DNT-290		SHEET 37 OF 53	





AT S2.1

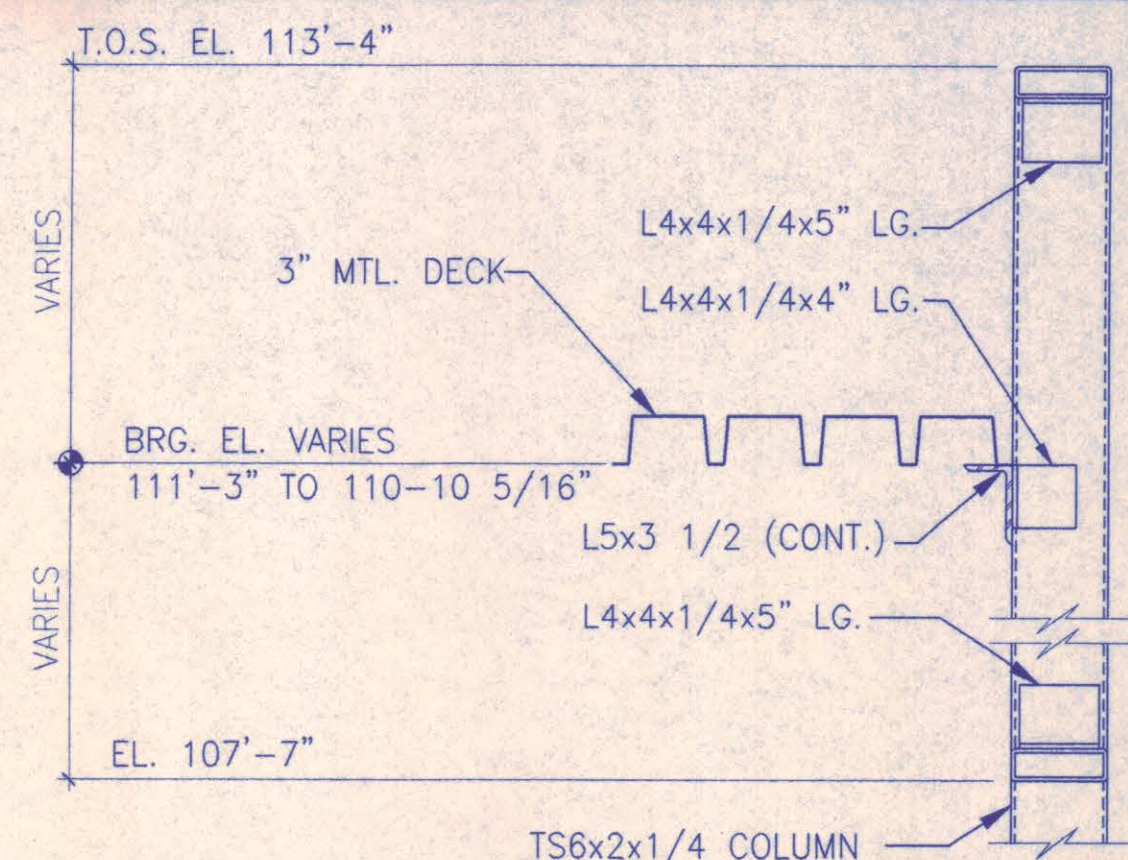


10 BOOTH COLUMN
1" = 1'-0"

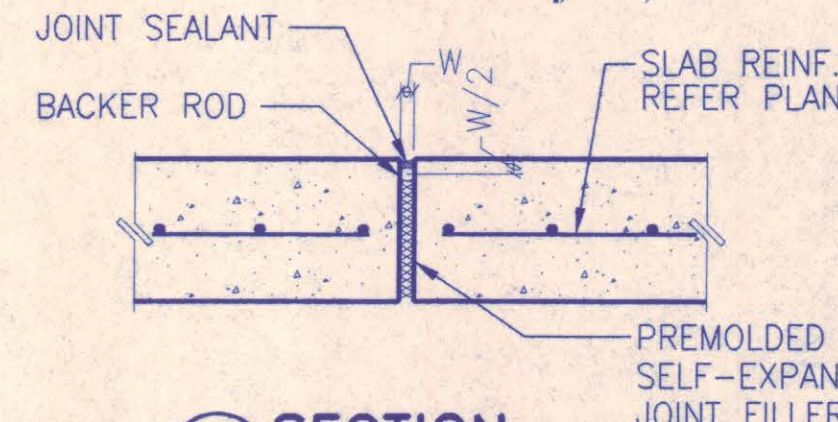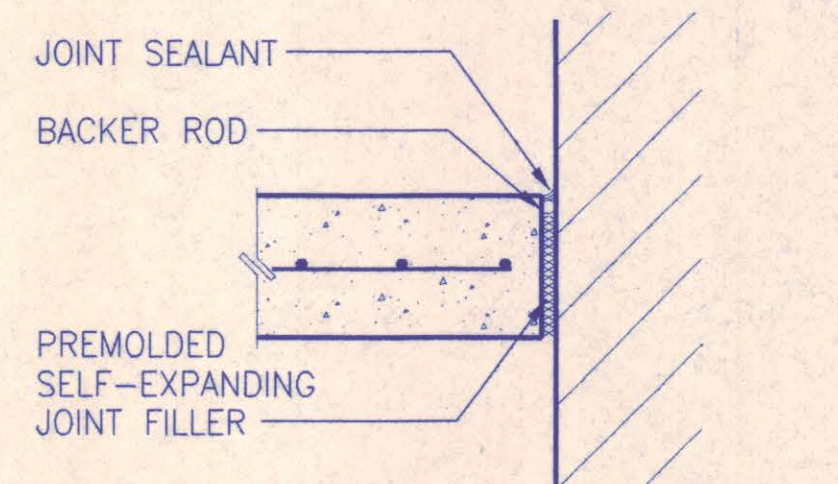


11 SECTION
N.T.S.

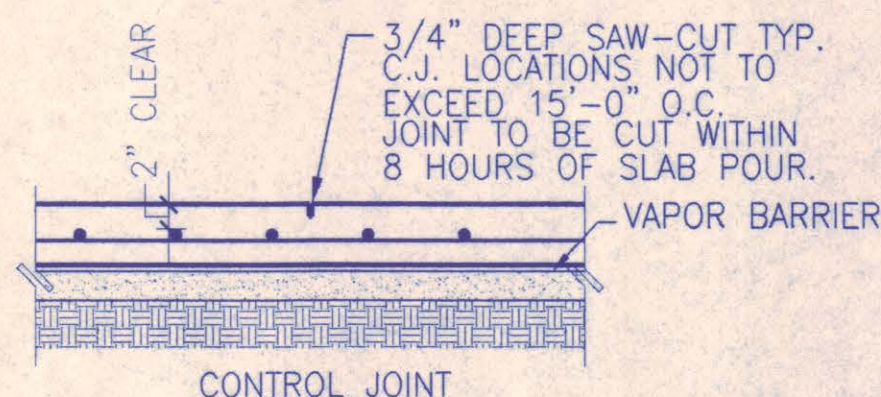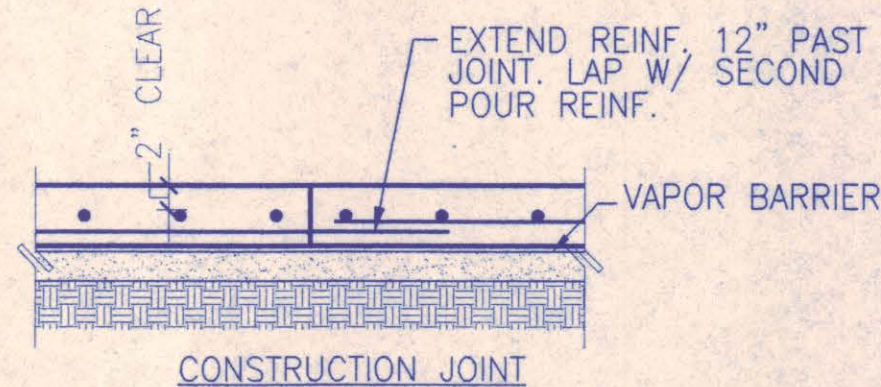


12 SECTION
N.T.S.

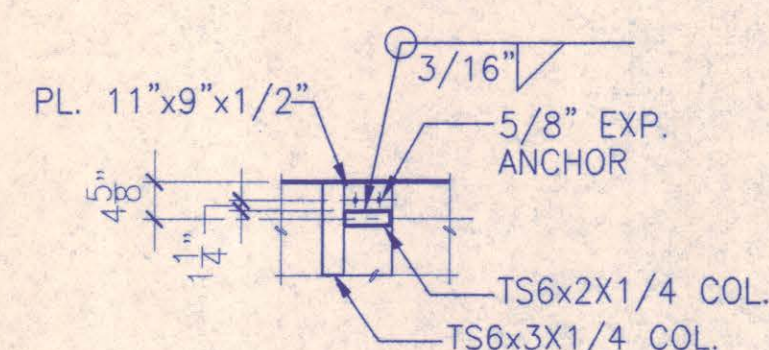


13 SECTION
N.T.S.

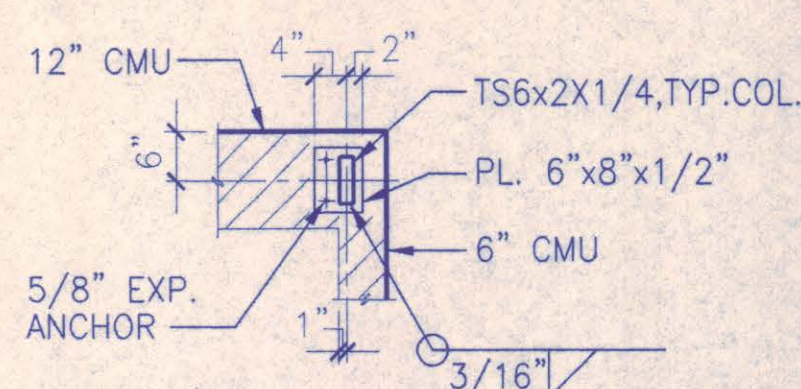

14 SECTION
N.T.S.

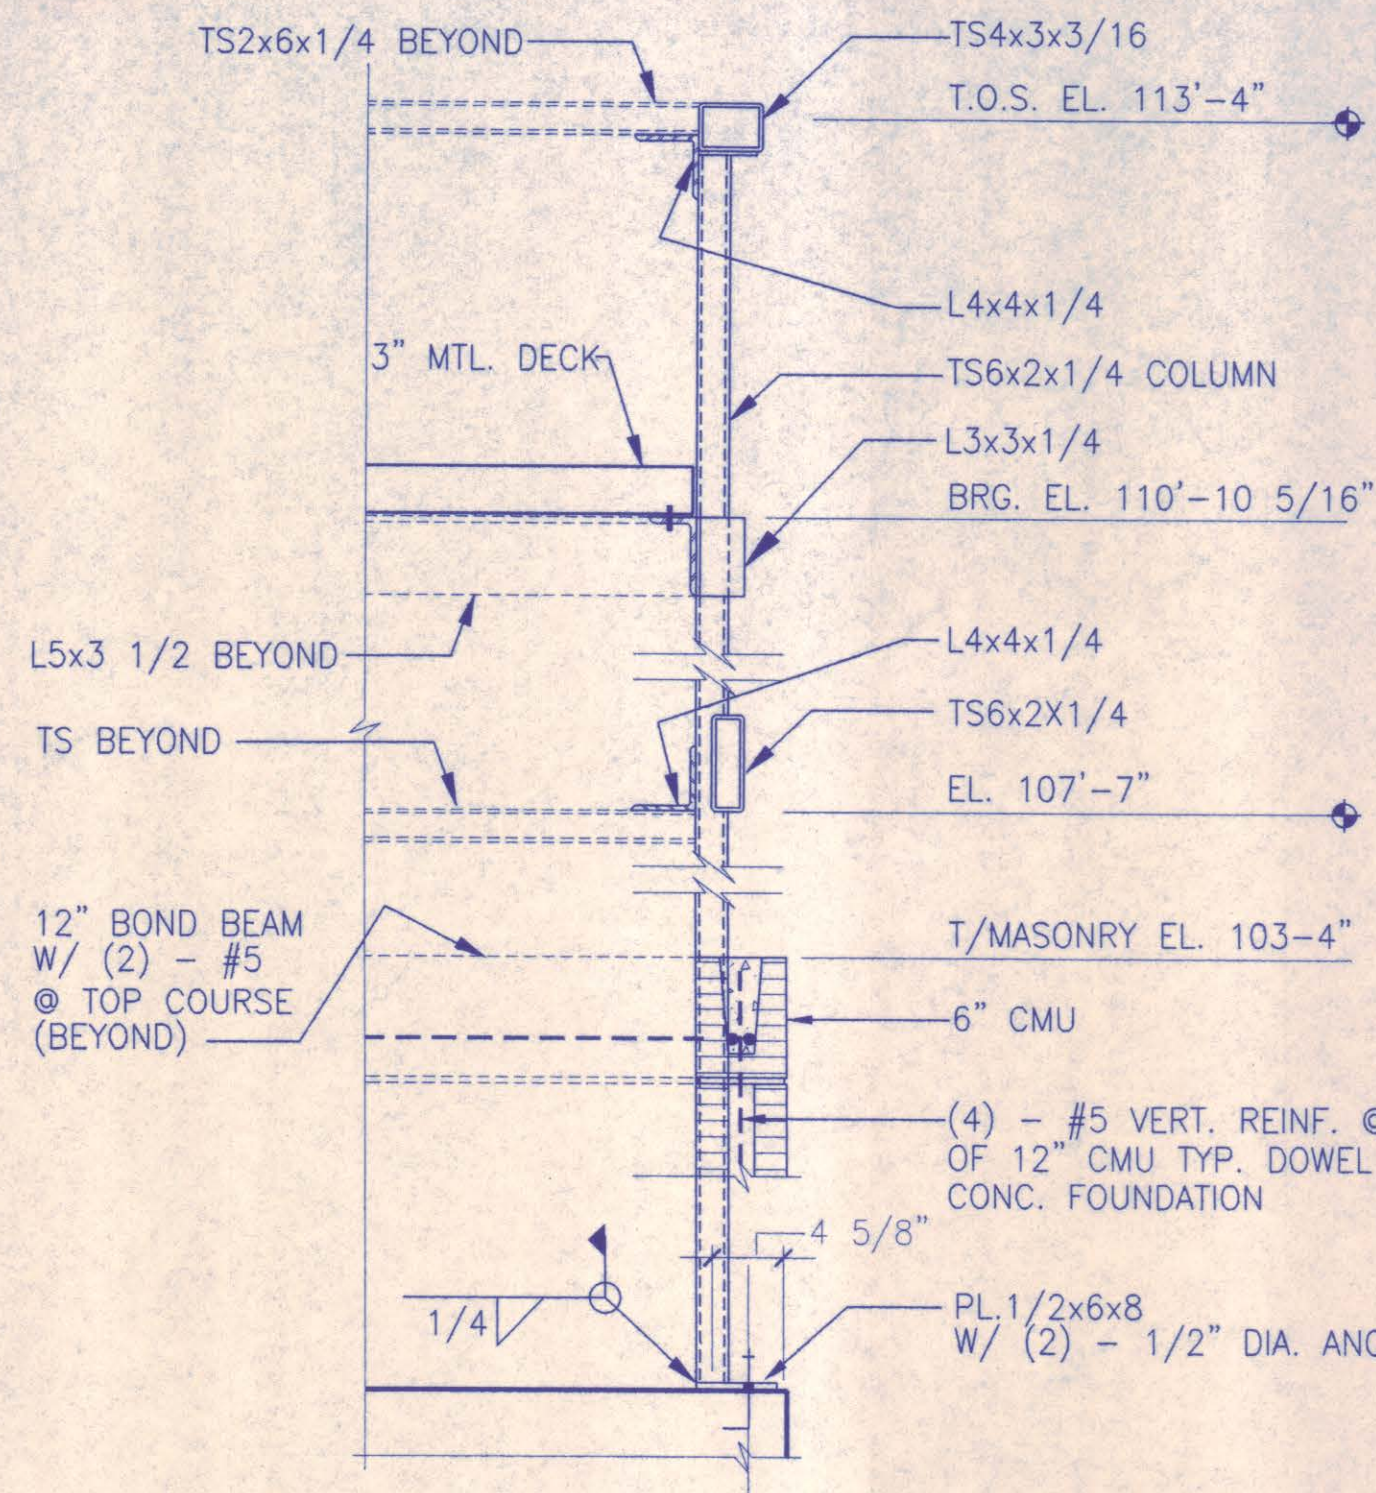


7 COLUMN AT CORNER OF BOOTH
1" = 1'-0"

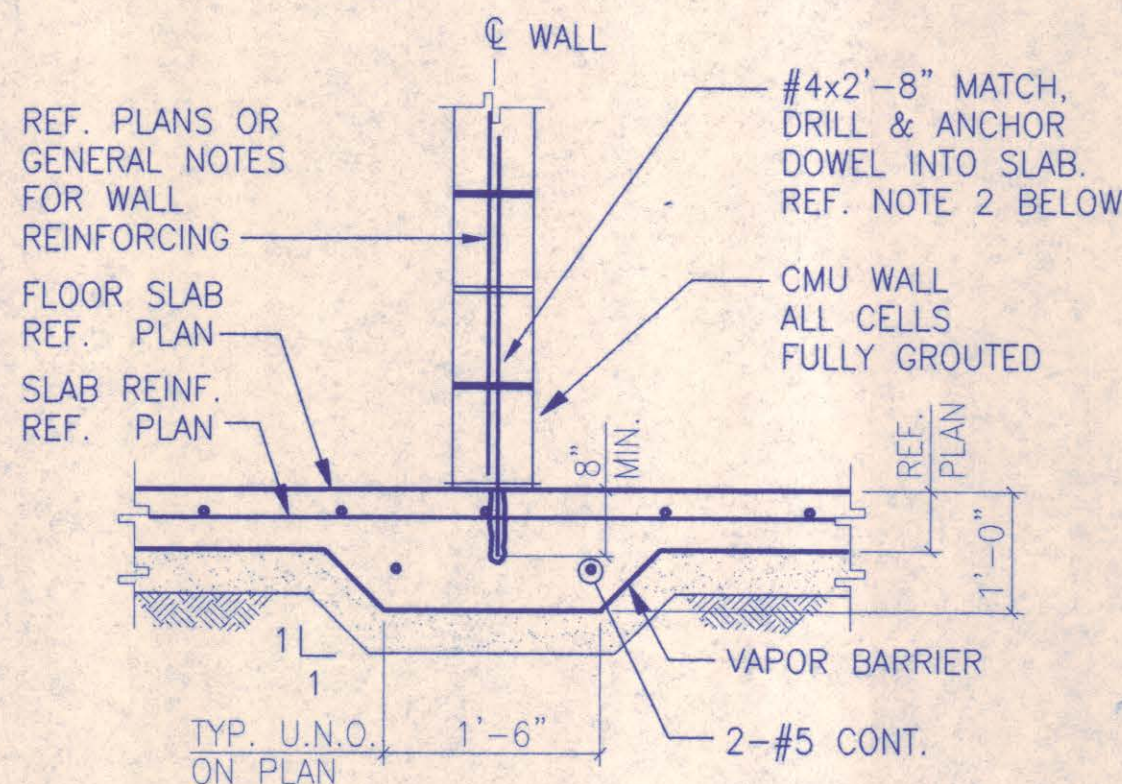


NOTES

- REF. ARCHITECTURAL DRAWINGS FOR CMU WALL LOCATIONS AND DIMENSIONS.
- VERTICAL WALL REINFORCING FOR CMU WALL SHALL BE ANCHORED INTO THE FLOOR SLAB USING THE HILTI C-100 CHEMICAL ANCHORING SYSTEM OR APPROVED EQUAL.


8 SECTION
N.T.S.

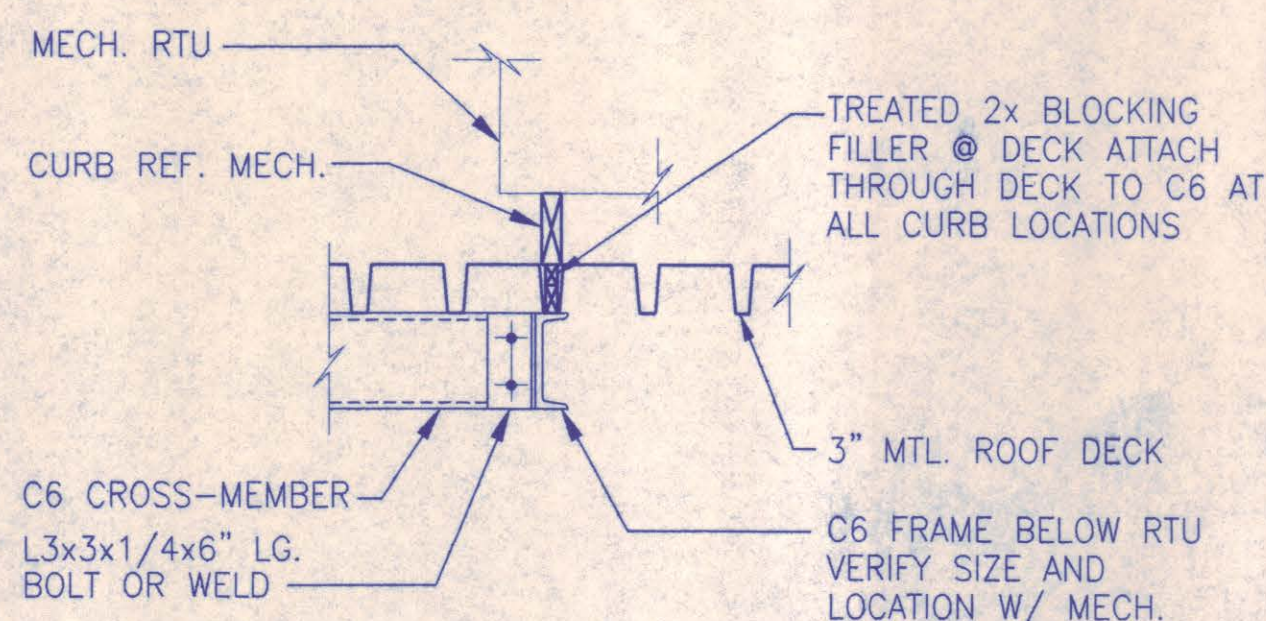


9 SECTION
1" = 1'-0"

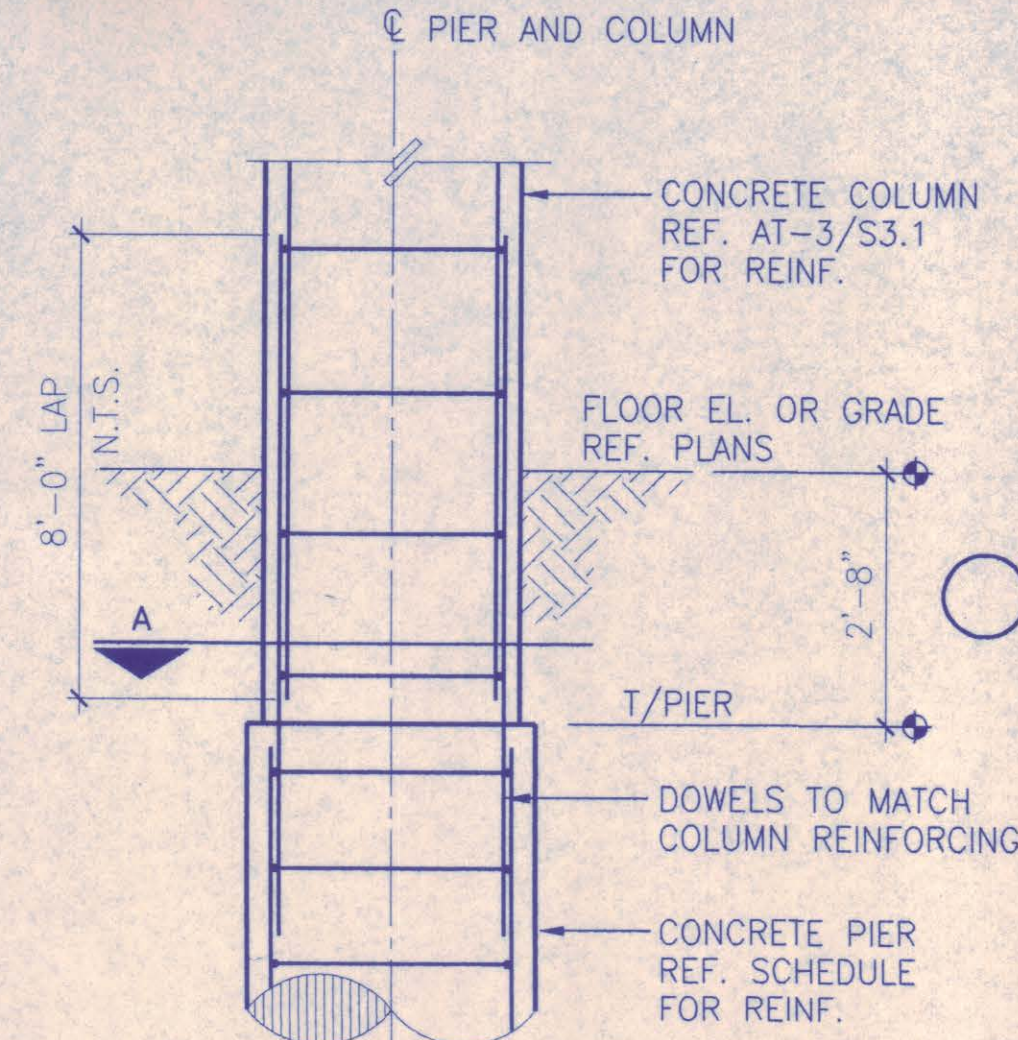

2 PIER AND COL. DETAIL
1/2" = 1'-0"

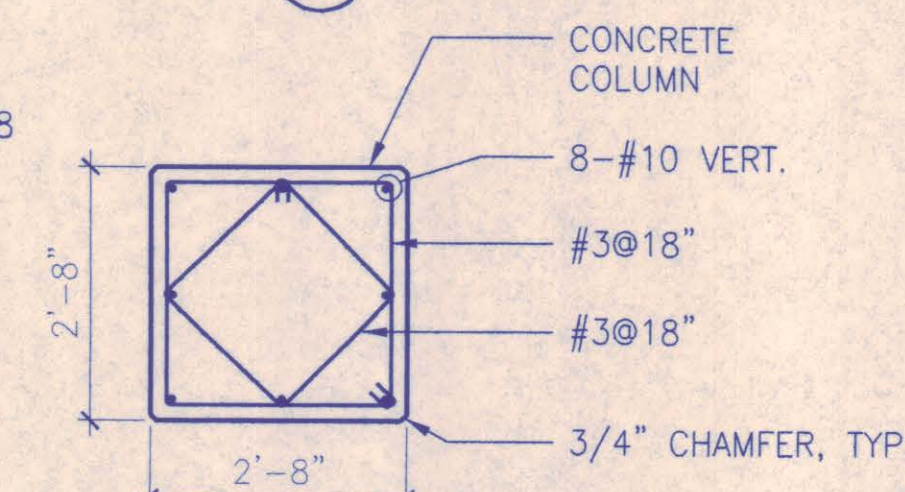


COLUMNS A-2, A-4, C-1, C-3, B-2, B-3

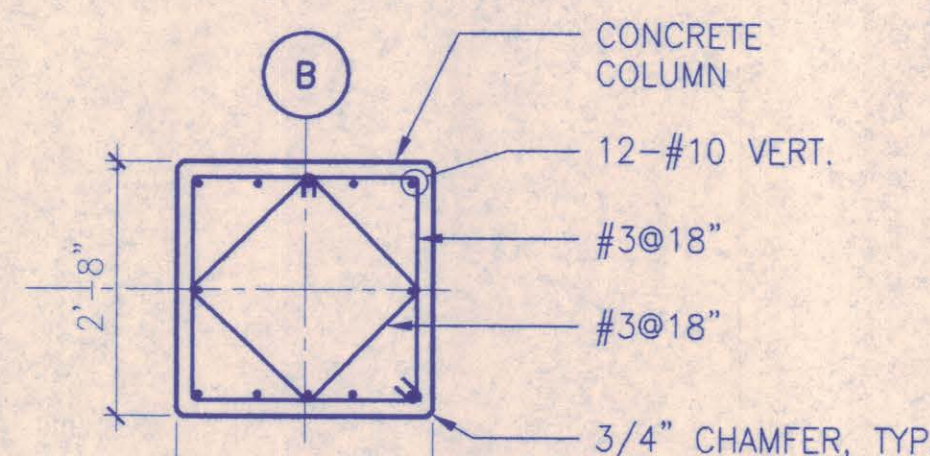


COLUMNS B-1, B-4


3 COLUMN DETAILS
N.T.S.

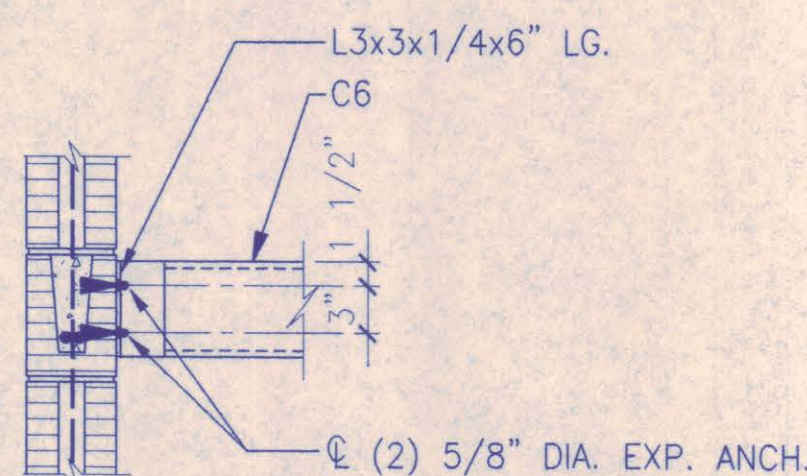


5 SECTION
1" = 1'-0"

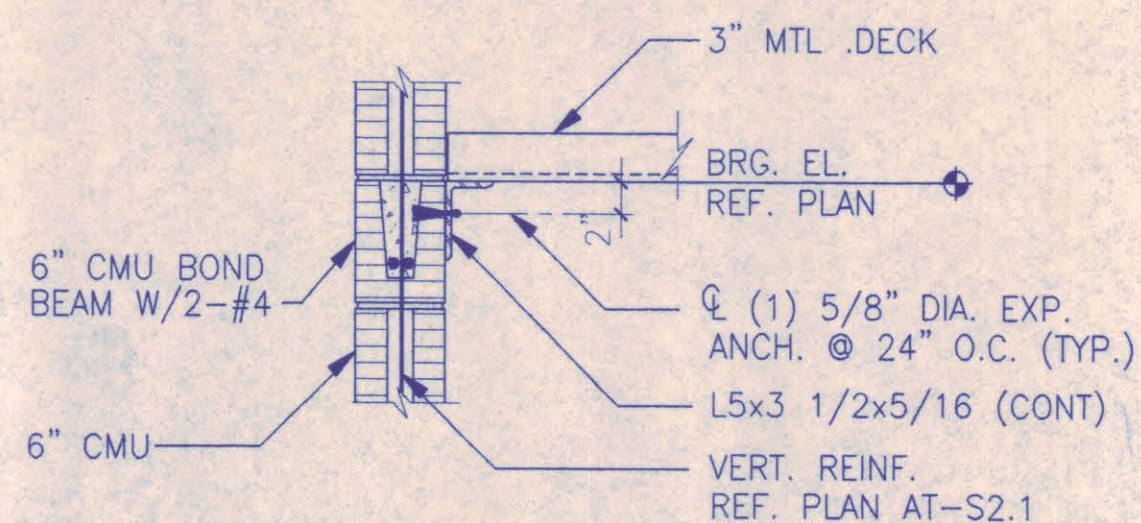

6 SECTION
1" = 1'-0"

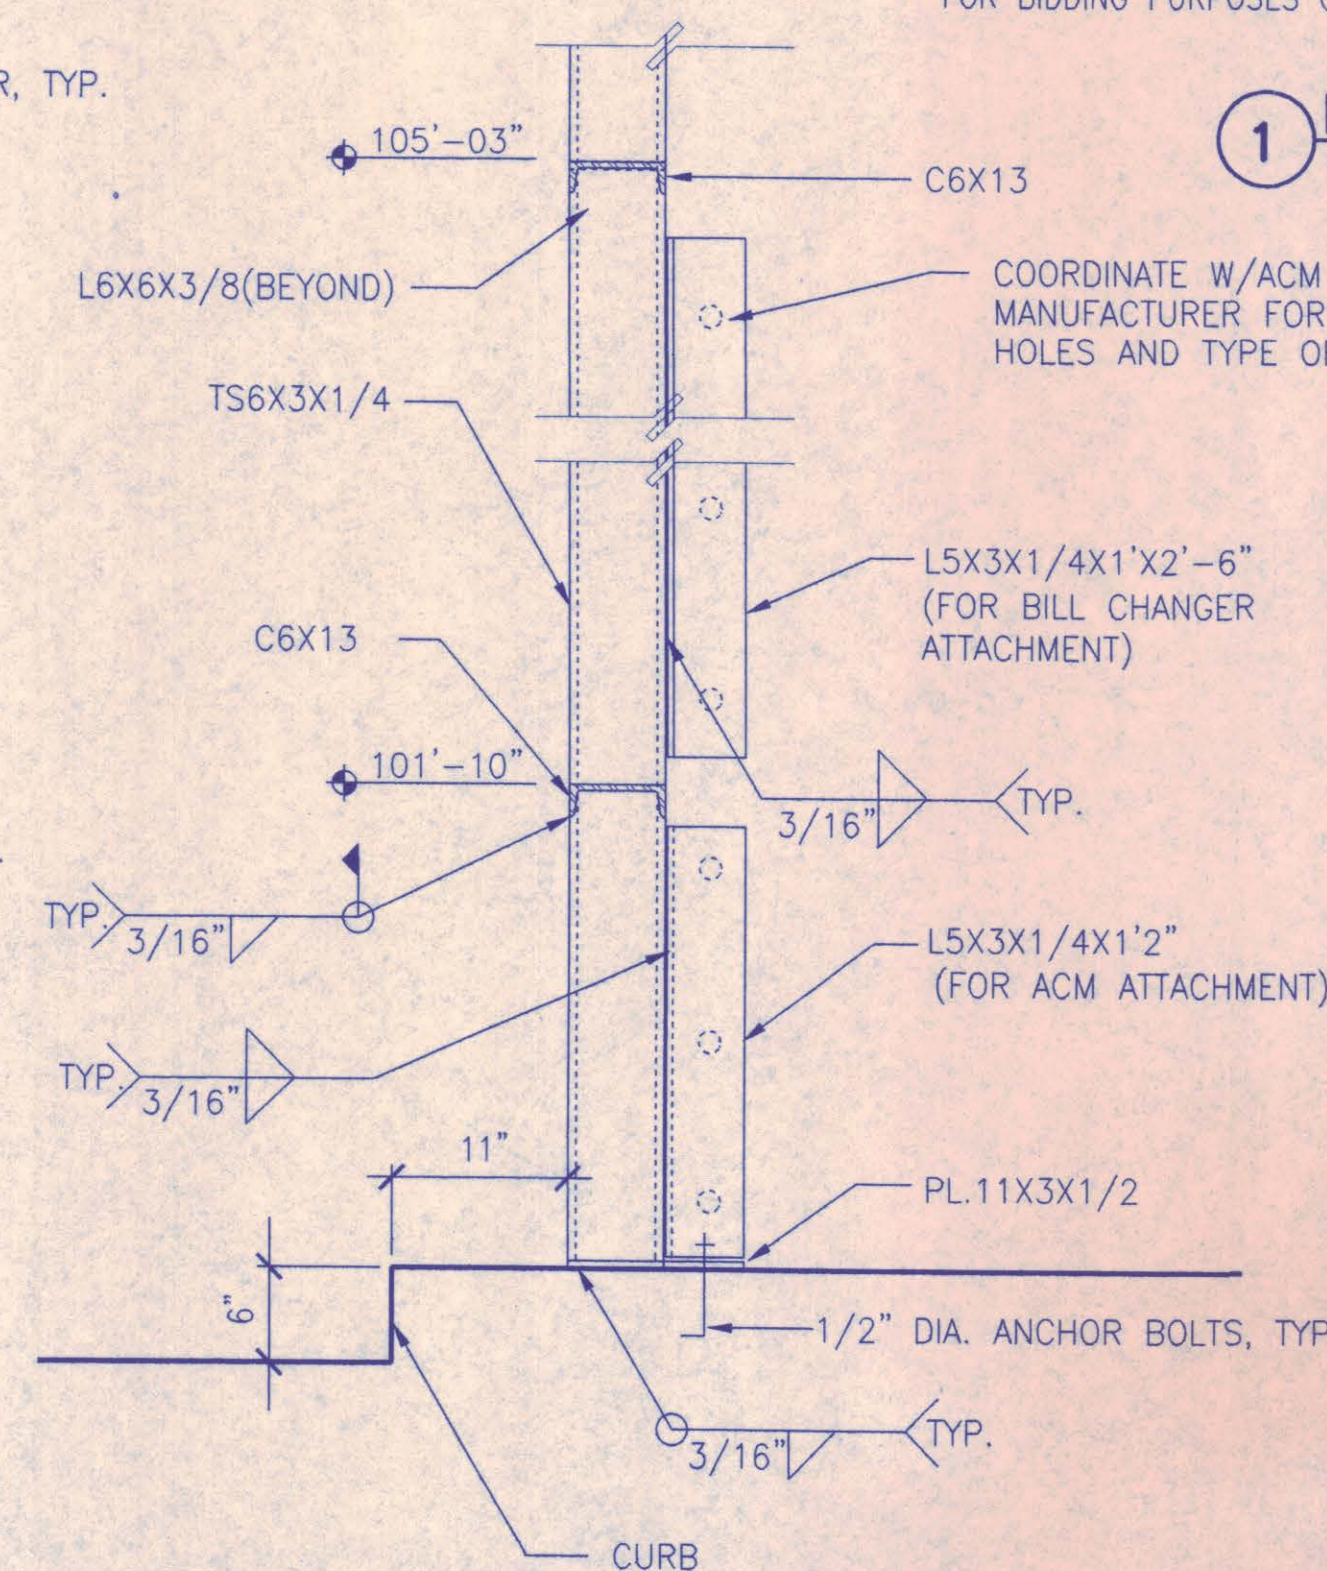

15 SECTION
1" = 1'-0"

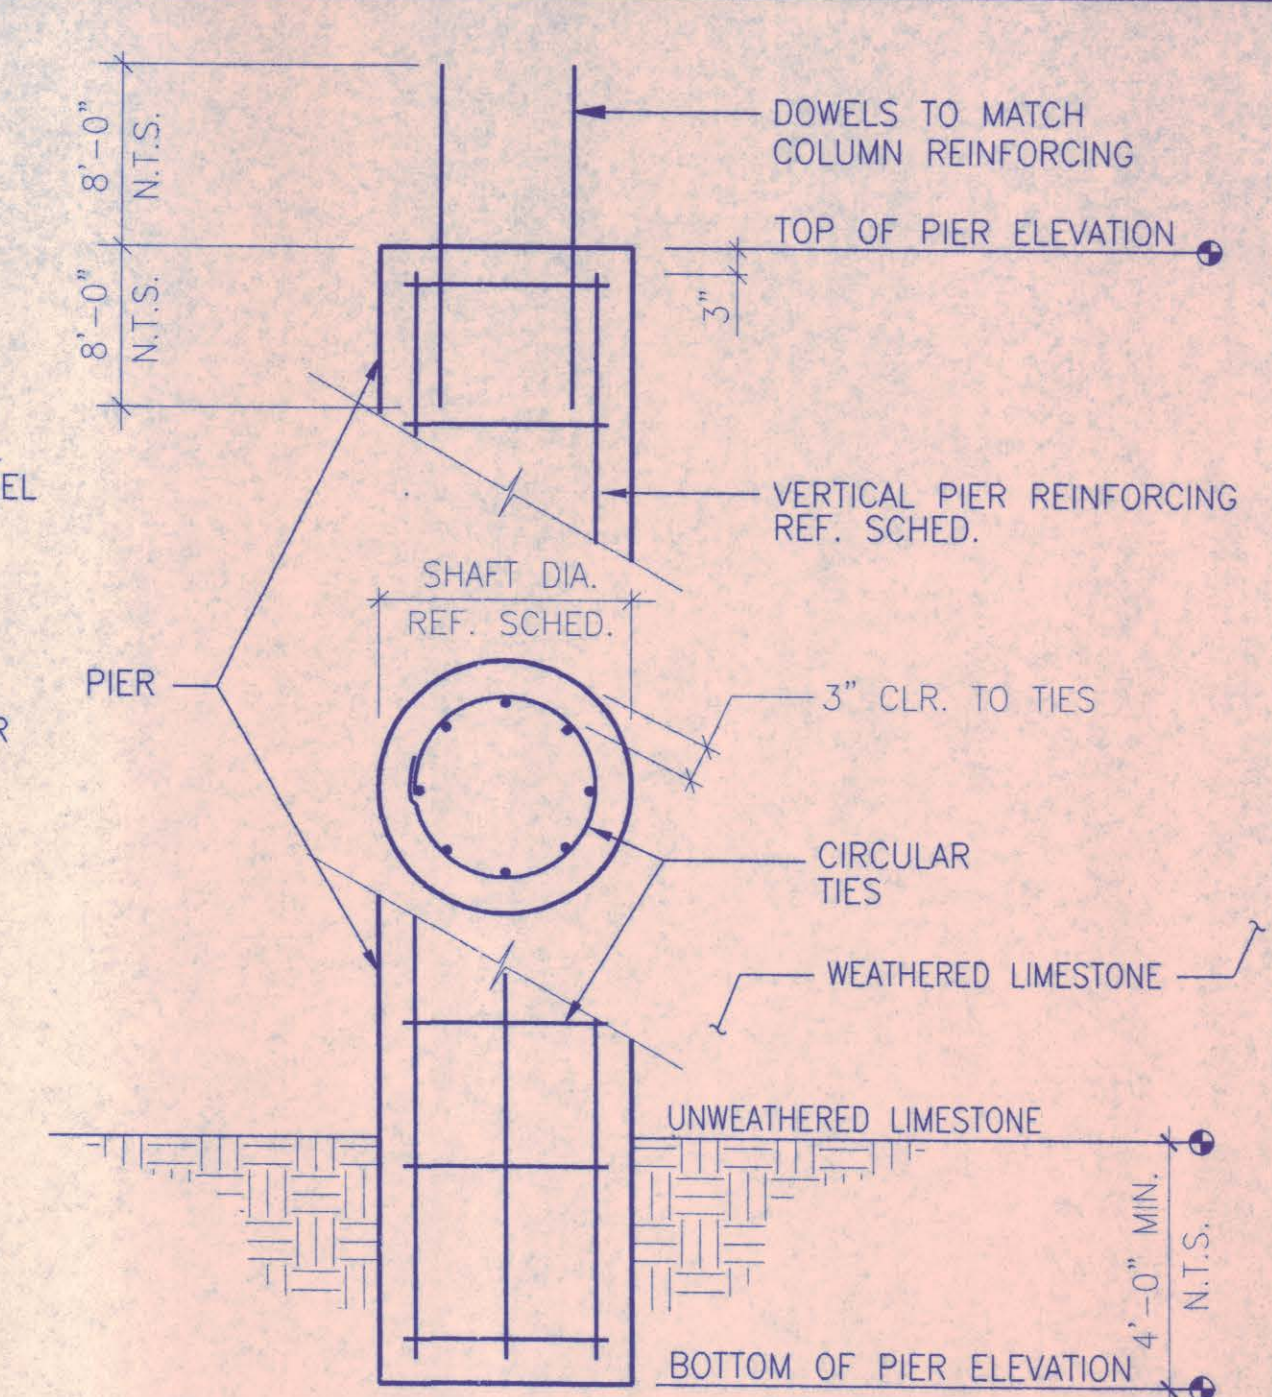

PIER NOTES:

- USE 4" TO 6" SLUMP CONCRETE AND 3/4" AGGREGATE TO FACILITATE CONCRETE PLACEMENT, VIBRATE ONLY TOP 5' OF PIER.
- TOP AND BOTTOM OF PIER ELEVATIONS GIVEN ARE FOR BIDDING PURPOSES ONLY.

PIER SCHEDULE

MARK	SHAFT DIA. (IN.)	REINFORCING		TOP OF PIER ELEVATION (FT.)	BOTTOM OF PIER ELEVATION (FT.) *
		VERT.	CIRCULAR TIES		
P1	48"	12-#10	#4@18"	97'-4"	80'-0"+/-

* FOR BIDDING PURPOSES ONLY.

1 PIER DETAIL
NONE



NO.	REVISION	BY	DATE
NORTH TEXAS TOLLWAY AUTHORITY ADDISON AIRPORT TUNNEL BARRIER TOLL PLAZA			
STRUCTURAL SECTIONS AND DETAILS			
AGUILERA Corporation 5700 PARK CENTRAL DRIVE 15 TH FLOOR DALLAS TEXAS 75201 TEL. (972) 780-9000			
SECTION XIII			
CHECKED <i>[Signature]</i>	DATE 12/18/97	DESIGNED SHJ	DATE 8/15/96
CHECKED <i>[Signature]</i>	DATE 12/18/97	SCALE 1/2" = 1'-0"	
CONTRACT NO. DNT-290		SHEET 38 OF 53	

AT S3.1

10 SECTION SCALE: $1/2" = 1'-0"$

7 SECTION
SCALE: 1/2" = 1'-0"


4 PLAN DETAIL

SCALE: $1/2" = 1'-0"$

1 PLAN DETAIL

BEAM SCHEDULE			
MARK	DETAIL	STIRRUPS	
		TYPE	SPACING @ EA. END
B1		A	1 @ 3", R @ 12"
B2		B/B'	1 @ 3", R @ 6"

NOTE: SEE DETAIL FOR DIMENSIONS OF BEAM

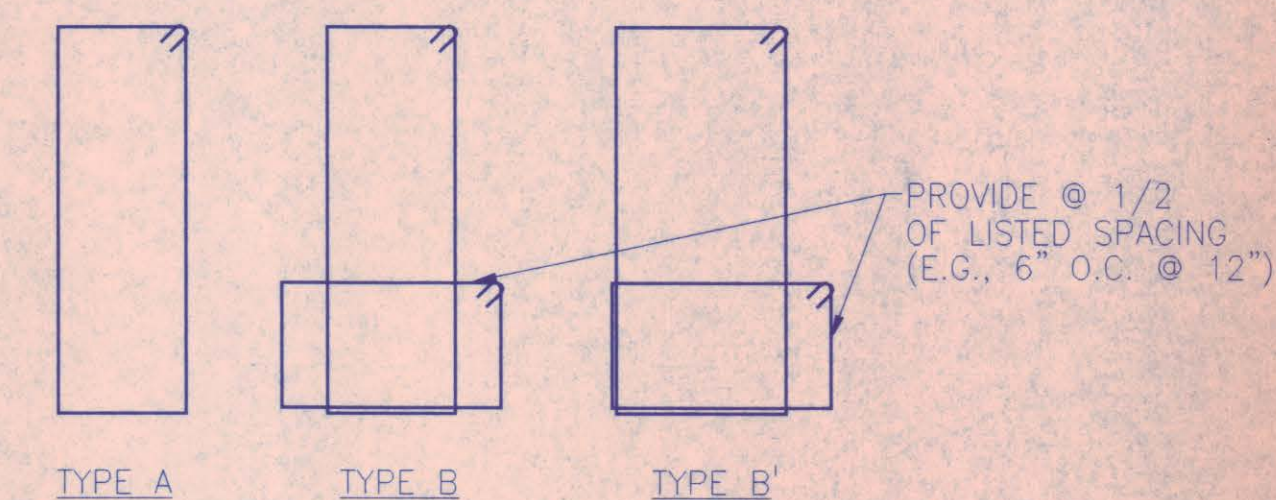

11 SECTION
SCALE: $1/2" = 1'-0"$

8 SECTION
SCALE: 1/2" = 1'-0"

5 PLAN DETAIL
SCALE: 1/2" = 1'-0"

2 CONCRETE CORBEL DETAIL

14 BOX BEAM DETAIL
SCALE: $1/2" = 1'-0"$

15 **INSERT DETAIL**
SCALE: 1 1/2" = 1'-0"



12 SECTION
SCALE: $1/2" = 1'-0"$

9 SECTION
SCALE: 1/2" = 1'-0"

6 SECTION
SCALE: $1/2" = 1'-0"$

3 SECTION
SCALE: $1/2" = 1'-0"$

AT S4.1

NO.	REVISION	BY	DATE
NORTH TEXAS TOLLWAY AUTHORITY ADDISON AIRPORT TUNNEL BARRIER TOLL PLAZA			
STRUCTURAL			
SECTIONS AND DETAILS			
 AGURRI Corporation 12700 PARK CENTRAL DRIVE 45 TH FLOOR DALLAS TEXAS 75281 TEL. (972) 788-1008			SECTION XIII
CHECKED <u>SP</u>	DATE <u>12/18/97</u>	DESIGNED <u>SHJ</u>	DATE <u>8/15/96</u>
CHECKED <u>SP</u>	DATE <u>12/18/97</u>	SCALE <u>1/2" = 1'-0"</u>	
CONTRACT NO. <u>DNT-290</u>		SHEET <u>39</u> OF <u>53</u>	

MECHANICAL SYMBOLS

ALL SYMBOLS SHOWN MAY NOT APPEAR IN ALL DRAWINGS.
SYMBOLS ARE SHOWN SCHEMATICALLY AND MAY NOT BE TO SCALE.

SYMBOL	DESCRIPTION	SYMBOL	DESCRIPTION
	NEW EQUIPMENT		HIGH PRESSURE STEAM
	EXISTING EQUIPMENT		LOW PRESSURE STEAM
	EXISTING EQUIPMENT TO BE REMOVED OR RELOCATED		LOW PRESSURE CONDENSATE
	NEW DUCT		OVERFLOW DRAIN LINE
	EXISTING DUCT		DIRECTION OF SLOPE
	EXISTING DUCT TO BE REMOVED OR RELOCATED		DIRECTION OF FLOW
	NEW SUPPLY DIFFUSER, SQUARE NECK		EXPANSION LOOP
	EXISTING SUPPLY DIFFUSER TO BE REMOVED OR RELOCATED		AUTOMATIC 2-WAY CONTROL VALVE
	NEW R/A OR EXHAUST GRILLE		AUTOMATIC 3-WAY CONTROL VALVE
	EXISTING R/A OR EXHAUST GRILLE		PLUG VALVE/BALANCING COCK
	EXISTING R/A OR EXHAUST GRILLE TO BE REMOVED OR RELOCATED		SOLENOID VALVE
	NEW SLOT DIFFUSER		GATE VALVE
	FLEXIBLE DUCT		BUTTERFLY VALVE
	EXISTING SLOT DIFFUSER		BALL VALVE
	EXISTING SLOT DIFFUSER TO BE REMOVED OR RELOCATED		GLOBE VALVE
	SUPPLY DUCT RISER		CHECK VALVE
	RETURN, EXHAUST OR OUTSIDE AIR DUCT RISER		TEMPERATURE AND PRESSURE RELIEF VALVE
	SIDEWALL SUPPLY GRILLE OR REGISTER WITH AIR EXTRACTOR		BUTTERFLY VALVE MOTORIZED
	THERMOSTAT		HYDRAULIC SHOCK ARRESTOR
	EXISTING THERMOSTAT TO BE REMOVED OR RELOCATED		VALVE IN VERTICAL
	45° PRESSURE TAP W/ VOLUME DAMPER		UNION
	CONICAL TAP WITH VOLUME DAMPER		P-TRAP
	MANUAL VOLUME DAMPER		FLOOR DRAIN W/ P-TRAP
	FIRE DAMPER		HUB DRAIN
	MOTORIZED DAMPER		FLOOR CLEANOUT OR GRADE CLEANOUT
	SMOKE DAMPER		CLEANOUT OR WALL CLEANOUT
	COMBINATION FIRE & SMOKE DAMPER		TWO WAY CLEANOUT
	CHILLED WATER SUPPLY PIPE		PETE'S PLUG
	CHILLED WATER RETURN PIPE		GAUGE COCK
	HEATING OR CHILLED WATER SUPPLY PIPE		THERMOMETER
	HEATING OR CHILLED WATER RETURN PIPE		THERMOMETER WELL
	CONDENSER WATER SUPPLY PIPE		STRAINER WITH BLOW-DOWN VALVE
	CONDENSER WATER RETURN PIPE		PRESSURE GAUGE WITH STOP COCK
	REFRIGERANT LIQUID PIPE		BRANCH CONNECTION OUT OF TOP
	REFRIGERANT SUCTION LINE		BRANCH CONNECTION OUT OF BOTTOM
	REFRIGERANT HOT GAS LINE		BRANCH CONNECTION OUT OF SIDE
	HEATING WATER SUPPLY		NEW CONNECTION TO EXISTING PIPING
	HEATING WATER RETURN		CONCENTRIC REDUCER
	DOMESTIC COLD WATER		ECCENTRIC REDUCER
	DOMESTIC HOT WATER		PIPING DOWN
	DOMESTIC HOT WATER RETURN		PIPING UP -OR- PIPING UP & DOWN
	SANITARY WASTE LINE (UNDERFLOOR)		CAP ON END OF PIPE
	SANITARY WASTE LINE (ABOVE FLOOR)		HOSE BIBB OR WALL HYDRANT (SEE ALSO NFWH)
	CONDENSATE DRAIN		VALVE BOX IN PAVEMENT OR GRADE
	PUMPED SANITARY LINE		ROOF DRAIN DOWNSPOUT
	VENT LINE		FIRE PROTECTION RISER, PUMP
	STORM DRAIN PIPING (UNDERFLOOR)		FIRE HOSE CABINET
	FIRE PROTECTION PIPING		PRESSURE REDUCING VALVE
	DRAIN PIPING		FLEXIBLE EXPANSION LOOP
	ROOF DRAIN LINE		FLOWMETER
	FUEL OIL SUPPLY		BACKFLOW PREVENTER
	FUEL OIL RETURN		STEAM TRAP

ABBREVIATIONS

ALL ABBREVIATIONS SHOWN MAY NOT
APPEAR ON ALL DRAWINGS.

ABBV.	DESCRIPTION
AFF	ABOVE FINISHED FLOOR
AHU	AIR HANDLING UNIT
A	AMPERE
BOD	BOTTOM OF DUCT
BOP	BOTTOM OF PIPE
BTU	BRITISH THERMAL UNIT
CB	CIRCUIT BREAKER
CFM	CUBIC FEET PER MINUTE
CO2	CARBON DIOXIDE
CI	CAST IRON
CL	CENTER LINE
CO	CLEAN OUT
C	CONDUIT
CRP	CONDENSATE RETURN PUMP
CRU	COMPUTER ROOM UNIT
CU	CONDENSING UNIT
DB	DRY BULB
DS	DISCONNECT SWITCH
EDH	ELECTRIC DUCT HEATER
ENT	ENTERING
EUH	ELECTRIC UNIT HEATER
EWC	ELECTRIC WATER COOLER
EWS	EMERGENCY EYEWASH/SHOWER
EF	EXHAUST FAN
FA	FIRE ALARM
FCO	FLOOR CLEANOUT
FCU	FAN COIL UNIT
FDC	FIRE DEPARTMENT CONNECTION
FHC	FIRE HOSE CABINET
FHR	FIRE HOSE REEL
FPB	FAN POWERED BOX
FPI	FINS PER INCH
PRV	PRESSURE REDUCING VALVE
GALV	GALVANIZED
GAL	GALLONS
GC	GENERAL CONTRACTOR
GCO	GRADE CLEAN OUT
GFI	GROUND FAULT INTERRUPTER
GPH	GALLONS PER HOUR
GPM	GALLONS PER MINUTE
HP	HORSEPOWER
HWR	HOT WATER RETURN
HZ	HERTZ
IE	INVERT ELEVATION
KVA	THOUSAND VOLT AMPERES
LAV	LAVATORY
lbs/HR	POUNDS PER HOUR
LO	LOCKED OPEN
LVG	LEAVING
NFWH	NON FREEZE WALL HYDRANT
OA	OUTSIDE AIR

ABBREVIATIONS

ALL ABBREVIATIONS SHOWN MAY NOT
APPEAR ON ALL DRAWINGS.

ABBV.	DESCRIPTION
OBD	OPPOSED BLADE DAMPER
PSI	POUNDS PER SQUARE INCH
RA	RETURN AIR
RCP	REFLECTED CEILING PLAN
RD	ROOF DRAIN
RF	RETURN/RELIEF FAN
RPM	REVOLUTIONS PER MINUTE
SA	SUPPLY AIR
SAN	SANITARY
SS	STAINLESS STEEL
TO	TRANSFER OPENING
TYP	TYPICAL
V	VOLTS
VD	VOLUME DAMPER
VAV	VARIABLE AIR VOLUME
VTR	VENT THRU ROOF
UH	UNIT HEATER
UNO	UNLESS NOTED OTHERWISE
WB	WET BULB
WG	WATER GAUGE
WH	WATER HEATER
WHP	WATER-SOURCE HEAT PUMP

THE SEAL APPEARING ON THIS DOCUMENT WAS
AUTHORIZED BY STEPHEN P. LEARY, P.E. 60987
ALTERATION OF A SEALED DOCUMENT WITHOUT
PROPER NOTIFICATION TO THE RESPONSIBLE ENGINEER
IS AN OFFENSE UNDER THE TEXAS ENGINEERING PRACTICE ACT.



NO.	REVISION	BY	DATE
NORTH TEXAS TOLLWAY AUTHORITY ADDISON AIRPORT TUNNEL BARRIER TOLL PLAZA			
MECHANICAL SYMBOLS & ABBREVIATIONS			
AGUIRRE Corporation 18700 PARK CENTRAL DRIVE 18 TH FLOOR DALLAS TEXAS 75281 TEL. 972 788-8008		SECTION XIII	
CHECKED	DATE 12/18/97	DESIGNED JCN	DATE 12/20/96
CHECKED	DATE 12/18/97	SCALE AS SHOWN	
CONTRACT NO. DNT-290		SHEET 40 OF 53	


AT-M1.1

GENERAL NOTES

1. REFER TO ARCHITECTURAL REFLECTED CEILING PLAN AND ELECTRICAL LIGHTING PLAN FOR EXACT PLACEMENT OF DIFFUSERS.

NOTES BY SYMBOL 'O'

- ① BASEBOARD HEATER BENEATH COUNTER. REF. ARCHITECTURAL. TYPICAL FOR TWO.
- ② RETURN OPEN TO SPACE.
- ③ 6"x6" DUCT THRU ROOF WITH CURB. TERMINATE WITH GOOSENECK AND BIRD SCREEN.
- ④ SPLIT SUPPLY, WITH 10/12 TO NORTH AND 10/10 TO 80 TO SOUTH.
- ⑤ TRANSFER GRILLE, OPEN TO SPACE ABOVE CEILING.

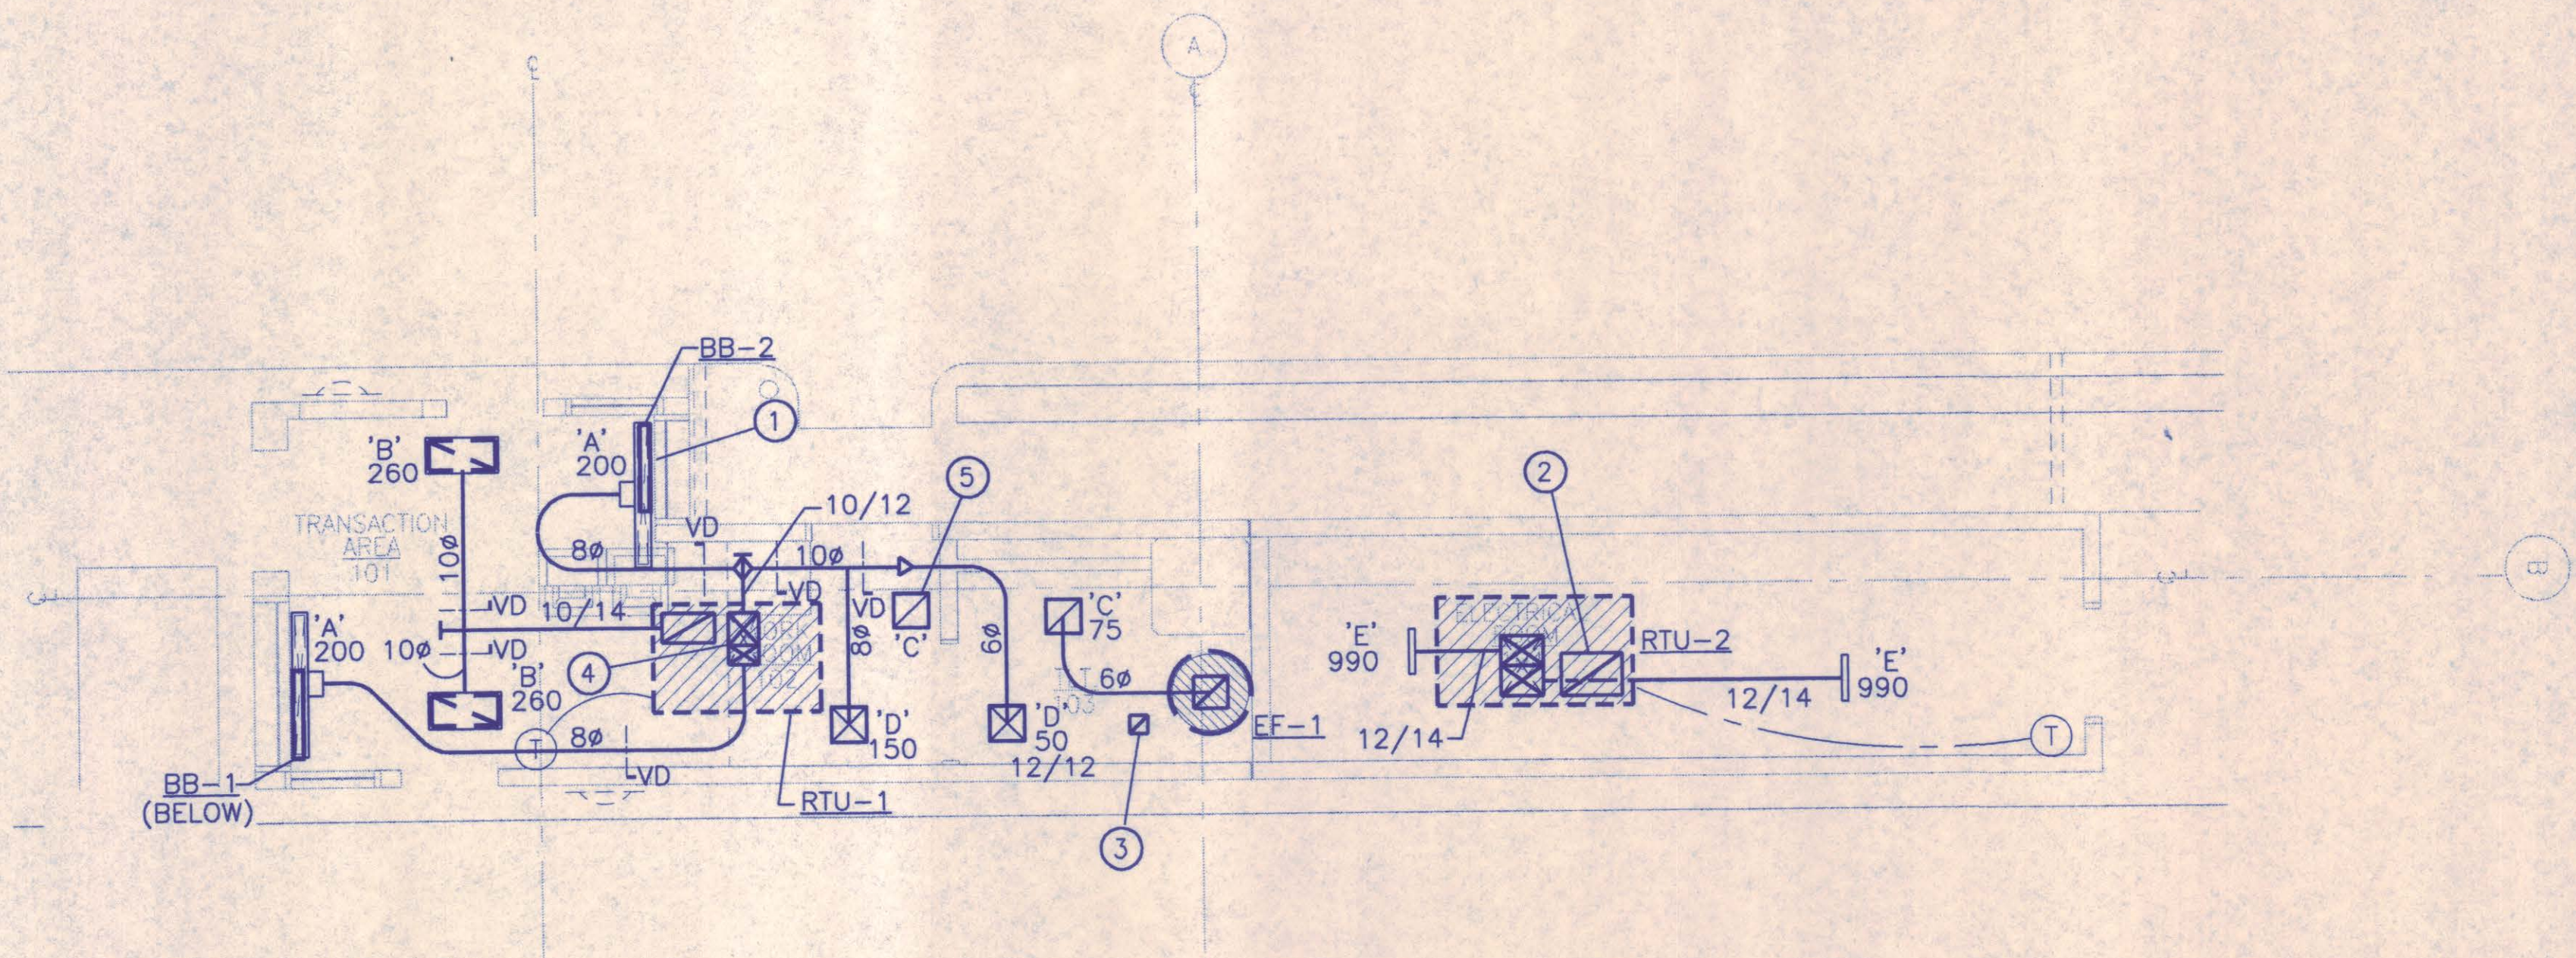

1 BOOTH MECHANICAL PLAN
SCALE: 1/4" = 1'-0"



THE SEAL APPEARING ON THIS DOCUMENT WAS
AUTHORIZED BY STEPHEN P. LEARY, P.E. 60987.
ALTERATION OF A SEALED DOCUMENT WITHOUT
PROPER NOTIFICATION TO THE RESPONSIBLE ENGINEER
IS AN OFFENSE UNDER THE TEXAS ENGINEERING PRACTICE ACT.

NO.	REVISION	BY	DATE
NORTH TEXAS TOLLWAY AUTHORITY ADDISON AIRPORT TUNNEL BARRIER TOLL PLAZA			
MECHANICAL HVAC PLAN			
AGUIRRE Corporation 8700 PARK CENTRAL DRIVE 15 TH FLOOR DALLAS, TEXAS 75241 TEL. 972 788-1008			SECTION XIII
CHECKED <i>SP</i>	DATE 12/18/97	DESIGNED JCN	DATE 12/20/96
CHECKED <i>SL</i>	DATE 12/18/97	SCALE AS NOTED	
CONTRACT NO. DNT-290 SHEET 41 OF 53			

AT-M2.1

ROOFTOP UNIT SCHEDULE																			
DESIGNATION	AREA SERVED	ELECTRICAL COMPRESSOR DATA		EVAPORATOR FAN				COOLING DATA					CONDENSER FAN			HEATER DATA		SIZE	REMARKS
		VOLTS/ PHASE	RLA/LRA	CFM	OA MIN	ESP	HP	TMBH	SMBH	EDB °F	EWB °F	AMBIENT TEMP	NO.	HP	FLA	INPUT MBH	OUTPUT MBH		
RTU-1	BOOTH	208/1	10/67	600	75	.75	1/4	17.3	10.9	80	67	105	1	1/5	1.6	40	30	NOMINAL 2 TONS	NOTES 1, 2
RTU-2	ELEC ROOM	208/3	17.5/118	1980	100	.25	3/4	56.4	37.1	80	67	105	1	1/2	3.3	-	-	NOMINAL 5 TONS	NOTES 1, 3

NOTES: 1. PROVIDE FACTORY ROOF CURB.
2. PROVIDE WITH HEAT/COOL PROGRAMMABLE THERMOSTAT. WITH AUTO CHANGE-OVER, WEEKLY TIME SCHEDULE AND NIGHT SETBACK.
3. PROVIDE WITH COOLING ONLY THERMOSTAT WITH FEATURES AS ABOVE.

EXHAUST FAN SCHEDULE												
DESIGNATION	LOCATION	SERVICE	TYPE	DRIVE	CFM	EXT. S.P. IN.	FAN RPM	MOTOR DATA			WEIGHT	REMARKS
								HP	VOLT/ PHASE	RPM		
EF-1	ROOF	RESTROOM	CENTRIFUGAL	DIRECT	75	0.25	1300	1/60	120/1	1300	20 LBS.	1,2

NOTES: 1. PROVIDE SPEED CONTROLLER FOR SYSTEM BALANCE.
2. FURNISH WITH BACKDRAFT DAMPER.

AIR DEVICE SCHEDULE					
DESIGNATION	DESCRIPTION	FACE TYPE	MAX S.P. IN	MAX NC.	REMARKS
'A'	SLOT	SLOT	0.1	35	48" LONG WITH 18" DOWN SLOT, LAY-IN CEILING
'B'	24"x12" RETURN	PERFORATED	0.05	35	MOUNTING FRAME FOR LAY-IN CEILING
'C'	8"x8" EXHAUST GRILLE	EGGCRATE	0.05	35	MOUNTING FRAME TO MATCH CEILING
'D'	CEILING DIFFUSER	LOUVERED	0.1	35	24"x24" IN BOOTH, 12"x12" IN RESTROOM, FRAME TO MATCH CLG.
'E'	20"x14" SUPPLY GRILLE	LOUVERED	0.1	35	DUCT MOUNT W/ OBD
NOTES:					

BASEBOARD HEATERS SCHEDULE						
DESIGNATION	LOCATION	MBH	WATTS	VOLTS/ PHASE	DIM.	REMARKS
BB-1 & 2	BOOTH UNDER CASH BOX	3.41	1000	120/1	12X10X5	1.

NOTES: 1. PROVIDE LINE VOLTAGE RHEOSTAT WITH PUSH ON-OFF DIAL MOUNTED IN TOLL BOOTH CONTROL PANEL (ONE PER ATTENDANT STATION REFER TO ELECTRICAL DETAILS.

RTU-1

1. FAN RUNS INTERMITTENTLY ON A CALL FOR HEATING OR COOLING. COMPRESSOR CYCLES TO MAINTAIN SPACE COOLING TEMPERATURE SETPOINT. FURNACE GAS VALVE CYCLES, WITH REQUIRED SAFETIES, TO MAINTAIN SPACE HEATING TEMPERATURE SETPOINT, WITHOUT OVERLAP WITH COOLING SETPOINT.

RTU-2


1. FAN RUNS INTERMITTENTLY ON A CALL FOR COOLING. COMPRESSOR CYCLES TO MAINTAIN SPACE TEMPERATURE SETPOINT.

BASEBOARD HEATER

1. HEATER ON-OFF AND PERCENT OUTPUT SHALL BE CONTROLLED FROM LOCAL SWITCH/RHEOSTAT. BASEBOARD HEATING SHALL BE AVAILABLE AT ALL TIMES. REFER TO SCHEDULE NOTES.

EXHAUST FANS

1. EXHAUST FAN SHALL RUN INTERMITTENTLY FROM TOILET ROOM LIGHT SWITCH.

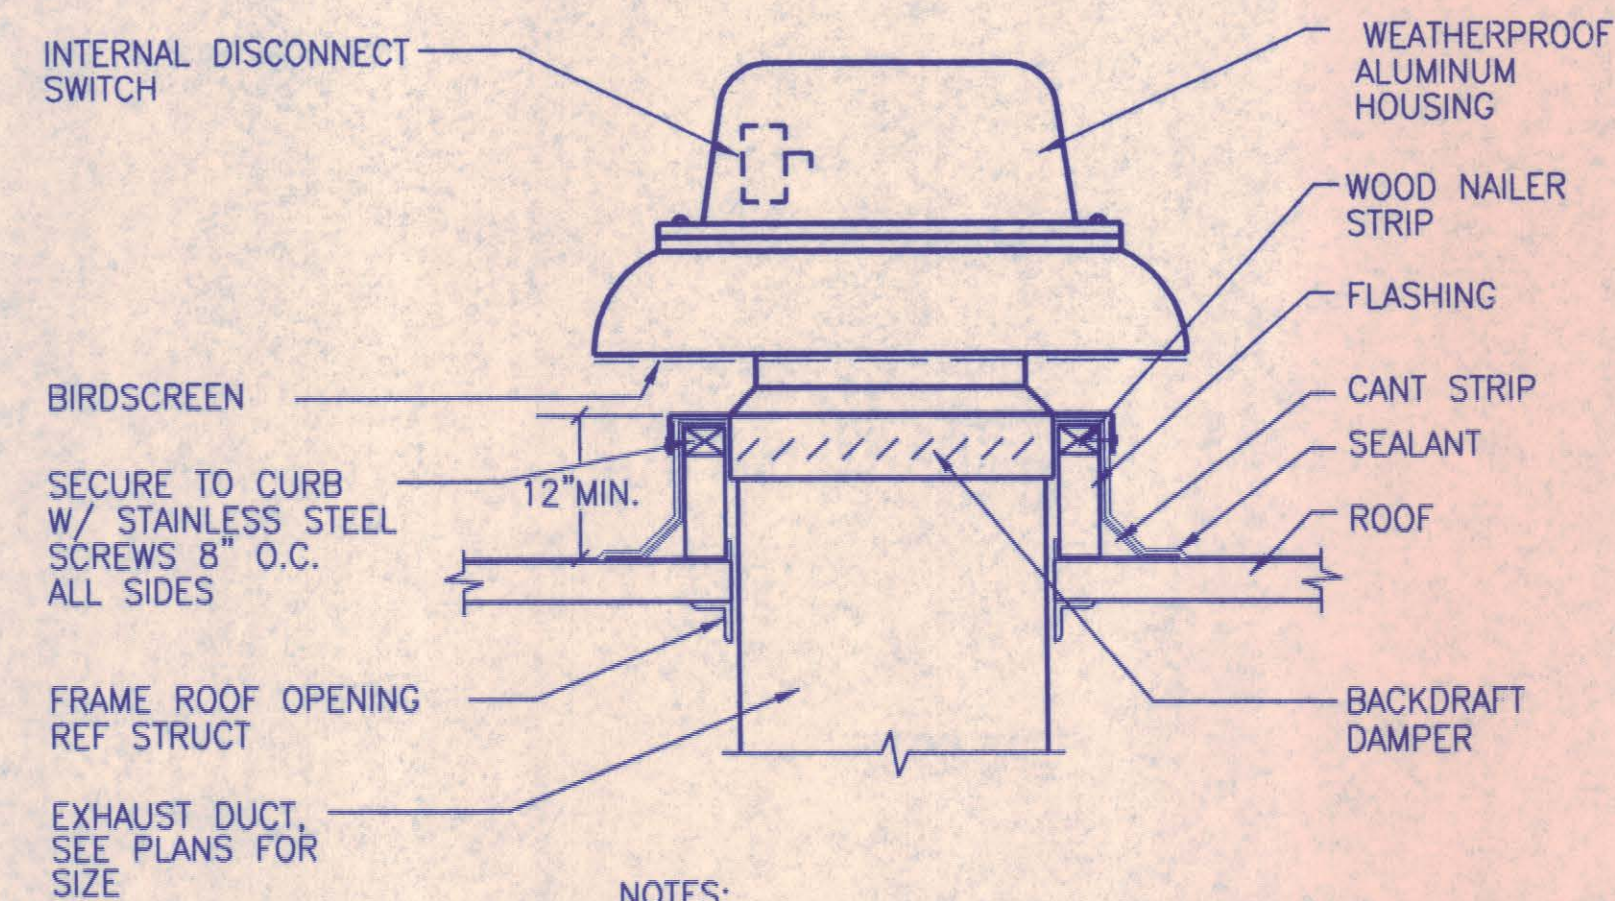


- NOTES:
1. EXHAUST DUCT-SIZES AS SHOWN ON PLANS. DUCTS SHALL EXTEND UP TO ROOF EXHAUSTER OPENING. DUCTS SHALL NOT TERMINATE BELOW ROOF.
 2. PROVIDE SPACE FOR ELECTRICAL CONDUIT BETWEEN DAMPER AND CURB.

1 EXHAUST FAN DETAIL

SCALE:NTS

 THE SEAL APPEARING ON THIS DOCUMENT WAS AUTHORIZED BY STEPHEN P. LEARY, P.E. 60987. ATTENTION OF A SEALED DOCUMENT WITHOUT PROPER NOTIFICATION TO THE RESPONSIBLE ENGINEER IS AN OFFENSE UNDER THE TEXAS ENGINEERING PRACTICE ACT.			
NO.	REVISION	BY	DATE
NORTH TEXAS TOLLWAY AUTHORITY ADDISON AIRPORT TUNNEL BARRIER TOLL PLAZA			
MECHANICAL HVAC SCHEDULES AND DETAILS			
 AGUIRRE Corporation 5700 PARK CENTRAL DRIVE 15 TH FLOOR DALLAS TEXAS 75201 TEL. (972) 788-1008		SECTION XIII.	
CHECKED <u>SPL</u>	DATE <u>12/18/97</u>	DESIGNED <u>JCN</u>	DATE <u>12/20/96</u>
CHECKED <u>Jeg</u>	DATE <u>12/18/97</u>	SCALE <u>AS NOTED</u>	
CONTRACT NO. <u>DNT-290</u>		SHEET <u>42</u>	OF <u>53</u>

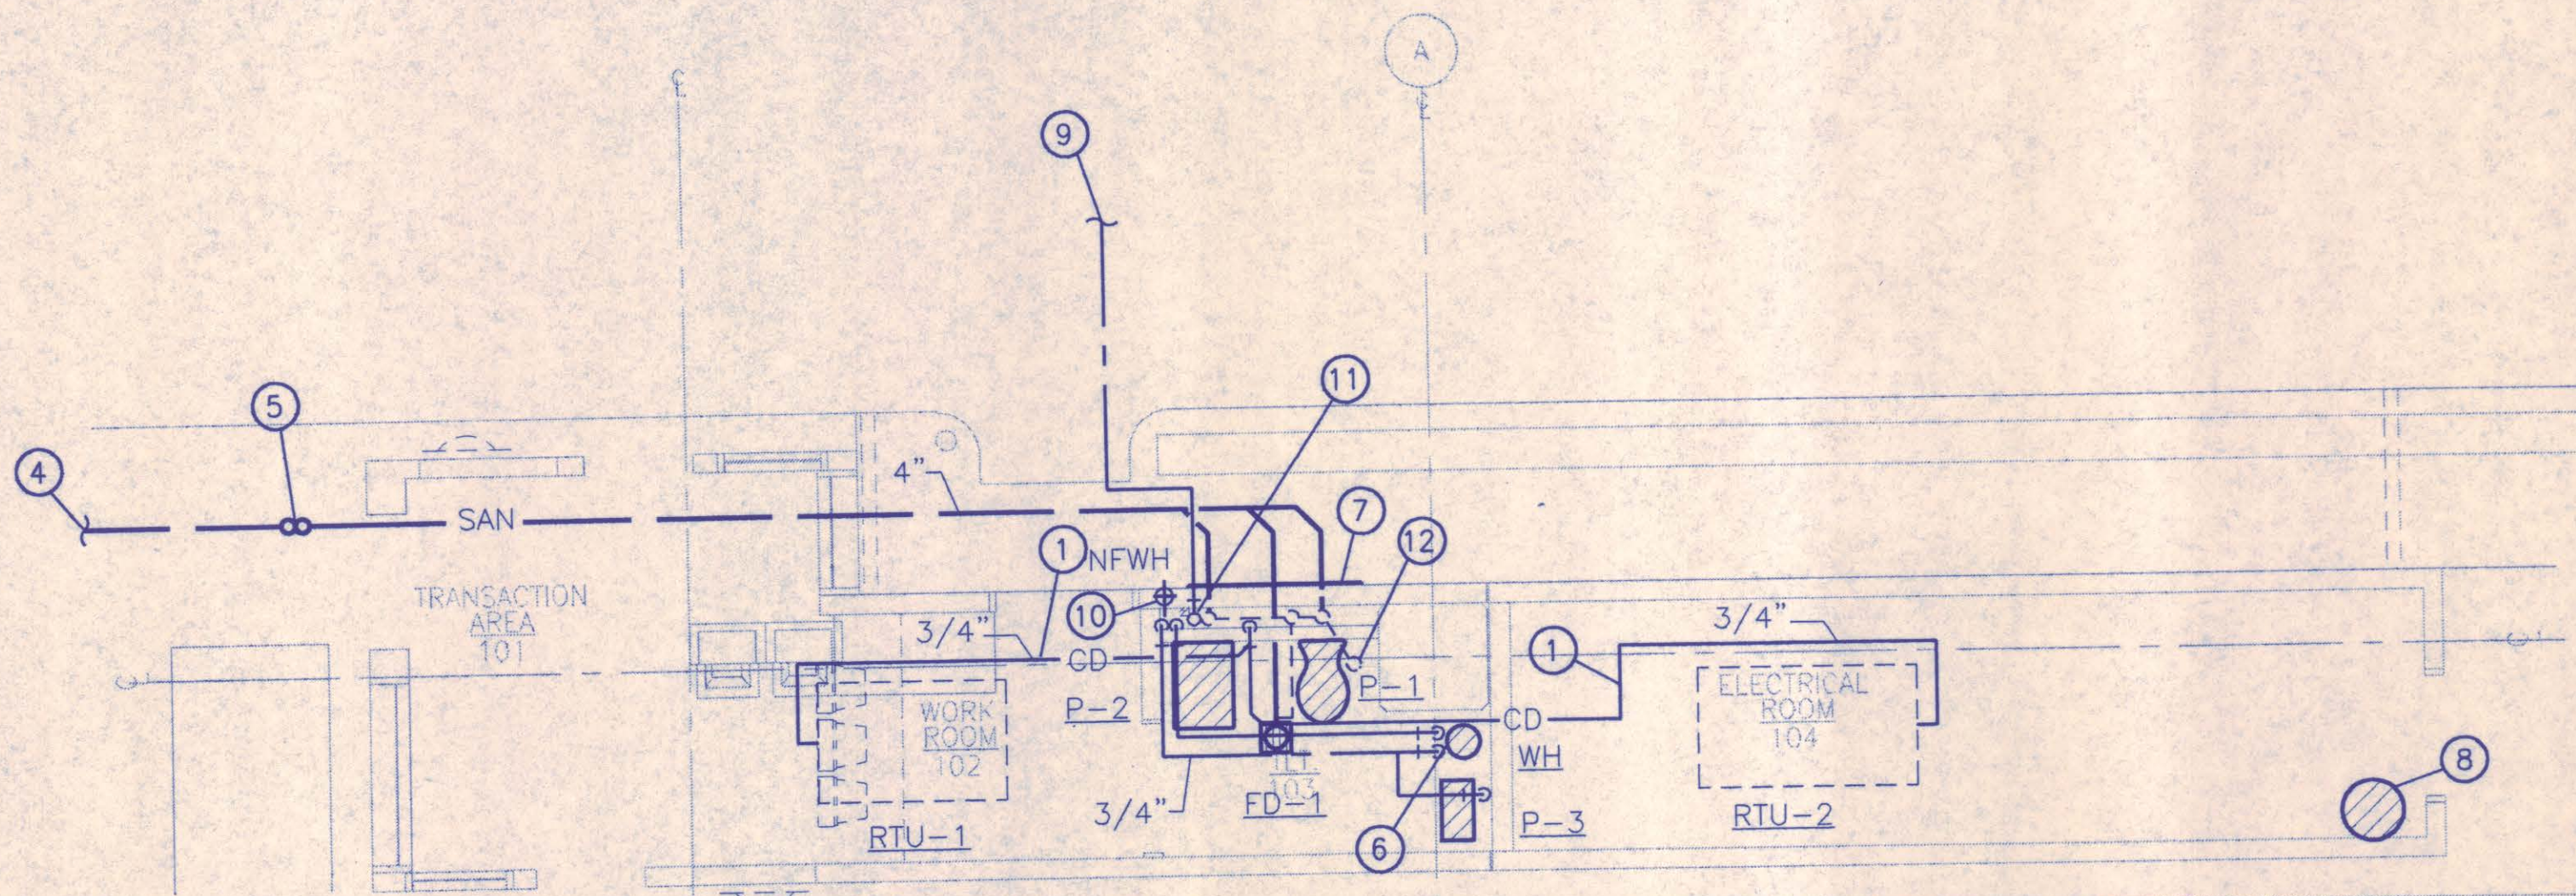


2 PLUMBING BOOTH PLAN
SCALE: 1/4" = 1'-0"
TAATPPB1



PLUMBING FIXTURE CONNECTION SCHEDULE						
TAG	DESCRIPTION	CONNECTION				REMARKS
		CW	HW	SAN	VENT	
P-1	WATER CLOSET	1"	-	4"	2"	HANDICAP ACCESSIBLE
P-2	LAVATORY	1/2"	1/2"	2"	1 1/2"	HANDICAP ACCESSIBLE
FD-1	FLOOR DRAIN	-	-	3"	2"	PROVIDE WITH TRAP PRIMER
WH	WATER HEATER	1/2"	1/2"	-	-	WITH T&P DRAIN TO EXTERIOR
P-3	WATER CHILLER	1/2"	-	-	-	

WH A.O. SMITH STOCK NO. ELSF-10, OR STATE, OR RHEEM, OR APPROVED EQUAL.
1500 WATTS/120V, 150 PSI MAXIMUM.

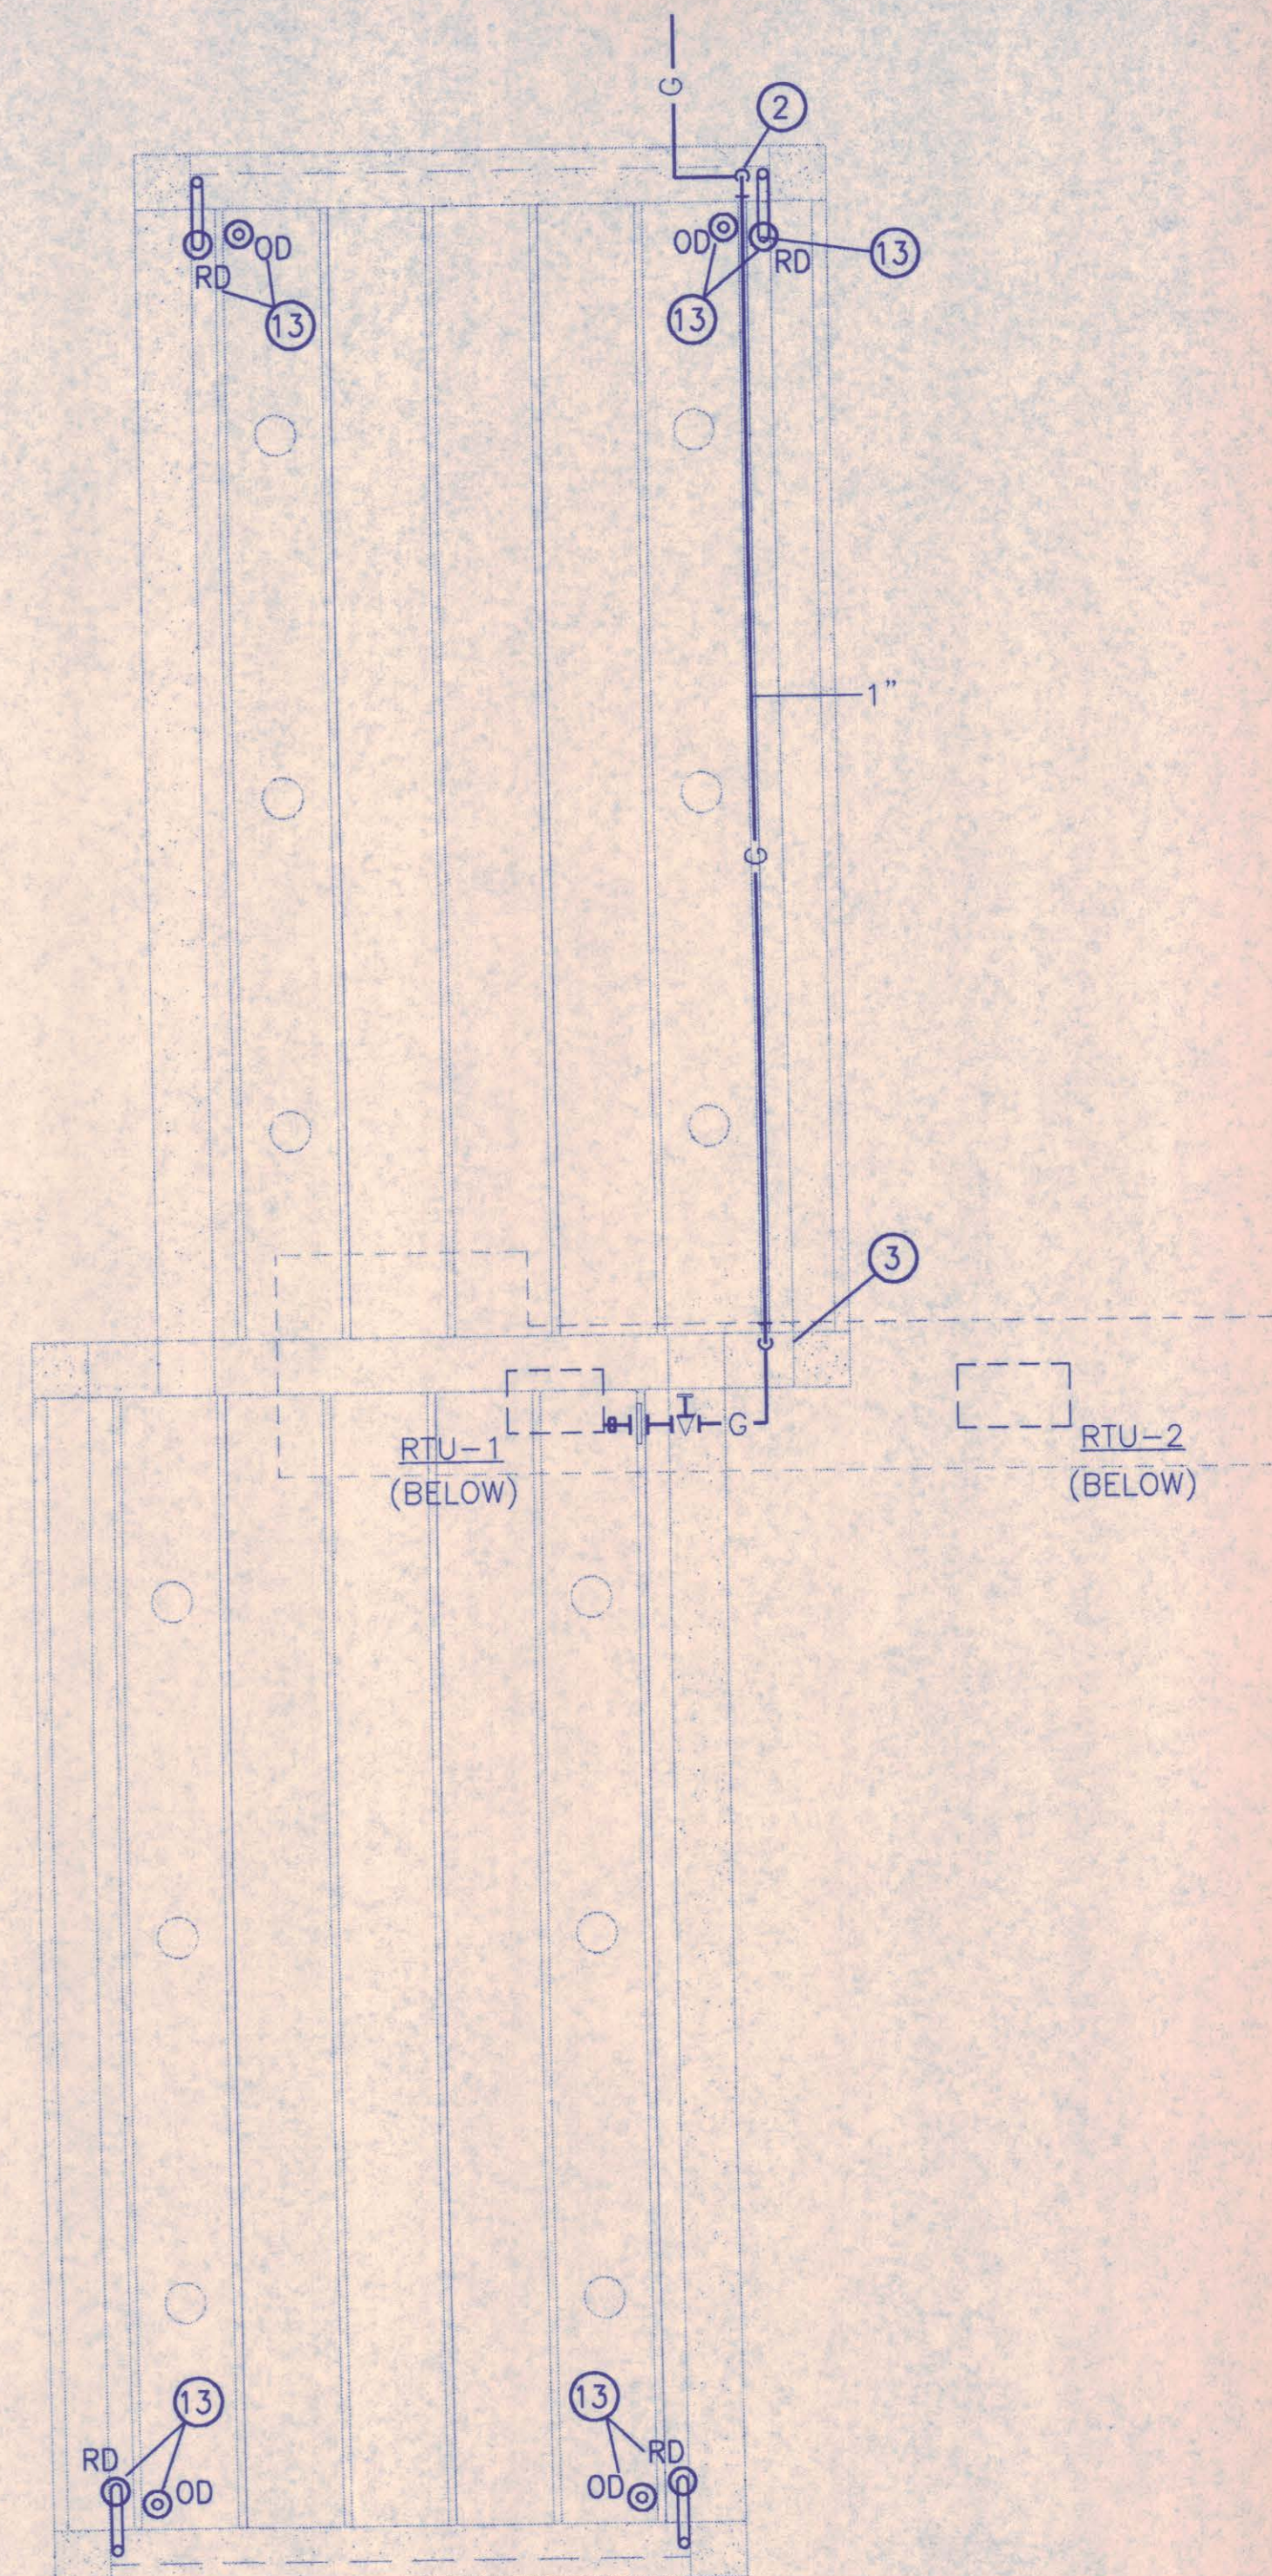

1 CANOPY PLUMBING PLAN
SCALE: 1/8" = 1'-0"
TAATMPC1



GENERAL NOTES

- ALL GAS PIPE IS TO BE EXPOSED UNDER CANOPY TO RTU'S. DO NOT ENCLOSE OR COVER IN RACEWAYS WITHOUT PROPER SLEEVE.
- PROVIDE ELECTRIC HEAT TRACE ON ALL HOT & COLD WATER PIPING EQUAL TO RAYCHEM 5XL-1, 40°F TEMPERATURE.

NOTES BY SYMBOL 'O'

- CONDENSATE LINE ON ROOF. TRAP ABOVE ROOF AND EXTEND 3/4" DOWN TO HUB DRAIN IN PLUMBING CHASE.
- ROUTE GAS LINE UP AT COLUMN TO UNDERSIDE OF PRECAST DOUBLE TEE ROOF STRUCTURE. PROVIDE 1 FOOT DEEP DIRT LEG WITH THREADED CAP AT BOTTOM.
- ROUTE 1" GAS LINE DOWN COLUMN TO ROOF OF BOOTH CONNECTION TO RTU-1.
- 4" SANITARY SEWER. I.E.= 98.0' AT BUILDING EXIT. REFER TO CIVIL FOR CONTINUATION.
- 2-WAY CLEANOUT.
- WATER HEATER ON SHELF ABOVE CEILING. FURNISH GALVANIZED PAN, 3" DEEP, 3" LARGER THAN HEATER O.D. WITH SWEATED 1/2" DRAIN LINE. ROUTE DRAIN LINE TO HUB DRAIN IN CHASE. FURNISH SHUT-OFF VALVE ON CW SUPPLY AND UNIONS AT HW/CW CONNECTIONS. ROUTE FULL SIZED DISCHARGE FROM T&P RELIEF DOWN IN CHASE AND OUT THROUGH EXTERIOR WALL NEAR NFWH AT 6" A.F.F. TERMINATE W/ 90° ELL DOWN.
- ACCESS PANELS. REF. ARCH.
- FIRE SUPPRESSION CANISTER FOR FM-200 SYSTEM. REF. DIV. 15 SPECIFICATIONS.
- 1 1/2" POTABLE WATER SUPPLY. REFER TO CIVIL FOR CONTINUATION.
- 3/4" CW DOWN TO RECESSED NFWH.
- ROUTE 1 1/2" POTABLE WATER SUPPLY UP INTO CHASE IN SLEEVE. PROVIDE SHUT-OFF VALVE IN VERTICAL, ACCESSIBLE FROM ACCESS PANEL. PROVIDE DOUBLE-CHECK BACKFLOW PREVENTER IN HORIZONTAL.
- 2" VENT THROUGH ROOF.
- 4" ROOF DRAIN WITH CAST IRON LEADER, AND OVERFLOW ROOF DRAIN. REFER TO ARCHITECTURAL FOR ROUTING ALONG COLUMN.



THE SEAL APPEARING ON THIS DOCUMENT WAS AUTHORIZED BY STEPHEN P. LEARY, P.E. 60987. ALIENATION OF A SEALED DOCUMENT WITHOUT PROPER NOTIFICATION TO THE RESPONSIBLE ENGINEER IS AN OFFENSE UNDER THE TEXAS ENGINEERING PRACTICE ACT.

NO.	REVISION	BY	DATE
NORTH TEXAS TOLLWAY AUTHORITY ADDISON AIRPORT TUNNEL BARRIER TOLL PLAZA			
PLUMBING PLANS AND SCHEDULES			
AGUIRRE Corporation 8700 PARK CENTRAL DRIVE 9TH FLOOR DALLAS TEXAS 75241 TEL 972 788-9508			SECTION XIII.
CHECKED <i>SPL</i>	DATE 12/18/97	DESIGNED <i>JCN</i>	DATE 12/20/96
CHECKED <i>PL</i>	DATE 12/18/97	SCALE <i>AS NOTED</i>	
CONTRACT NO. <i>DNT-290</i>		SHEET <i>43</i> OF <i>53</i>	

AT-P1.1

ELECTRICAL SYMBOLS

COMMUNICATIONS

- | | |
|---|------------------|
|  | DATA OUTLET |
|  | PUSHBUTTON |
|  | TELEPHONE OUTLET |

FIRE ALARM

- | | |
|---|---|
|  | MANUAL PULL STATION |
|  | FIRE ALARM – AUDIBLE HORN |
|  | FIRE ALARM – COMBINATION UNIT
LIGHT & HORN |
|  | HEAT DETECTOR |
|  | SMOKE DETECTOR |
|  | FIRE ALARM CONTROL PANEL |
|  | FIRE ALARM SPEAKER |
|  | FIRE ALARM FLASHER |

LIGHTING

- | | |
|---|----------------------------------|
|  | 2' X 2' LIGHT FIXTURE |
|  | 2' X 4' LIGHT FIXTURE |
|  | STRIP LIGHT FIXTURE |
|  | HID LIGHT FIXTURE |
|  | WALL MOUNTED EXIT LIGHT - 1 SIDE |
|  | PHOTOCELL |
|  | WALL MOUNT |
|  | RECESSED IN CONCRETE |
|  | WALL MOUNT LIGHT FIXTURE |

PANELS

- 120/208 PANELBOARD

ABBREVIATIONS

- | | |
|--------------|---|
| AAT | ADDITION AIRPORT TUNNEL |
| AFC | ABOVE FINISHED COUNTER |
| AFF | ABOVE FINISHED FLOOR |
| AVI | AUTOMATIC VEHICLE IDENTIFICATION |
| C | CONDUIT |
| CB, C/B OR | CIRCUIT BREAKER |
| CKT | CIRCUIT |
| CCTV | CLOSED CIRCUIT TELEVISION |
| CLG | CEILING |
| CACP/FP | CARD ACCESS PROCESSING
CONTROL FIELD PANEL |
| C.T | CURRENT TRANSFORMER |
| ELEC | ELECTRIC |
| EMERG | EMERGENCY |
| EW | ELECTRIC WATER COOLER |
| FA | FIRE ALARM |
| FACP | FIRE ALARM CONTROL PANEL |
| FIXT | FIXTURE |
| FLR | FLOOR |
| FLUOR | FLUORESCENT |
| FTU | FAN TERMINAL UNIT |
| G.GND | GROUND |
| GEF | GENERAL EXHAUST FAN |
| GEN | GENERATOR |
| GFI | GROUND FAULT CIRCUIT
INTERRUPTER |
| HP | HORSEPOWER |
| ILP | IN LANE PROCESSOR |
| INCAND | INCANDESCENT |
| IG | ISOLATED GROUND |
| JBOX | JUNCTION BOX |
| LTS | LIGHTS |
| LTG | LIGHTING |
| LV | LOW VOLTAGE |
| MCB | MAIN CIRCUIT BREAKER |
| MLO | MAIN LUGS ONLY |
| MTD | MOUNTED |
| MTG HGT | MOUNTING HEIGHT |
| NEC | NATIONAL ELECTRICAL CODE |
| NFD | NON-FUSED DISCONNECT |
| PNL | PANEL |
| PWR | POWER |
| RECEPT, RCPT | RECEPTACLE |
| RF | RETURN AIR FAN |
| R/T/G | RED/TOLL/GREEN |
| TEL - | TELEPHONE |
| THHN/THWN | |
| NTTA | NORTH TEXAS TURNPIKE
AUTHORITY |
| TYP | TYPICAL |
| UL | UNDERWRITER'S LABORATORIES |
| UPS | UNINTERRUPTIBLE POWER SUPPLY |
| UNO | UNLESS NOTED OR INDICATED
OTHERWISE |
| V | VOLTAGE |
| W | WIRE |
| W/ | WITH |
| WP | WEATHER PROOF |
| W/S | WATER SWITCH |
| WT | WATER TIGHT |
| XFMR | TRANSFORMER |

GENERAL NOTES

A. GENERAL NOTES

1. THE WORD 'PROVIDE' AS USED IN THE DRAWINGS SHALL MEAN FOR THE CONTRACTOR TO 'FURNISH AND INSTALL', UNLESS NOTED OTHERWISE.
2. FASTENING HARDWARE (BOLTS, SCREWS, NUTS, WASHERS) SHALL BE GALVANIZED UNLESS NOTED OTHERWISE. SUPPORTS FOR CONDUIT AND EQUIPMENT SHALL BE HOT DIP GALVANIZED STEEL.
3. CONTRACTOR SHALL INSTALL PANELS, FIXTURES, BOXES, CONDUIT, ETC. IN LOCATIONS SHOWN. MINOR DEVIATIONS FROM THE DRAWINGS, AS REQUIRED BY FIELD CONDITIONS SHALL BE PERMITTED.
4. 120 VOLT BRANCH CIRCUITS 100' TO 200' SHALL BE A MINIMUM #10 AWG. CIRCUITS OVER 200' SHALL BE A MINIMUM #8 AWG. 208 VOLT CIRCUITS OVER 200' SHALL BE A MINIMUM #10 AWG. THE DISTANCE SHALL BE MEASURED FROM THE PANEL TO THE MOST DISTANT POINT IN THE CIRCUIT. CONDUIT SHALL BE ROUTED PARALLEL AND PERPENDICULAR TO STRUCTURAL SYSTEM.
5. NOT USED
6. MINIMUM BRANCH CIRCUIT SIZE SHALL BE 2#12 AND #12 AWG GROUND.
7. BRANCH CIRCUITS SHALL MEET THE REQUIREMENTS OF THE NEC AND OTHER STATE AND LOCAL ORDINANCES. WHERE THERE IS A CONFLICT, THE MOST STRINGENT SHALL APPLY.
8. COORDINATE WITH MECHANICAL SHEETS FOR LOCATION OF MOTORS.
9. COORDINATE THE POWER REQUIREMENTS FOR ALL MECHANICAL EQUIPMENT WITH THE EQUIPMENT BEING INSTALLED BEFORE INSTALLING CONDUIT AND WIRE.
10. EQUIPMENT IS NEW UNLESS NOTED OTHERWISE.

B. CONDUIT

1. POWER AND LIGHTING CONDUITS ARE SIZED BASED ON THHN/THWN INSULATION.
2. OPEN KNOCKOUTS IN JUNCTION BOXES AND EQUIPMENT SHALL BE PLUGGED.

C. LIGHTING

1. EXIT AND SEI CONTAINED EMERGENCY FIXTURES SHALL BE CIRCUITED AHEAD OF THE WALL SWITCH , OR ON A SEPARATE CIRCUIT.
2. LIGHT SWITCHES ARE TO BE AT 48" AFF UNLESS NOTED OTHERWISE
3. FLUORESCENT LAMPS SHALL BE 5000 DEGREES KELVIN UNLESS STATED OTHERWISE
4. VERIFY SWITCH LOCATIONS WITH ARCHITECTURAL SHEETS

D. POWER

1. VERIFY EXACT POWER CONNECTION TYPE AND NEMA CONFIGURATION OF OUTLETS REQUIRED TO SERVE OWNER FURNISHED EQUIPMENT.
2. 120 VOLT RECEPTACLES WITHIN 6 FEET DISTANCE FROM PLUMBING FIXTURES OR SINKS SHALL BE EQUIPPED WITH GFI PROTECTION.
3. OUTLETS SHALL NOT BE MOUNTED BACK TO BACK. A MINIMUM OF ONE STUD SHALL BE BETWEEN OUTLETS.
4. RECEPTACLES ARE TO BE AT 16" AFF TO MEET ADA CODE, UNLESS OTHERWISE NOTED.
5. TWO SECTION PANELBOARDS SHALL BE SAME AMPACITY. PROVIDE A SUBFEED LOGS.
6. DO NOT CONNECT MORE THAN SEVEN CONVENIENCE OUTLETS PER 20 AMPERE CIRCUIT.

E. COMMUNICATIONS

1. COMMUNICATIONS WIRING SHALL BE INSTALLED PER NEC. USE LOW SMOKE PRODUCING CABLE OR INSTALL IN MINIMUM OF 1/2" CONDUIT.

F. FIRE ALARM


1. FIRE ALARM CONDUIT SHALL BE 3/4 " MINIMUM.
2. FIRE ALARM CABLES SHALL BE AS REQUIRED BY THE FIRE ALARM SYSTEM MANUFACTURER.

G. GROUNDING

1. PER NEC ARTICLE 250.

LIGHT FIXTURE SCHEDULE

TYPE	DESCRIPTION	VOLTS	SIMILAR TO MANUFACTURER'S PART NUMBER	LAMP(S)
A	2'X2', 2 LAMP, RECESSED FLUORESCENT, ACRYLIC A12 LENS	120	LITHONIA 2SPG-2U32-A12-120-GEB OR COLUMBIA OR APPROVED EQUAL	(2) OSRAM/ SYLVANIA FB032/841/6
A3	2'X4', 3 LAMP, RECESSED FLUORESCENT, ACRYLIC A12 LENS	120	LITHONIA 2SPG-332-A12-120-GEB OR COLUMBIA OR APPROVED EQUAL	(3) OSRAM/ SYLVANIA F032/950
J2	4' INDUSTRIAL FLUORESCENT, MOUNTED TO BOTTOM OF ROOF DECK.	120	LITHONIA L32-120-GEB OR COLUMBIA OR APPROVED EQUAL	(2) OSRAM/ SYLVANIA F032/950
H1	HIGH PRESSURE SODIUM HID FIXTURE, MOUNTED ON STRUCTURE.	MULTI- TAP	SPAULDING NKII-CM-S250-VS-MT-DBZ OR MOLDCAST OR APPROVED EQUAL	250 WATT HPS
X1	RED, LIGHT EMITTING DIODE TYPE, STENCIL FACE, WHITE, SINGLE FACE, DUAL VOLTAGE, UNIVERSAL MOUNT, EXIT LIGHT EGRESS LIGHT.	120	LITHONIA LE-S-W-1-R-120 OR PRESCOLITE OR APPROVED EQUAL	NONE
K	WALL MOUNTED HALOGEN FIXTURE. REFER TO ARCH. FOR MOUNTING HEIGHT.	120	BEGA 6615 BLACK OR APPROVED EQUAL	150 WATT HALOGEN
B	WALL MOUNT ABOVE WINDOW	120	KENALL 6120 OR LITHONIA EQUAL	GOLBUG LITES F20J12/GO/ES
M	RECESSED IN CONCRETE	120	HYDREL #4418-4 LESS YOKE WITH #1422-2A AMBER LENS OR HUBBELL OR APPROVED EQUAL	(1) OSRAM SYLVANIA 69A21/TS

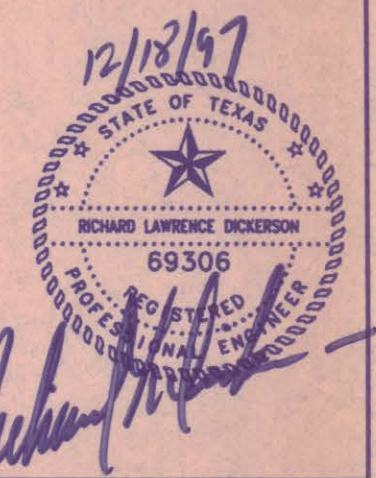

NO.	REVISION	BY	DATE
NORTH TEXAS TOLLWAY AUTHORITY ADDISON AIRPORT TUNNEL BARRIER TOLL PLAZA			
ELECTRICAL GENERAL NOTES, SYMBOLS, AND ABBREVIATIONS			
 AGUIRRE Corporation 5700 PARK CENTRAL DRIVE 15 TH FLOOR DALLAS TEXAS 75201 TEL. 972-3 755-1608		SECTION XIII	
CHECKED <i>RLD</i> <i>Jes</i>	DATE <u>12/18/97</u>	DESIGNED <u>FA</u> N.T.S.	DATE <u>12/20/96</u>
CHECKED	DATE <u>12/18/97</u>	SCALE	
CONTRACT NO. DNT-290		SHEET 44	OF 53


AT-E0.1

GENERAL NOTES

1. LIGHTNING PROTECTION SHALL BE PROVIDED PER SPEC SECTION 16670.
2. PULLBOXES SHALL BE CAST METAL, FLUSH TOP, WATERTIGHT, UL TYPE 4, SIZE AS INDICATED.

KEY NOTES

- ① STUB CONDUITS FLUSHED WITH COMMUNICATION BOARD. PROVIDE PULLSTRING AND TERMINATE CONDUITS WITH PLASTIC BUSHING.
- ② REFER TO "HDR" ADDISON AIRPORT TUNNEL CONTRACT DOCUMENTS FOR NITA CONTRACT No. DNT-260 FOR TERMINATION POINT OF ELECTRICAL 480/277V SERVICE IN THE TUNNEL.

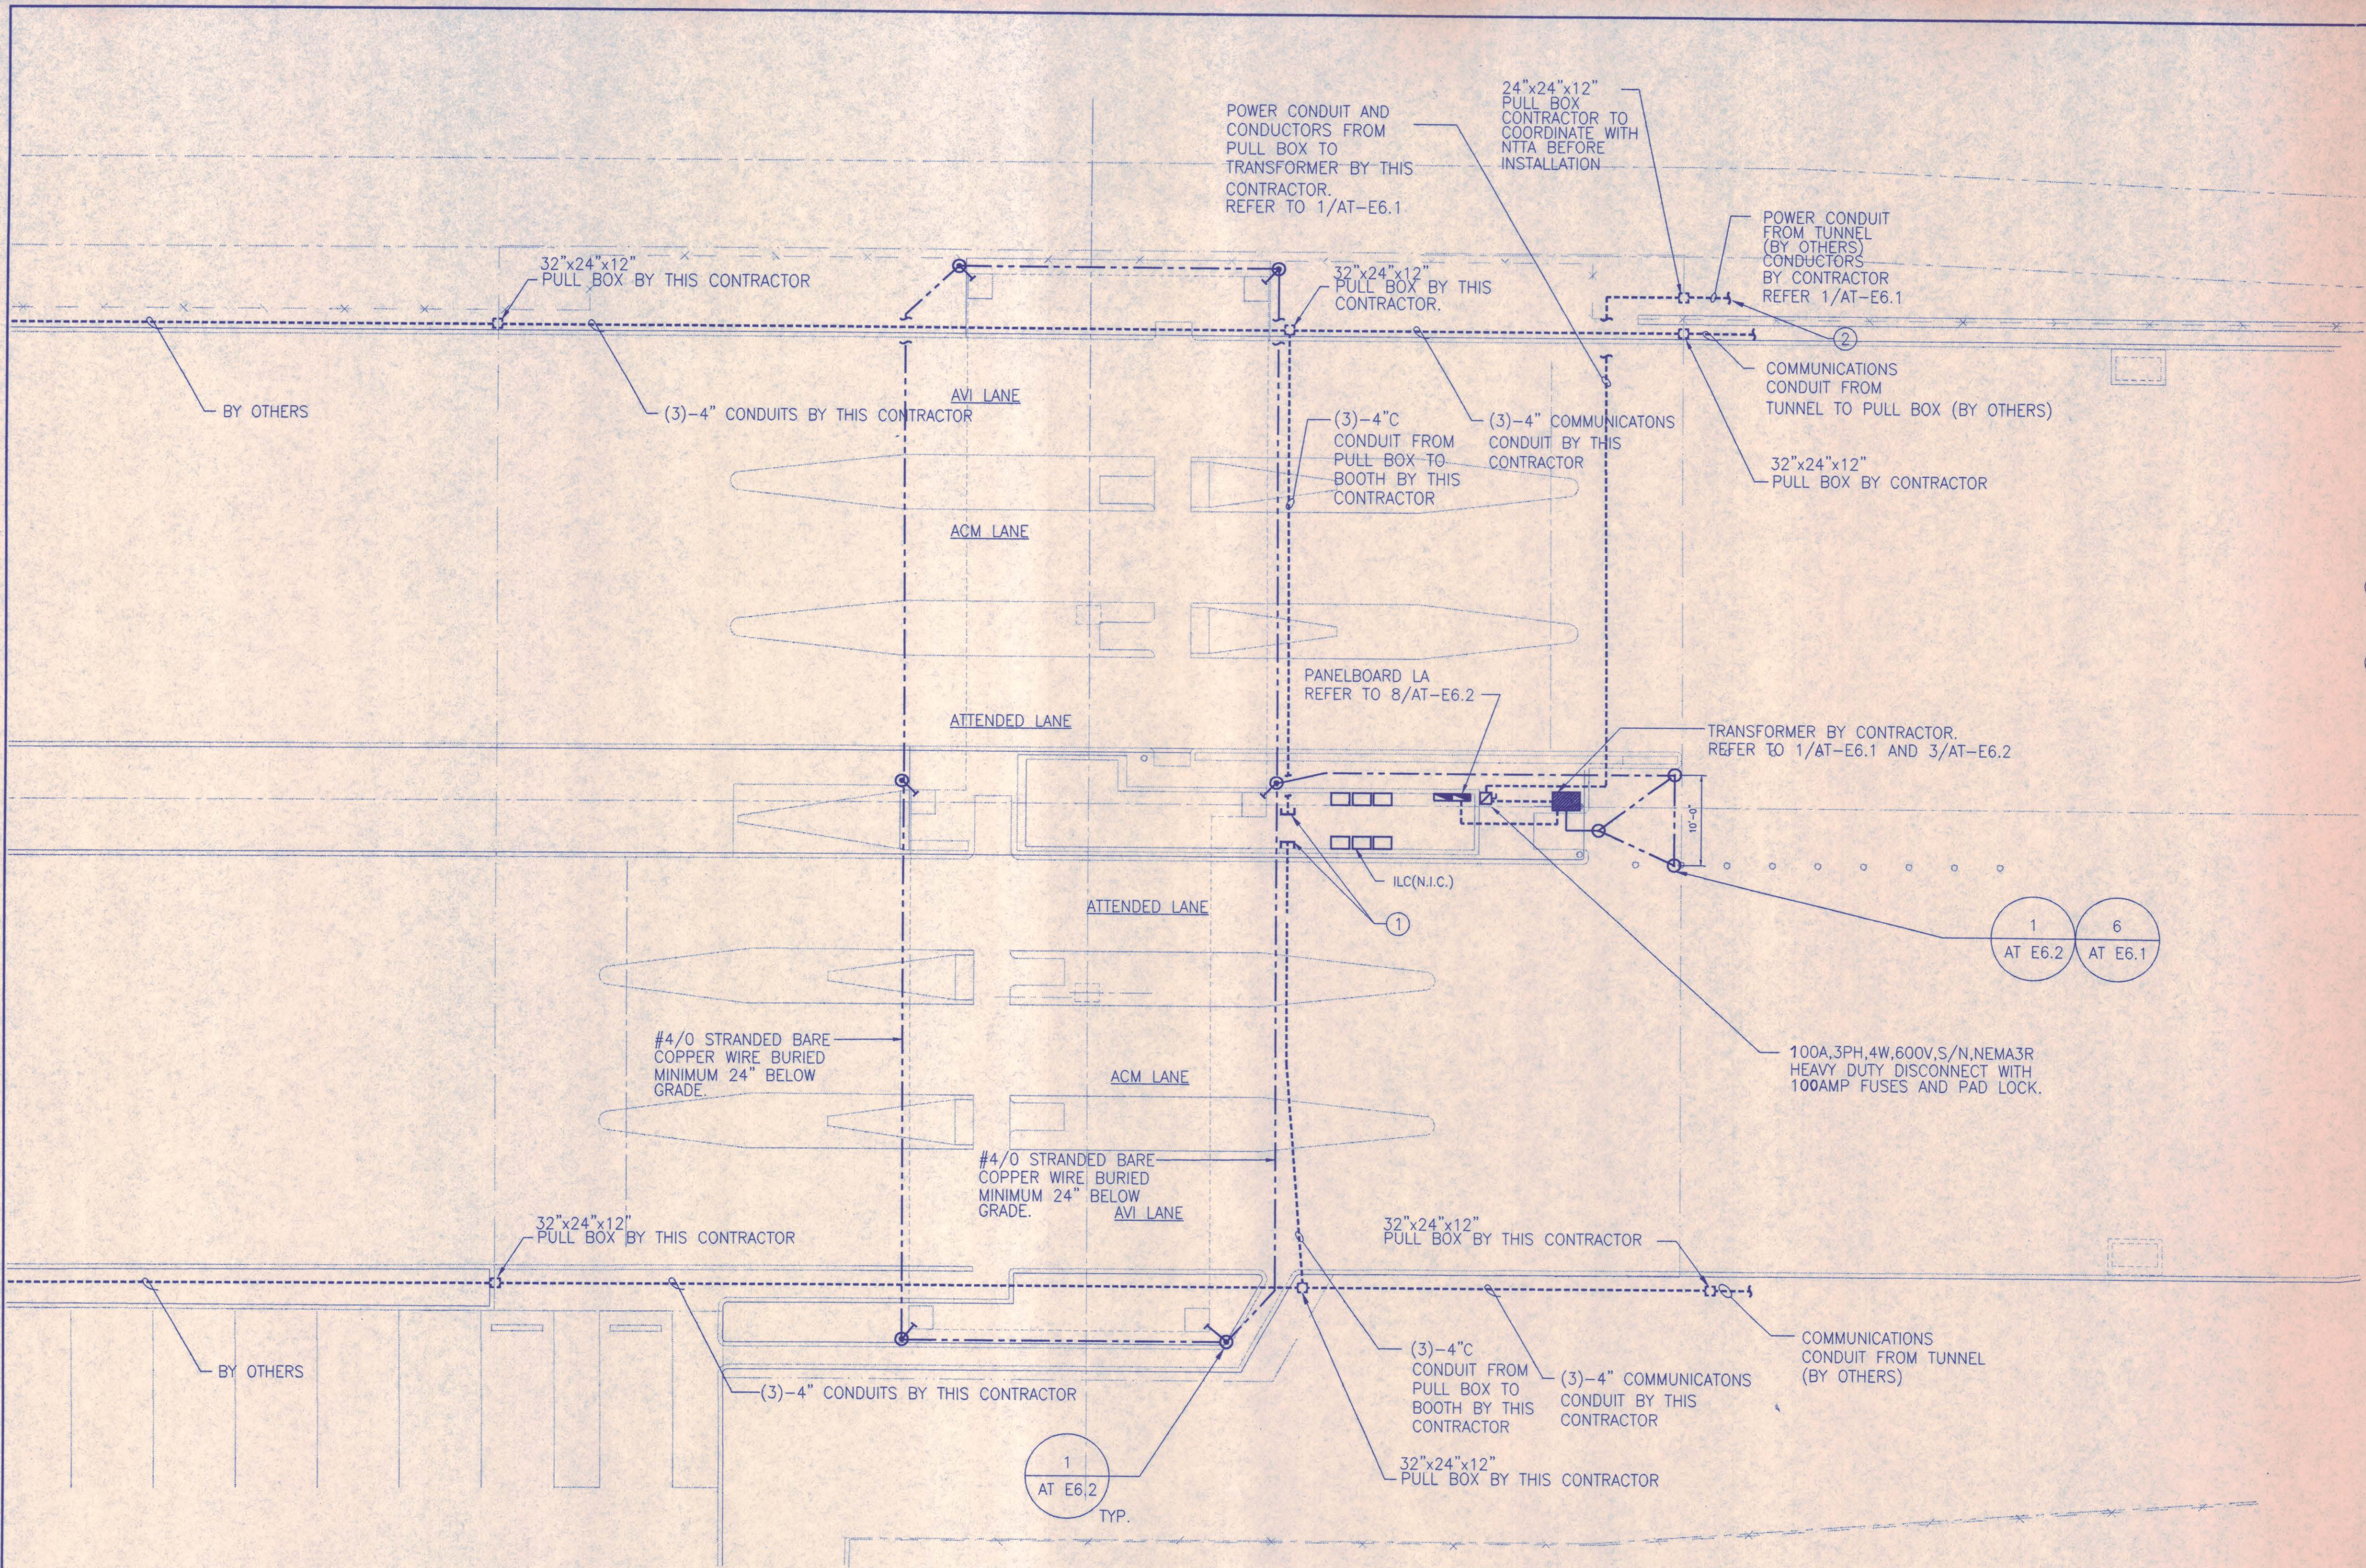


1 ELEC. SITE UTILITY & GROUNDING PLAN
SCALE: 1" = 10'-0"



AT-E1.1



NO.	REVISION	BY	DATE
NORTH TEXAS TOLLWAY AUTHORITY ADDISON AIRPORT TUNNEL BARRIER TOLL PLAZA			
ELECTRICAL SITE/UTILITY AND GROUNDING PLAN			
AGUIRRE CORPORATION 12700 PARK CENTRAL DRIVE 15 TH FLOOR DALLAS TEXAS 75241 TEL. (972) 788-1606			SECTION XIII
CHECKED <i>[Signature]</i>	DATE 12/18/97	DESIGNED FA	DATE 12/20/96
CHECKED <i>[Signature]</i>	DATE 12/18/97	SCALE 1/8" = 1'-0"	
CONTRACT NO. DNT-290		SHEET 45 OF 53	

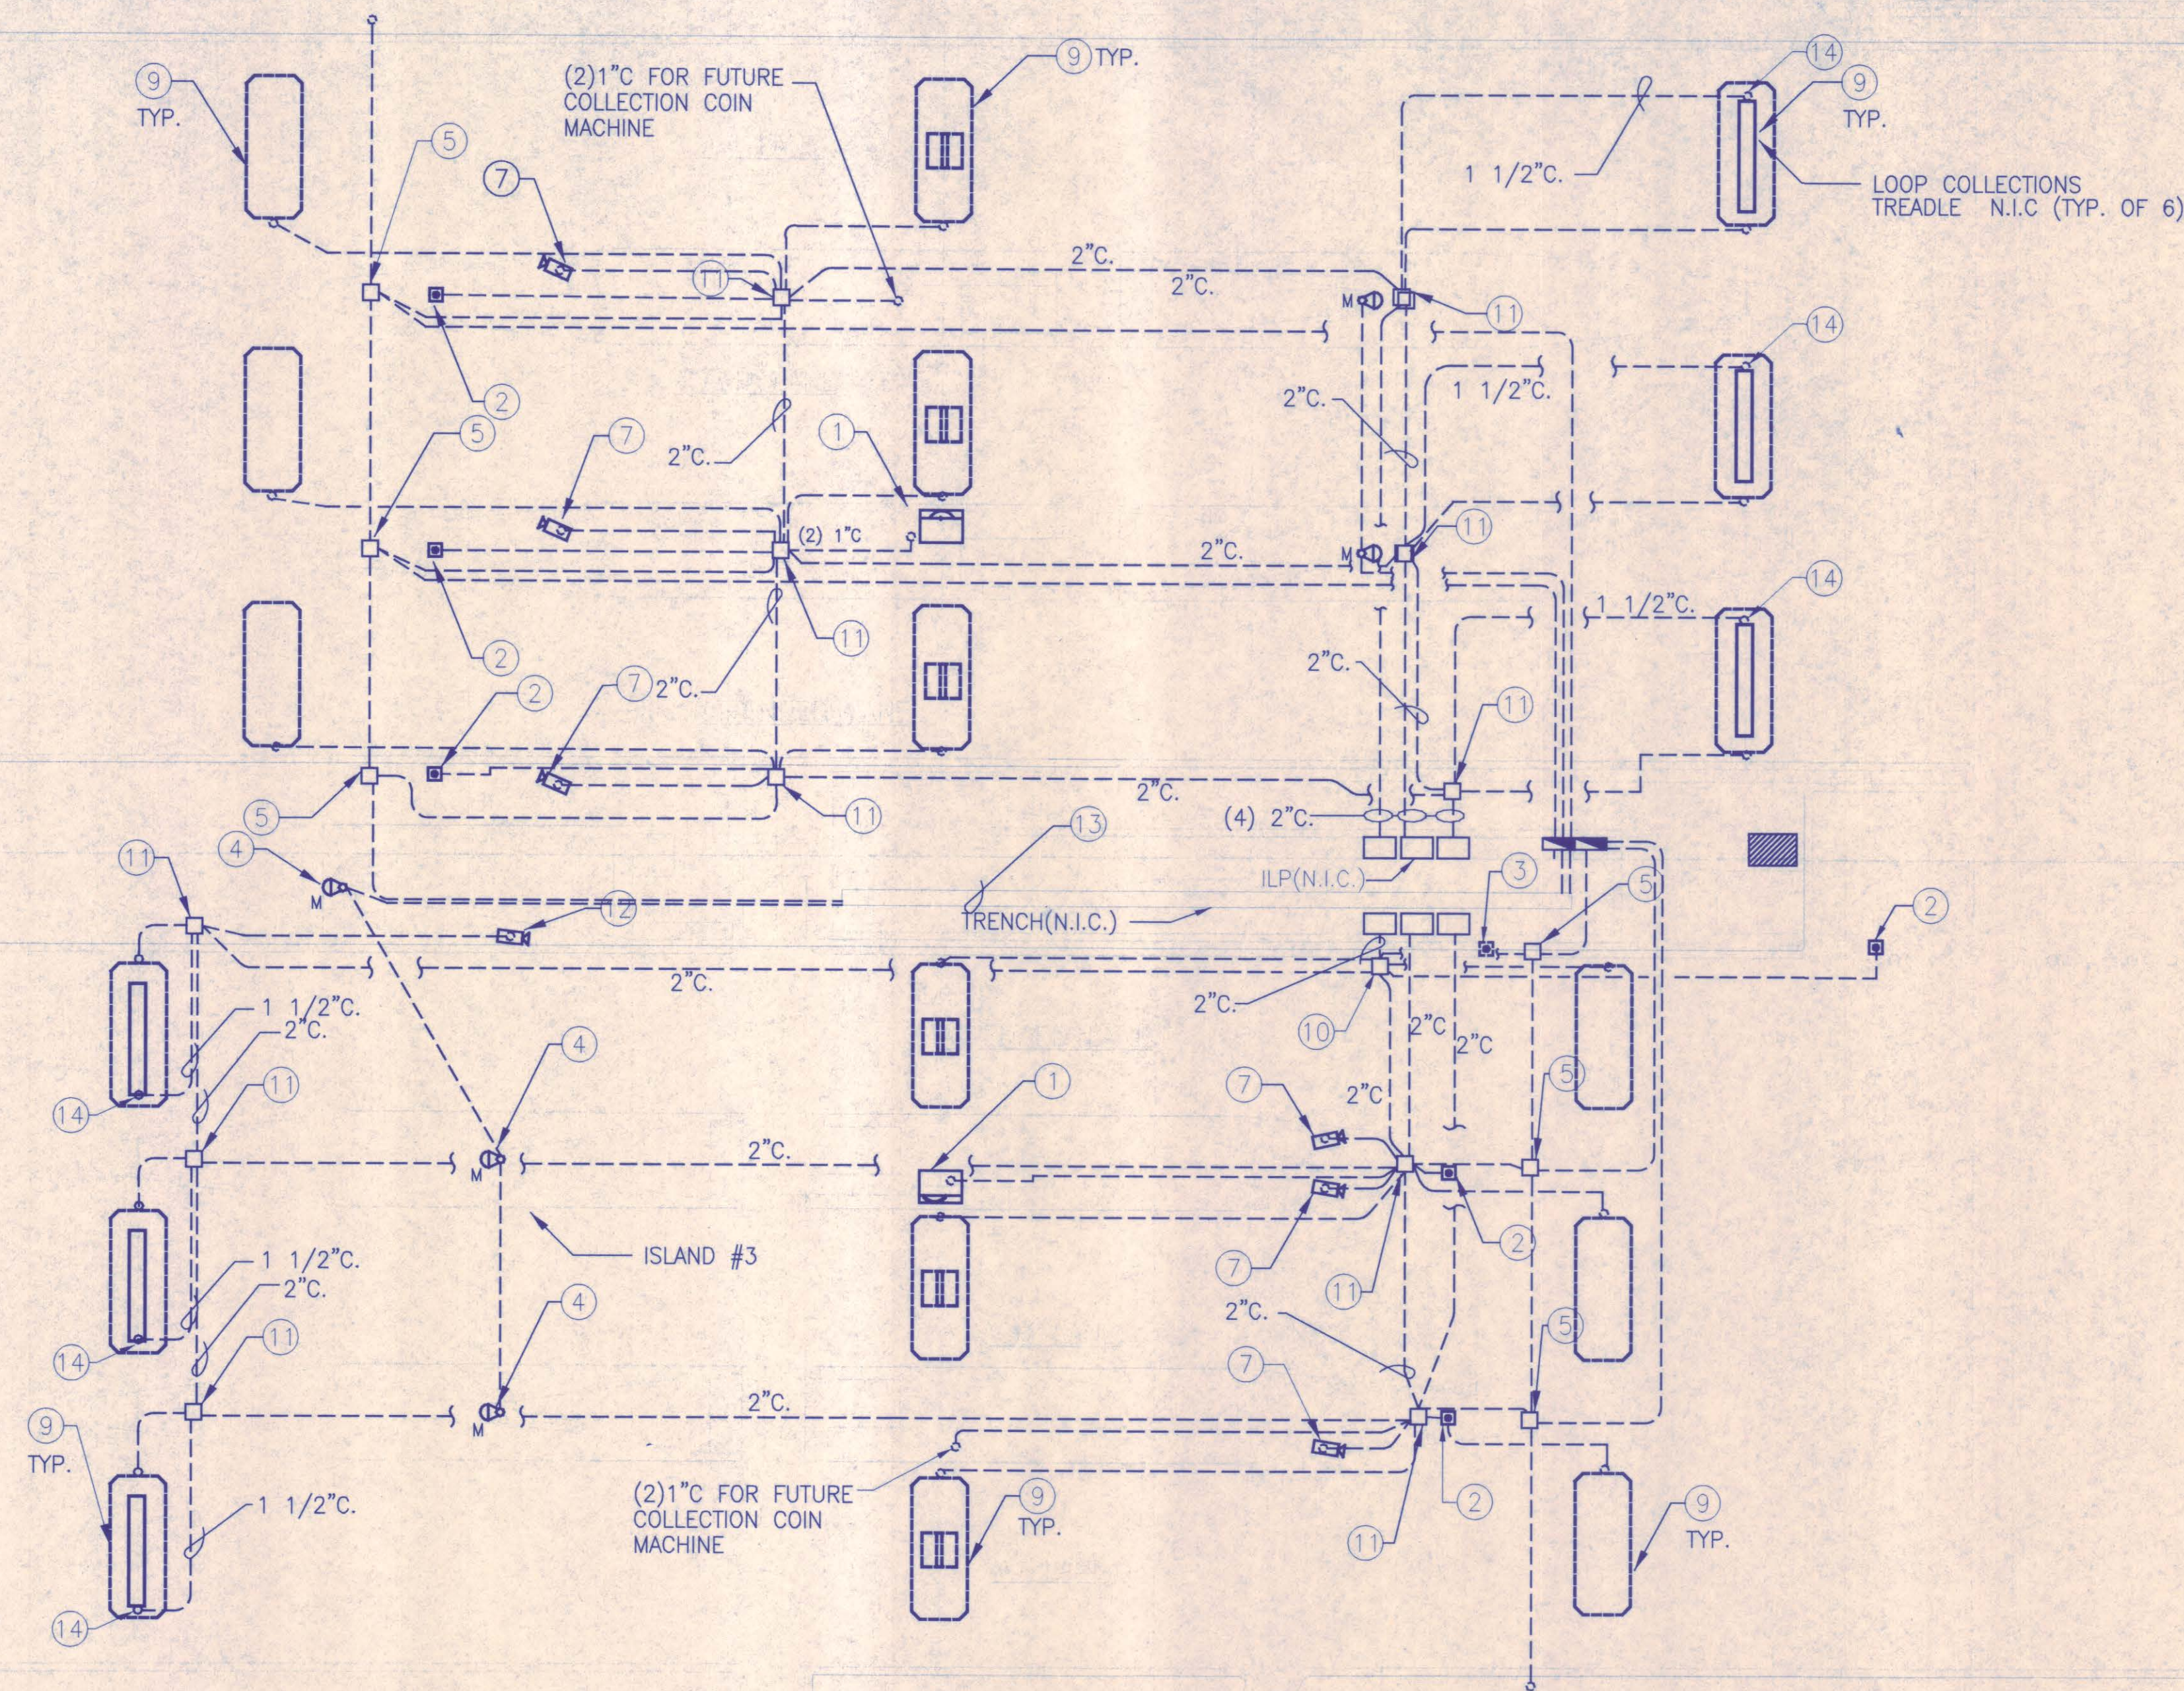

1 ELECTRICAL CONDUIT LAYOUT
SCALE: 1/8"=1'




GENERAL NOTES

1. ALL EQUIPMENT LOCATIONS ARE APPROXIMATE. EXACT LOCATIONS TO BE VERIFIED WITH CIVIL DRAWINGS AND NTTA.
2. ALL LANE EQUIPMENT CONDUITS ARE 1" UNLESS STATED OTHERWISE.
3. REFER TO 2/AT-E6.2 FOR PLUGGING AND EMPTY CONDUITS, UNLESS STATED OTHERWISE.

KEY NOTES

- 1 TOLL COLLECTION COIN MACHINE, N.I.C. REFER TO 2/AT-E6.2.
- 2 TOLL COLLECTION LIGHT N.I.C. REFER TO 2/AT-E6.2. STUB CONDUIT AT LOCATION DIRECTED BY NTTA.
- 3 ALTERNATE LOCATION OF THE TOLL COLLECTION LIGHT (N.I.C.) REFER TO 2/AT-E3.1.
- 4 LANE OBSTRUCTION LIGHT BY CONTRACTOR. REFER TO 4/AT-E6.2.
- 5 12"x12"x8" PULLBOX CASTMETAL, FLUSH TOP, WATERTIGHT, UL TYPE 4 FOR FUTURE LIGHT CURTAIN N.I.C.
- 6 NOT USED
- 7 VIOLATION CAMERA N.I.C. STUB CONDUIT AT LOCATION DIRECTED BY NTTA. REFER TO 2/AT-E6.2.
- 8 NOT USED
- 9 LOOP DETECTOR N.I.C. VERIFY WITH CIVIL DRAWINGS FOR EXACT LOCATION. CONTRACTOR TO VERIFY WITH INSTALLER FOR ANY ADDITIONAL ELECTRICAL INFORMATION.
- 10 UNDERGROUND PULL BOX. PULLBOX SHALL BE LOCATED ON ISLAND #3. REFER TO 5/AT-E6.2.
- 11 UNDERGROUND PULL BOX. REFER TO 5/AT-E6.2 FOR INSTALLATION.
- 12 SURVEILLANCE CAMERA MOUNTED ON PEDESTAL. REFER TO 2/AT-E3.1 AND 2/AT-E4.1 FOR POWER REQUIREMENTS.
- 13 RUN CONDUITS TO TRENCH. REFER TO AT-E3.1 AND ARCH. DRAWINGS FOR LOCATION. STUB CONDUITS INTO BOTTOM OF TRENCH DUCT.
- 14 REFER TO 9/AT-E6.2 FOR TREADLE DETAIL AND TO CIVIL DRAWINGS RX-C3.2 FOR MORE INFORMATION.

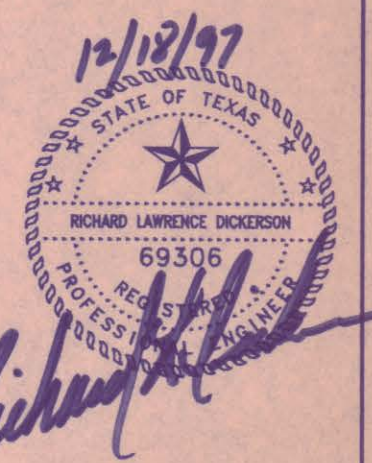

NO.	REVISION	BY	DATE
NORTH TEXAS TOLLWAY AUTHORITY ADDISON AIRPORT TUNNEL BARRIER TOLL PLAZA			
ELECTRICAL CONDUIT LAYOUT LIGHTING PLAN			
AGUIRRE Corporation 18700 PARK CENTRAL DRIVE 18 TH FLOOR DALLAS TEXAS 75281 TEL. (972) 786-1808			SECTION XIII
CHECKED <i>FLD</i>	DATE 12/18/97	DESIGNED <i>FA</i>	DATE 12/20/96
CHECKED <i>FLD</i>	DATE 12/18/97	SCALE 1/8"=1'-0"	
CONTRACT NO. DNT-290	SHEET 46	OF 53	


AT-E1.2

GENERAL NOTES


- 1. FOR LIGHT FIXTURE TYPE REFER TO LIGHT FIXTURE SCHEDULE ON AT-E0.1.
- 2. ALL HOMERUNS UNDER CANOPY TO BE ROUTED TO PULLBOX AS INDICATED BY KEYNOTE-1.

KEY NOTES


- ① 18"x18"x8" PULLBOX-REFER TO 3/AT-E6.1.
- ② ROUTE THROUGH LIGHTING CONTACTOR IN ELECTRICAL ROOM.
- ③ PHOTOCELL FACE NORTH AWAY FROM LOCAL LIGHT SOURCES. PROVIDE FACE SHIELD. REFER TO 2/AT-E6.3 FOR CONNECTION DIAGRAM. INSTALL PER MANUFACTURER REQUIREMENTS AND SEAL ALL ROOF PENETRATION AS DIRECTED BY ARCHITECT.
- ④ WALL PACKS-REFER TO A5.1 FOR ELEVATION. RUN CIRCUIT THRU CONTACTOR-REFER TO 2/AT-E6.3
- ⑤ MOUNT FIXTURE TO BOTTOM OF DECK-REFER TO 7/AT-E6.2 TYPICAL.

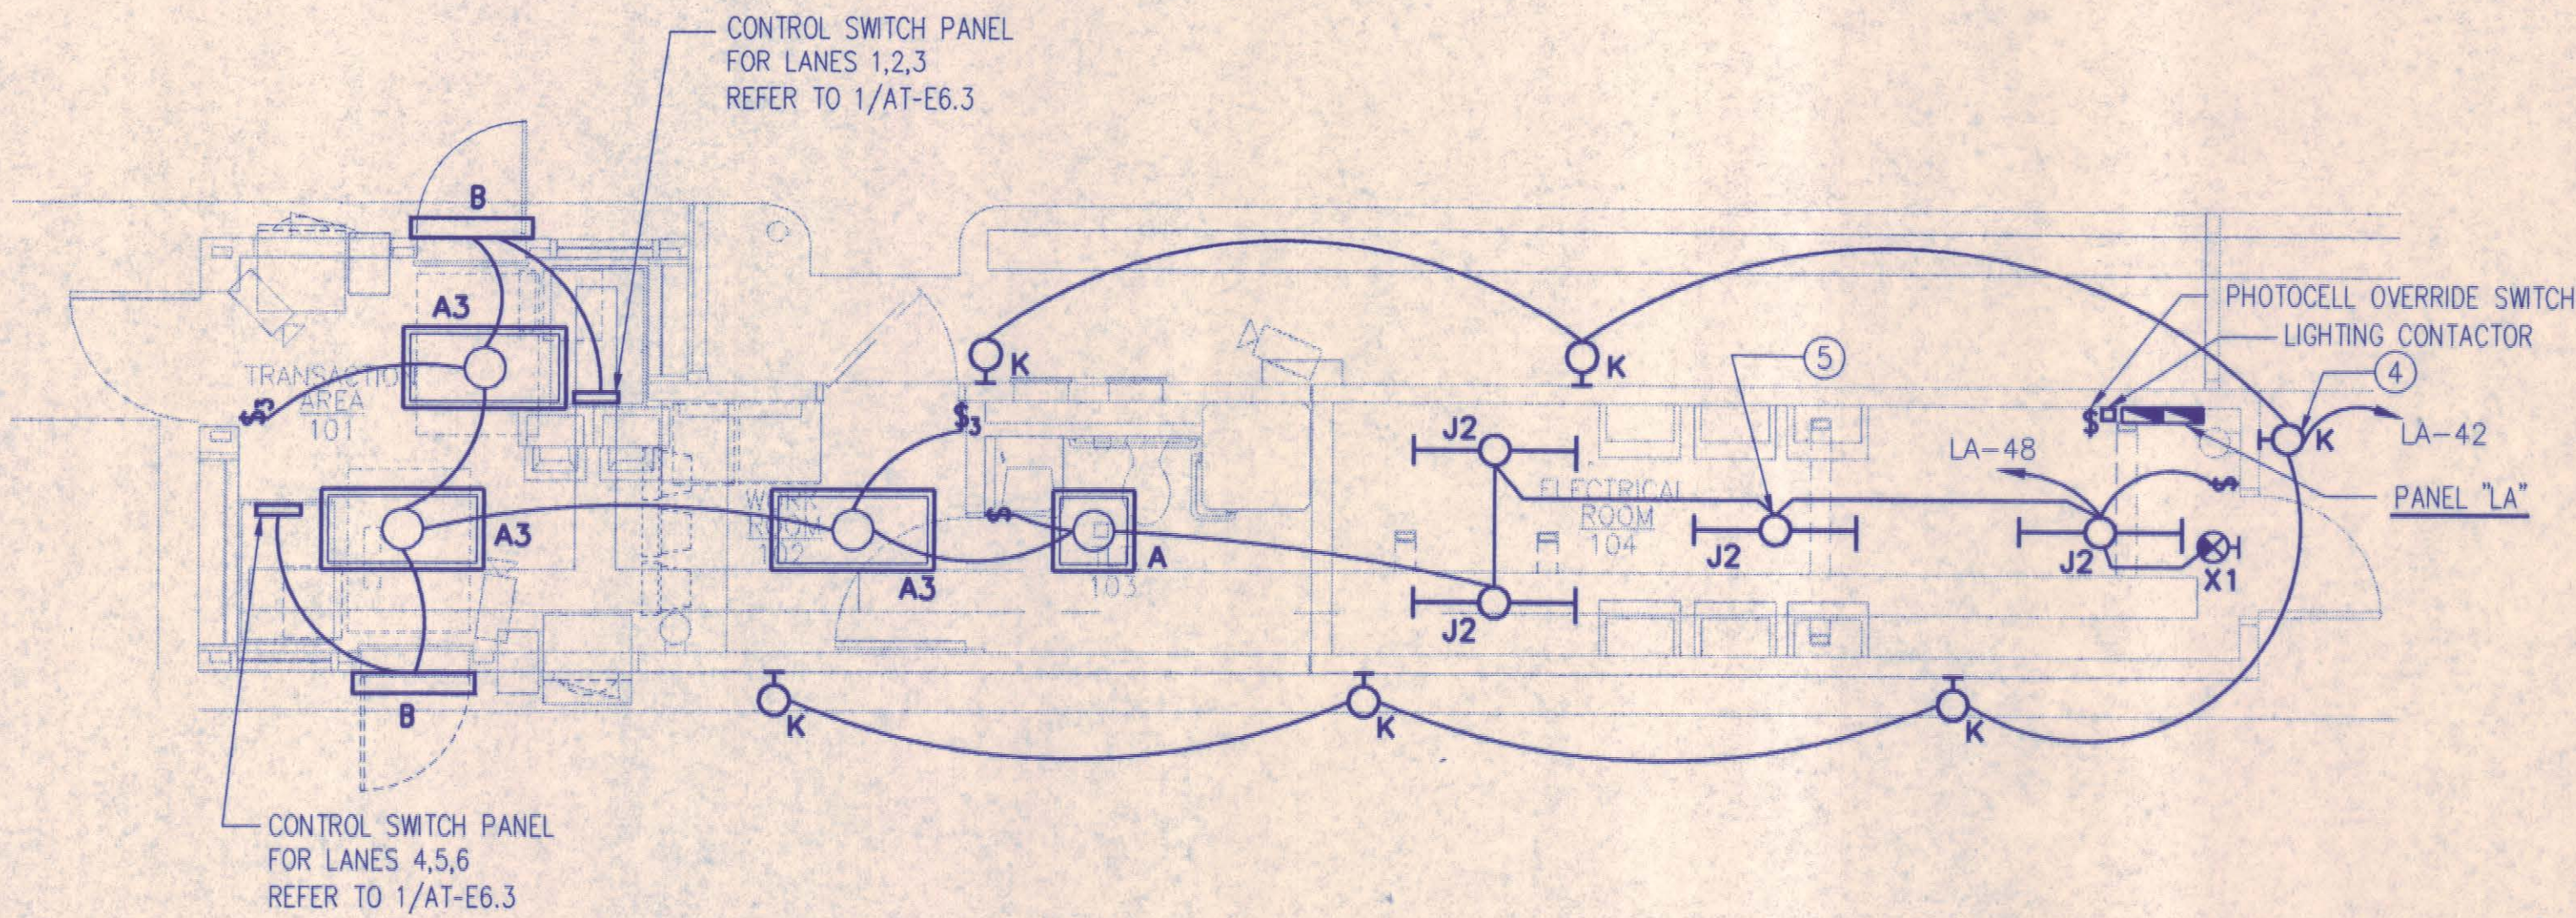

2 ELEC. BOOTH LIGHTING PLAN
SCALE: 1/4" = 1'-0"

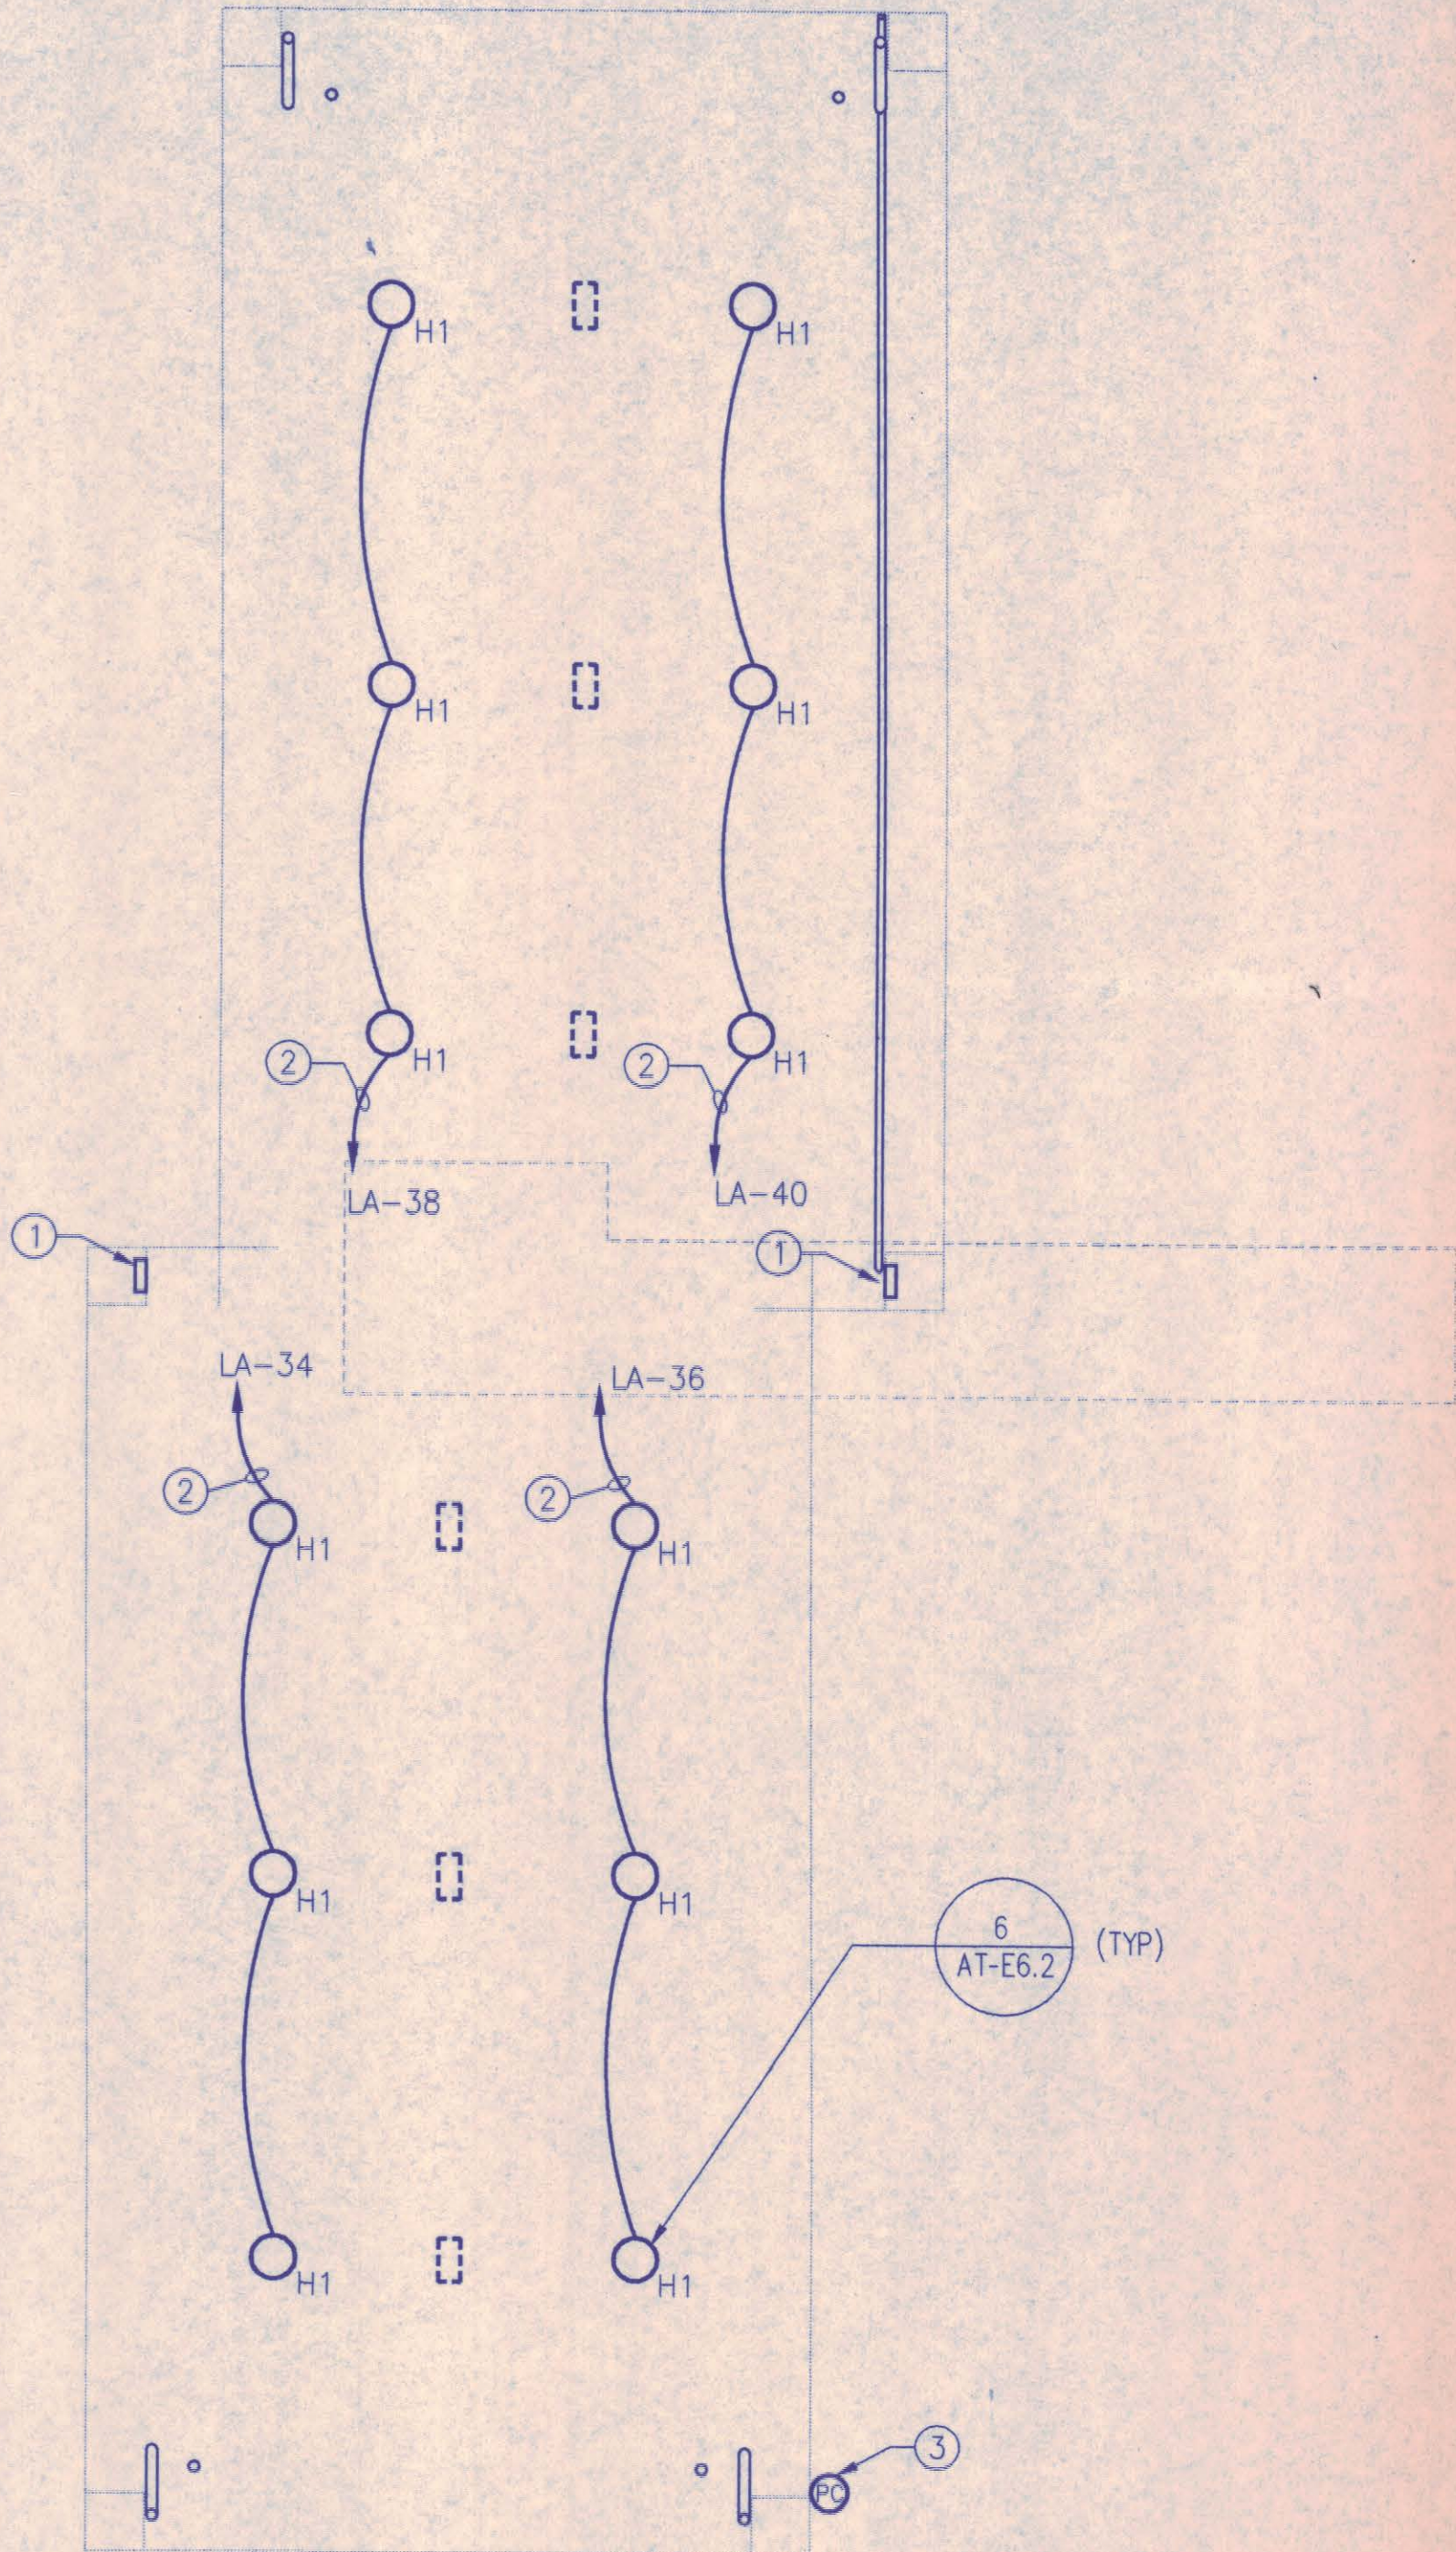


1 ELEC. CANOPY LIGHTING PLAN
SCALE: 1/8" = 1'-0"

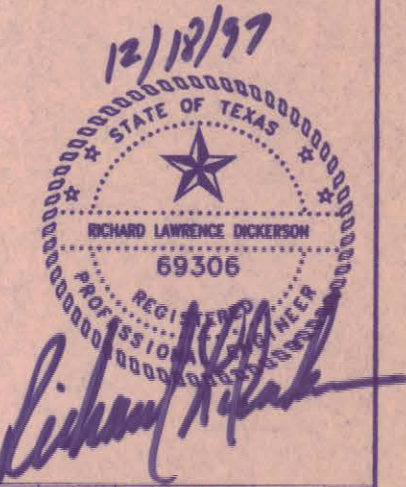


NO.	REVISION	BY	DATE
NORTH TEXAS TOLLWAY AUTHORITY ADDISON AIRPORT TUNNEL BARRIER TOLL PLAZA			
ELECTRICAL LIGHTING PLANS			
AGUIRRE CORPORATION 18700 PARK CENTRAL DRIVE 15 TH FLOOR DALLAS TEXAS 75281 TEL. (214) 788-9500			SECTION XIII
CHECKED <i>RLO</i>	DATE 12/18/97	DESIGNED <i>FA</i>	DATE 12/20/98
CHECKED <i>Jey</i>	DATE 12/18/97	SCALE AS NOTED	
CONTRACT NO. DNT-290		SHEET 47 OF 53	


AT-E2.1

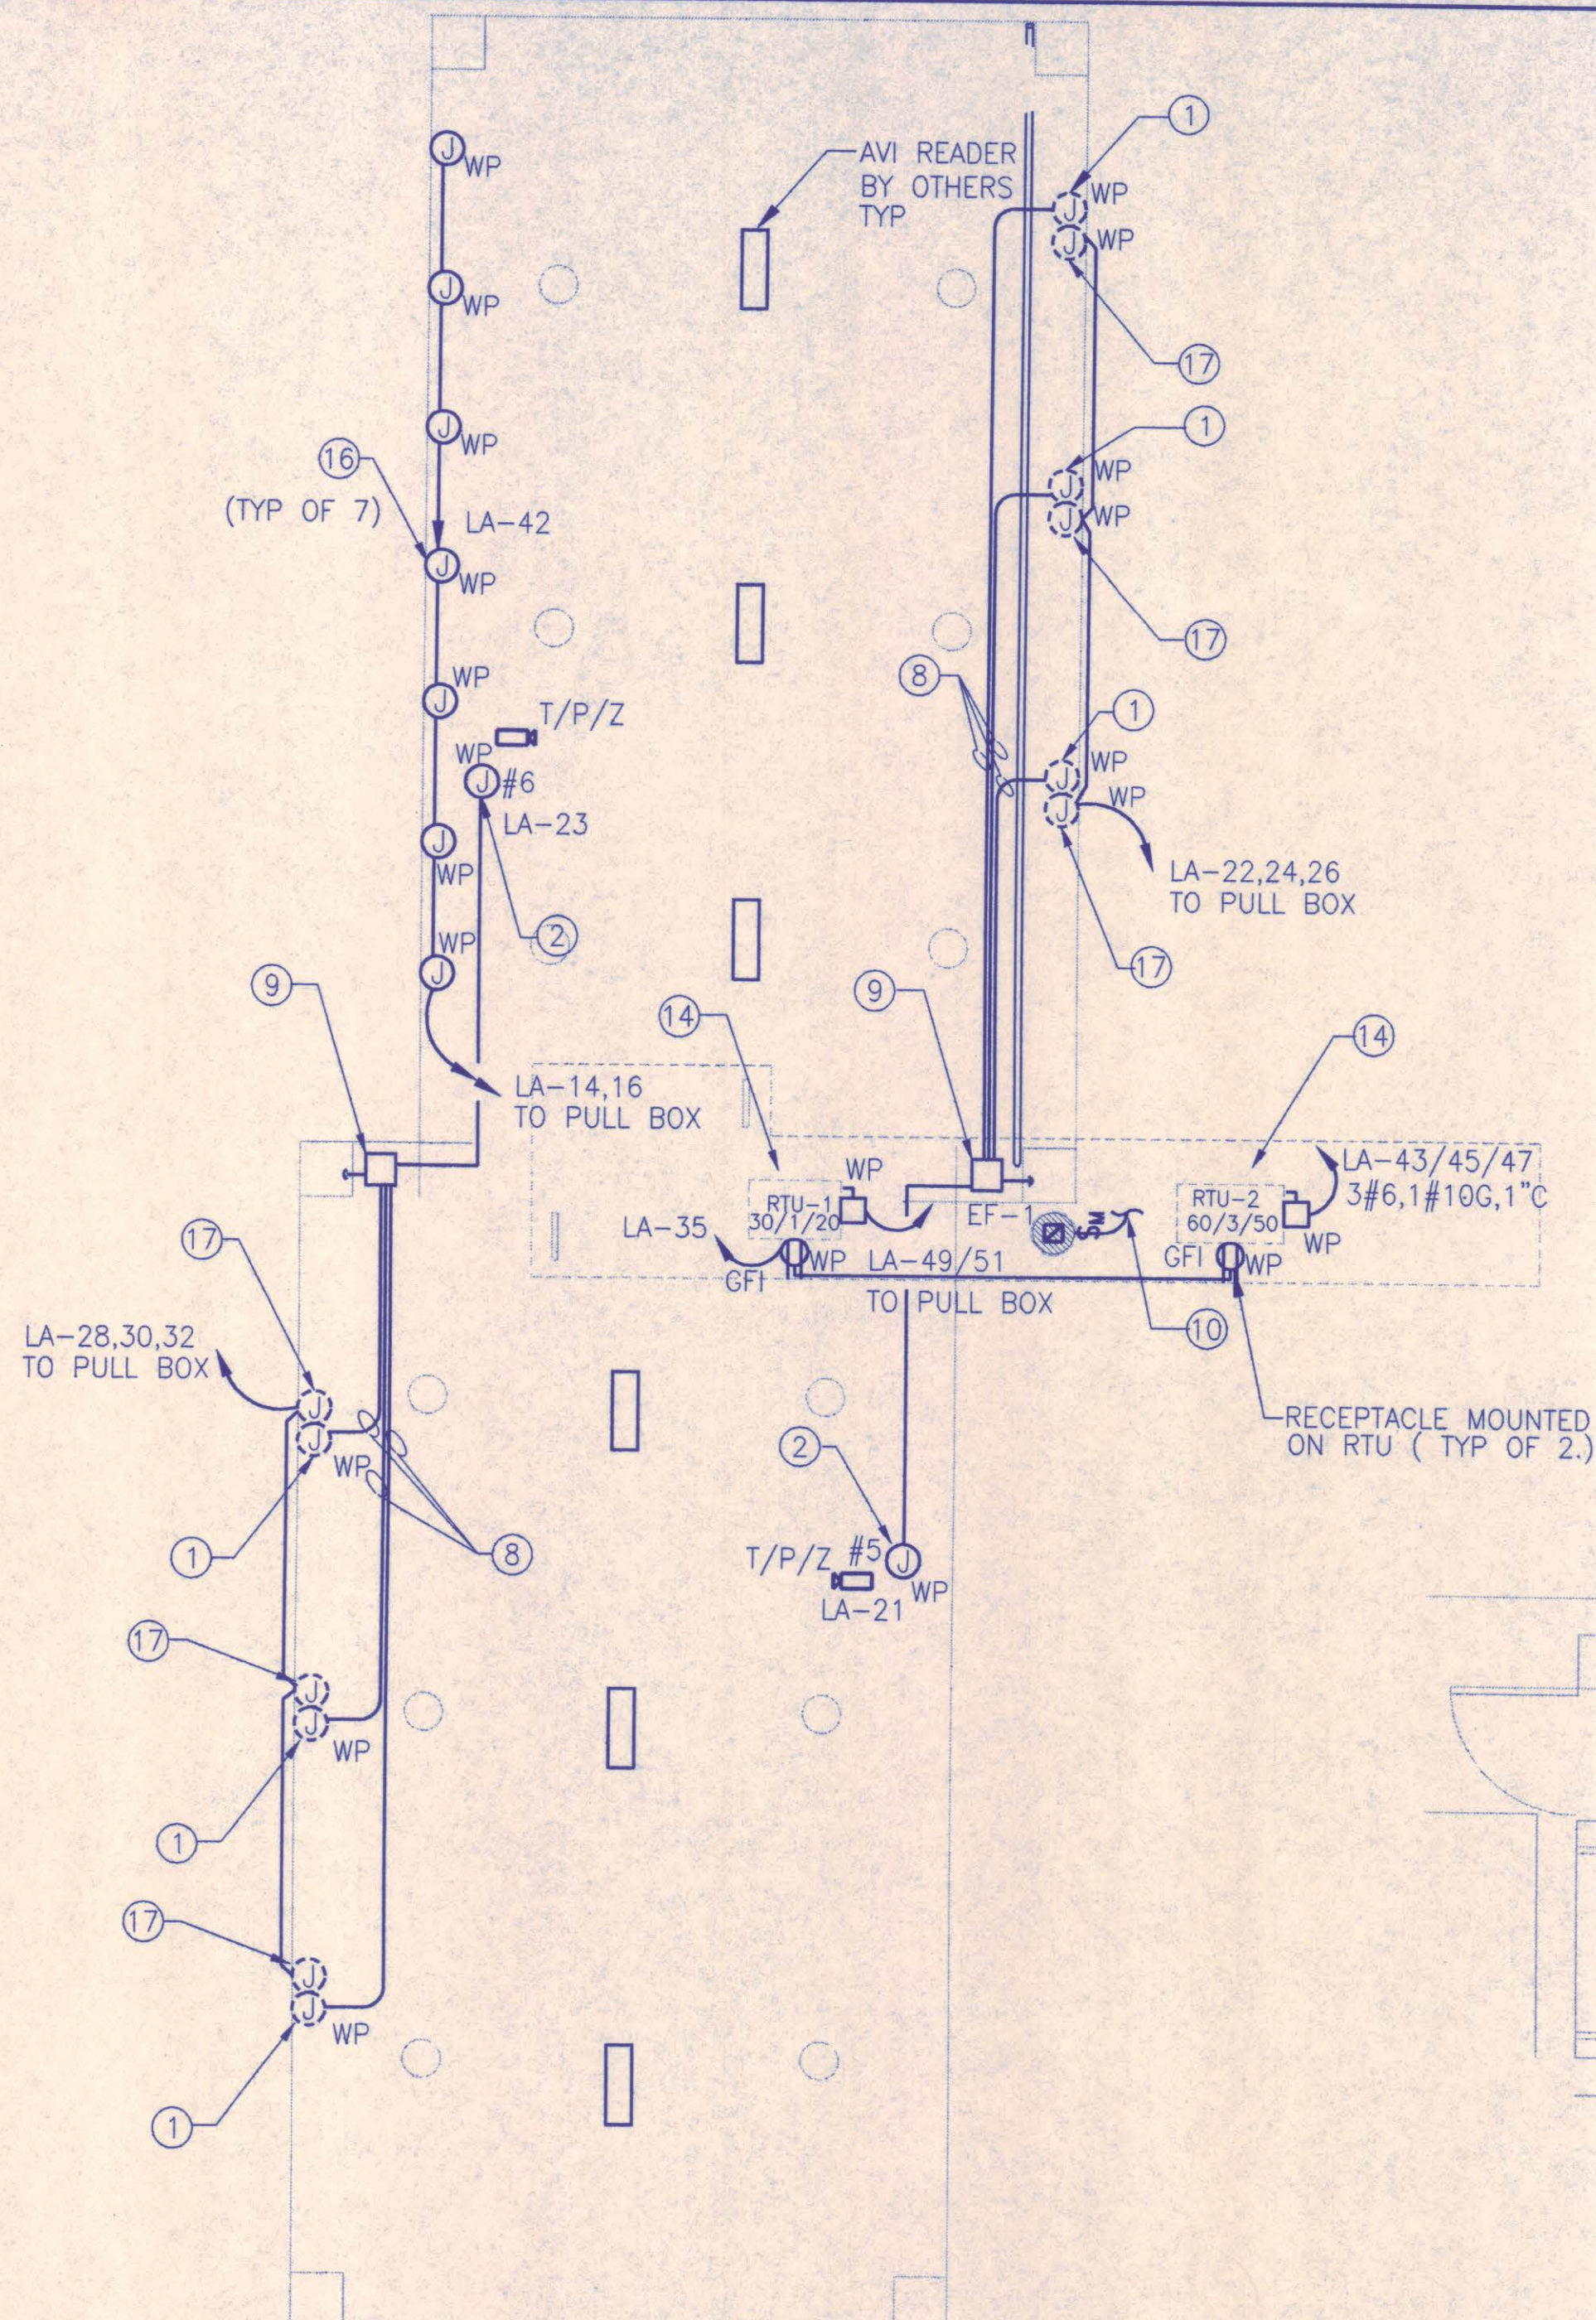

1 ELEC. CANOPY POWER PLAN
SCALE: 1/8" = 1'-0"

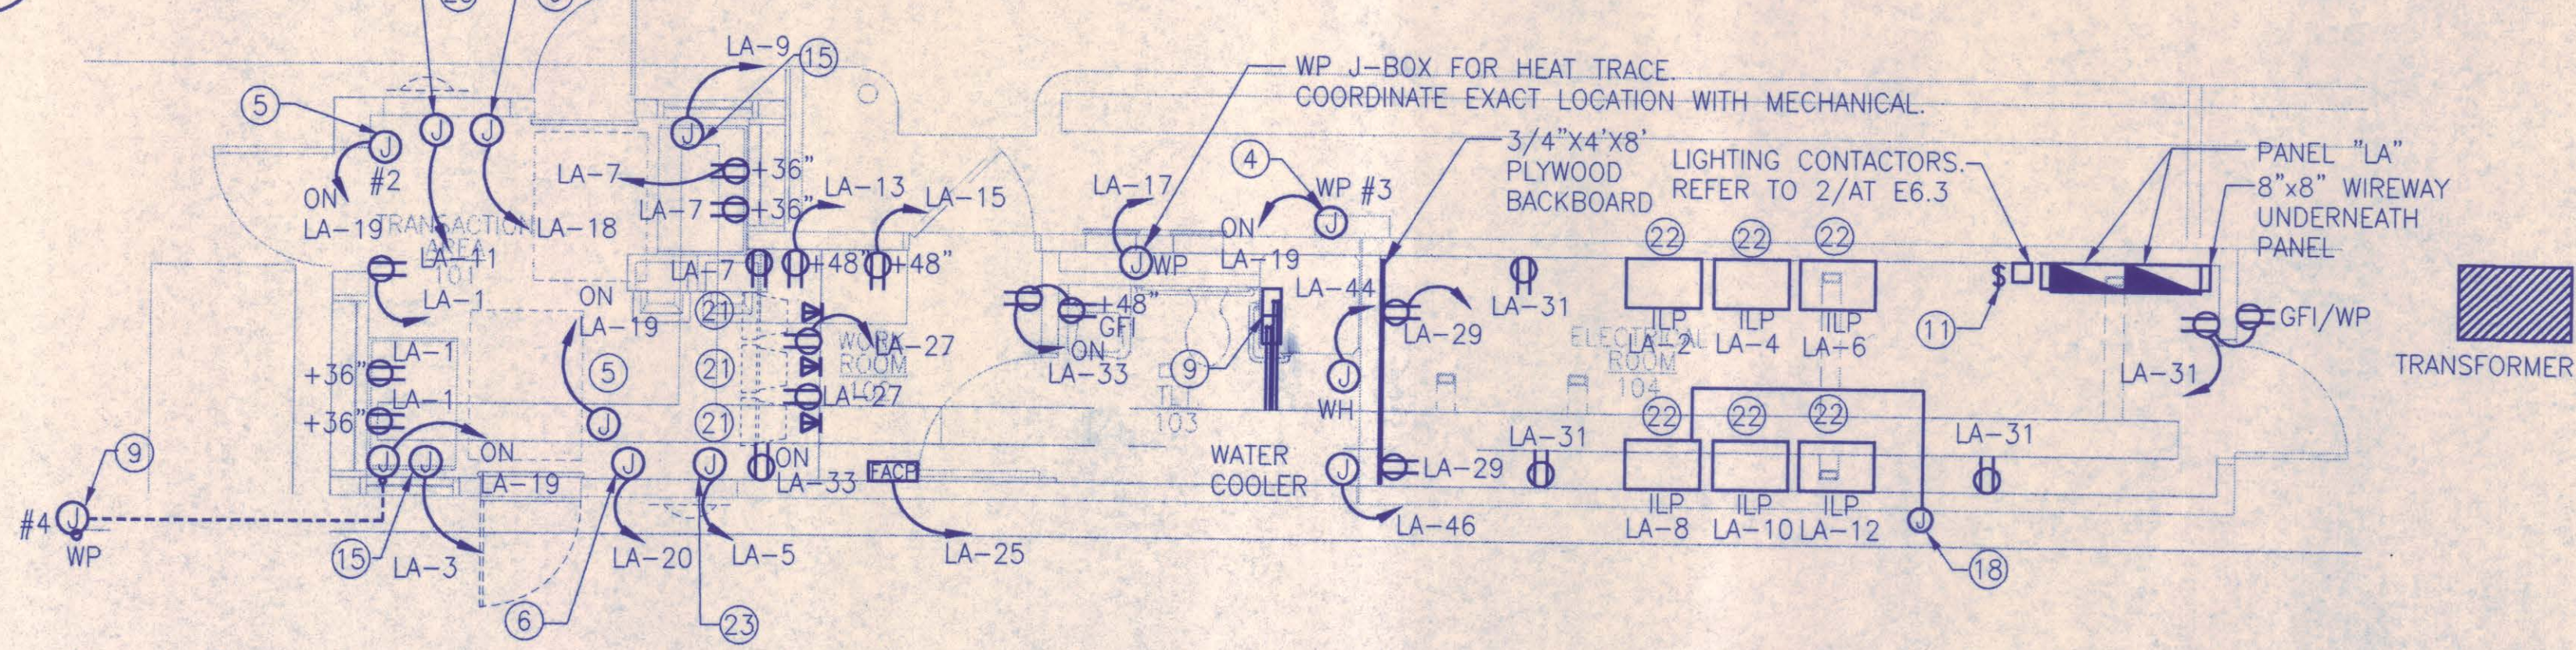

2 ELEC. BOOTH POWER PLAN
SCALE: 1/4" = 1'-0"

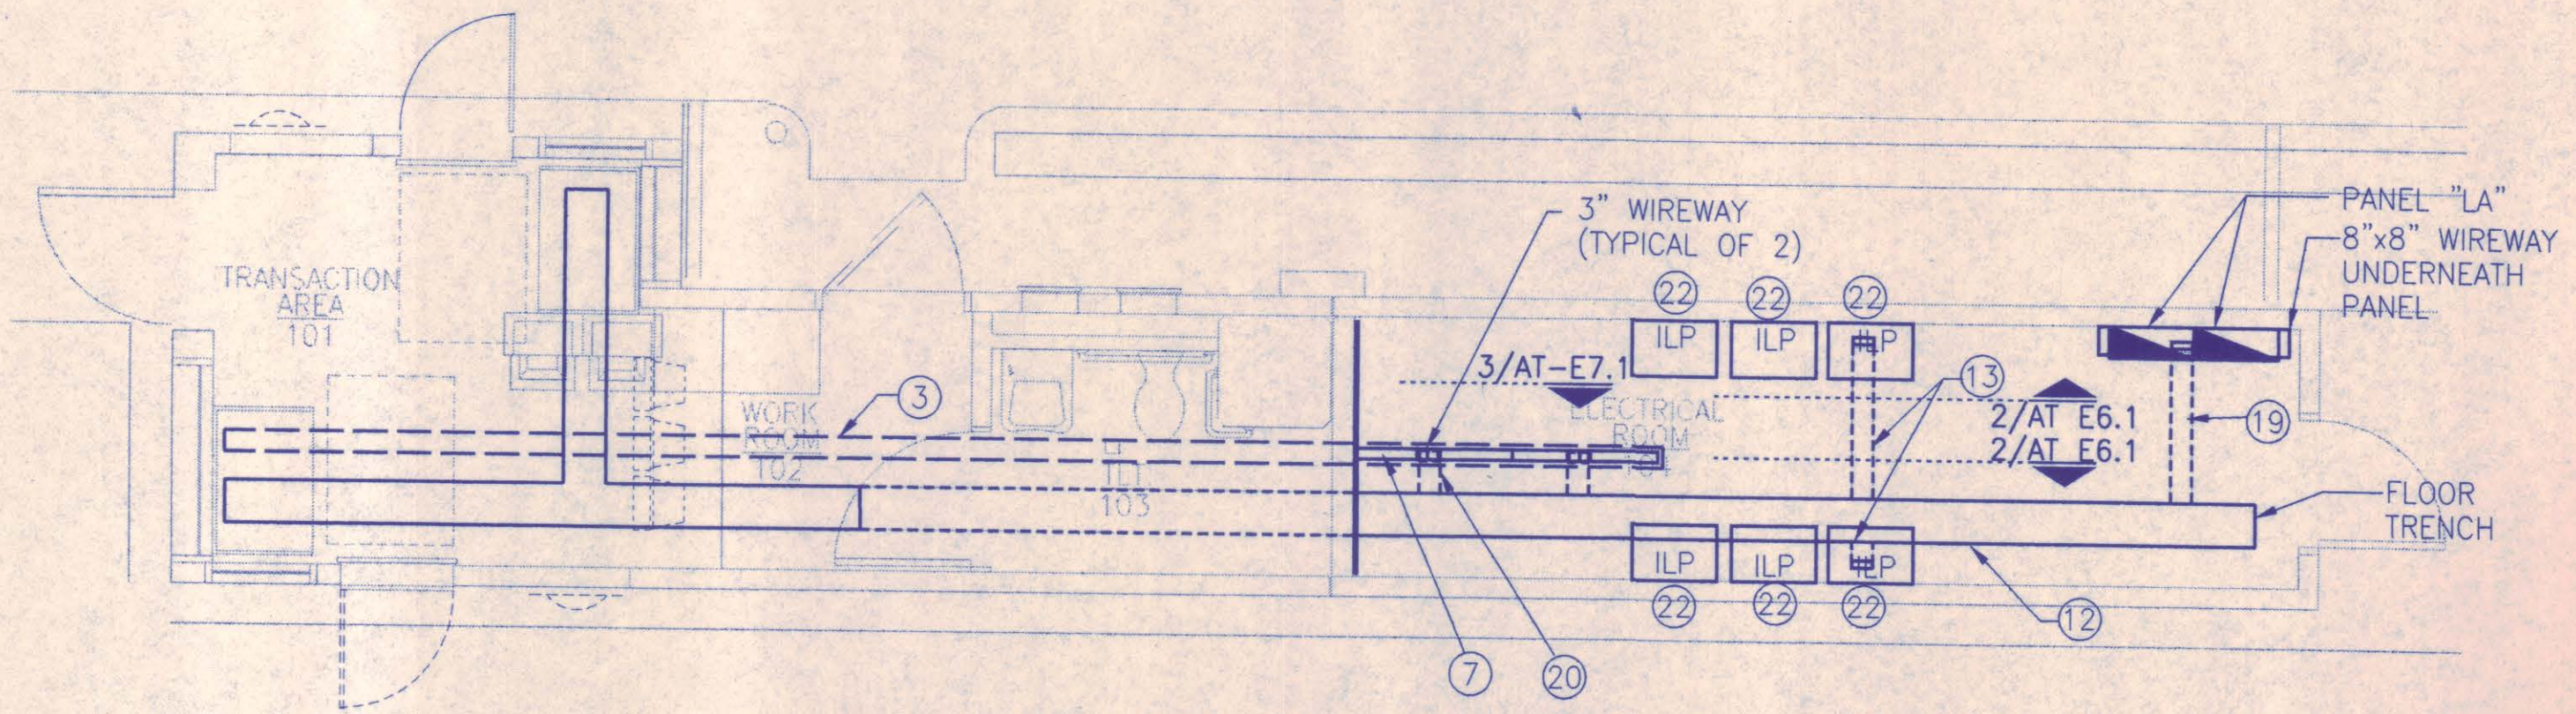

3 ELEC. BOOTH POWER PLAN
SCALE: 1/4" = 1'-0"

KEY NOTES (CONT'D)


- 15 UNDER COUNTER HEATER FINAL CONNECTIONS BY CONTRACTOR. VERIFY REQUIREMENTS WITH MECHANICAL.
- 16 ADDISON AIRPORT TUNNEL NEON SIGN PROVIDED AND INSTALLED BY OTHERS. CONTRACTOR TO PROVIDE WEATHER-PROOF J-BOX AS REQUIRED. VERIFY LOCATION OF J-BOXES WITH SIGN INSTALLER. RUN CIRCUIT THRU CONTACTOR. REFER TO 2/AT-E6.3.
- 17 WEATHER-PROOF J-BOX FOR LANE ICON SIGN. RUN CIRCUITS THRU CONTACTOR. REFER TO 2/AT-E6.3. VERIFY EXACT LOCATION AND ANY OTHER REQUIREMENTS.
- 18 PROVIDE 4"x4" WP JBOX FLUSHED ON THE OUTSIDE WALL AT 48" AFF AND RUN 1" C TO ILP FOR AN ALTERNATE FUTURE LOCATION OF THE TOLL COLLECTION LIGHT (N.I.C)
- 19 UNDER FLOOR DUCT FROM TRENCH TO 8" WIREWAY INSTALLED UNDERNEATH PANEL "LA.". REFER TO 2/AT-E6.1.
- 20 UNDERFLOOR DUCT FROM TRENCH TO RACKS (TYPICAL 2 PLACES.)
- 21 TV MONITORS ABOVE. REFER TO 6/AT-A5.1 & 3/AT-A6.1 FOR MOUNTING DETAIL AND LOCATION OF OUTLETS.
- 22 IN LANE PROCESSOR (ILP) WITH CONTROLLER ABOVE N.I.C
- 23 AUTOMATIC COIN MACHINE (N.I.C). VERIFY EXACT LOCATION AND INSTALL PER MANUFACTURER REQUIREMENTS.

GENERAL NOTES

1. ALL EQUIPMENT LOCATIONS ARE APPROXIMATE. EXACT LOCATION TO BE VERIFIED WITH NTTA.
2. ALL POWER CIRCUITS AND COMMUNICATION CONDUITS UNDER CANOPY TO RUN TO JUNCTION BOX AS INDICATED. REFER TO 3/AT-E6.1.
3. ALL CCTV CAMERAS SHALL BE 24VAC. CONTRACTOR TO PROVIDE POWER SUPPLIES AS REQUIRED. COORDINATE REQUIREMENTS WITH MANUFACTURER.

KEY NOTES

- 1 WEATHER-PROOF J-BOX FOR LANE TRAFFIC SIGNAL R/T/G AND "CLOSED" SIGN ON CANOPY. VERIFY LOCATION WITH SIGN INSTALLER. LANE TRAFFIC SIGNALS SHALL BE CONTROLLED VIA ILP FROM THE OPERATOR KEYBOARD. VERIFY REQUIREMENTS WITH ILP EQUIPMENT INSTALLER.
- 2 WEATHER-PROOF J-BOX FOR P/T/Z DOMED CAMERA(S). MOUNTED UNDER CANOPY OVER ISLAND FROM CONCRETE TEE @ 16'-6" AFG TO BOTTOM OF DOME. VERIFY MOUNTING REQUIREMENTS WITH MANUFACTURER.
- 3 6"x4" CABLE TRAY. MOUNT ABOVE LAY-IN CEILING, 12" BELOW ROOF STRUCTURE. USE CABLE TRAY TO RUN ALL LOW VOLTAGE (FIRE, SECURITY, TELEPHONE, ETC.) WIRING.
- 4 WEATHER-PROOF J-BOX FOR CCTV CAMERA MOUNTED 6' AFG ON EXTERIOR WALL. REFER TO 2/AT-E4.1.
- 5 J-BOX FOR CCTV CAMERA MOUNTED ABOVE CEILING IN BOOTH.
- 6 BILL CHANGER(N.I.C). VERIFY EXACT LOCATION AND INSTALL PER MANUFACTURER REQUIREMENTS.
- 7 3KVA UPS INSTALLED IN 19" RACK. LIEBERT MODEL# UPSTATION GX 3000VA 208/120V, BEST, OR EQUAL.
- 8 3/4"C REFER TO 3/AT-E6.3
- 9 PULLBOX AT FLOOR LEVEL WITH UNDERFLOOR CONDUITS REFER TO 3/AT-E6.1.
- 10 EXHAUST FAN SHALL BE SWITCHED WITH RESTROOM LIGHT. COORDINATE EXACT LOCATION WITH MECHANICAL.
- 11 MANUAL OVERRIDE SWITCH FOR PHOTOCELL.
- 12 FLOOR TRENCH. REFER TO ARCHITECTURAL DRAWINGS FOR EXACT LOCATION AND 2/AT-E6.1.
- 13 UNDER FLOOR DUCT FROM TRENCH TO WIREWAY. REFER TO 2/AT-E6.1.
- 14 RTU'S ARE MOUNTED ON THE BOOTH ROOF. REFER TO MECHANICAL DRAWINGS FOR EXACT LOCATION.

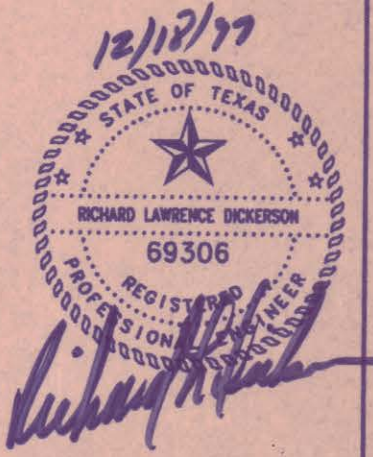

NO.	REVISION	BY	DATE
NORTH TEXAS TOLLWAY AUTHORITY ADDISON AIRPORT TUNNEL BARRIER TOLL PLAZA			
ELECTRICAL POWER/COMMUNICATION PLANS			
AGUIRRE Corporation 32700 PARK CENTRAL DRIVE 10 TH FLOOR DALLAS TEXAS 75281 TEL. (972) 785-1608			SECTION XIII
CHECKED <i>RLD</i>	DATE 12/18/97	DESIGNED FA	DATE 12/20/96
CHECKED <i>TLG</i>	DATE 12/18/97	SCALE AS NOTED	
CONTRACT NO. DNT-290		SHEET 48 OF 53	


AT-E3.1

GENERAL NOTES


1. PROVIDE PULL STRING WITH ALL COMMUNICATION CONDUITS.
2. FOR EXACT LOCATION OF EQUIPMENT IN BOOTH REFER TO ARCHITECTURAL SHEET AT-A10.1.
3. ALL ILP CONTROL WIRING TO RUN IN CONDUIT FROM TRENCH TO LOCATIONS AS SHOWN. TERMINATE CONDUITS WITH BUSHINGS.
4. ALL COMMUNICATION CONDUITS IN THE TOLLBOOTH TO BE 3/4"C UNLESS STATED OTHERWISE.
5. ALL CONDUITS TO CABLE TRAY SHALL TERMINATE WITH BUSHINGS.
6. CABLES ABOVE CEILING SHALL BE PLENUM RATED IF CEILING SPACE IS USED FOR RETURN AIR. COORDINATE WITH MECHANICAL.

KEY NOTES

- ① CARD READER/KEY PAD REFER TO 4/AT-E6.1
- ② 4"x4" J-BOX FLUSHED IN WALL AT 44" AFF FOR TELEPHONE. RUN 3/4" C WITH PULLSTRING TO CABLE TRAY ABOVE.
- ③ 4"x4" WEATHER PROOF J-BOX FLUSHED IN WALL AT 46" AFF FOR PATRON FARE INDICATOR (NIC). RUN 1" C CONCEALED IN WALL TO FLOOR TRENCH.
- ④ CCTV CAMERA. PROVIDE 4" OCTAGONAL J-BOX ABOVE CEILING AT LOCATION INDICATED. RUN 3/4"C TO CABLE TRAY.
- ⑤ 4"x4" J-BOX FOR MAGNETIC DOOR MONITOR SWITCH AND MAGNETIC DOOR LOCKING UNIT. INSTALL BOX ABOVE CEILING PER DETAIL 4/AT-E6.1. RUN 1" C TO CABLE TRAY.
- ⑥ PANIC BUTTON/SWITCH (NIC) MOUNTED AT 36" AFF. RUN 3/4"C CONCEALED IN WALL TO CABLE TRAY.
- ⑦ WALL MOUNTED CCTV CAMERA. PROVIDE 2"x4" WEATHER PROOF J-BOX FLUSHED ON THE OUTSIDE WALL AT 6" AFF. RUN 3/4"C CONCEALED IN WALL TO CABLE TRAY.
- ⑧ PAN/TILT/ZOOM CAMERA IN WEATHERPROOF DOME. LOCATED BELOW CANOPY JOISTS.
- ⑨ COMMUNICATIONS PULLBOX. REFER TO DETAIL 3/AT-E6.1.
- ⑩ PROVIDE FLUSH MOUNTED DOUBLE GANG J-BOX FLUSHED IN WALL AT 36"A.F.F. RUN (2) 1"C TO FLOOR TRENCH FOR ILP CONTROL.
- ⑪ 4"x4" J-BOX FLUSHED IN WALL AT 4" AFF FOR THE AUTOMATIC COIN MACHINE (NIC). RUN 1"C TO FLOOR TRENCH FOR ILP CONTROL.
- ⑫ PROVIDE 4"x4" J-BOX AND RUN 1"C FROM BOX AT EACH TOLL COLLECTION TO CABLE TRAY.
- ⑬ CAPC/FP. REFER TO SPECIFICATIONS FOR QUANTITY. CAPC/FP SHALL BE WIRED TO UPS SYSTEM. REFER TO DETAIL 3/AT-E7.1

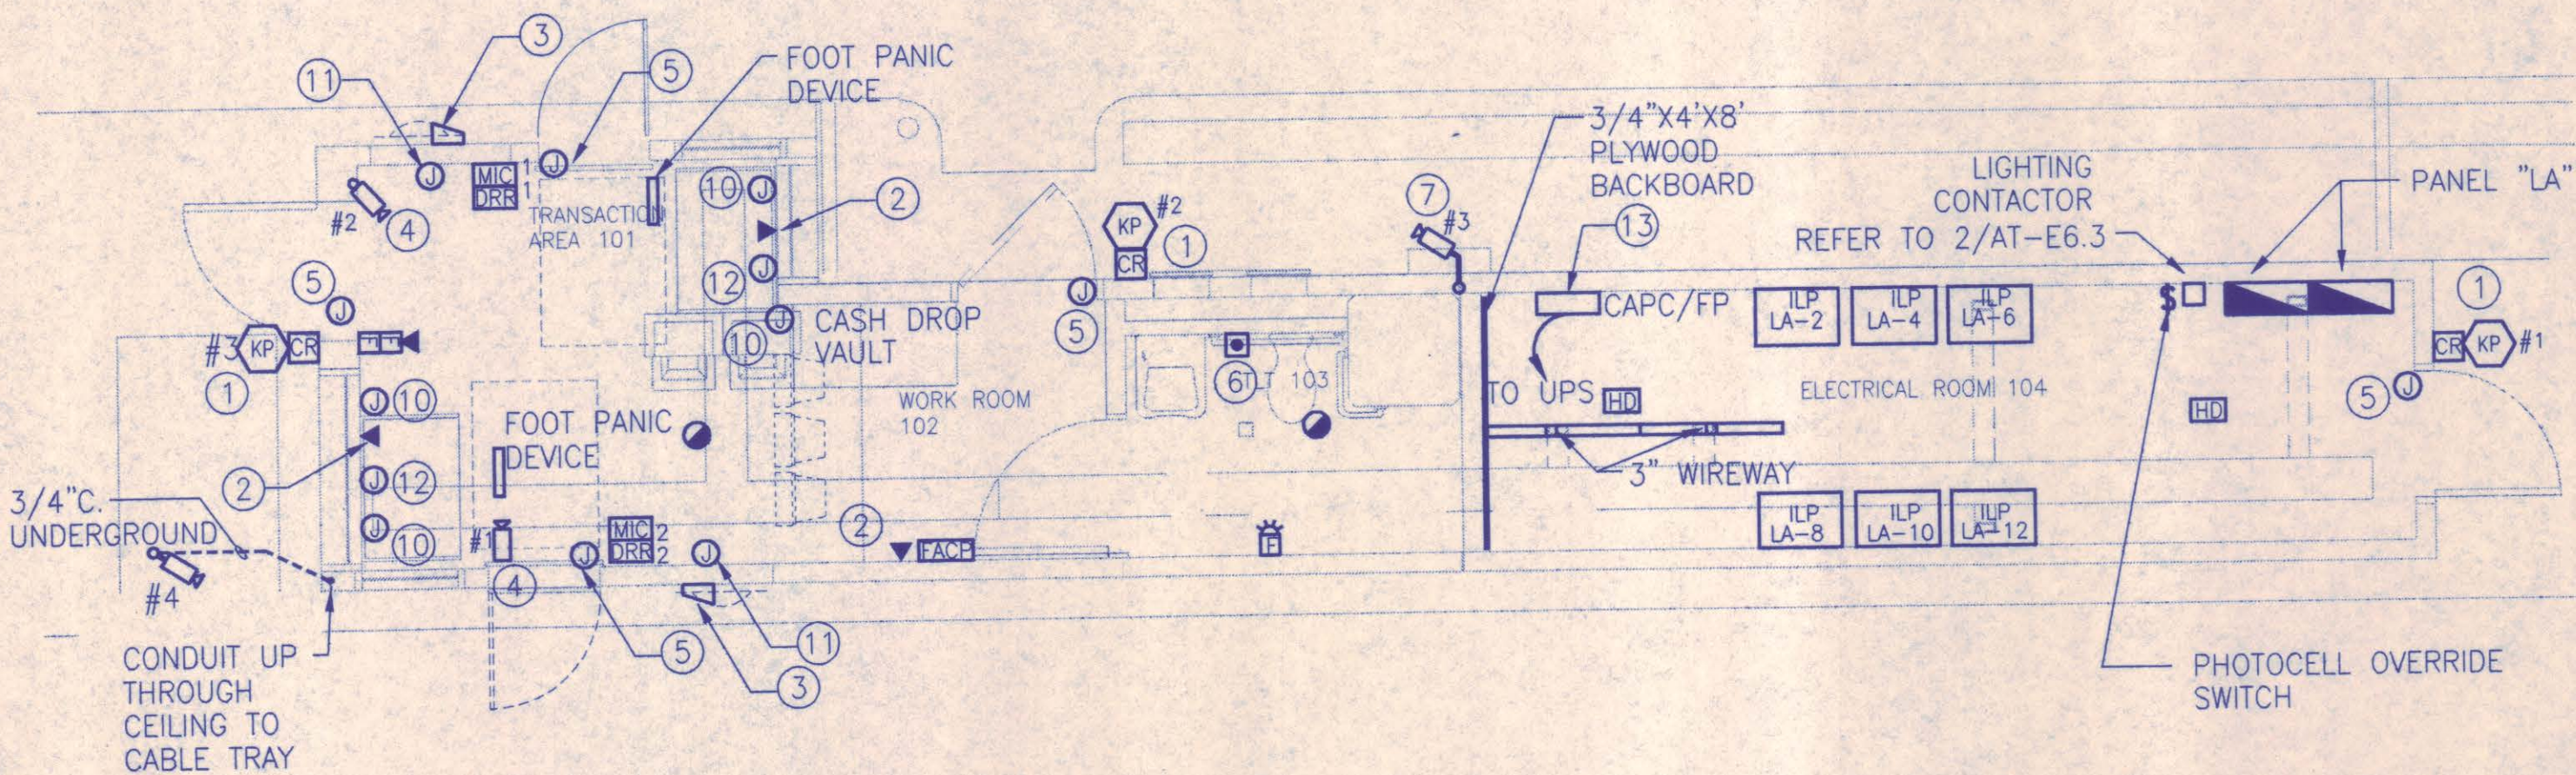

2 ELEC. BOOTH COMMUNICATIONS PLAN
SCALE: 1/4" = 1'-0"
TAATECB1.DWG

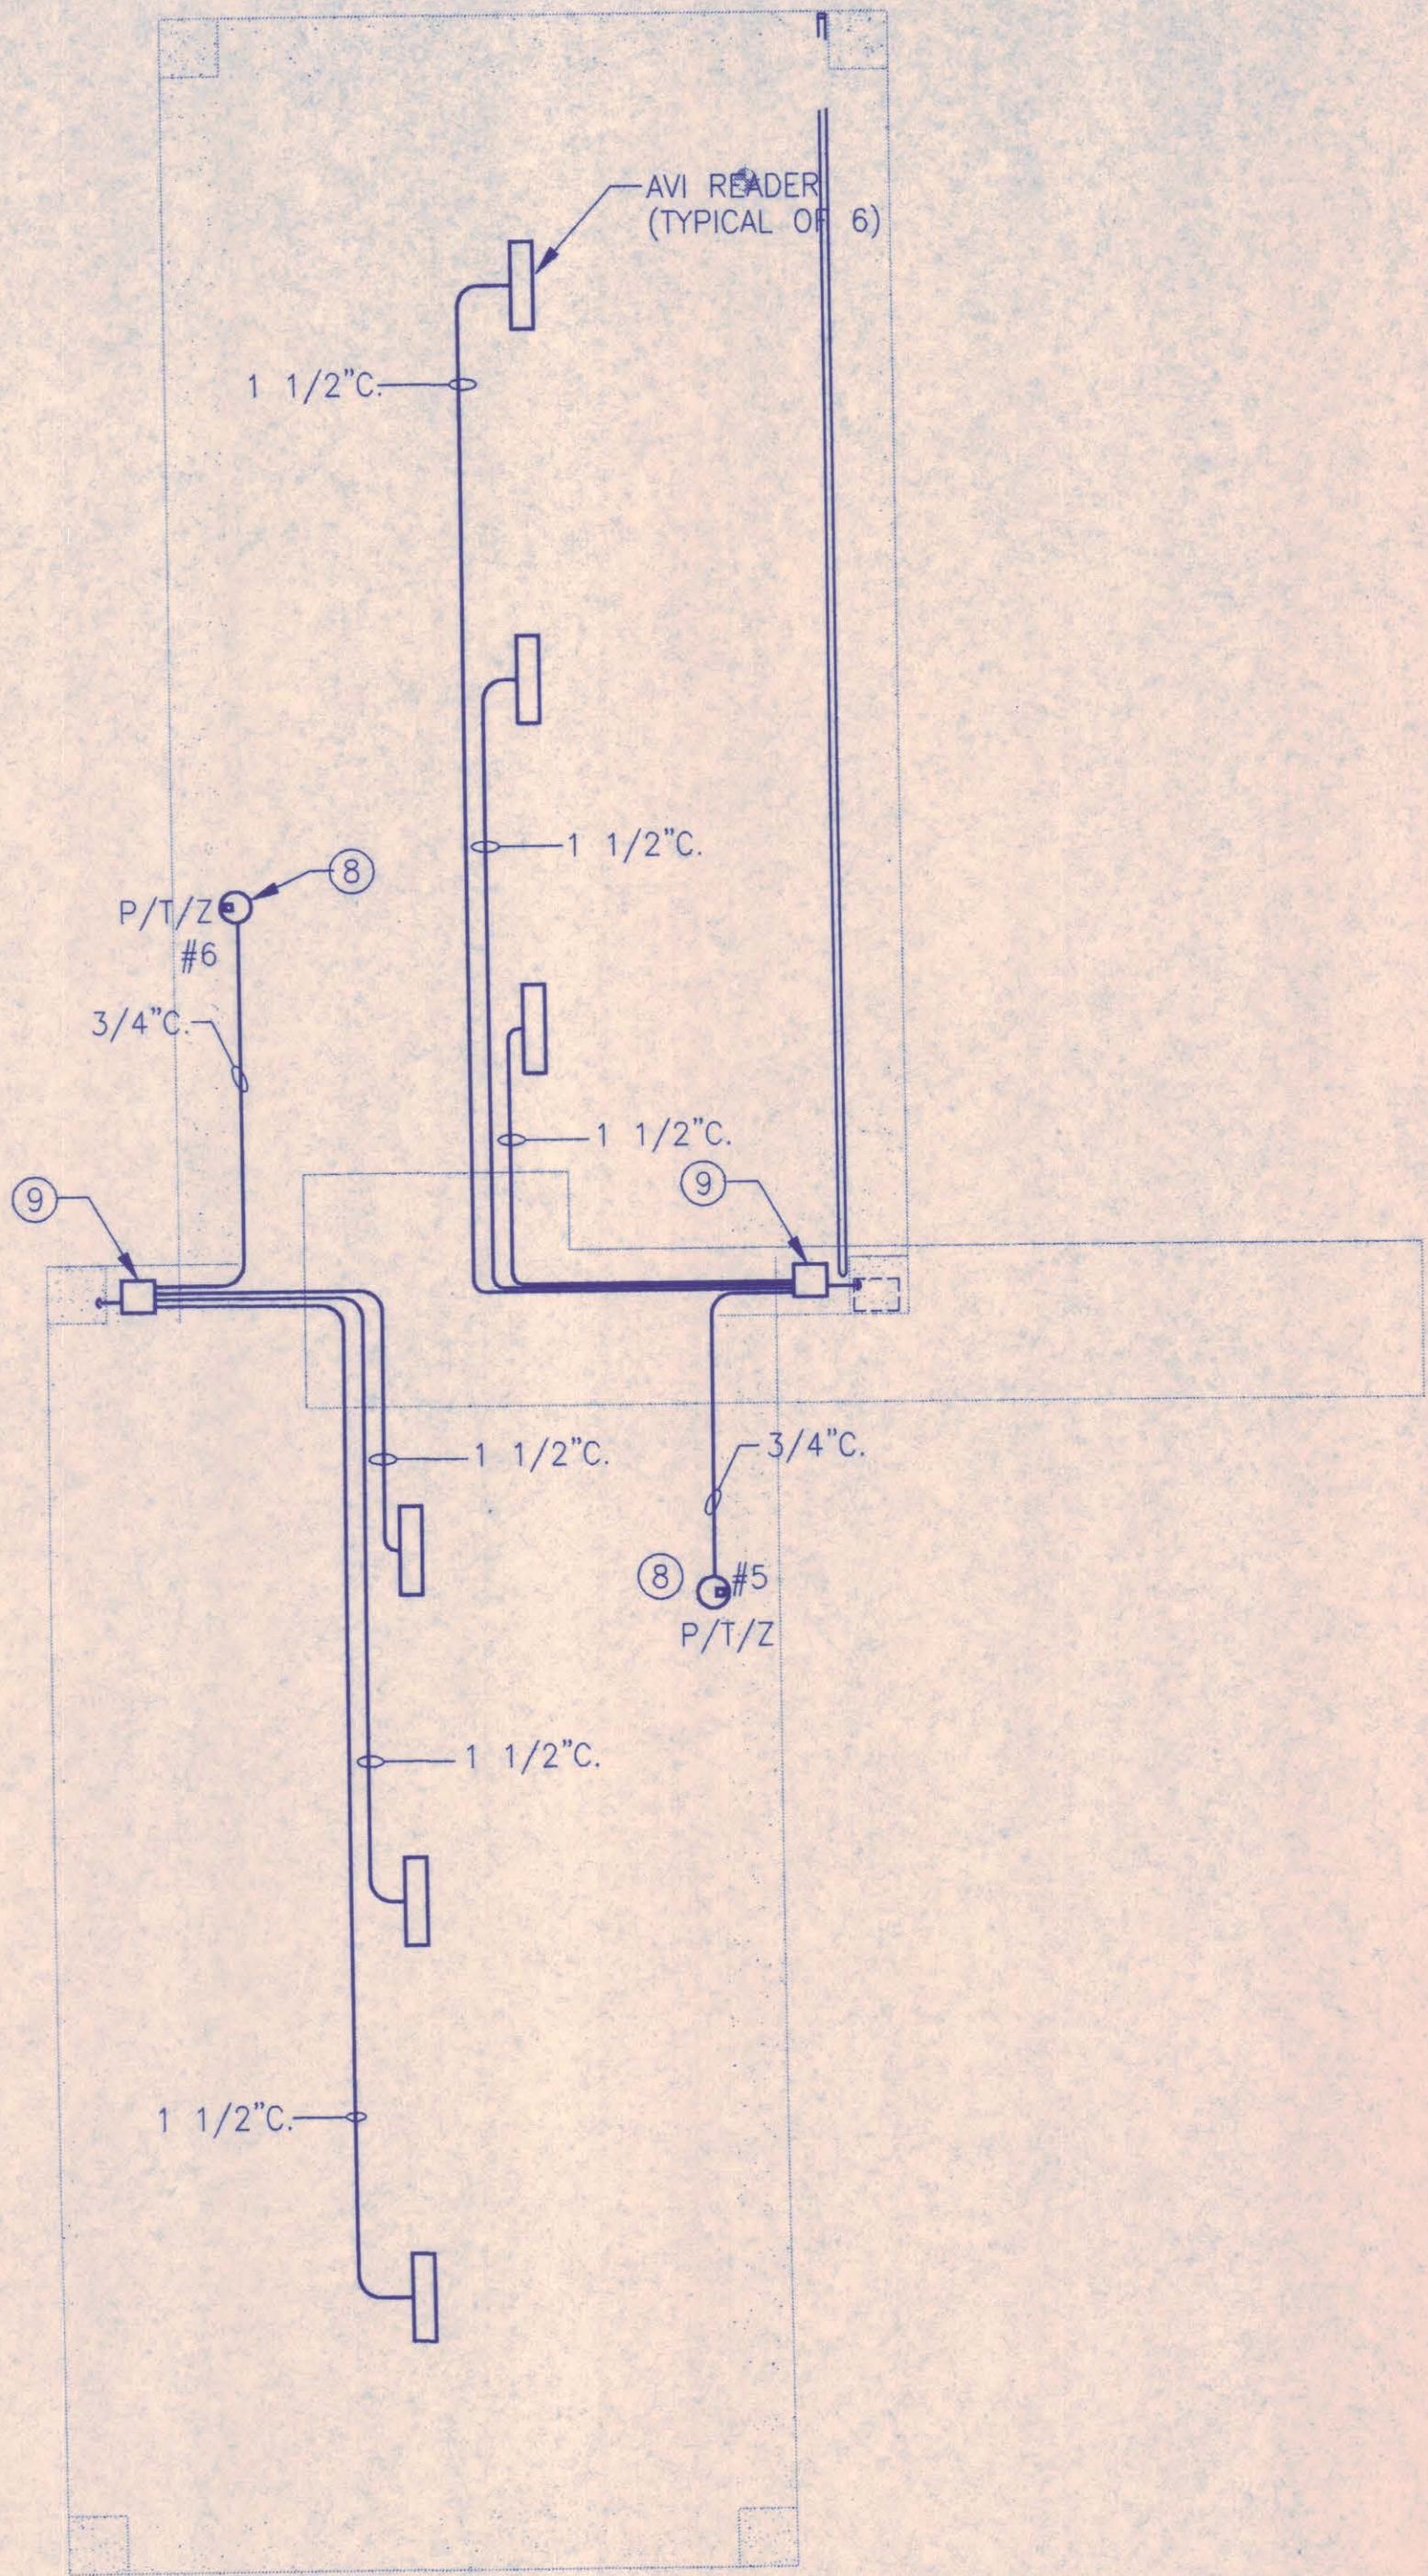


1 ELEC. CANOPY COMMUNICATIONS PLAN
SCALE: 1/8" = 1'-0"
TAATECC1.DWG




AT-E4.1

NO. REVISION BY DATE			
NORTH TEXAS TOLLWAY AUTHORITY ADDISON AIRPORT TUNNEL BARRIER TOLL PLAZA			
ELECTRICAL / ILP COMMUNICATIONS PLANS			
AGUIRRE CORPORATION 12700 PARK CENTRAL DRIVE 9TH FLOOR DALLAS, TEXAS 75241 TEL. 972 756-1808			SECTION XIII
CHECKED <i>PLD</i>	DATE 12/18/97	DESIGNED <i>FA</i>	DATE 12/20/96
CHECKED <i>tes</i>	DATE 12/18/97	SCALE AS NOTED	
CONTRACT NO. DNT-290	SHEET 49 OF 53		

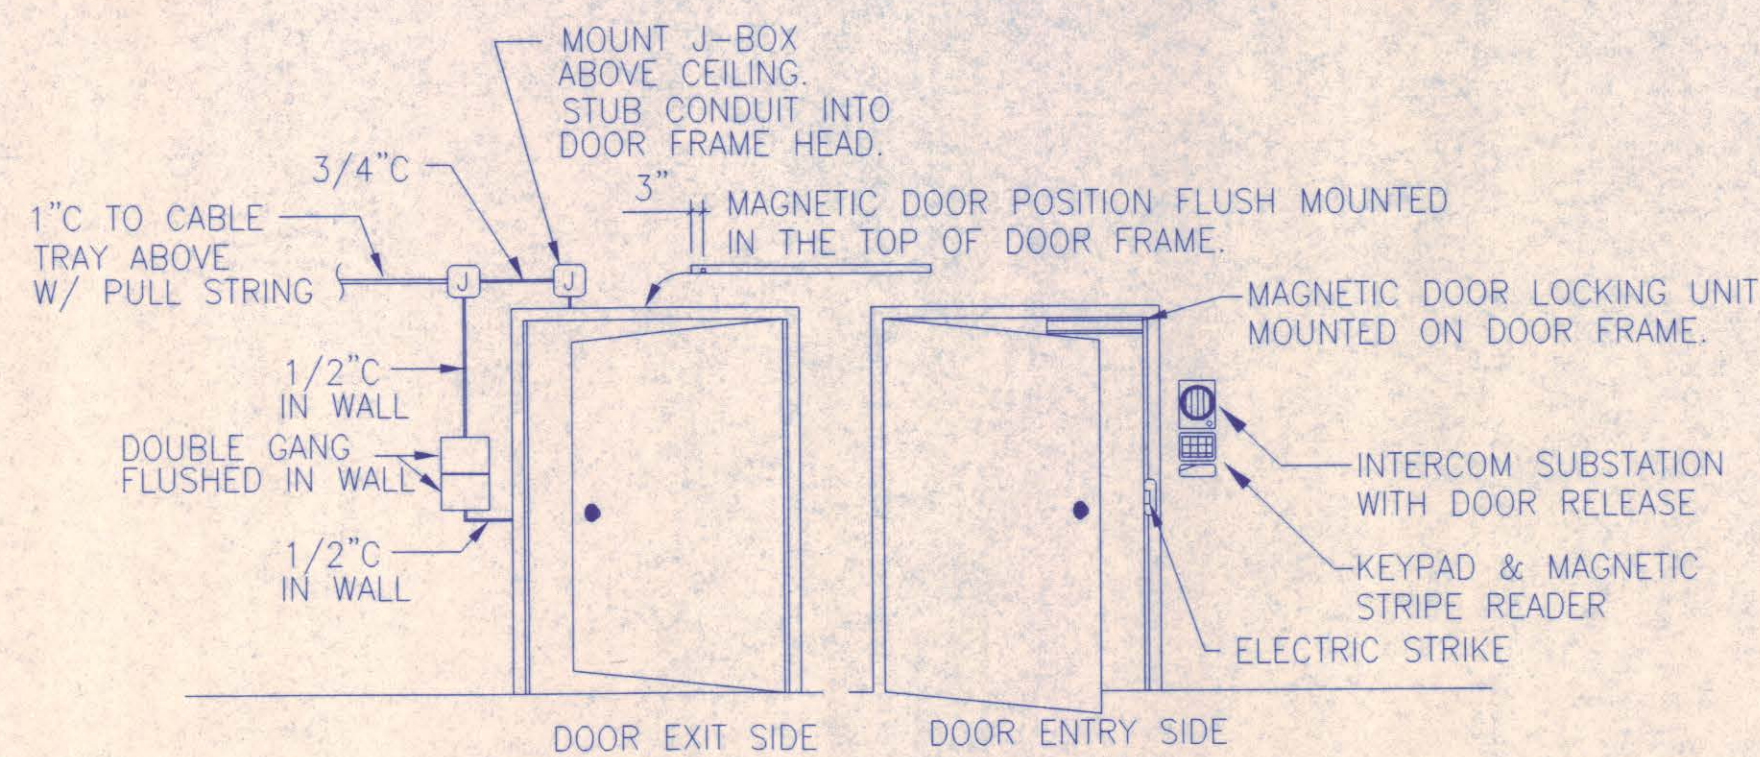


4 CARD ACCESS ENTRY DOORS
SCALE: 1/4"=1'-0" (APROX) TAATED17.DWG

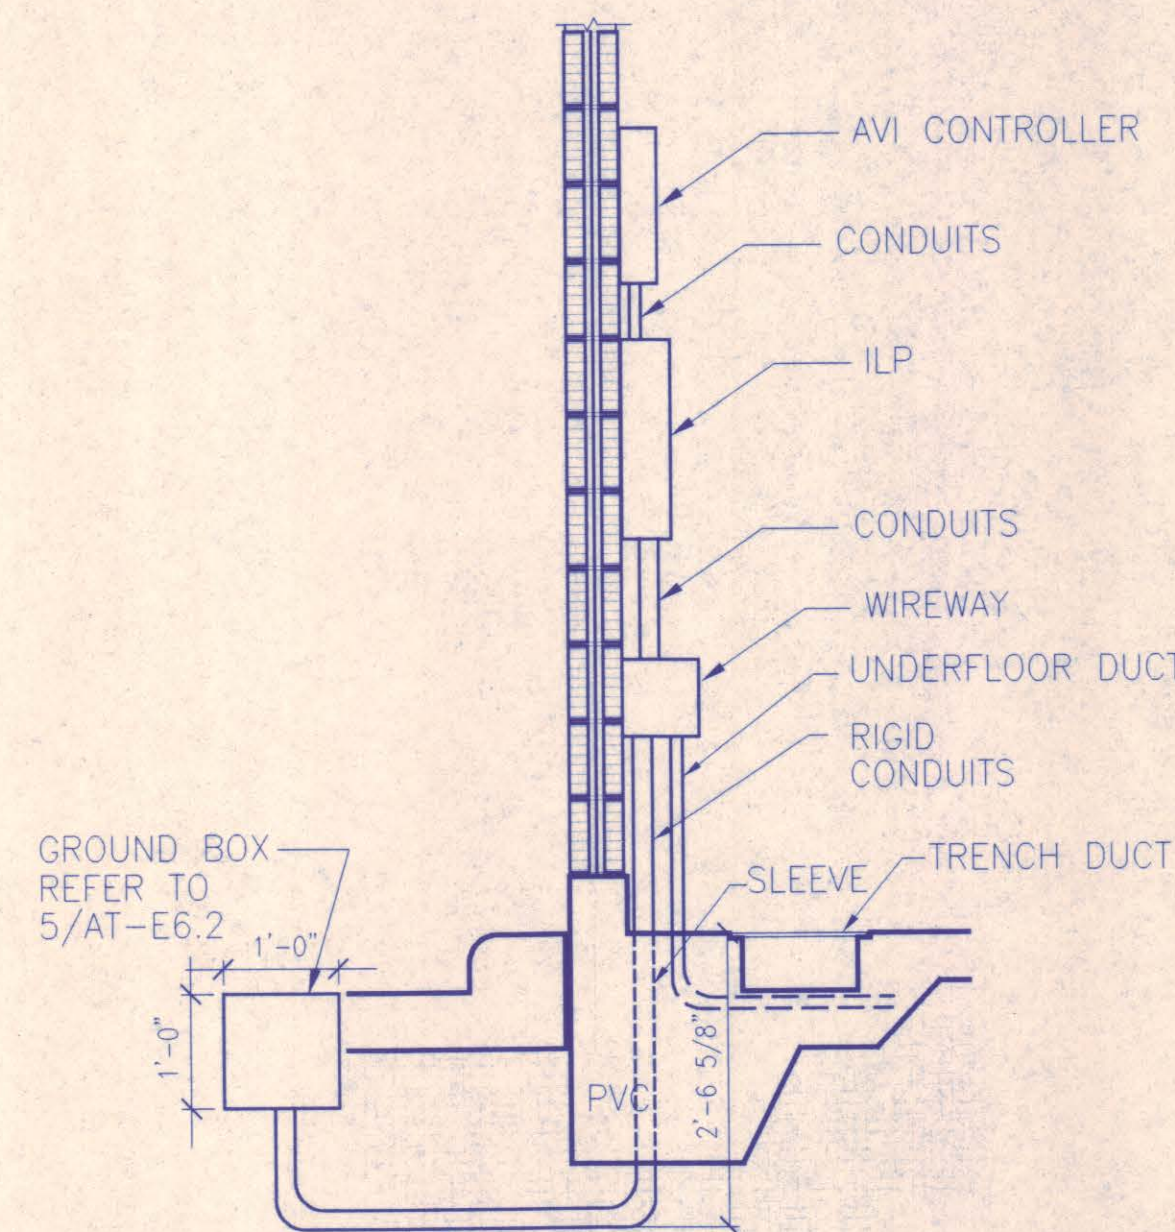


5 ELECTRICAL ILP CONDUIT DETAIL
SCALE: NONE TAATED22.DWG


TEST GROUND ELECTRODE USING NULL-BALANCE TESTER AND DRIVE AUXILIARY RODS WHERE GROUND EXCEEDS 25 OHMS. DRIVE ADDITIONAL GROUND RODS AND CONNECT RODS TOGETHER USING #4/0 BARE COPPER. EXOTHERMIC WELD RODS AND GROUND ELECTRODE CONDUCTOR FROM DISTRIBUTION PANEL TO GROUND GRID.

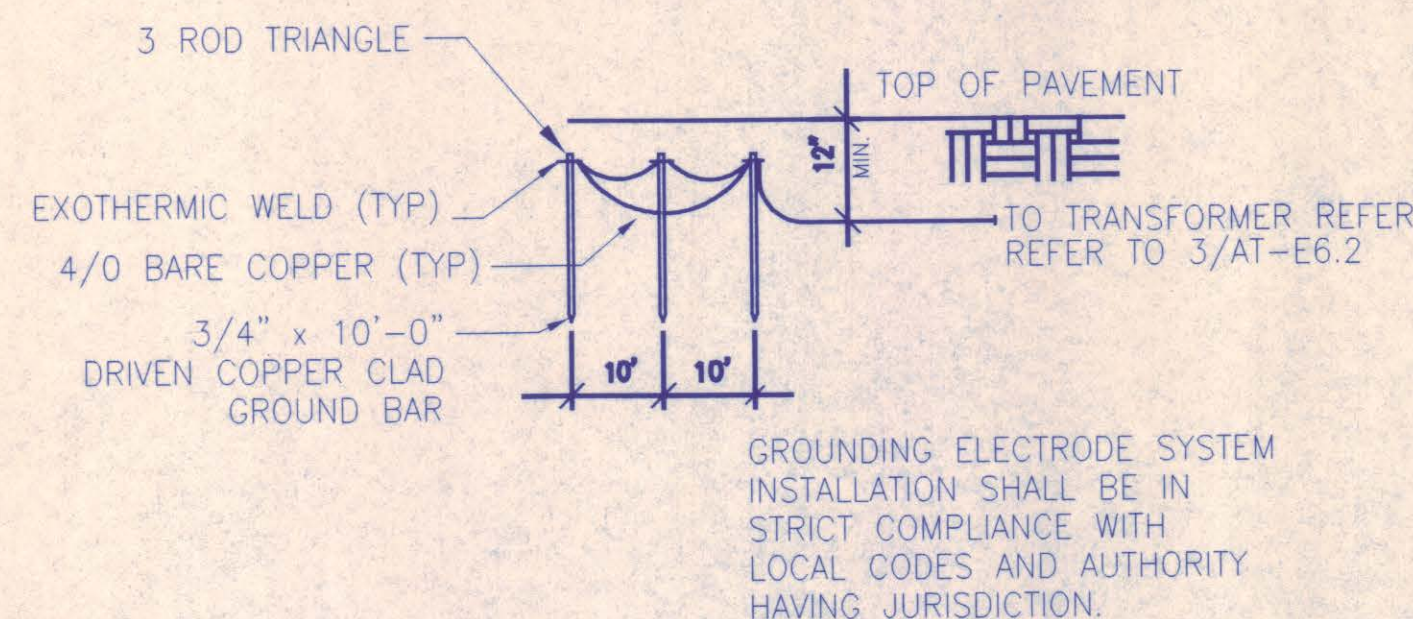


6 GROUNDING ELECTRODE DETAIL
SCALE: NONE TAATED30.DWG

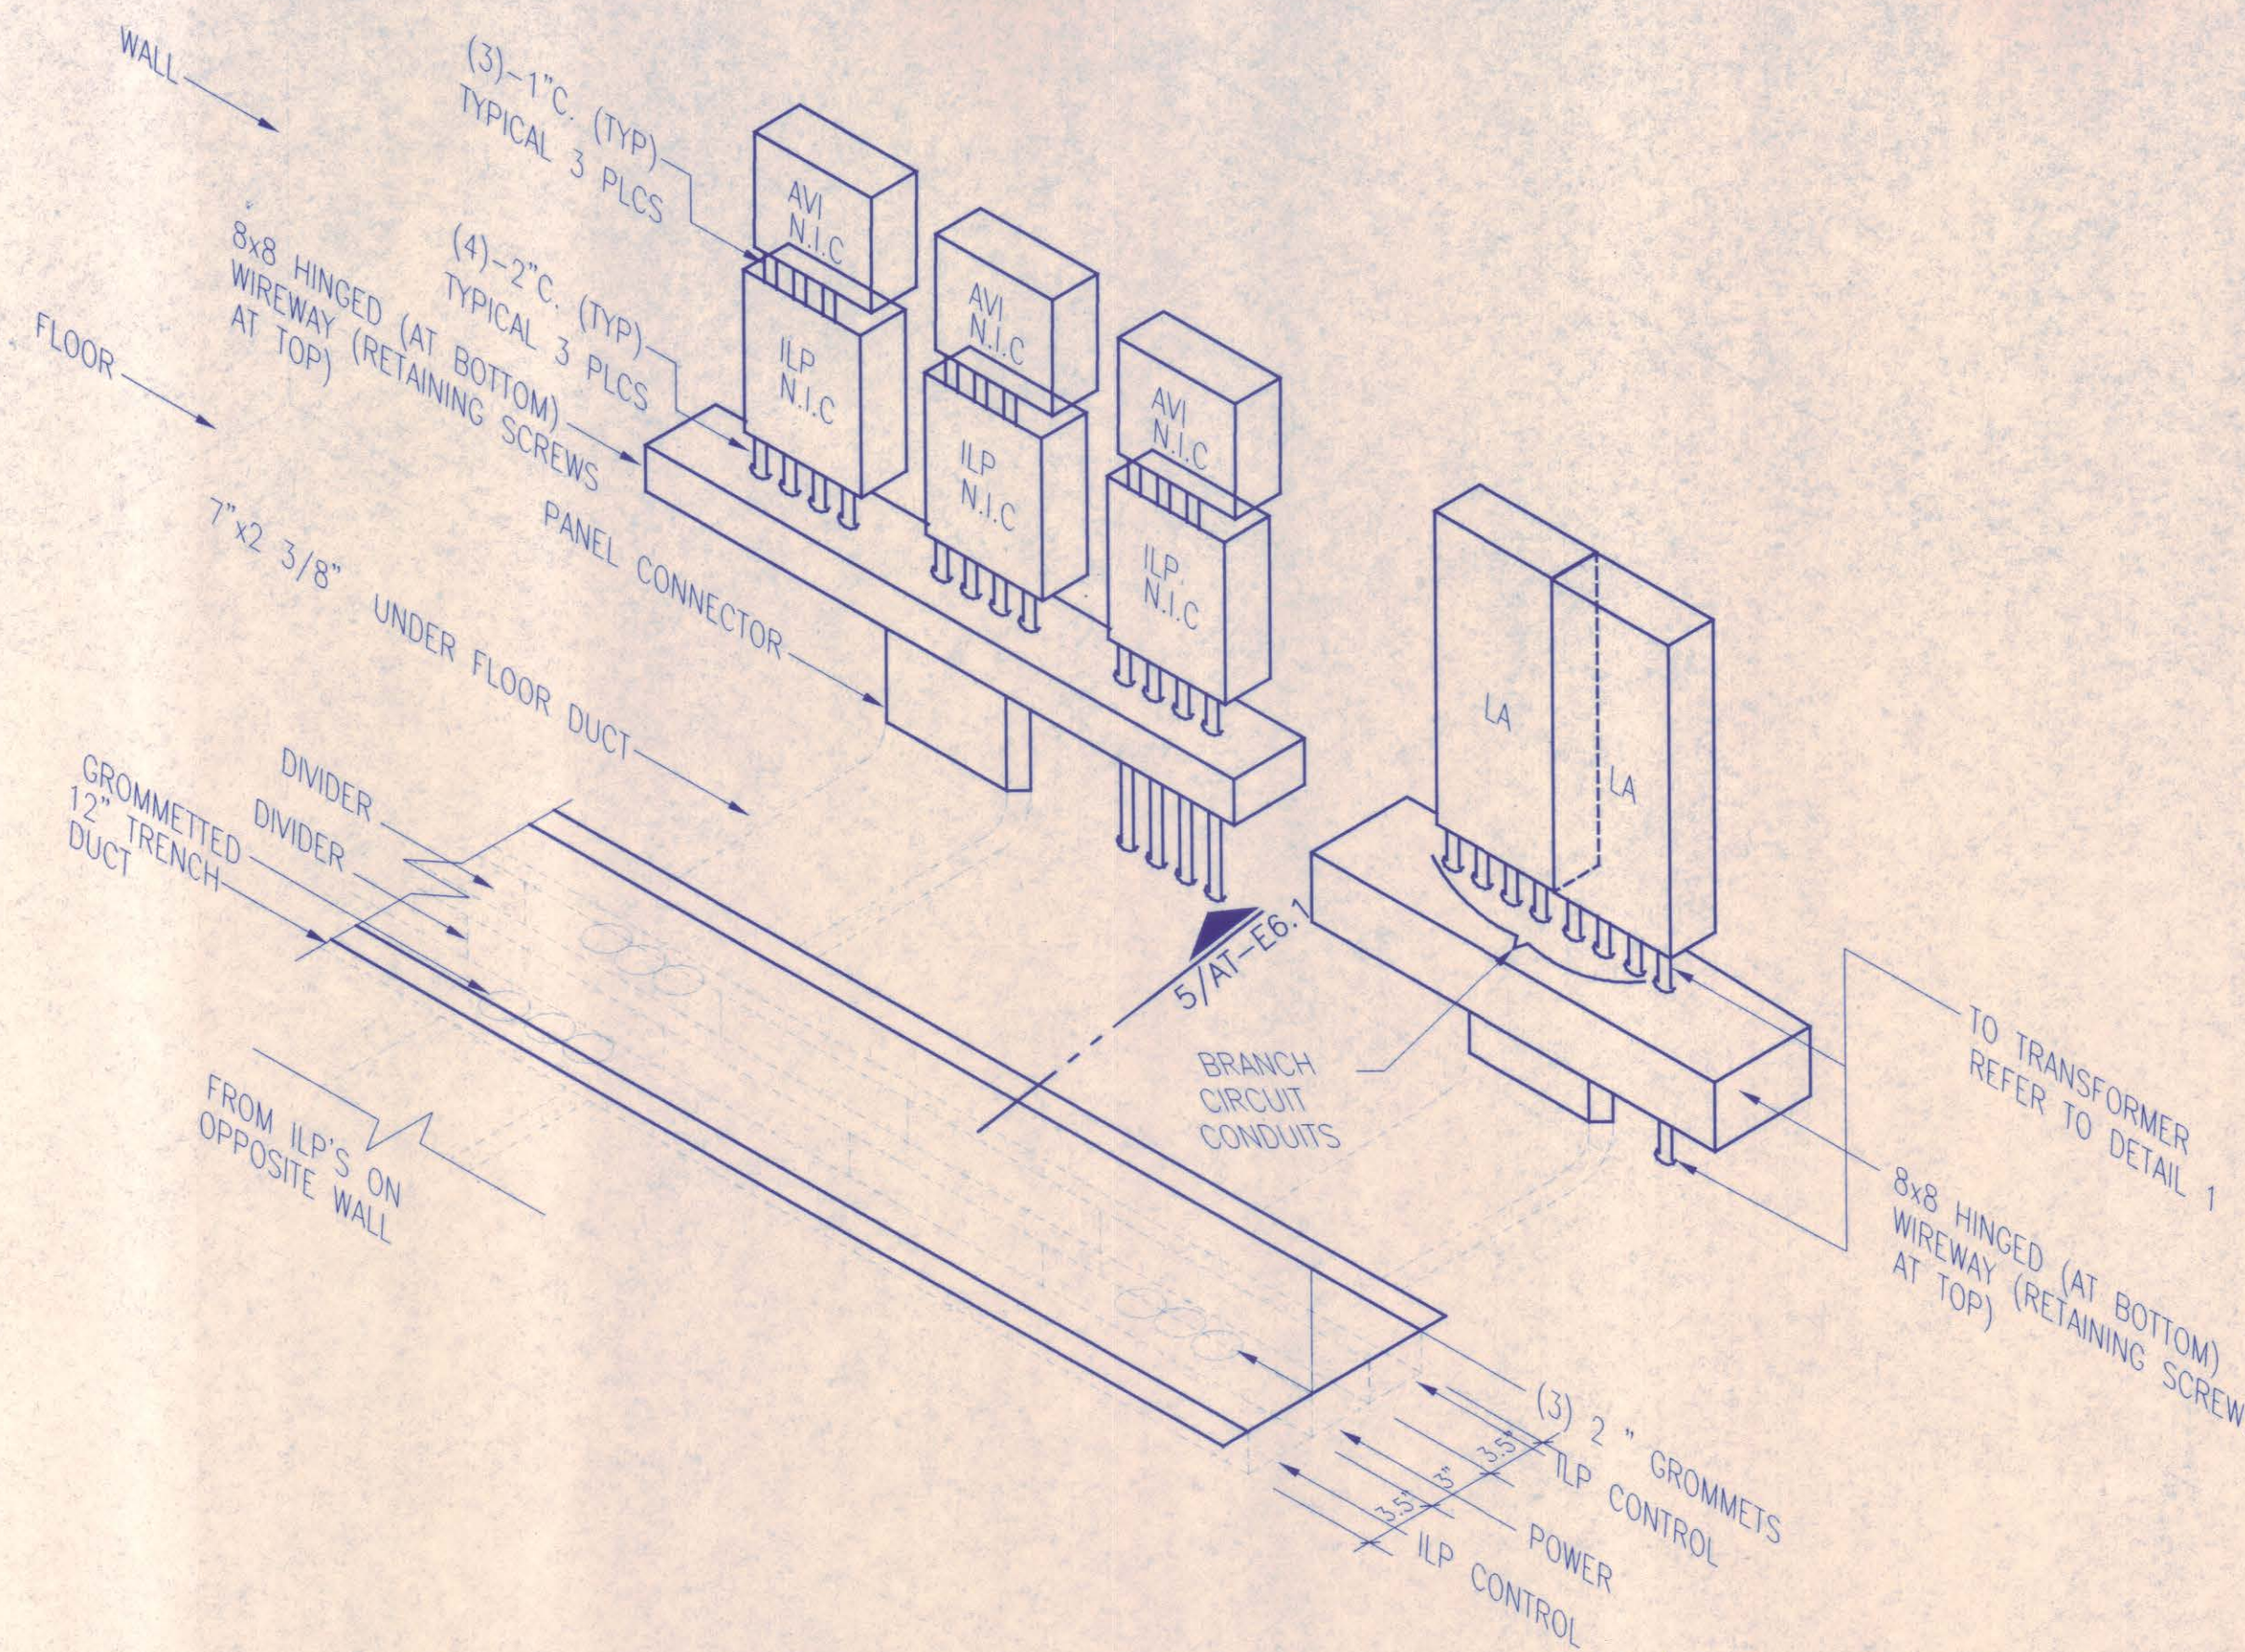


2 UNDERGROUND DUCT DETAIL
SCALE: NONE TAATED02.DWG

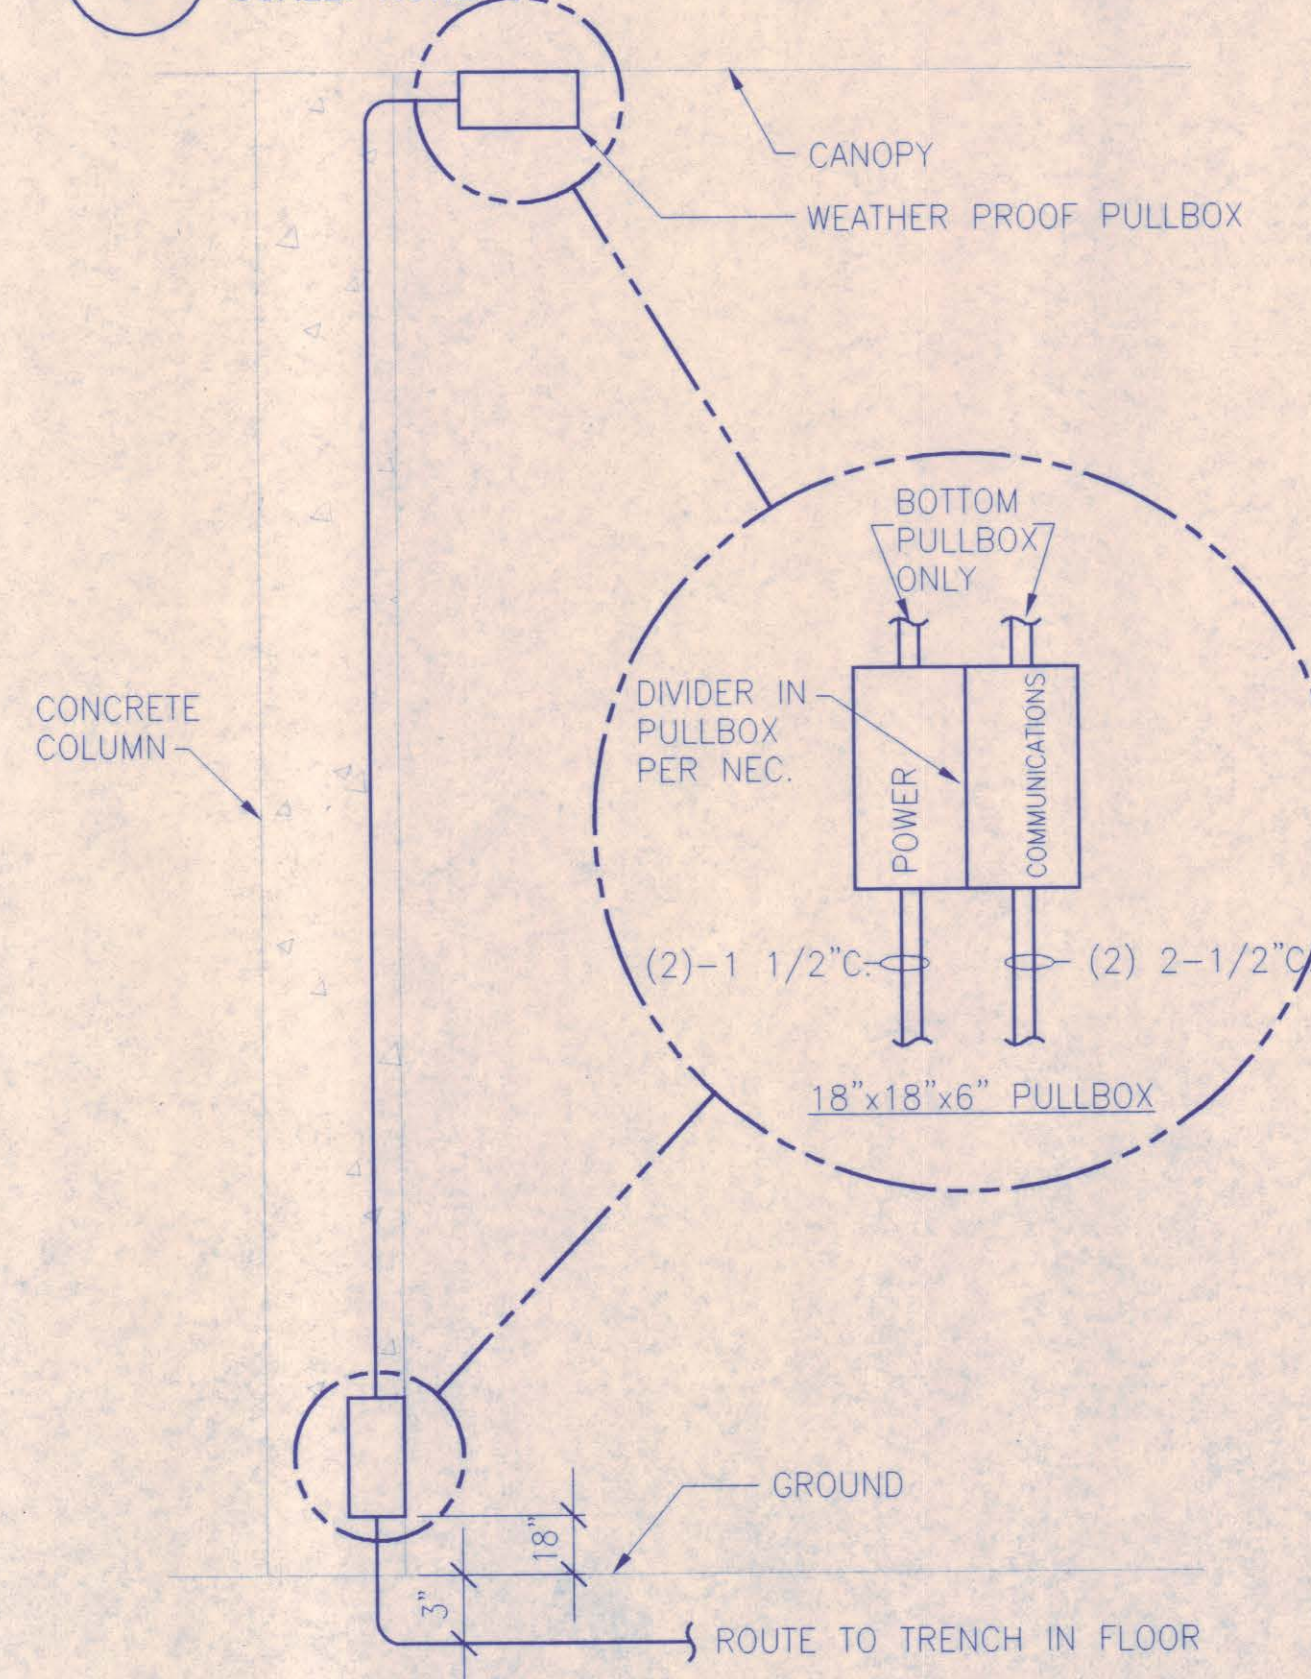

3 PULLBOX DETAIL
SCALE: NONE TAATED01.DWG

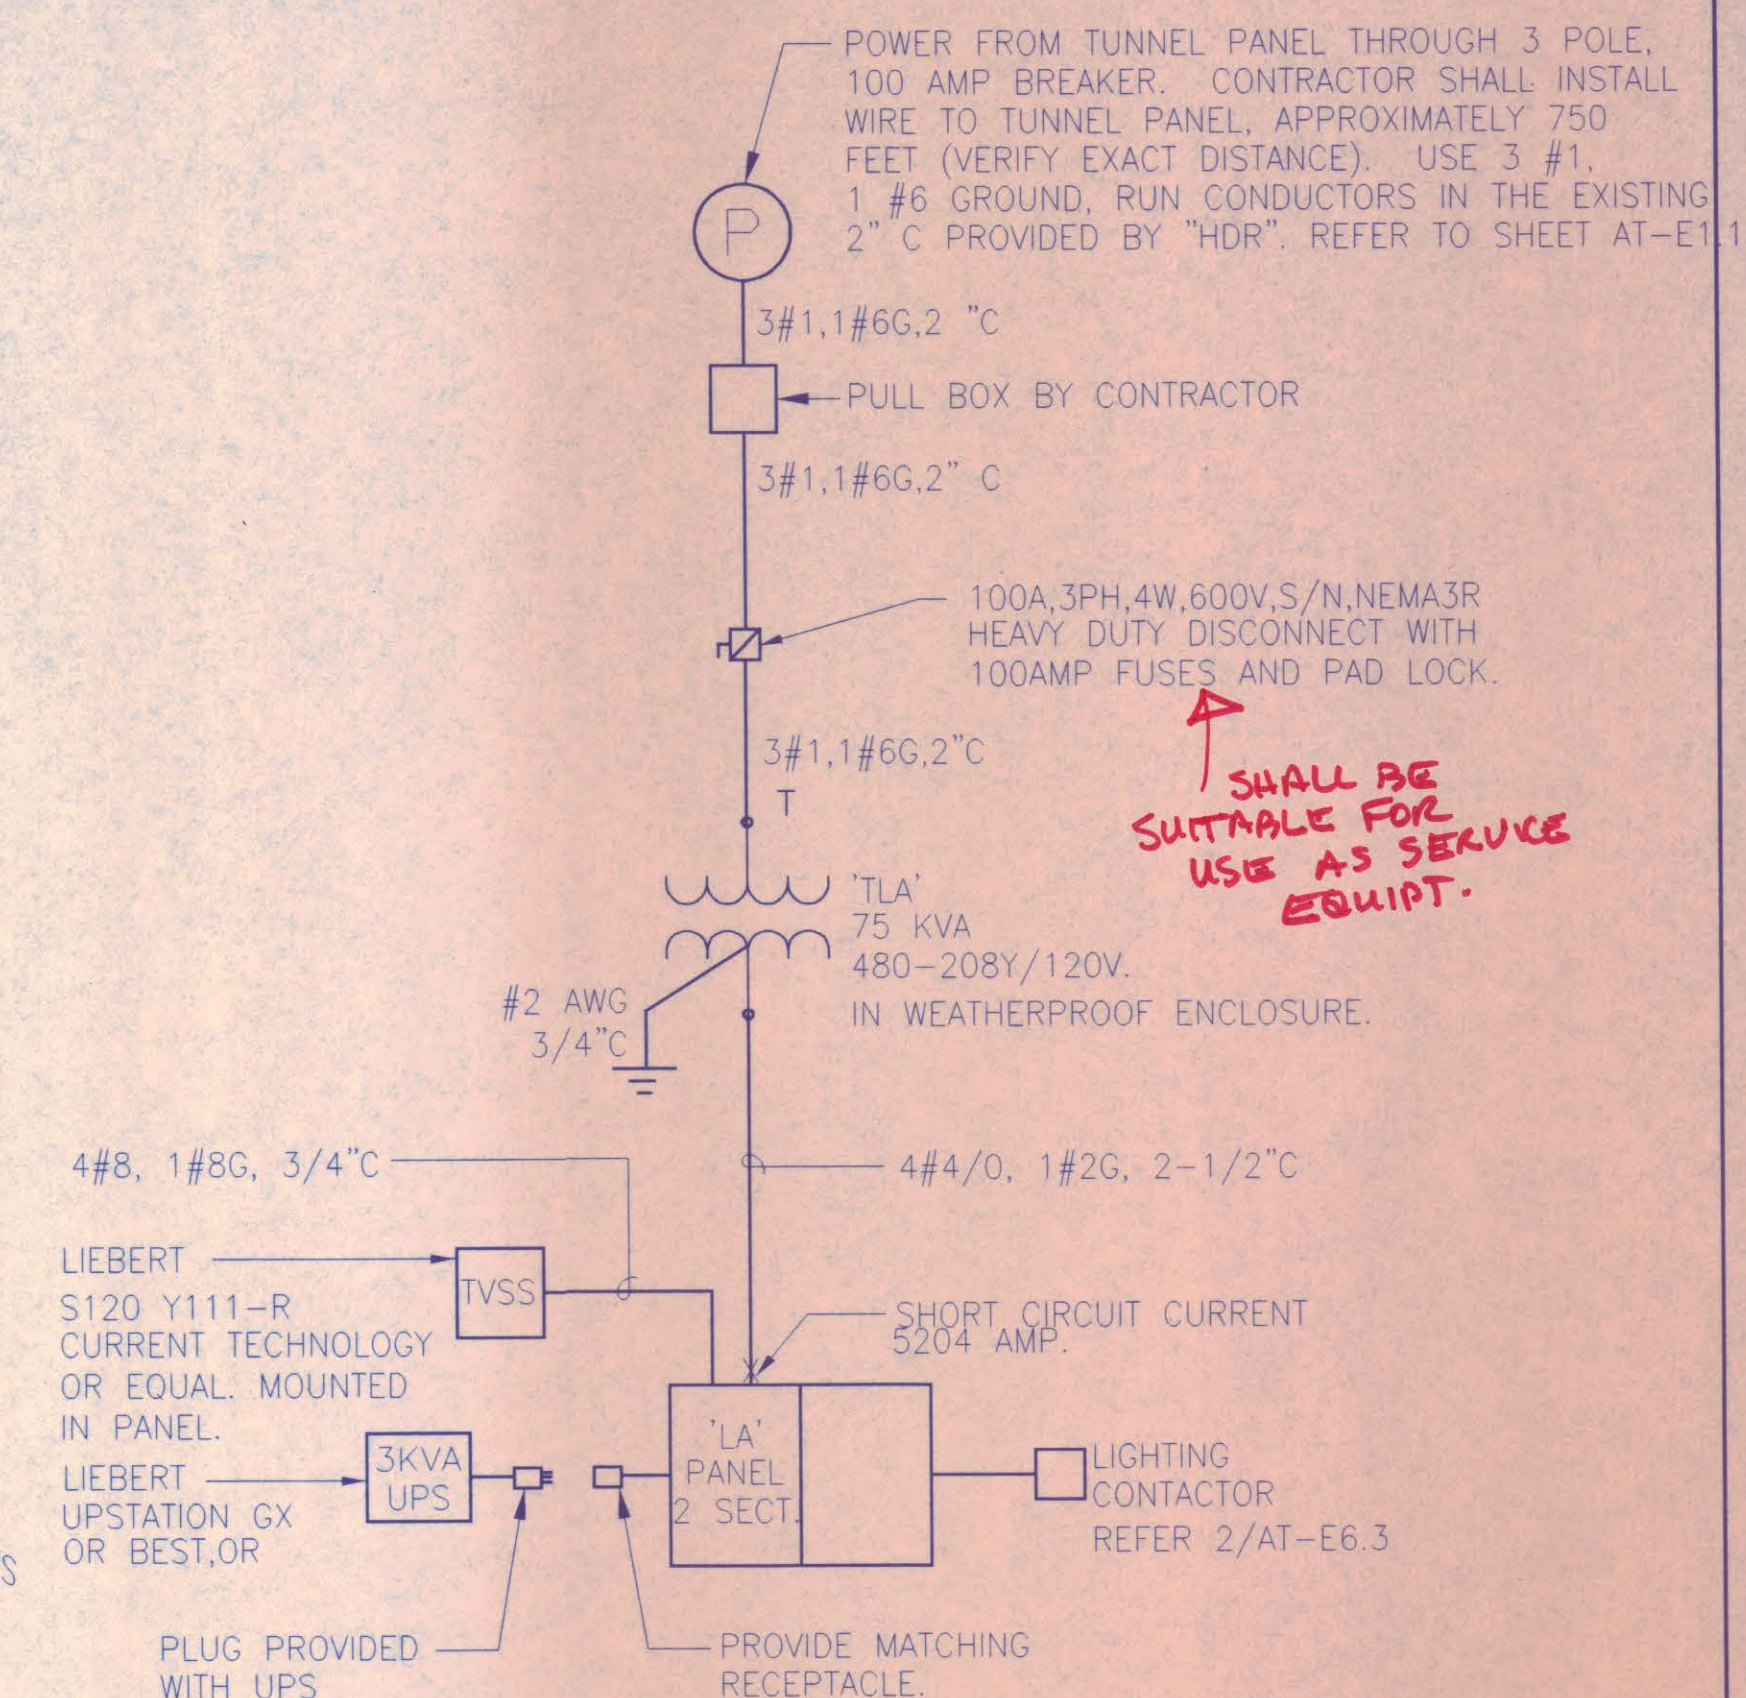


1 ELECTRICAL RISER DIAGRAM
SCALE: NONE TAATED01.DWG

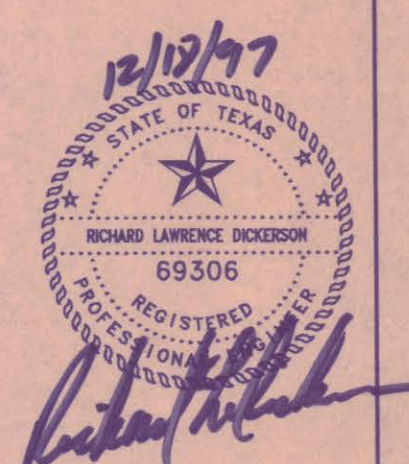


NO.	REVISION	BY	DATE
NORTH TEXAS TOLLWAY AUTHORITY ADDISON AIRPORT TUNNEL BARRIER TOLL PLAZA			
ELECTRICAL RISER DIAGRAMS AND DETAILS			
AGUIRRE CORPORATION 18700 PARK CENTRAL DRIVE 15 TH FLOOR DALLAS, TEXAS 75248 TEL. 972/758-5008			SECTION XIII
CHECKED <i>RL</i>	DATE 12/18/97	DESIGNED FA	DATE 12/20/96
CHECKED <i>RL</i>	DATE 12/18/97	SCALE AS NOTED	
CONTRACT NO. DNT-290		SHEET 50 OF 53	


AT-E6.1

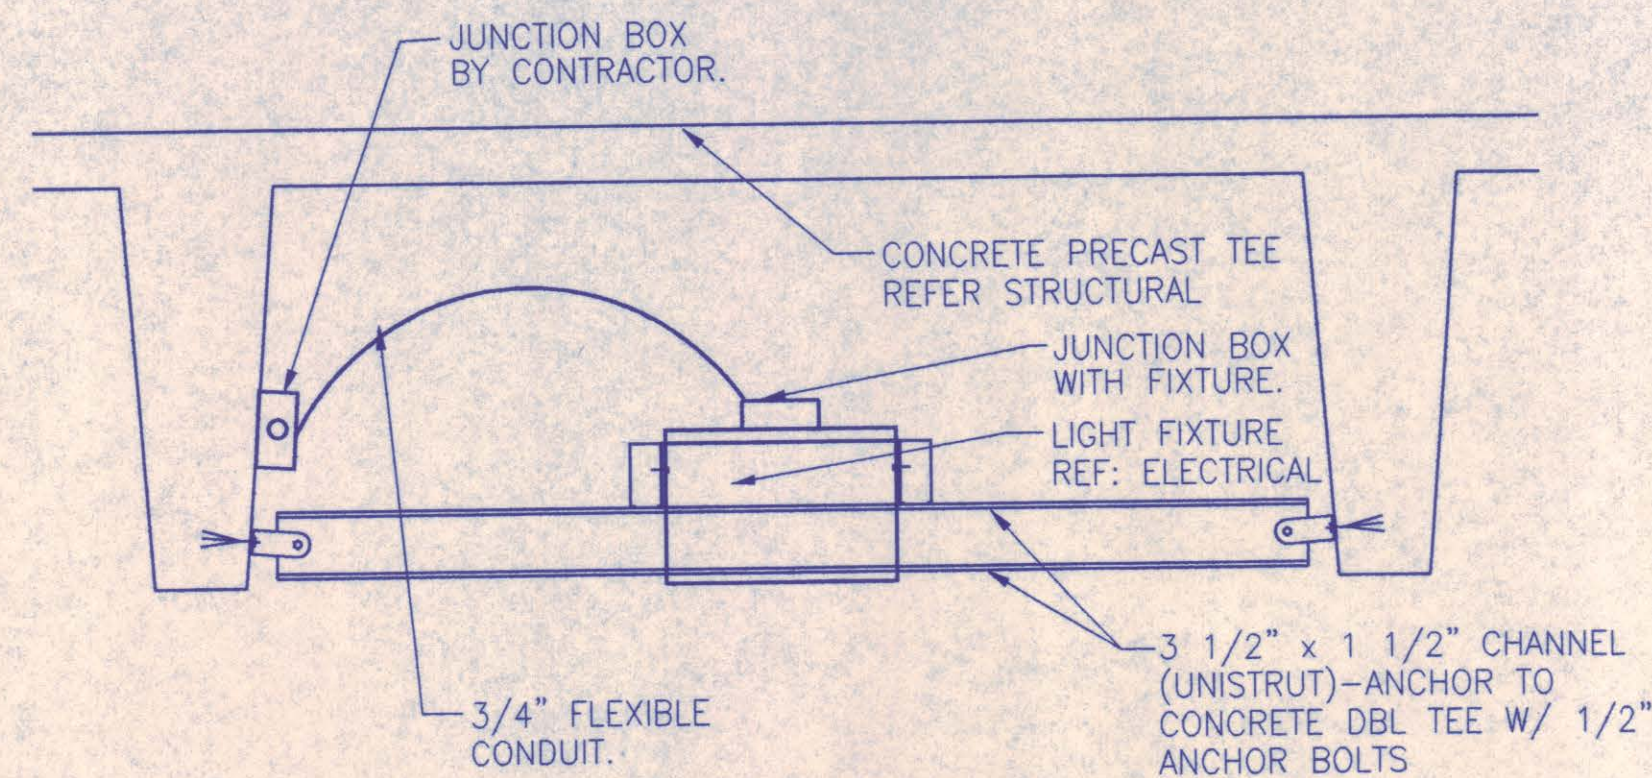


6 UNDER CANOPY LIGHTS
N.T.S. TAATED25

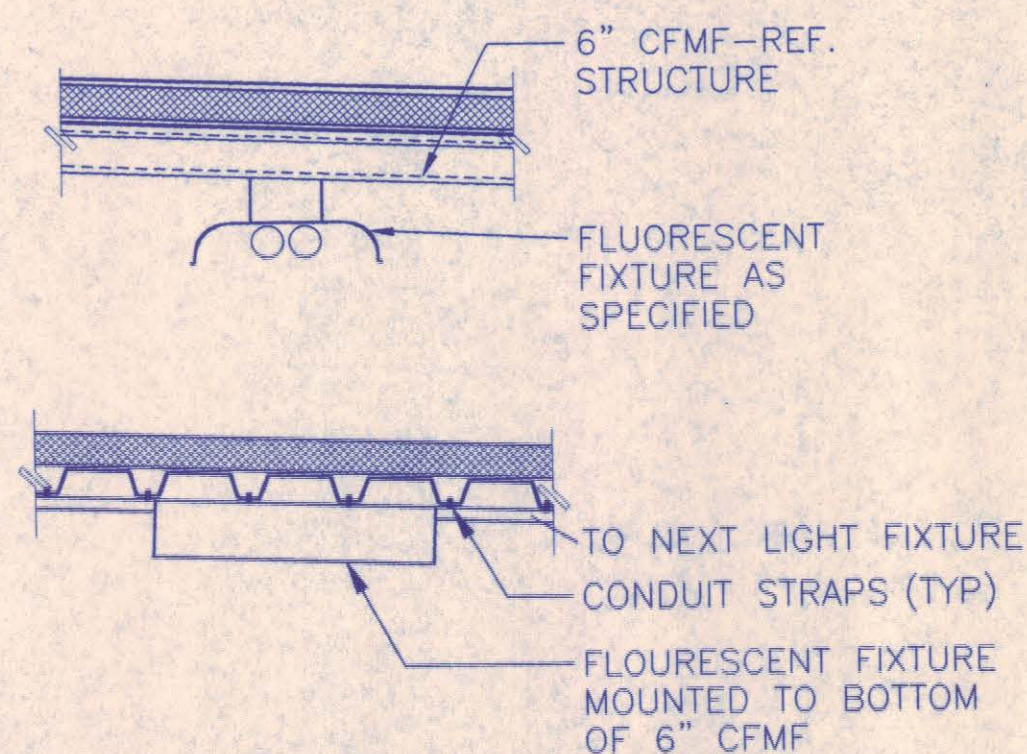


7 FIXTURE MOUNTING DETAIL
N.T.S. TAATED15

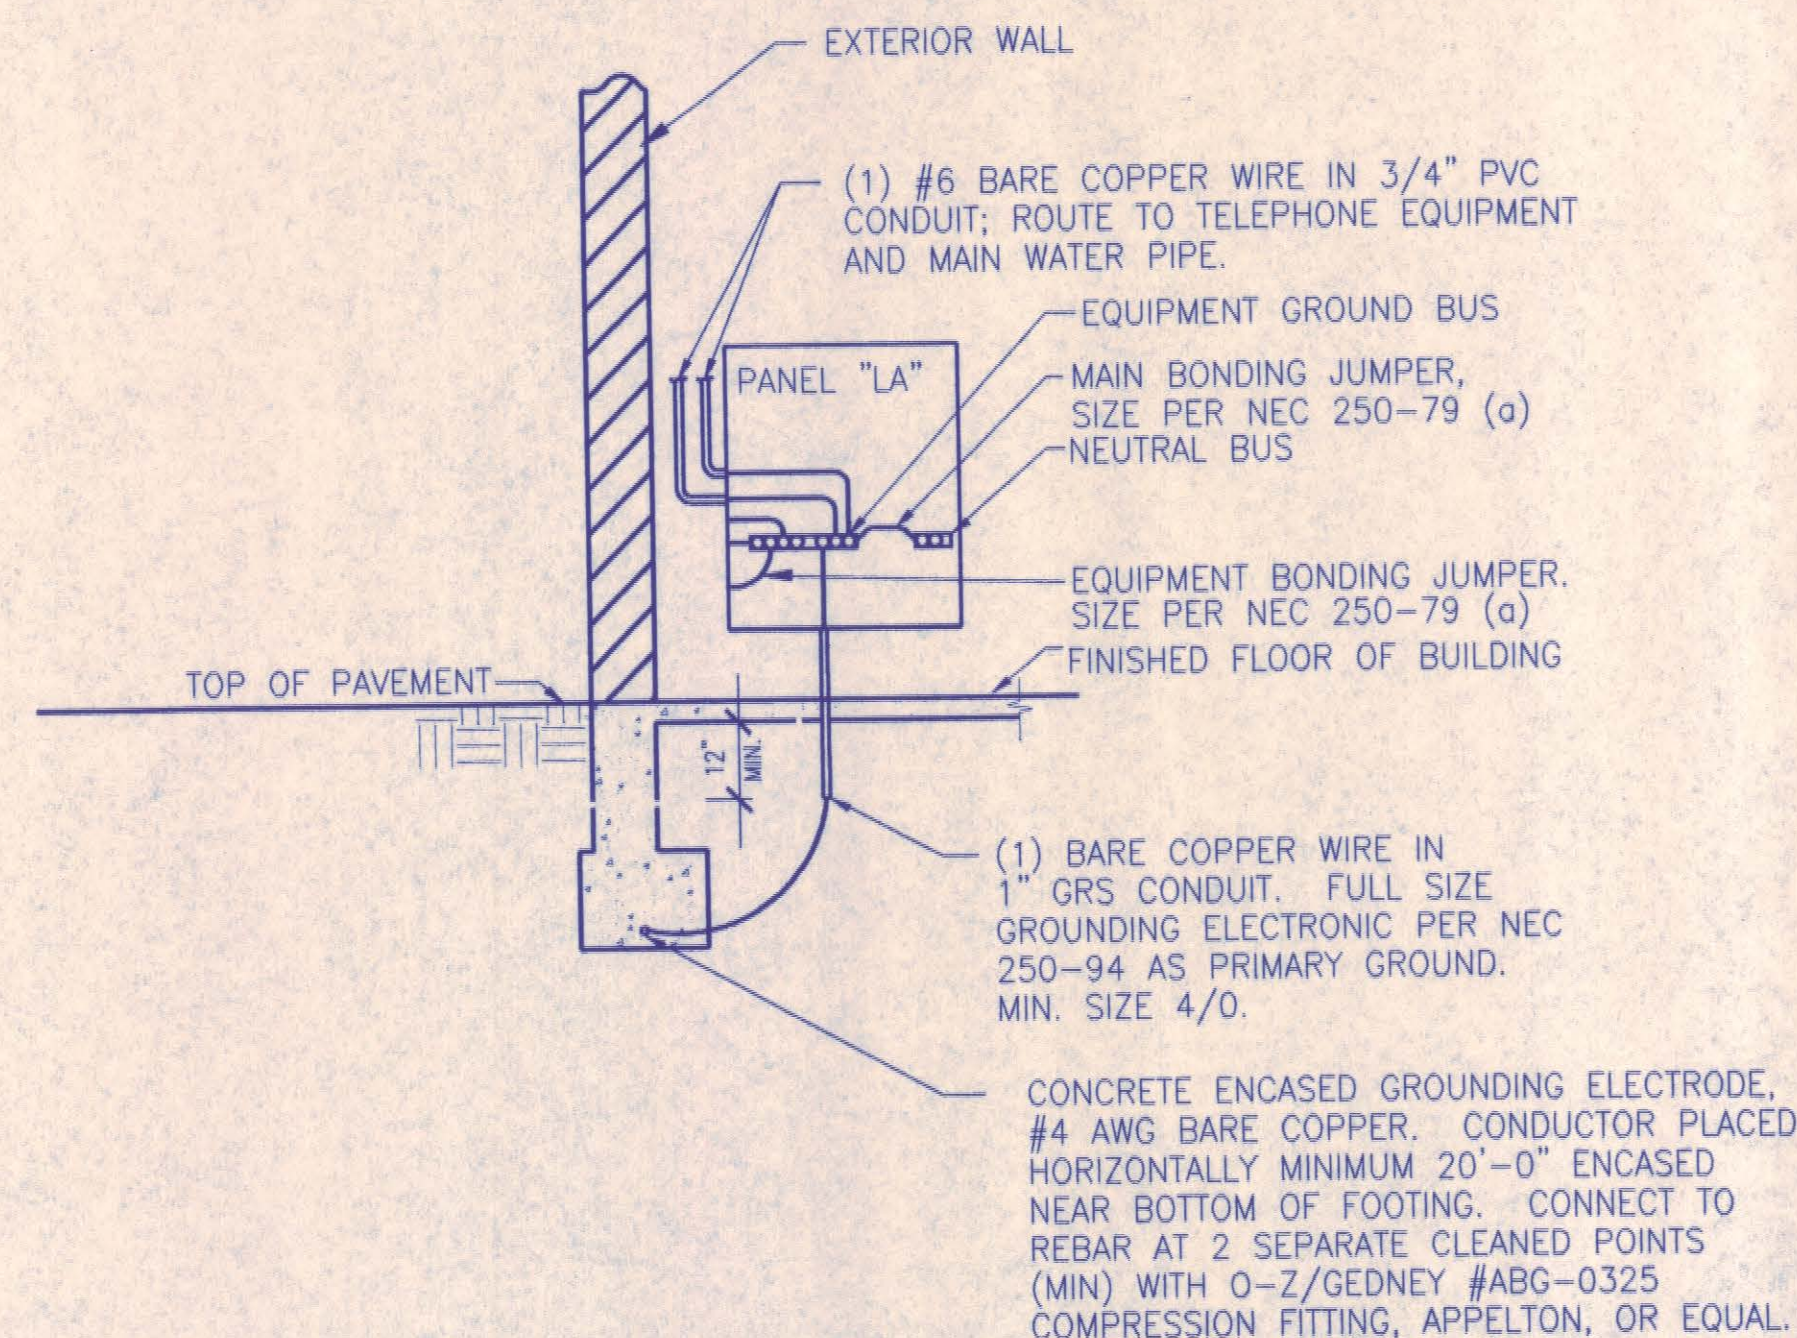


8 GROUNDING ELECTRODE DETAIL
N.T.S. TAATED24

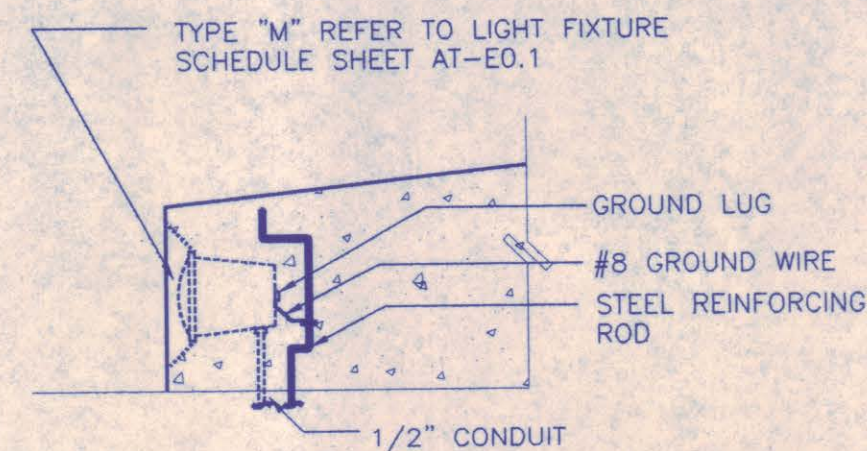


4 TOLL COLLECTION LIGHT DTL.
N.T.S. TAATED07

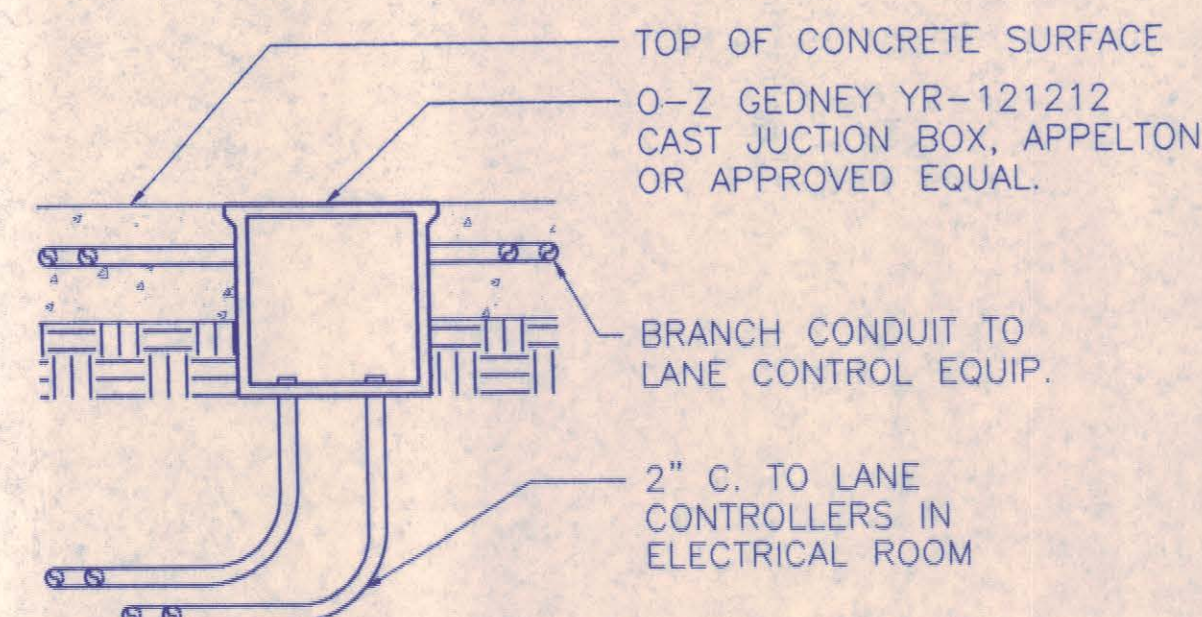


5 LANE CONTROL JUNCT. BOX
N.T.S. TAATED13

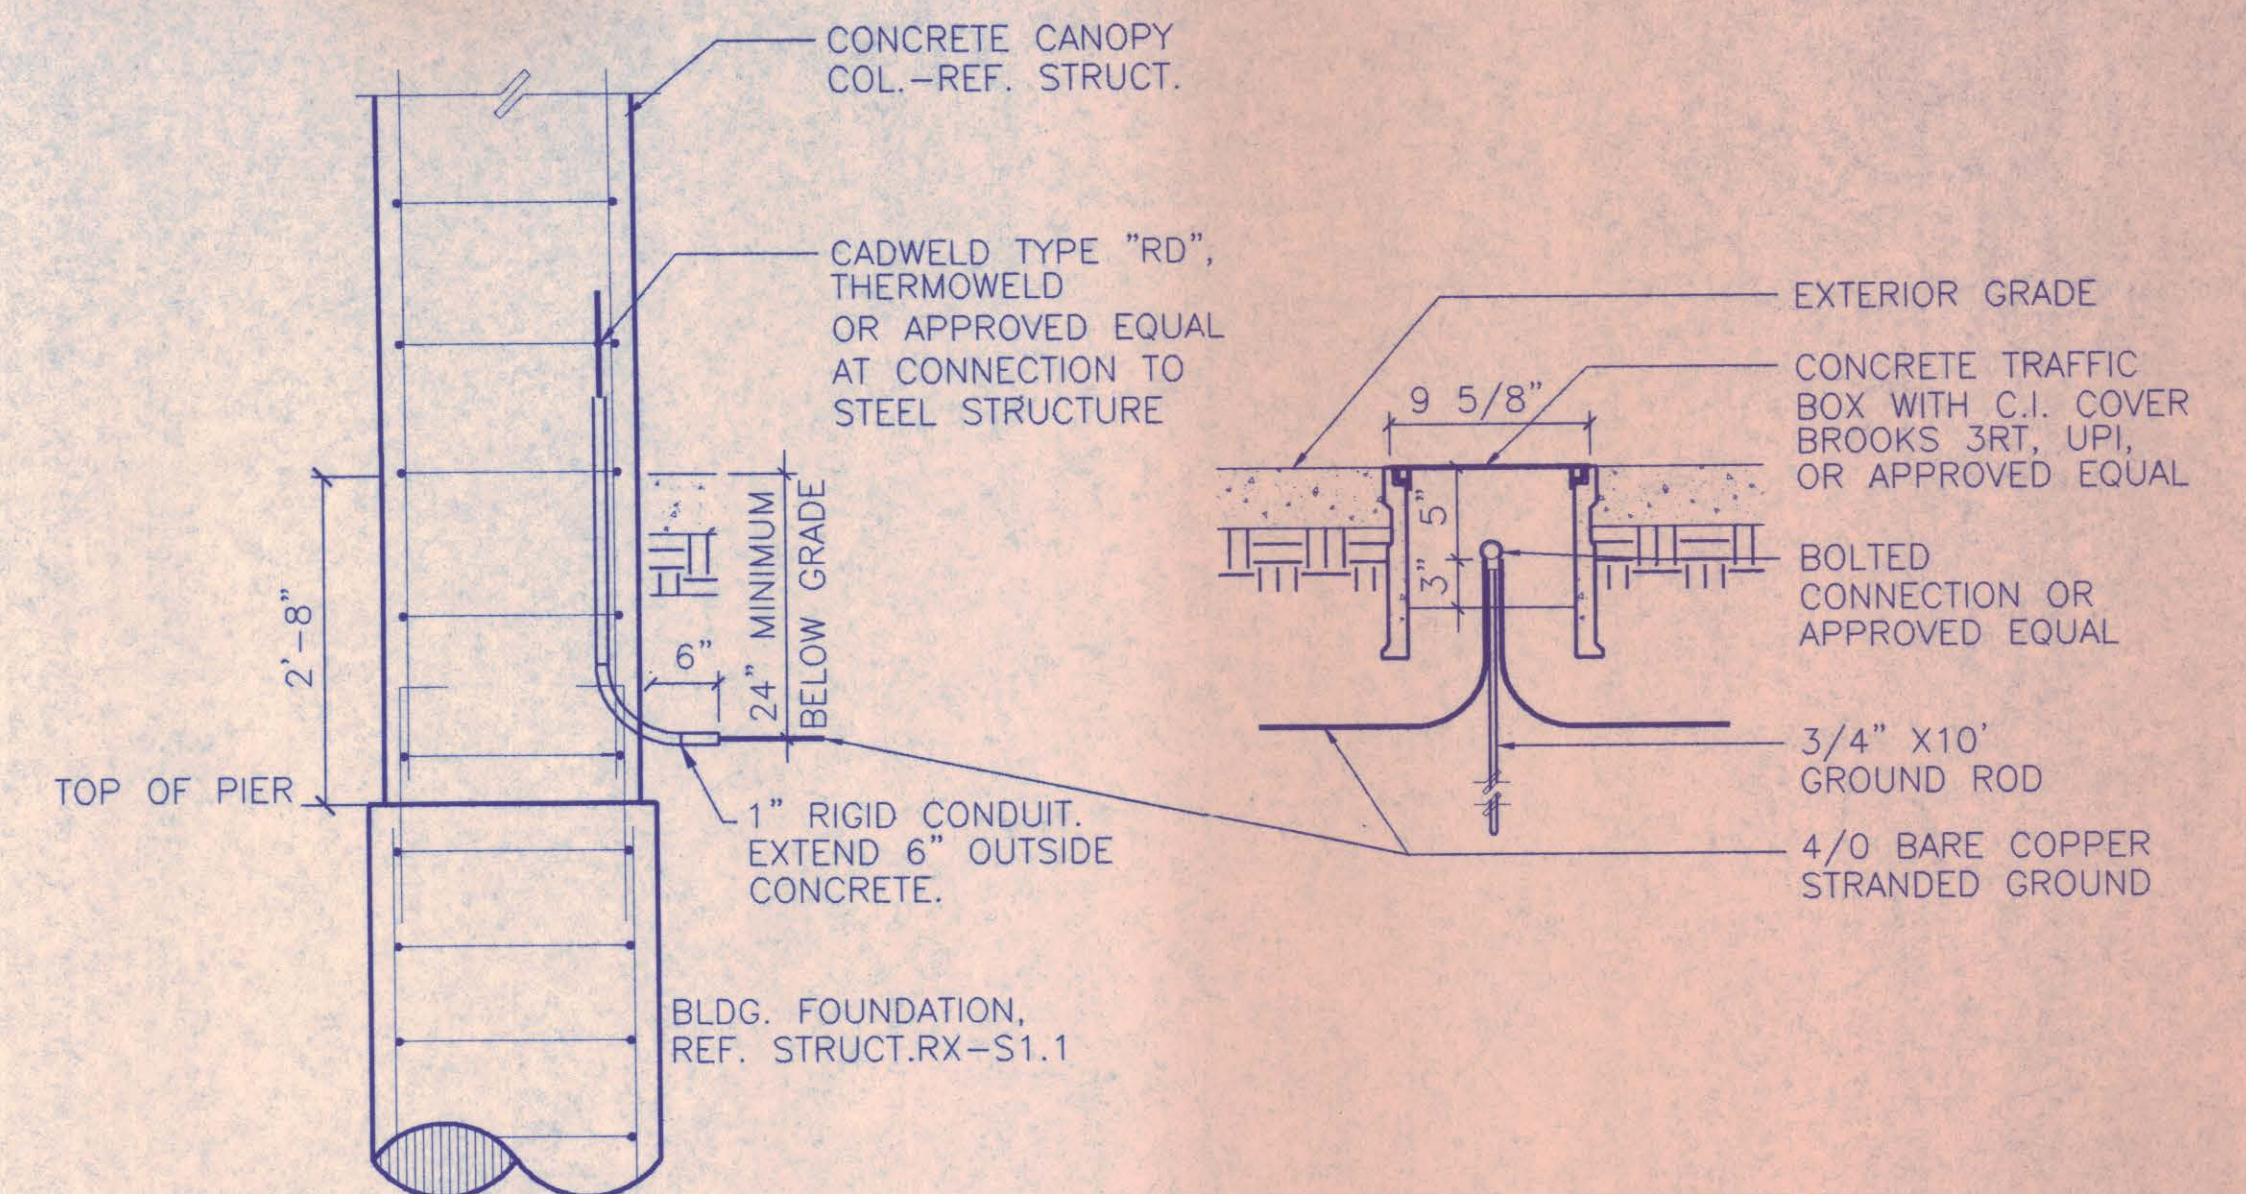


1 GROUNDING DETAILS
N.T.S. TAATED09

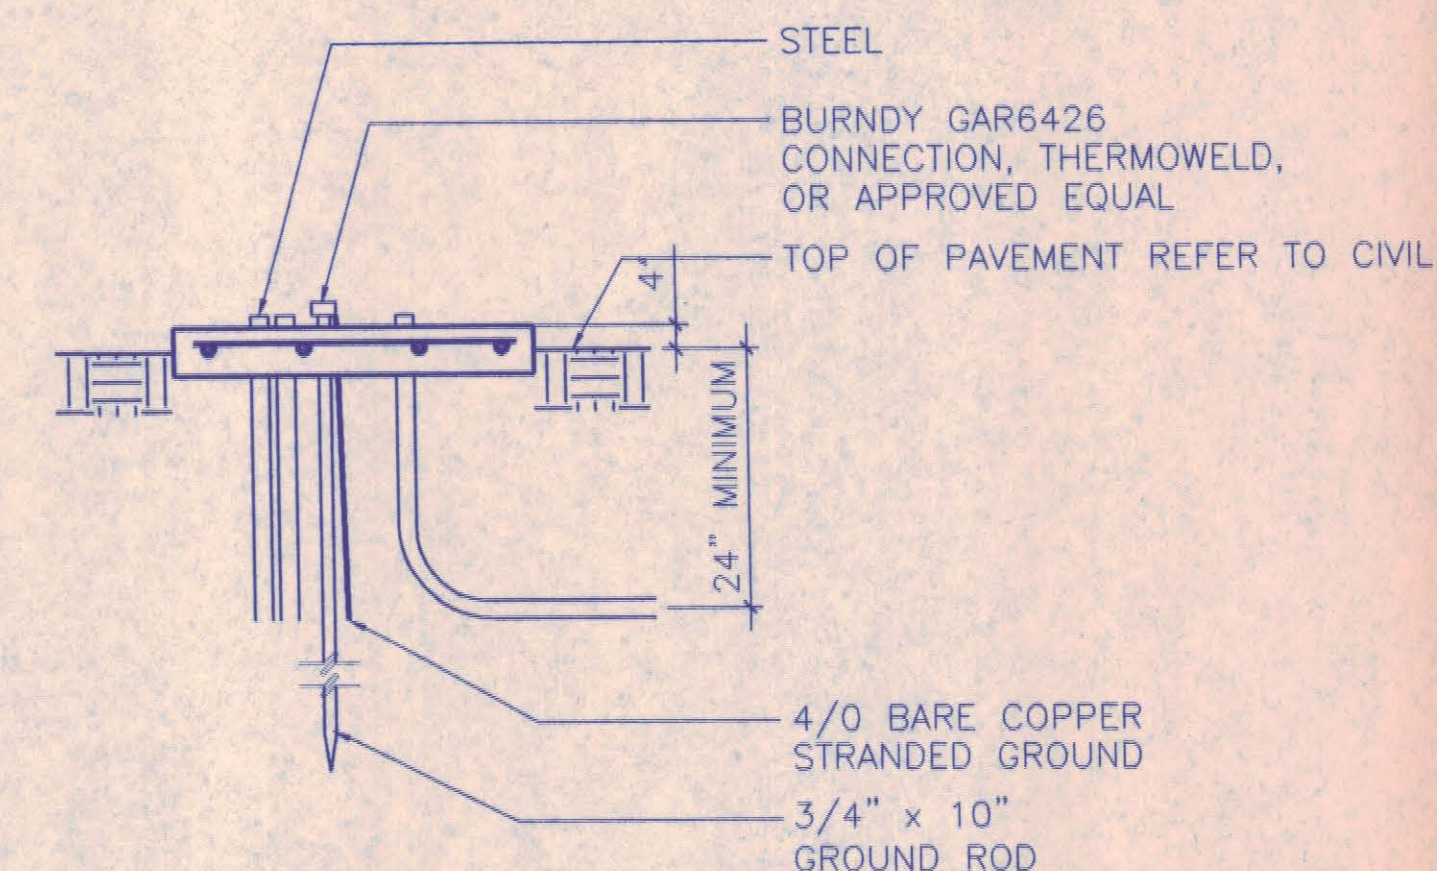

3 TRANSFM. PAD/GROUNDING
N.T.S. TAATED08

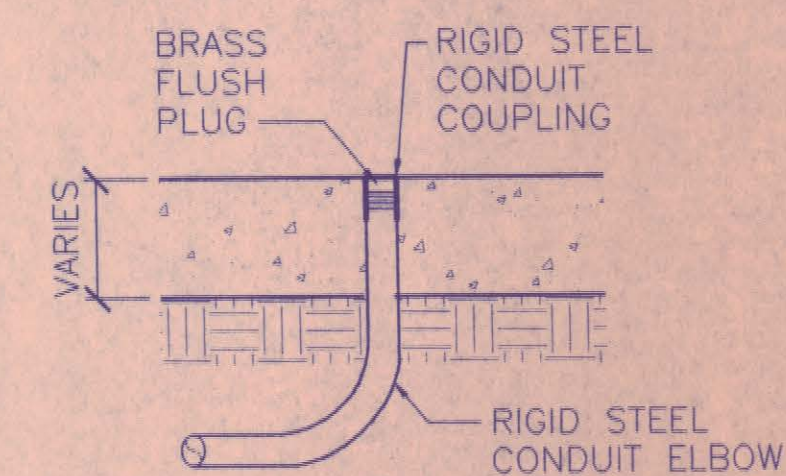

2 CONDUIT FLUSH TERMIN.
N.T.S. TAATED10

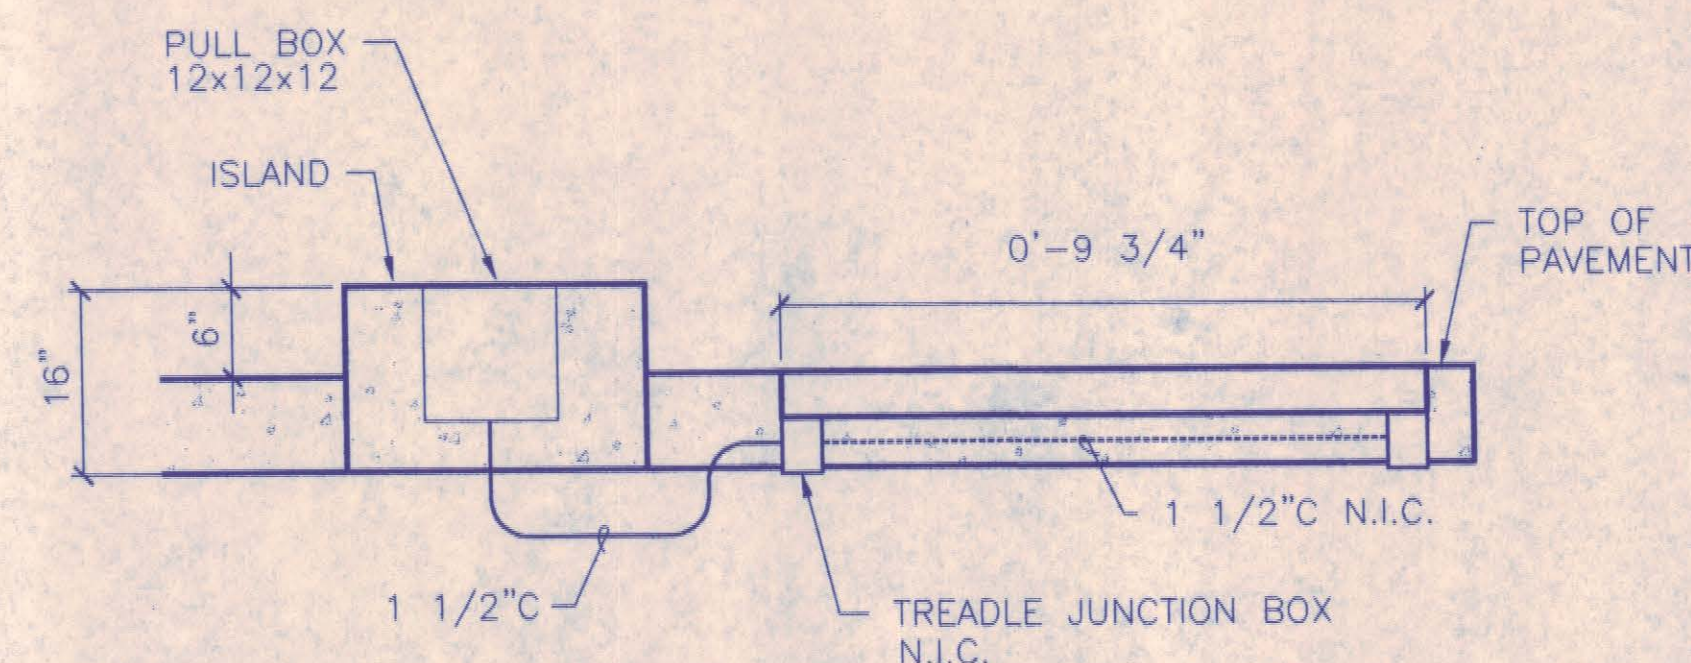

NOTE


REFER TO CIVIL DRAWING SHEET RX_C3.2.
CONTRACTOR TO VERIFY EXACT REQUIREMENT WITH TREADLE INSTALLER.

9 TREADLE DETAIL
N.T.S. TAATED29




NO.	REVISION	BY	DATE
NORTH TEXAS TOLLWAY AUTHORITY			
ADDISON AIRPORT TUNNEL			
BARRIER TOLL PLAZA			
ELECTRICAL DETAILS			
AGUILERA Corporation 9700 PARK CENTRAL DRIVE 16 TH FLOOR DALLAS TEXAS 75241 TEL. 972 755-1005			SECTION XIII
CHECKED <i>E.P.</i>	DATE 12/18/97	DESIGNED <i>FA</i>	DATE 12/20/97
CHECKED <i>kg</i>	DATE 12/18/97	SCALE N.T.S.	
CONTRACT NO. DNT-290	SHEET 51	OF 53	

AT-E6.2

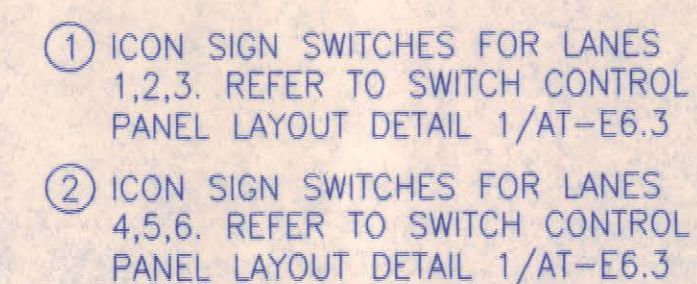

NO.	REVISION	BY	DATE
NORTH TEXAS TOLLWAY AUTHORITY ADDISON AIRPORT TUNNEL BARRIER TOLL PLAZA			
ELECTRICAL DETAILS			
AGUIRRE CORPORATION 2700 PARK CENTRAL DRIVE 15 TH FLOOR DALLAS TEXAS 75201 TEL. (972) 795-9505		SECTION XIII	
CHECKED <i>B.D.</i> <i>Feb</i>	DATE 12/18/97	DESIGNED <i>FA</i>	DATE 12/20/96
CHECKED <i>Feb</i>	DATE 12/18/97	SCALE N.T.S.	
CONTRACT NO. DNT-290		SHEET 52 OF 53	

AT-E6.3

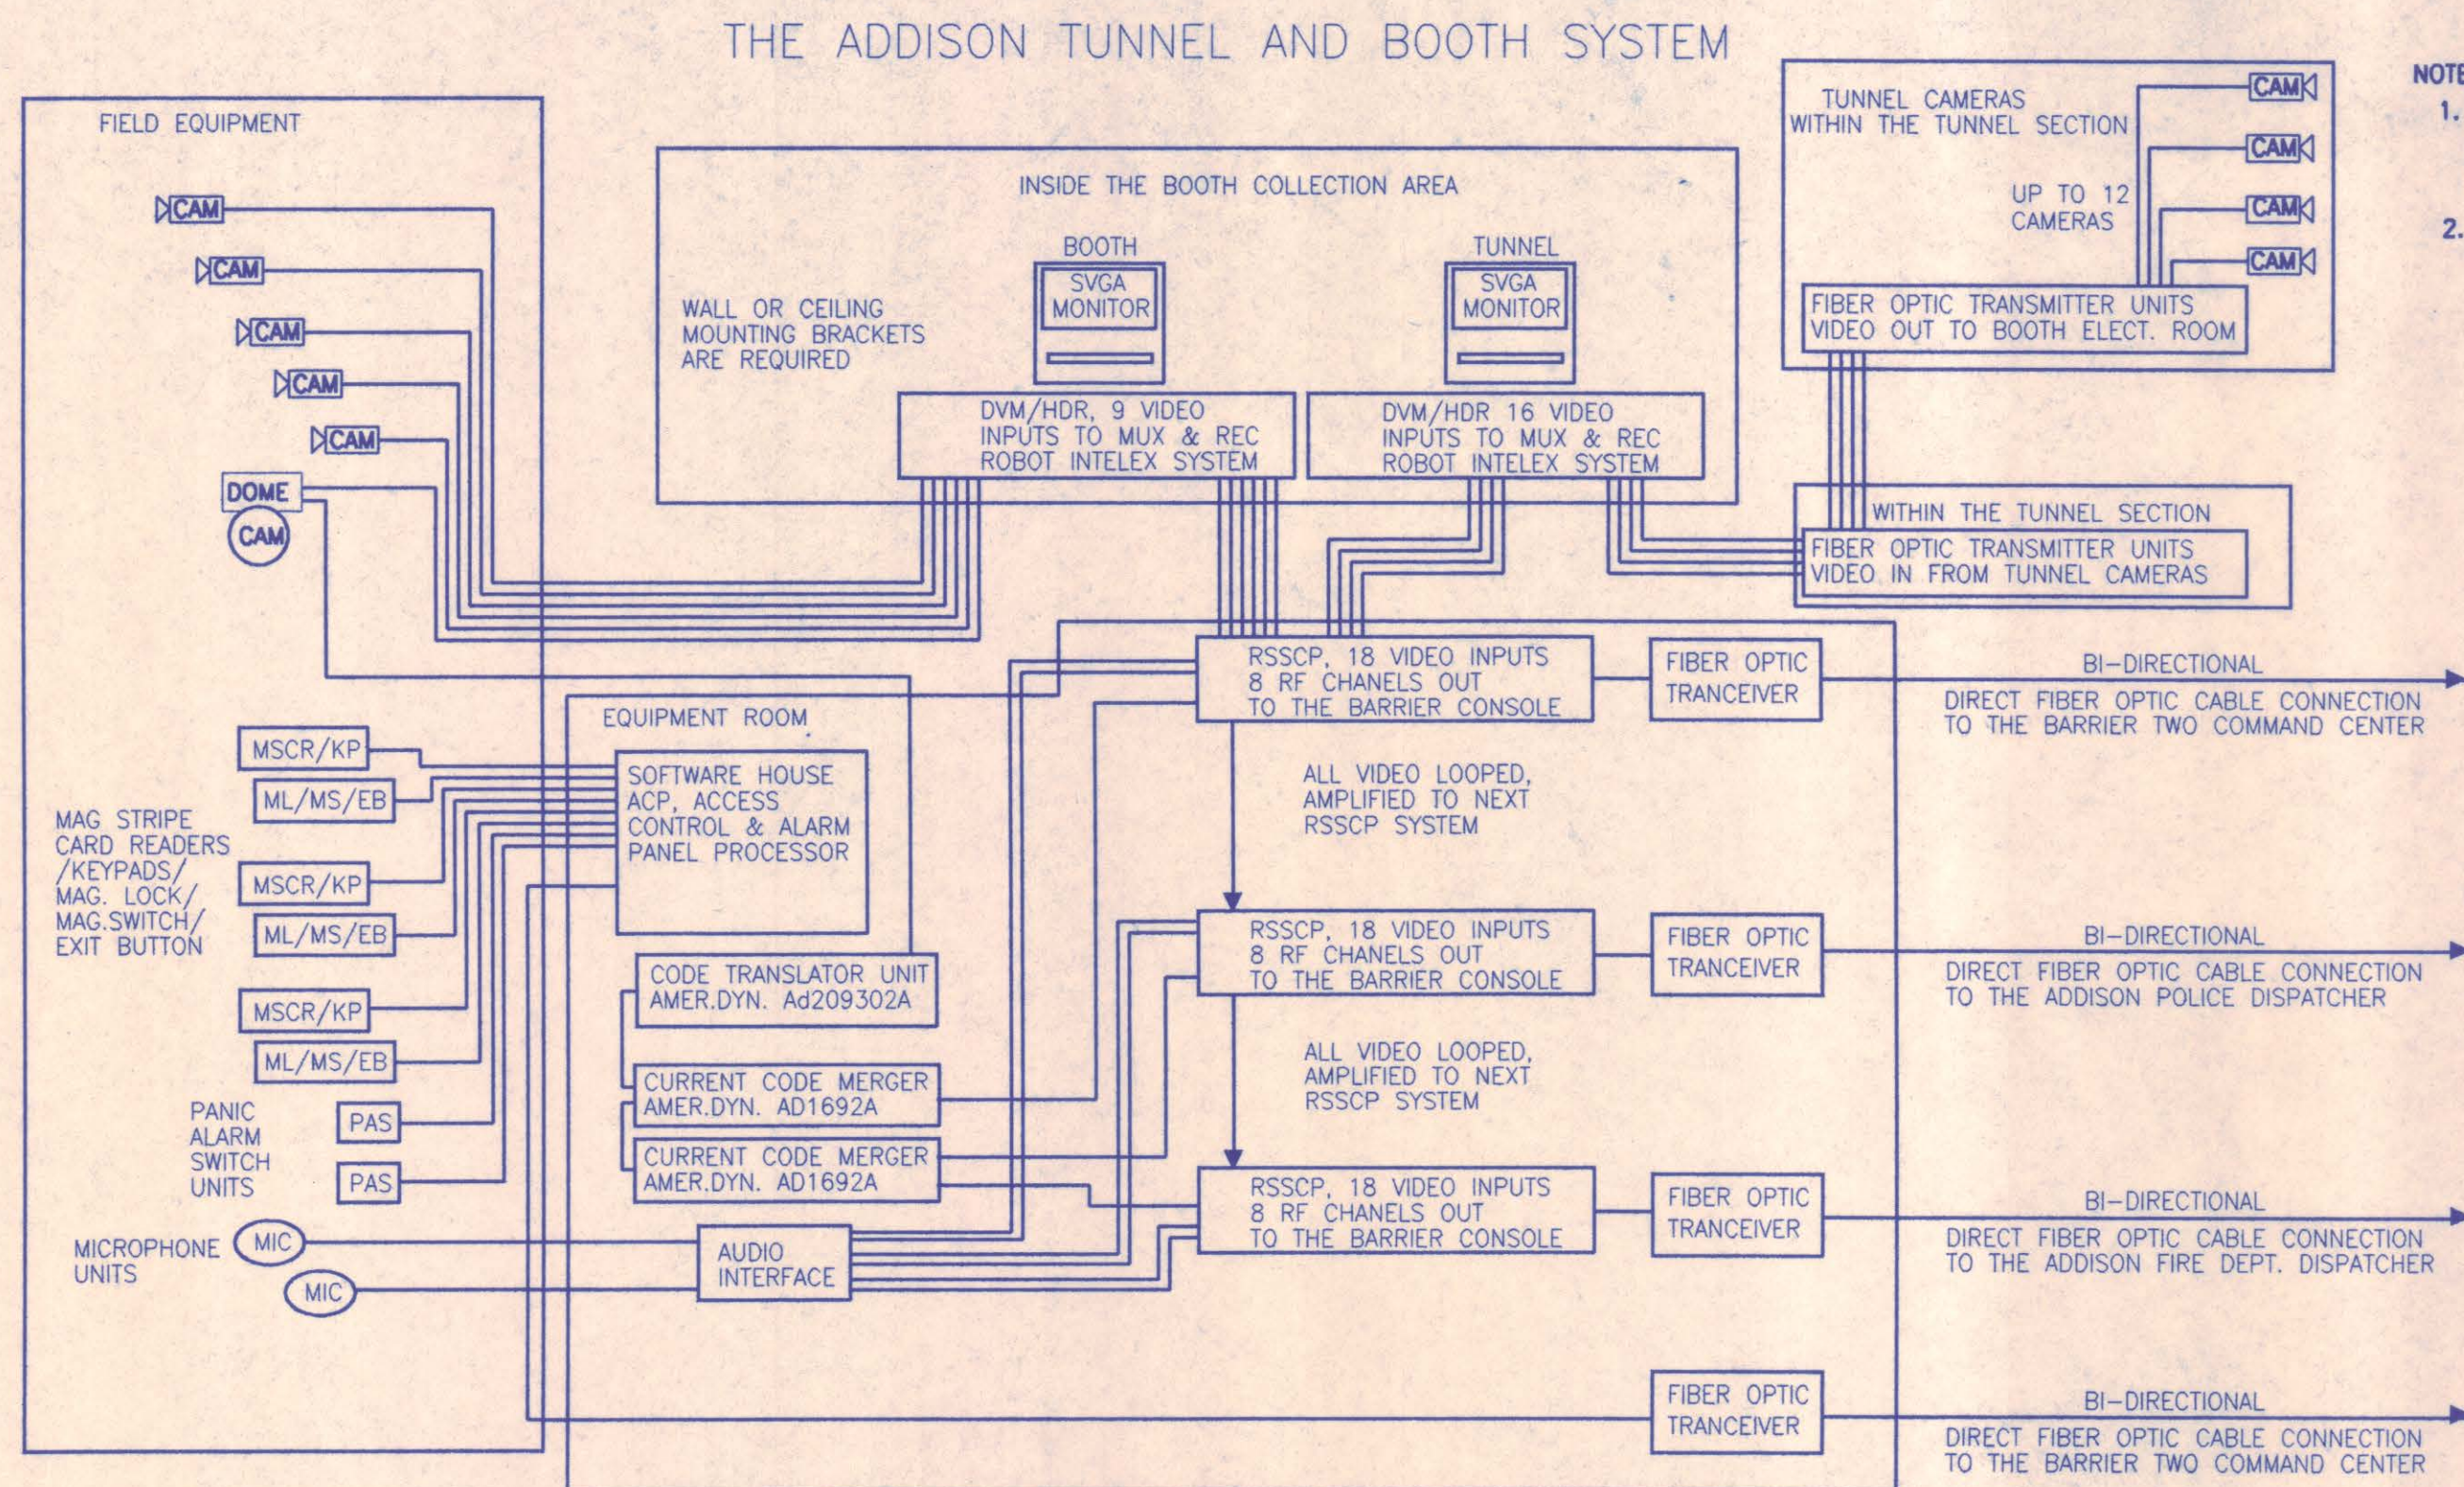

NOTE:

1. THE RISER DIAGRAM IS AN ILLUSTRATION ONLY. OF THE REQUIRED SYSTEM EQUIPMENT LAYOUT AND INTERCONNECTION FOR A COMPLETE AND OPERATIONAL ELECTRONIC SECURITY SYSTEM.
2. THE CONTRACTOR IS ULTIMATELY RESPONSIBLE FOR A COMPLETE AND WORKING SYSTEM WHICH CONFORMS TO THE DESIRED OPERATIONAL FEATURES AND FUNCTIONS AS DESCRIBED WITHIN THE WRITTEN SYSTEM SPECIFICATIONS.

2 SECURITY AND CCTV RISER

NONE TAATEOL4.DWG

PANEL LA SECTION 1 OF 2 SURFACE MOUNTED SERVES ADDISON TUNNEL PLAZA LOCATION ELEC RM 104

225 AMP MCB 208Y/120 VOLTS 3 PHASE 4 WIRE S/N AIC 10,000

CONN KVA	DESCRIPTION	TRIP AMPS	POLES	CKT NO	PHASE	CKT NO	POLES	TRIP AMPS	DESCRIPTION	CONN KVA
0.54	RECEPTACLES	20	1	1	A	2	1	20	ILP	1.2
1.00	UNDER COUNTER HTR	20	1	3	B	4	1	20	ILP	1.2
0.36	ACM/PTD	20	1	5	C	6	1	20	ILP	1.2
0.54	RECEPTACLES	20	1	7	A	8	1	20	ILP	1.2
1.00	UNDER COUNTER HTR	20	1	9	B	10	1	20	ILP	1.2
0.36	ACM/PTD	20	1	11	C	12	1	20	ILP	1.2
0.75	MICROWAVE	20	1	13	A	14	1	20	AAT SIGN	0.50
0.50	REFRIGERATOR	20	1	15	B	16	1	20	AAT SIGN	0.50
0.2	HEAT TRACE	20	1	17	C	18	1	20	BILL CHANGER	0.50
0.40	CCTV (4) #1, #2, #3, #4	20	1	19	A	20	1	20	BILL CHANGER	0.50
0.60	CCTV #5	20	1	21	B	22	1	20	EXIT ICON SIGN	0.50
0.60	CCTV #6	20	1	23	C	24	1	20	EXIT ICON SIGN	0.50
0.50	FACP	20	1	25	A	26	1	20	EXIT ICON SIGN	0.50
0.54	SECURITY MONITOR	20	1	27	B	28	1	20	ENTRY SIGN ICON	0.50
0.36	TELEPHONE	20	1	29	C	30	1	20	ENTRY SIGN ICON	0.50
0.72	RECEPTACLES	20	1	31	A	32	1	20	ENTRY SIGN ICON	0.50
0.54	RECEPTACLES	20	1	33	B	34	1	20	CANOPY LIGHTS	0.90
0.36	RTU'S RECEPTACLES	20	1	35	C	36	1	20	CANOPY LIGHTS	0.90
1.00	RACK PLUGMOLD	20	1	37	A	38	1	20	CANOPY LIGHTS	0.90
1.00	RACK PLUGMOLD	20	1	39	B	40	1	20	CANOPY LIGHTS	0.90
1.00	RACK PLUGMOLD	20	1	41	C	42	1	20	EXTERIOR BOOTH LIGHTS	0.90

REMARKS:

* RUN CIRCUITS THRU CONTACTORS CONTROLLED BY PHOTOCELL AND/OR OVERRIDE SWITCH.

NOTES:



1. PROVIDE SUBFEED THRU LUGS FOR SECTION TWO PANEL.
2. INSTALL TVSS IN PANEL. LIEBERT S120Y111-R OR EQUAL.

PANEL LA SECTION 2 OF 2 SURFACE MOUNTED SERVES ADDISON TUNNEL PLAZA LOCATION ELEC RM 104

225 AMP MLO 208Y/120 VOLTS 3 PHASE 4 WIRE S/N 10,000

CONN KVA	DESCRIPTION	POLES	TRIP AMPS	CKT NO	PHASE	CKT NO	TRIP AMPS	POLES	DESCRIPTION	CONN KVA
11.2	RTU-2	45	43	44	A	44	30	1	WATER HEATER	1.5
		45	46	46	B	46	20	1	WATER CHILLER	0.164
		47	48	48	C	48	20	1	BOOTH LIGHTS	0.72
5.40	RTU-1	20	49	50	A	50	20	1	SPARE	-
3.00	UPS	2	51	52	B	52	20	1	SPARE	-
		20	53	54	C	54	20	1	SPARE	-
	SPARE	2	55	56	A	56	20	1	SPARE	-
	SPARE	1	57	58	B	58	20	1	SPARE	-
	SPARE	1	59	60	C	60	20	1	SPARE	-
	SPARE	1	61	62	A	62	-	-	SPARE	-
	SPARE	-	63	64	B	64	-	-	SPARE	-
	SPARE	-	65	66	C	66	-	-	SPARE	-
	SPARE	-	67	68	A	68	-	-	SPARE	-
	SPARE	-	69	70	B	70	-	-	SPARE	-
	SPARE	-	71	72	C	72	-	-	SPARE	-
	SPARE	-	73	74	A	74	-	-	SPARE	-
	SPARE	-	75	76	B	76	-	-	SPARE	-
	SPARE	-	77	78	C	78	-	-	SPARE	-
	SPARE	-	79	80	A	80	-	-	SPARE	-
	SPARE	-	81	82	B	82	-	-	SPARE	-
	SPARE	-	83	84	C	84	-	-	SPARE	-

REMARKS:

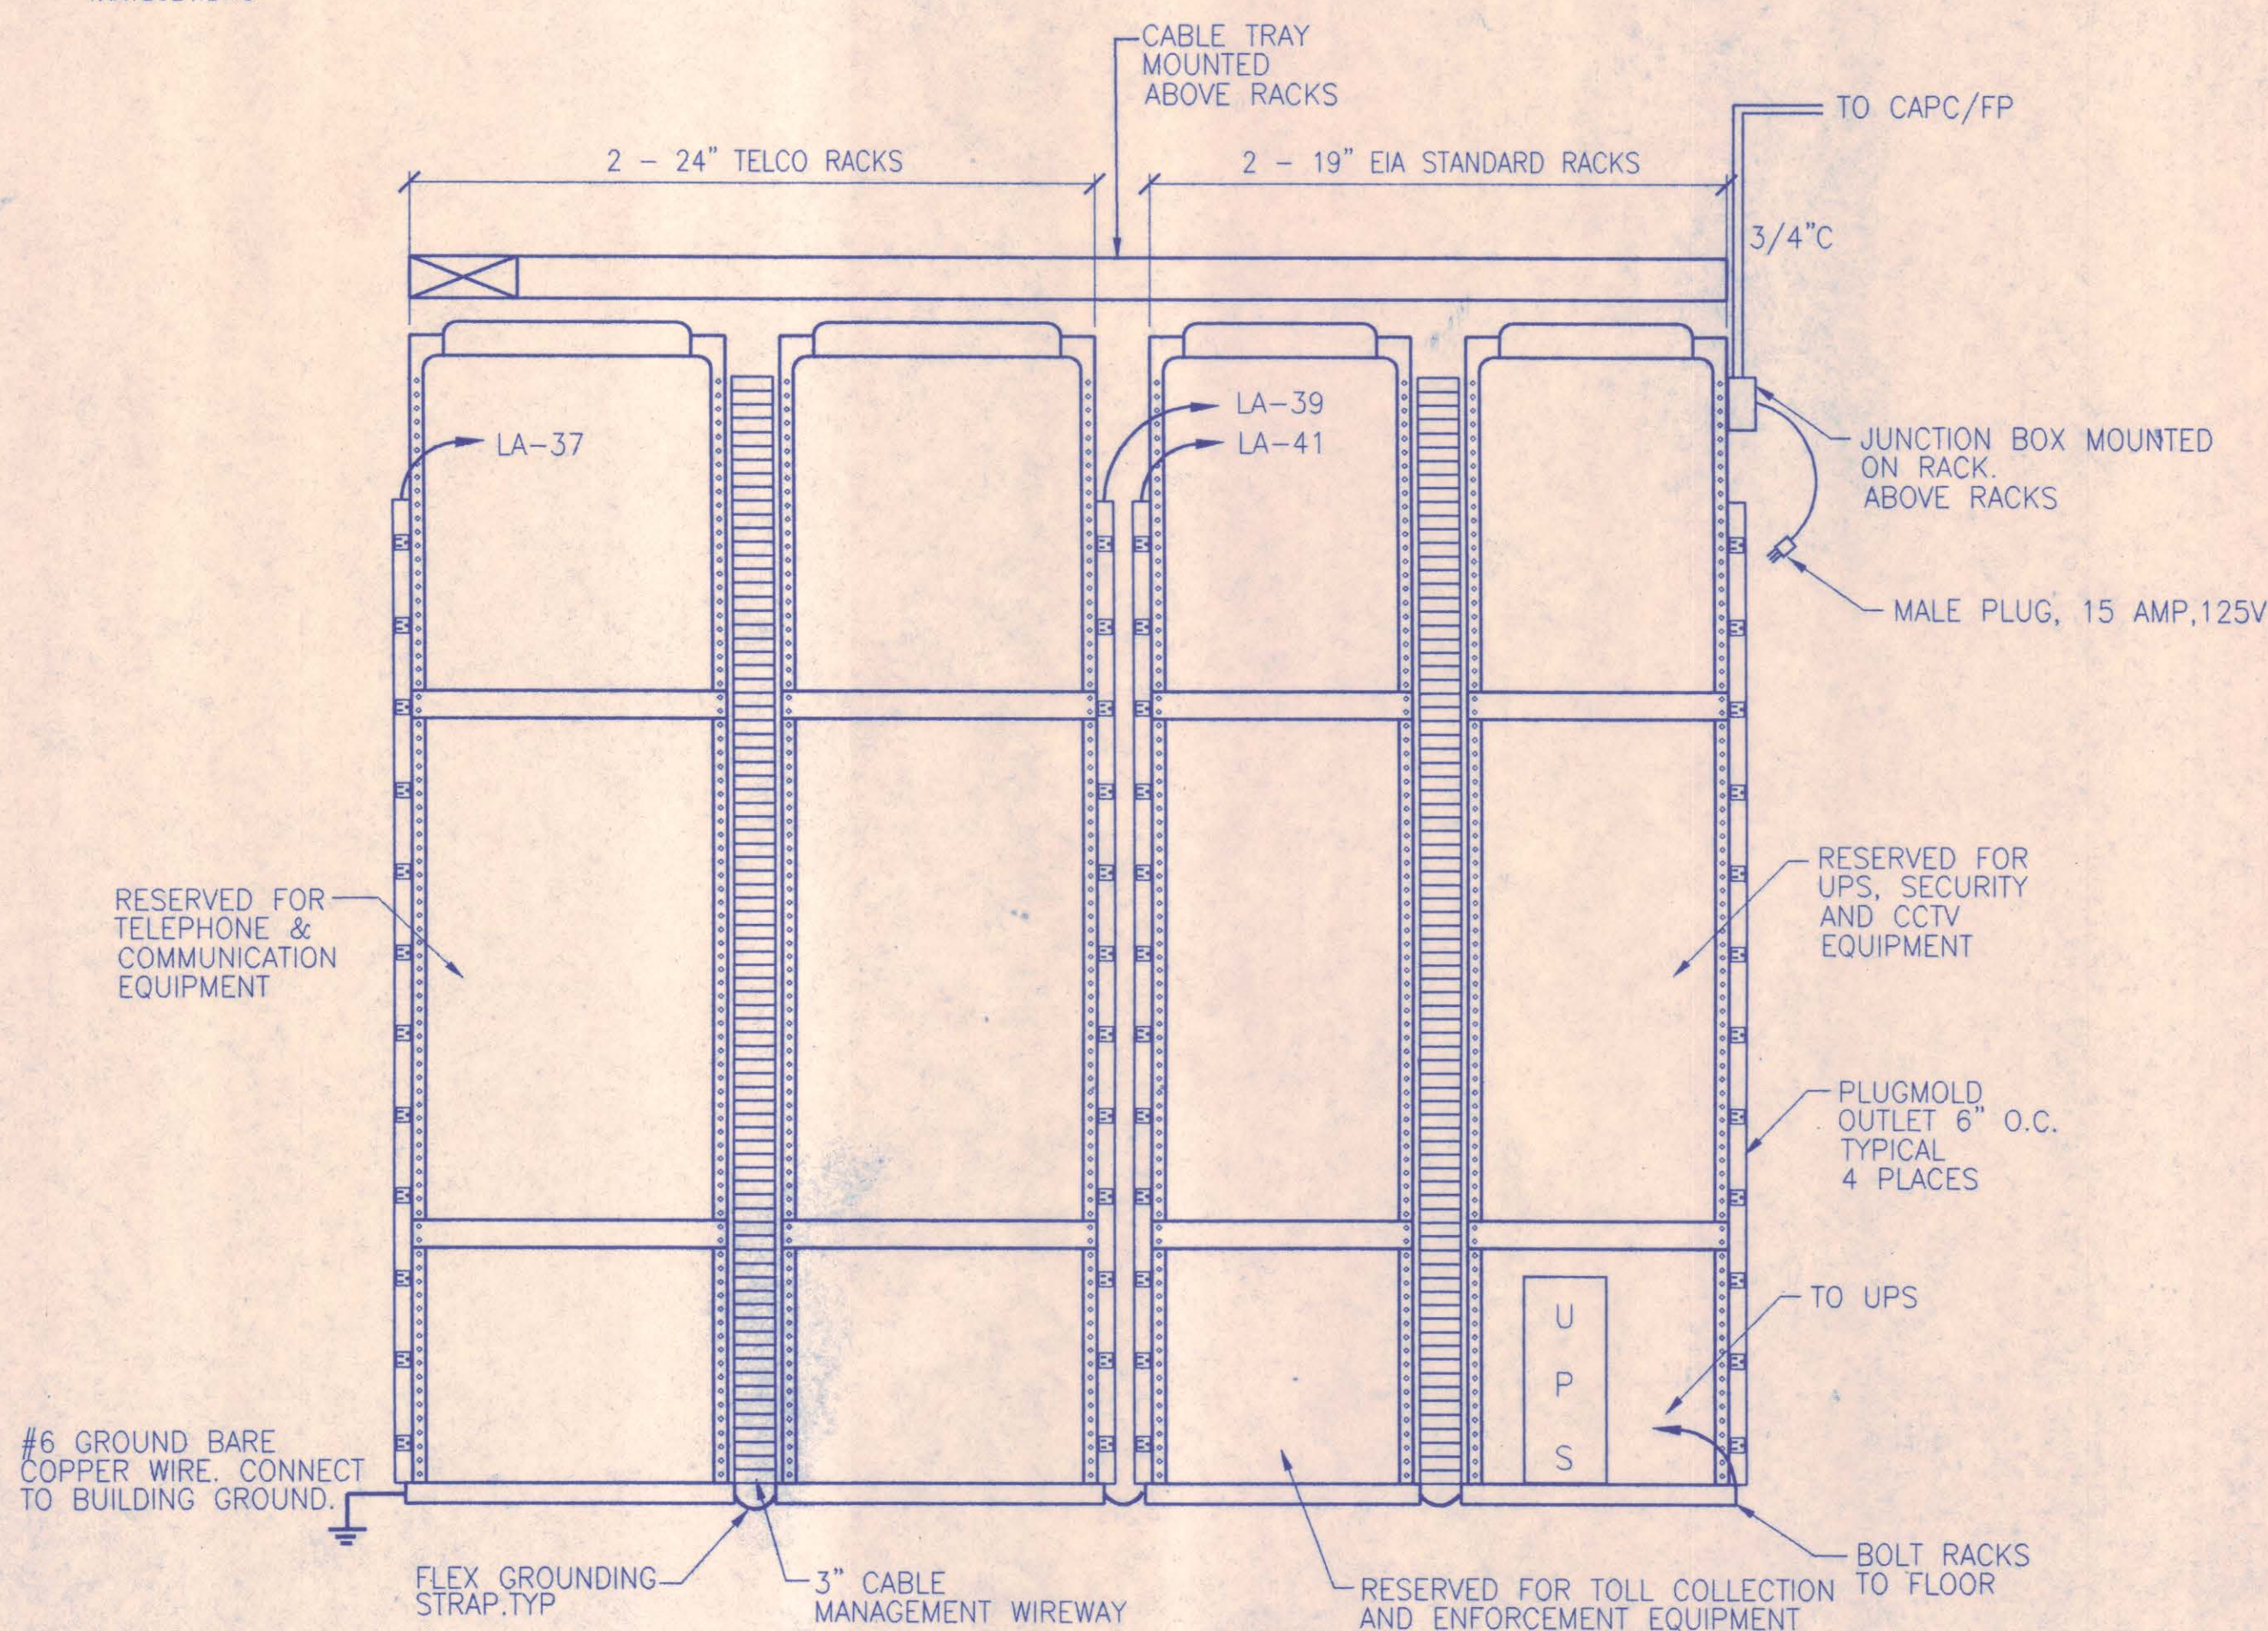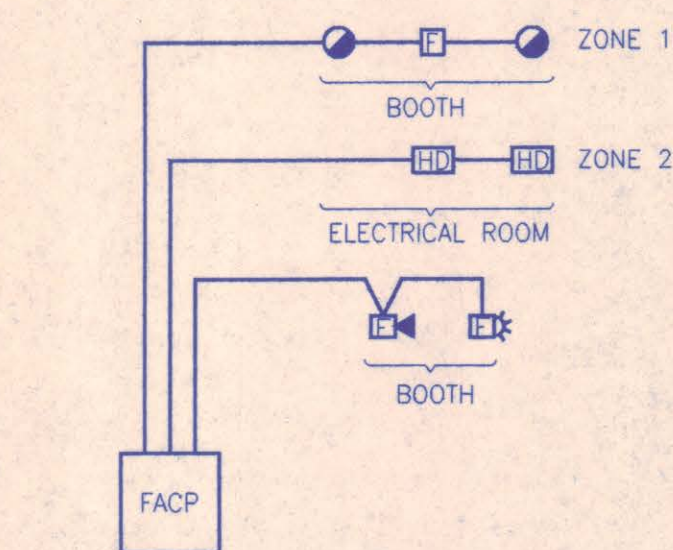

3 PLUGMOLD ALONG CABLE RACK

1"=1'-0" TAATED18.DWG



NO. REVISION BY DATE

NORTH TEXAS TOLLWAY AUTHORITY

ADDISON AIRPORT TUNNEL

BARRIER TOLL PLAZA

ELECTRICAL SCHEDULES AND RISER DIAGRAMS

SECTION XIII

CHECKED BY DATE 12/18/97 DESIGNED FA DATE 12/20/96


CHECKED BY DATE 12/18/97 SCALE AS NOTED

CONTRACT NO. DNT-290 SHEET 53 OF 53

AT-E7.1



0 10 20
SCALE IN FEET


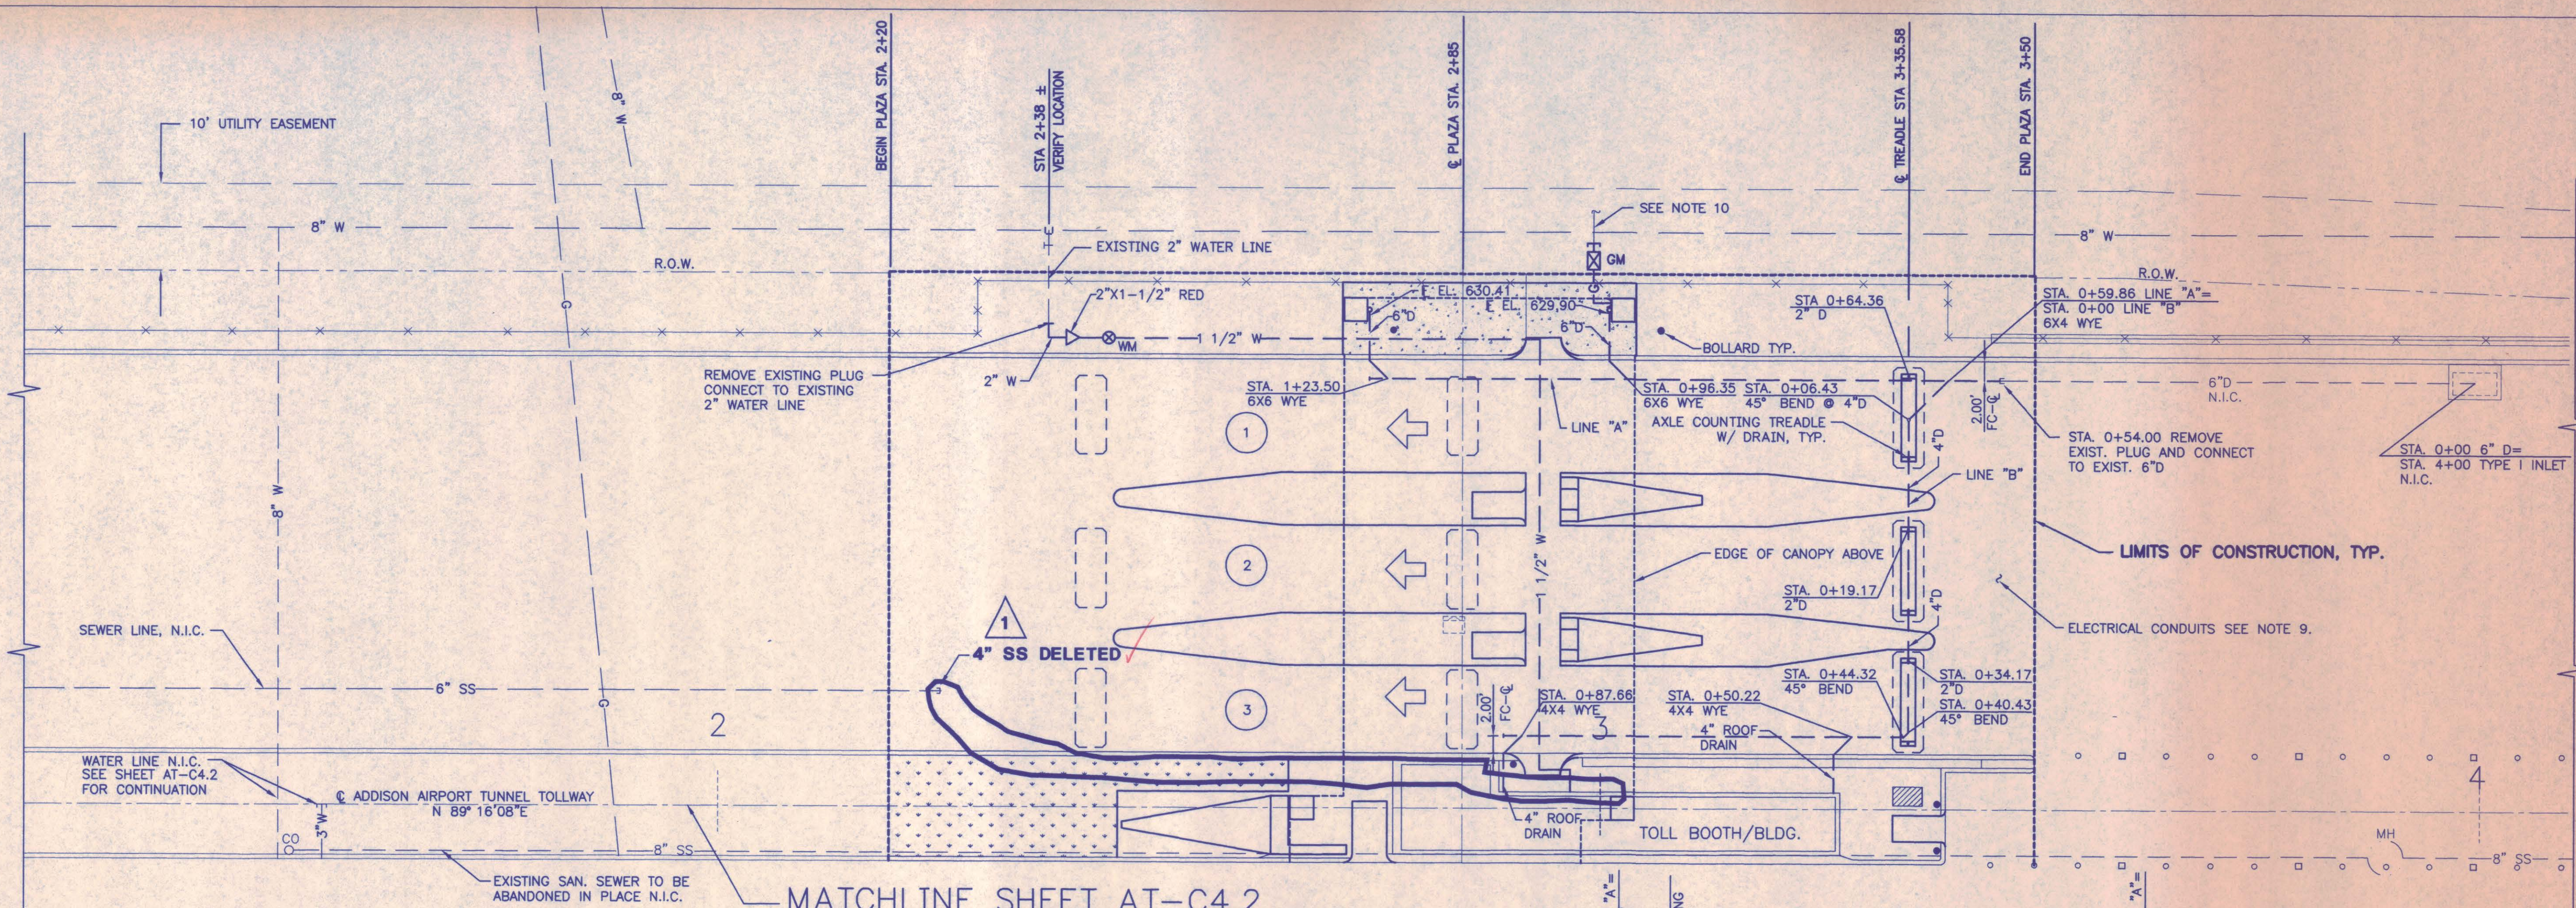


LEGEND:

NEW	
— W —	WATER LINE
— G —	GAS LINE
— SS —	SANITARY SEWER LINE
— D —	DRAIN LINE
— WM —	WATER METER (WM)
— GM —	GAS METER (GM)
EXISTING OR BY OTHERS	
— W-T —	WATER LINE W/VALVE
— G —	GAS LINE
— D —	DRAIN LINE
— SS —	SANITARY SEWER LINE W/MH AND CO
○ MH	
○ CO	

NOTES:


- SEE GENERAL NOTES ON SHEET AT-C1.1.
- ALL WATER, SANITARY SEWER, AND DRAINAGE CONSTRUCTION SHALL CONFORM TO THE TOWN OF ADDISON STANDARDS, AND NORTH CENTRAL TEXAS COUNCIL OF GOVERNMENTS STANDARD SPECIFICATIONS FOR PUBLIC WORK CONSTRUCTION.
- ALL WATER LINES SHALL BE TYPE K COPPER PIPE CONFORMING TO ASTM B88.
- ALL SANITARY SEWER LINES AND DRAIN LINES SHALL BE SDR-35 PVC PIPE.
- EMBEDMENT FOR ALL PVC SANITARY SEWER LINES AND DRAIN LINES SHALL BE CLASS 4 EMBEDMENT CONFORMING TO TOWN OF ADDISON STANDARD CONSTRUCTION DETAILS.
- CONTRACTOR SHALL PROVIDE SHEETING AND SHORING AS REQUIRED TO PROTECT EXISTING UTILITIES AND STRUCTURES.
- PROVIDE A MINIMUM OF 3' COVER FOR ALL UTILITIES UNLESS OTHERWISE NOTED.
- REFER TO PLUMBING DRAWINGS FOR CONTINUATION OF WATER AND SANITARY SEWER LINES TO TOLL BOOTH BUILDING.
- REFER TO ELECTRICAL DRAWINGS FOR ELECTRICAL CONDUIT LOCATIONS.
- CONNECTION TO EXISTING GAS LINE WILL BE PROVIDED BY LONE STAR GAS. THE CONTRACTOR SHALL COORDINATE WITH LONE STAR GAS TO DETERMINE THE EXACT LOCATION OF THE SERVICE BEYOND THE METER.
- GAS METER AND REGULATOR TO PROVIDE 30 CFH AT MEDIUM PRESSURE 2 PSI TO 1.5 PSI.

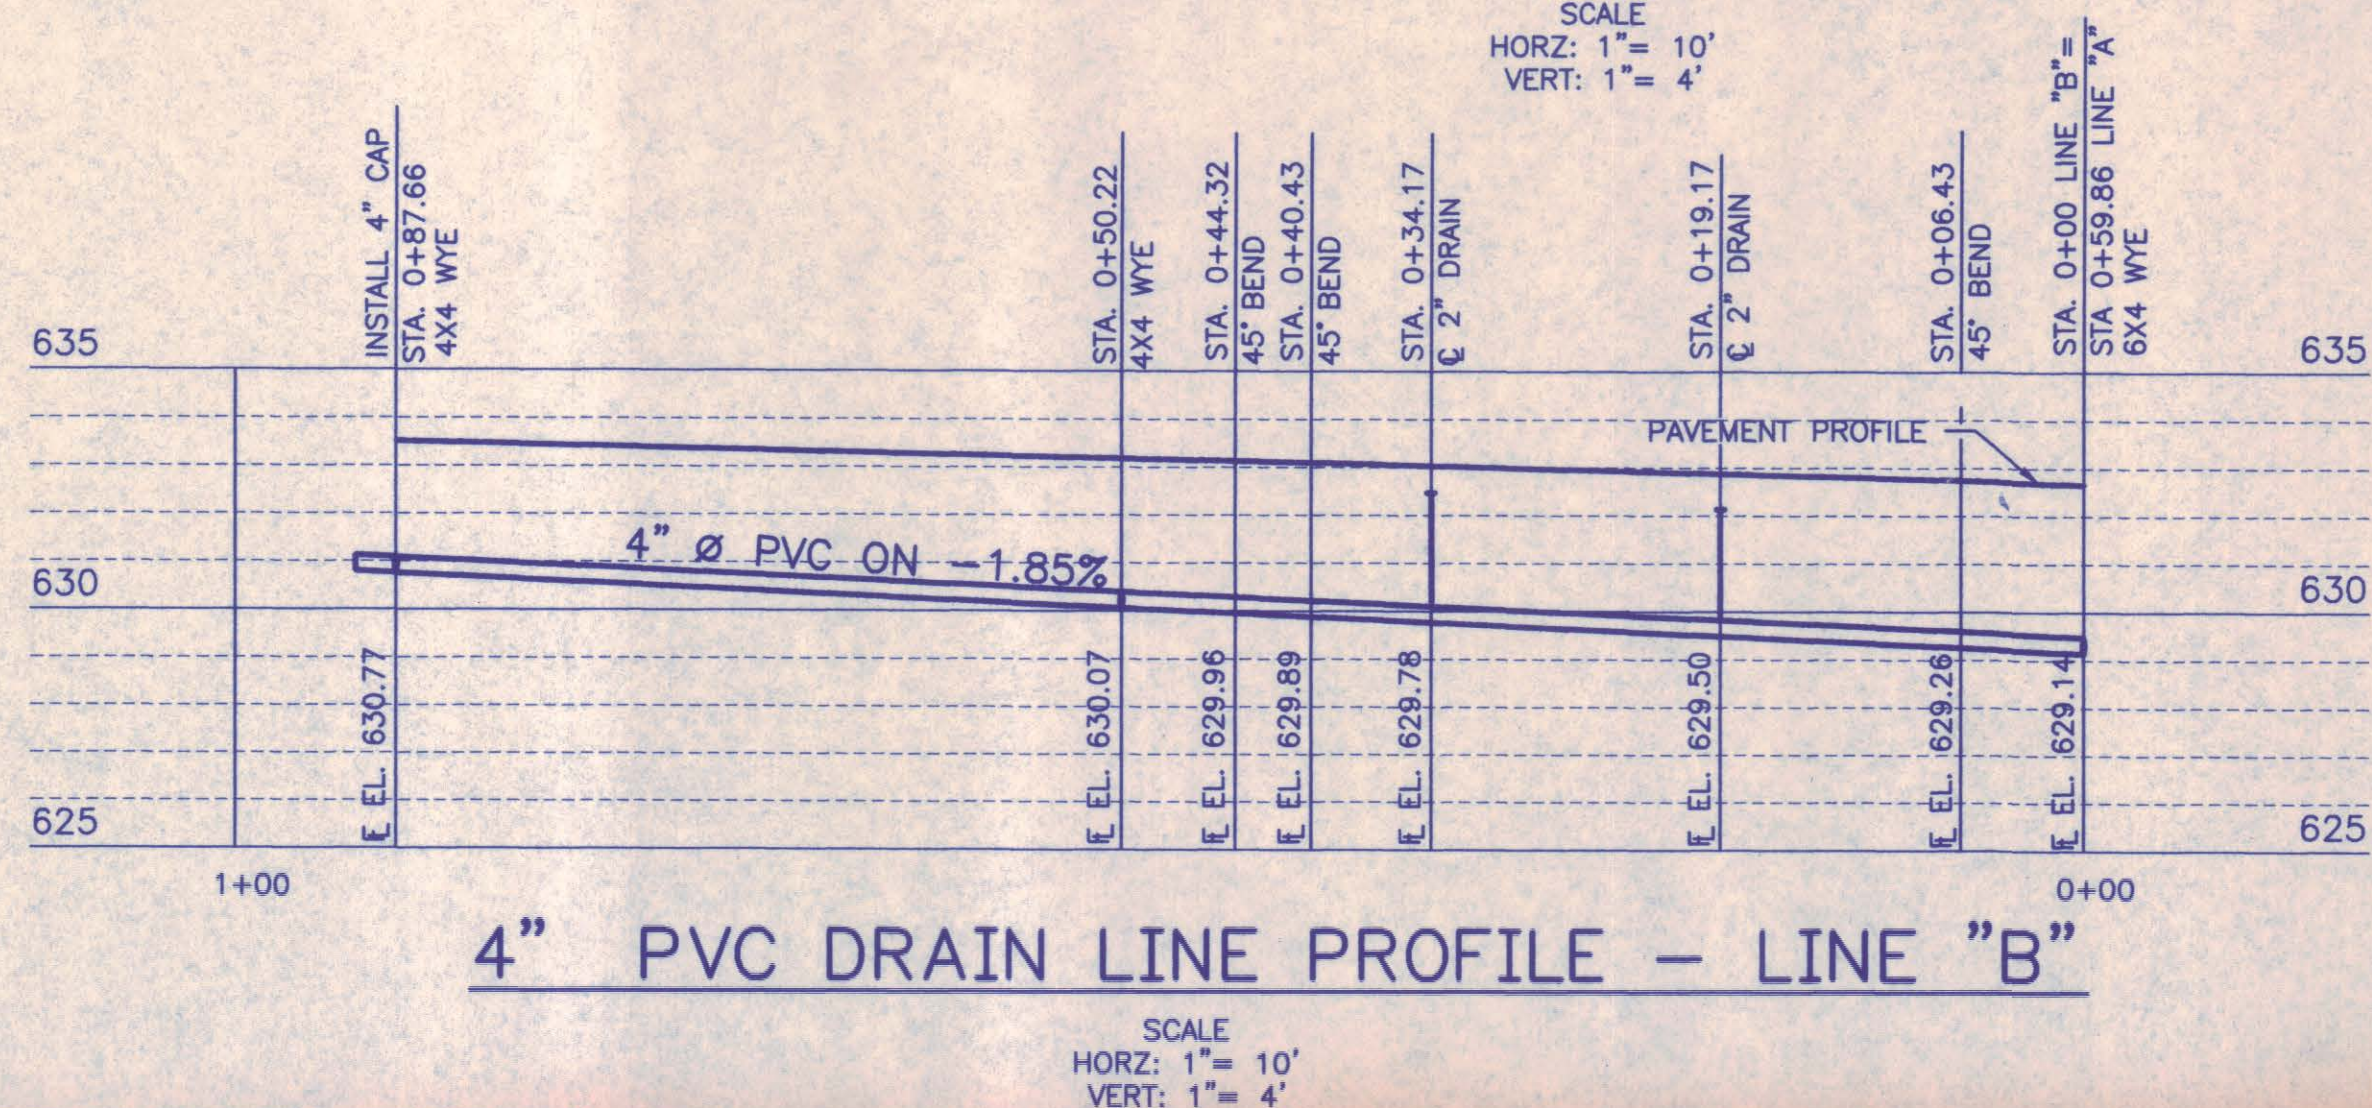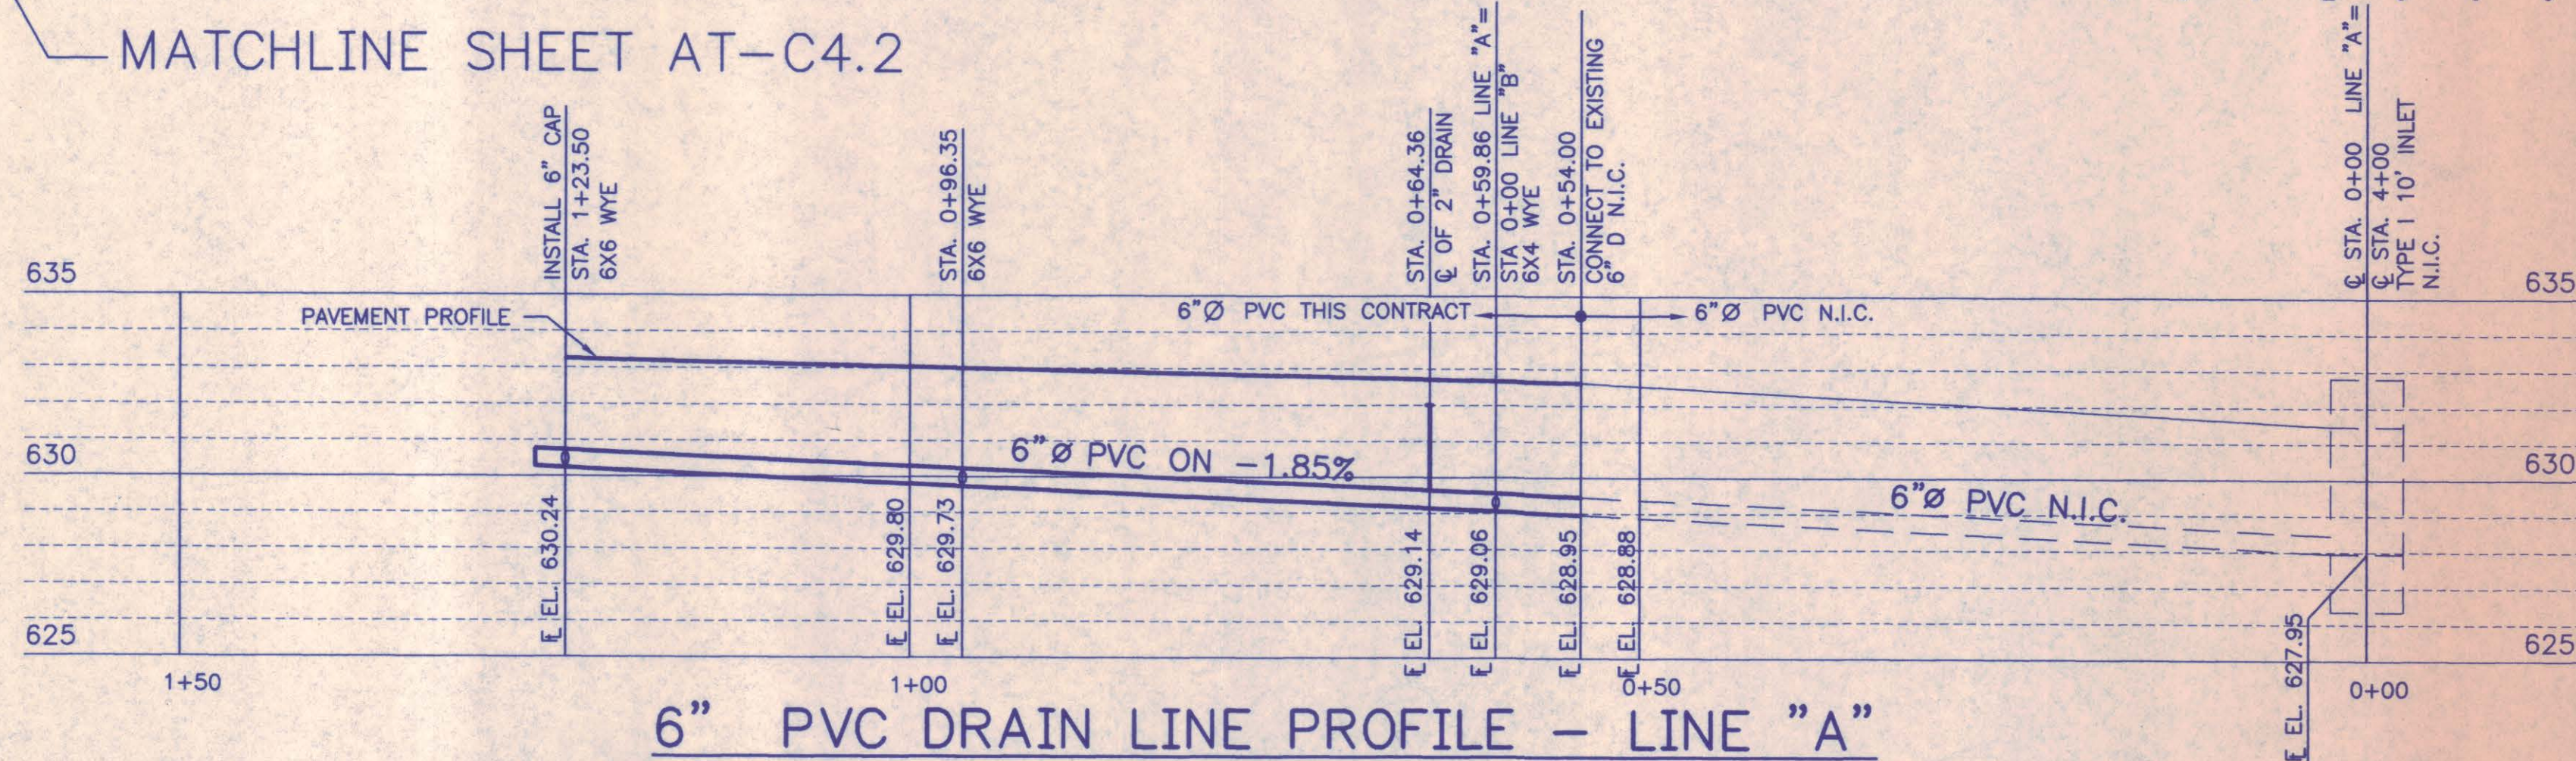

Chiang, Patel & Yerby, Inc.
Consulting Engineers • Planners • Project Managers
Dallas • Fort Worth • Houston • San Antonio

ADDENDUM NO. 1

AT-C4.1

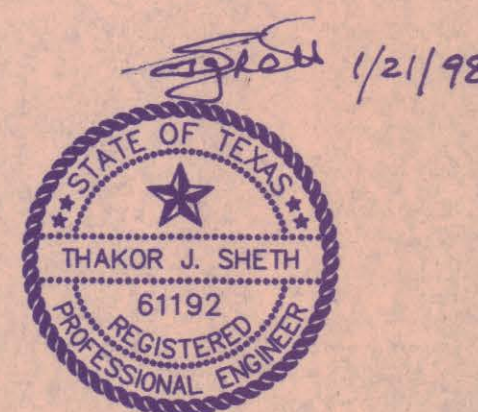


DELETED 4" S.S. WEST OF TOLL BOOTH	TJS	1/21/98
NO.	REVISION	BY DATE
NORTH TEXAS TOLLWAY AUTHORITY ADDISON AIRPORT TUNNEL		
UTILITY PLAN AND PROFILE A		
AGUIRRE ASSOCIATES INC. 12700 PARK CENTRAL DRIVE 15 TH FLOOR DALLAS TEXAS 75261 TEL (972) 788-1808		SECTION XIV
DRAWN WAB	DATE 8/28/97	DESIGNED WAB
CHECKED TJS	DATE 11/5/97	SCALE 1"=10'-0"
CONTRACT NO. DNT-290	SHEET 9	OF 53



SCALE IN FEET

MATCH LINE SHEET AT-C4.1

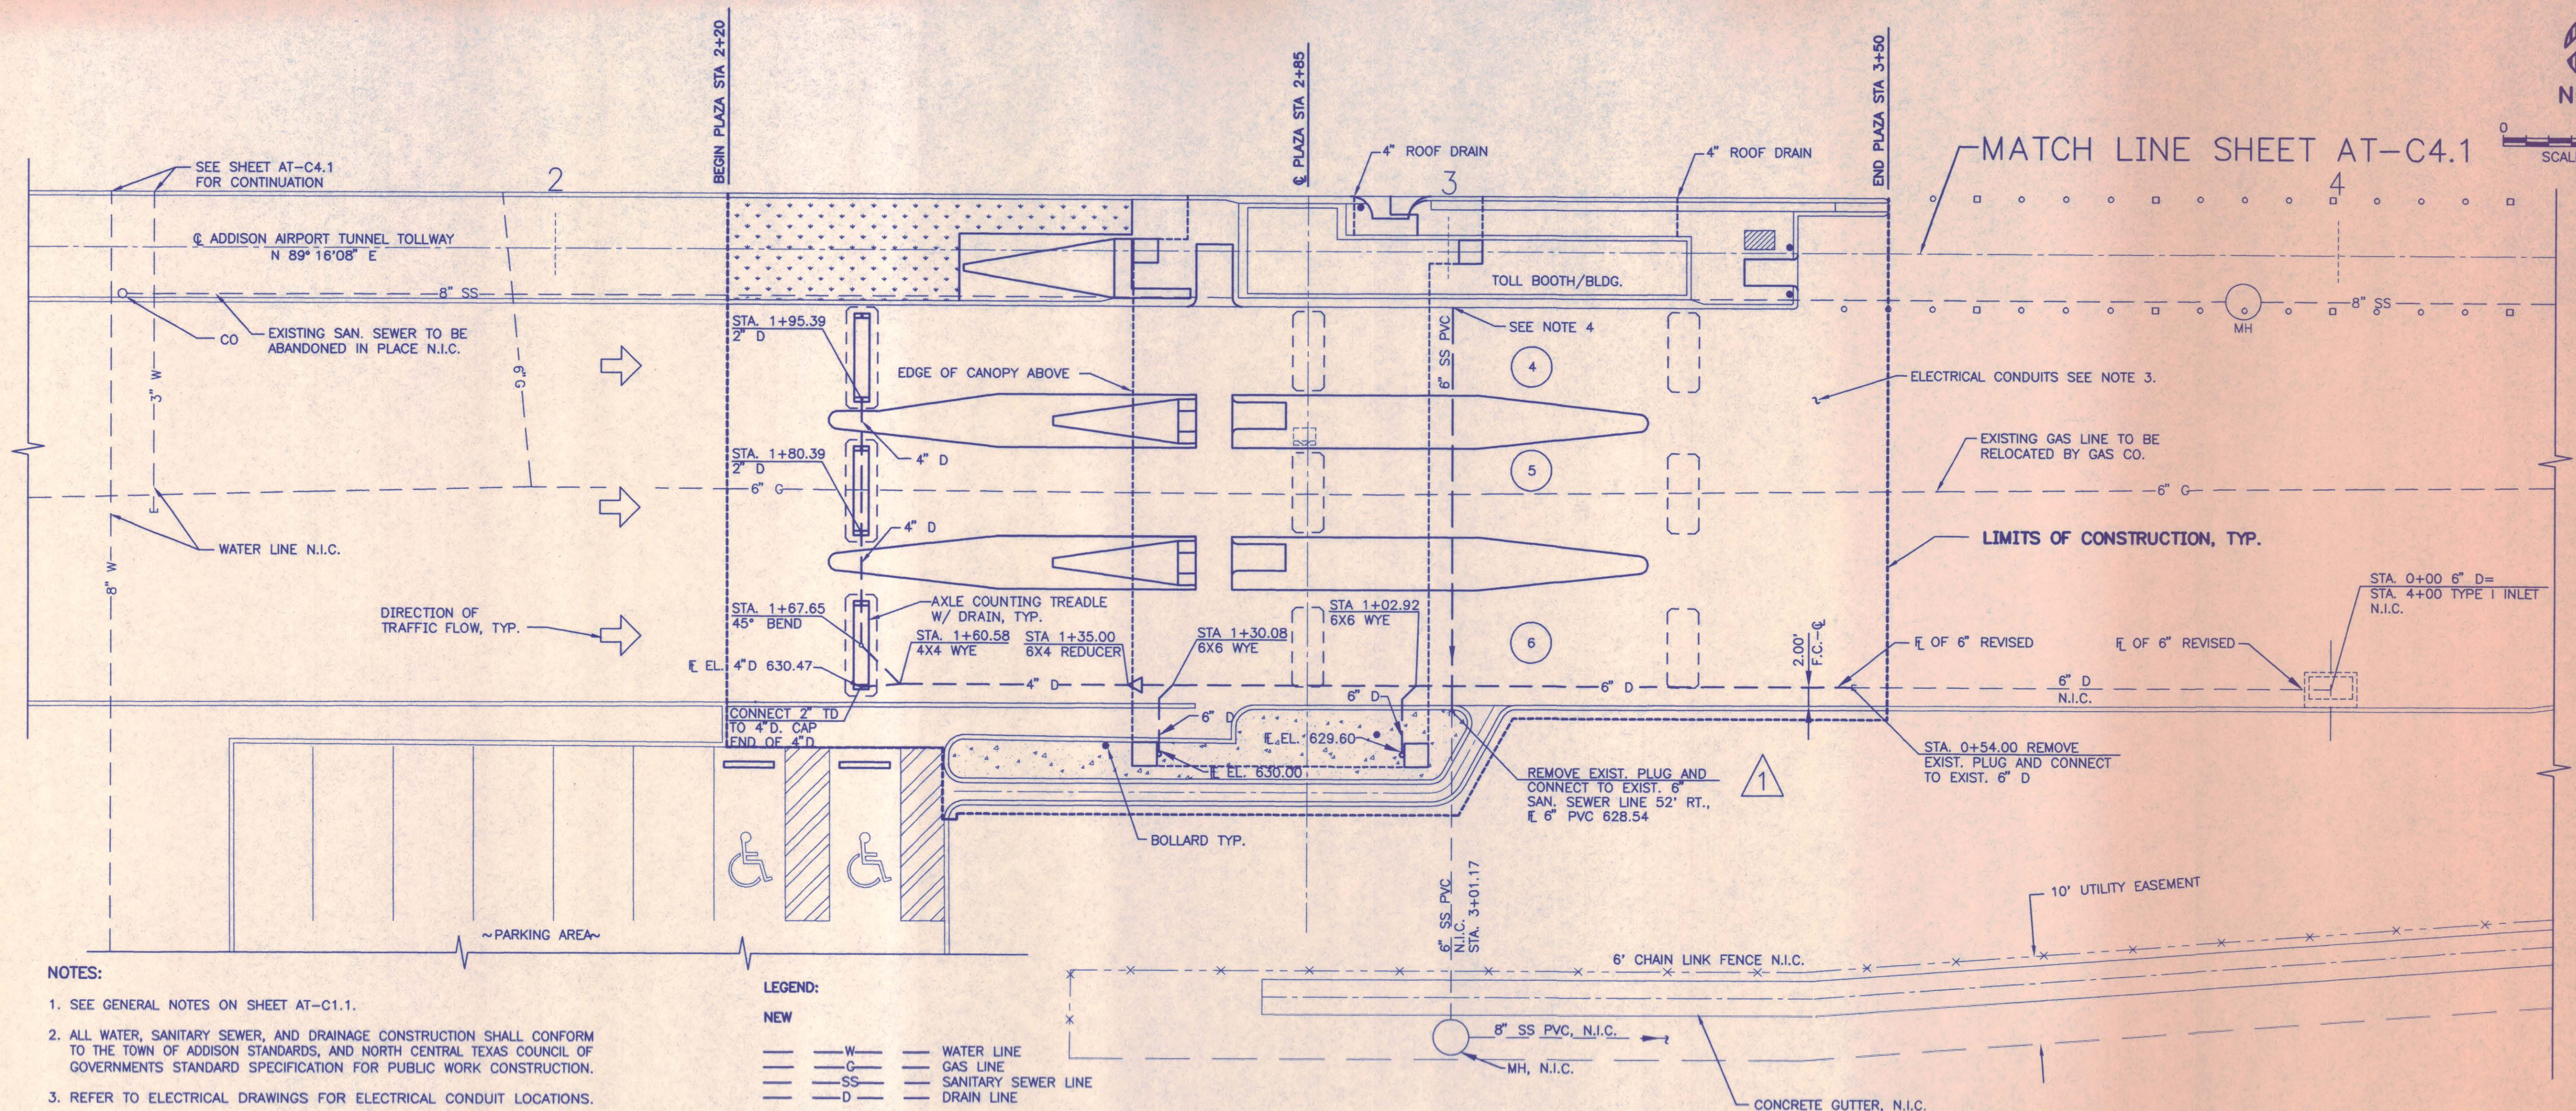


NOTES:

- SEE GENERAL NOTES ON SHEET AT-C1.1.
- ALL WATER, SANITARY SEWER, AND DRAINAGE CONSTRUCTION SHALL CONFORM TO THE TOWN OF ADDISON STANDARDS, AND NORTH CENTRAL TEXAS COUNCIL OF GOVERNMENTS STANDARD SPECIFICATION FOR PUBLIC WORK CONSTRUCTION.
- REFER TO ELECTRICAL DRAWINGS FOR ELECTRICAL CONDUIT LOCATIONS.
- REFER TO PLUMBING DRAWINGS FOR CONTINUATION OF WATER AND SEWER LINE TO TOLL BOOTH/BUILDING.
- DRAIN SHALL BE SDR-35 PVC PIPE. EMBEDMENT FOR PVC DRAIN LINES SHALL BE CLASS 4 EMBEDMENT CONFORMING TO TOWN OF ADDISON STANDARD CONSTRUCTION DETAILS.
- CONTRACTOR SHALL PROVIDE SHEETING AND SHORING AS REQUIRED TO PROTECT EXISTING UTILITIES AND STRUCTURES.

LEGEND:

- NEW
- W - WATER LINE
 - G - GAS LINE
 - SS - SANITARY SEWER LINE
 - D - DRAIN LINE
- EXISTING OR BY OTHER
- W-T - WATER LINE W/VALVE
 - G - GAS LINE
 - D - DRAIN LINE
 - SS - SANITARY SEWER LINE W/MH AND CO

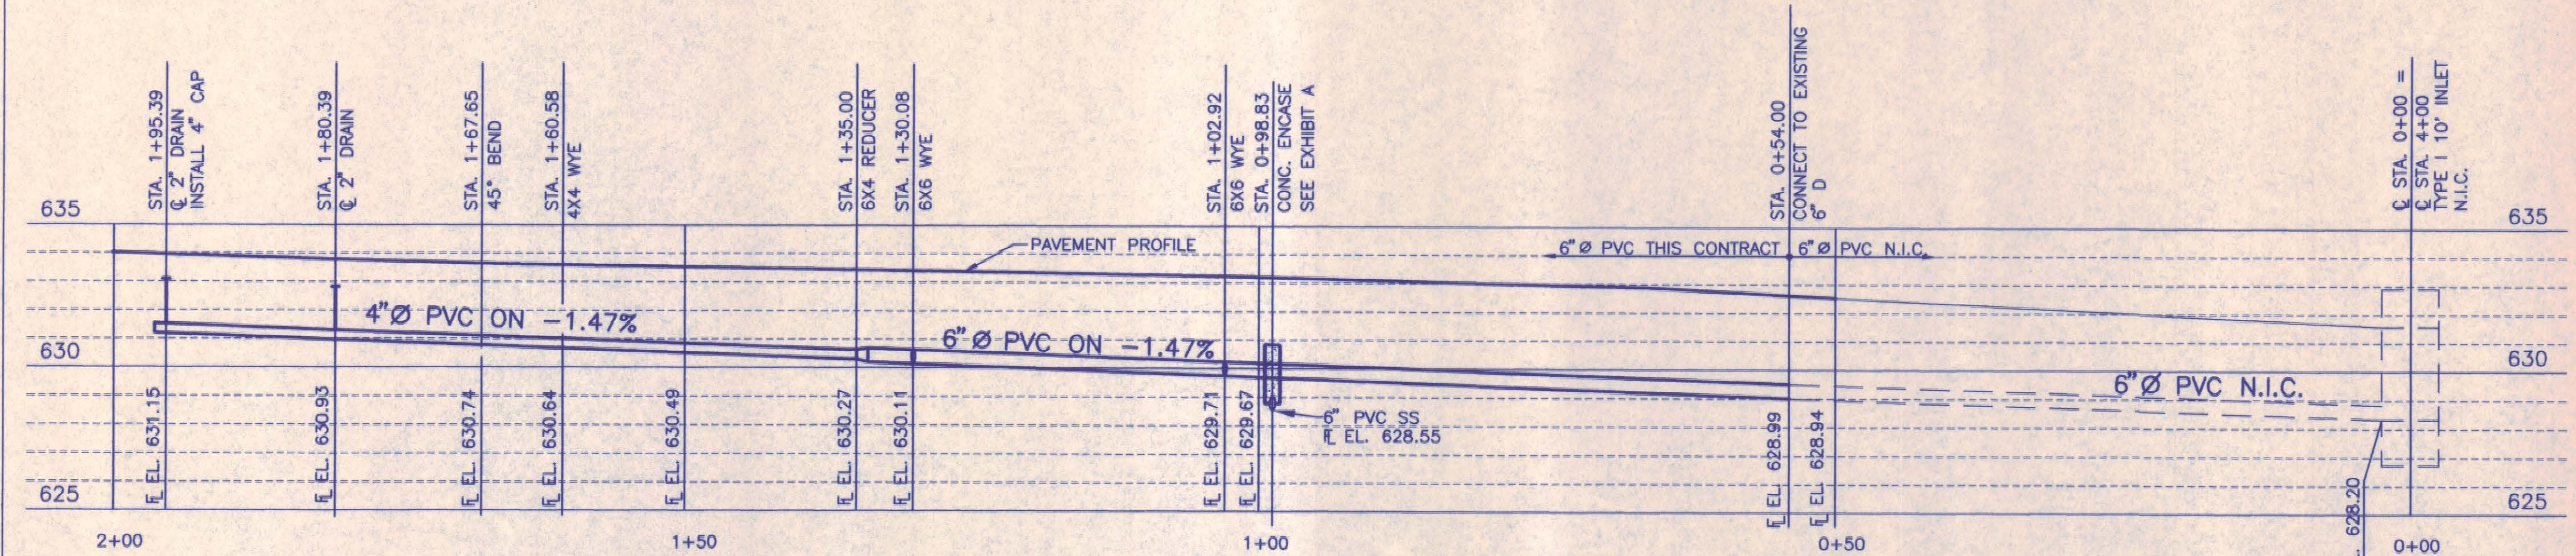


DRAIN LINE PROFILE

SCALE
HORZ: 1" = 10'
VERT: 1" = 4'

Chiang, Patel & Yerby, Inc.
Consulting Engineers • Planners • Project Managers
Dallas • Fort Worth • Houston • San Antonio

AT-C4.2

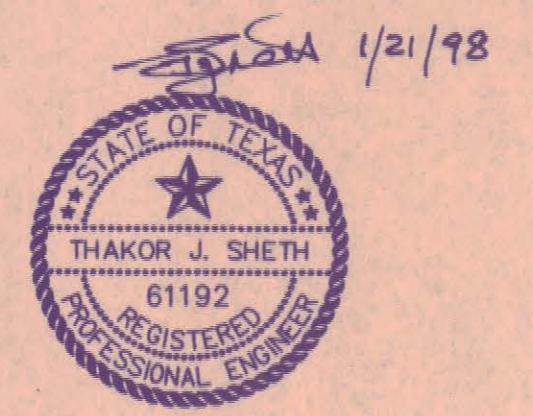


REVISION	NO.	REVISION	BY	DATE
1		REVISED DRAIN LINE PROFILE AND ADDED SANITARY SEWER LINE AND DELETED 4" SS WEST OF TOLL BOOTH	TJS	1/21/98


NORTH TEXAS TOLLWAY AUTHORITY
ADDISON AIRPORT TUNNEL

UTILITY PLAN AND PROFILE B


DRAWN: WAB		DATE: 8/28/97		DESIGNED: WAB		DATE: 12/20/96	
CHECKED: TJS		DATE: 11/5/97		SCALE: 1"=10'-0"			
CONTRACT NO. DNT-290				SHEET 10 OF 53			

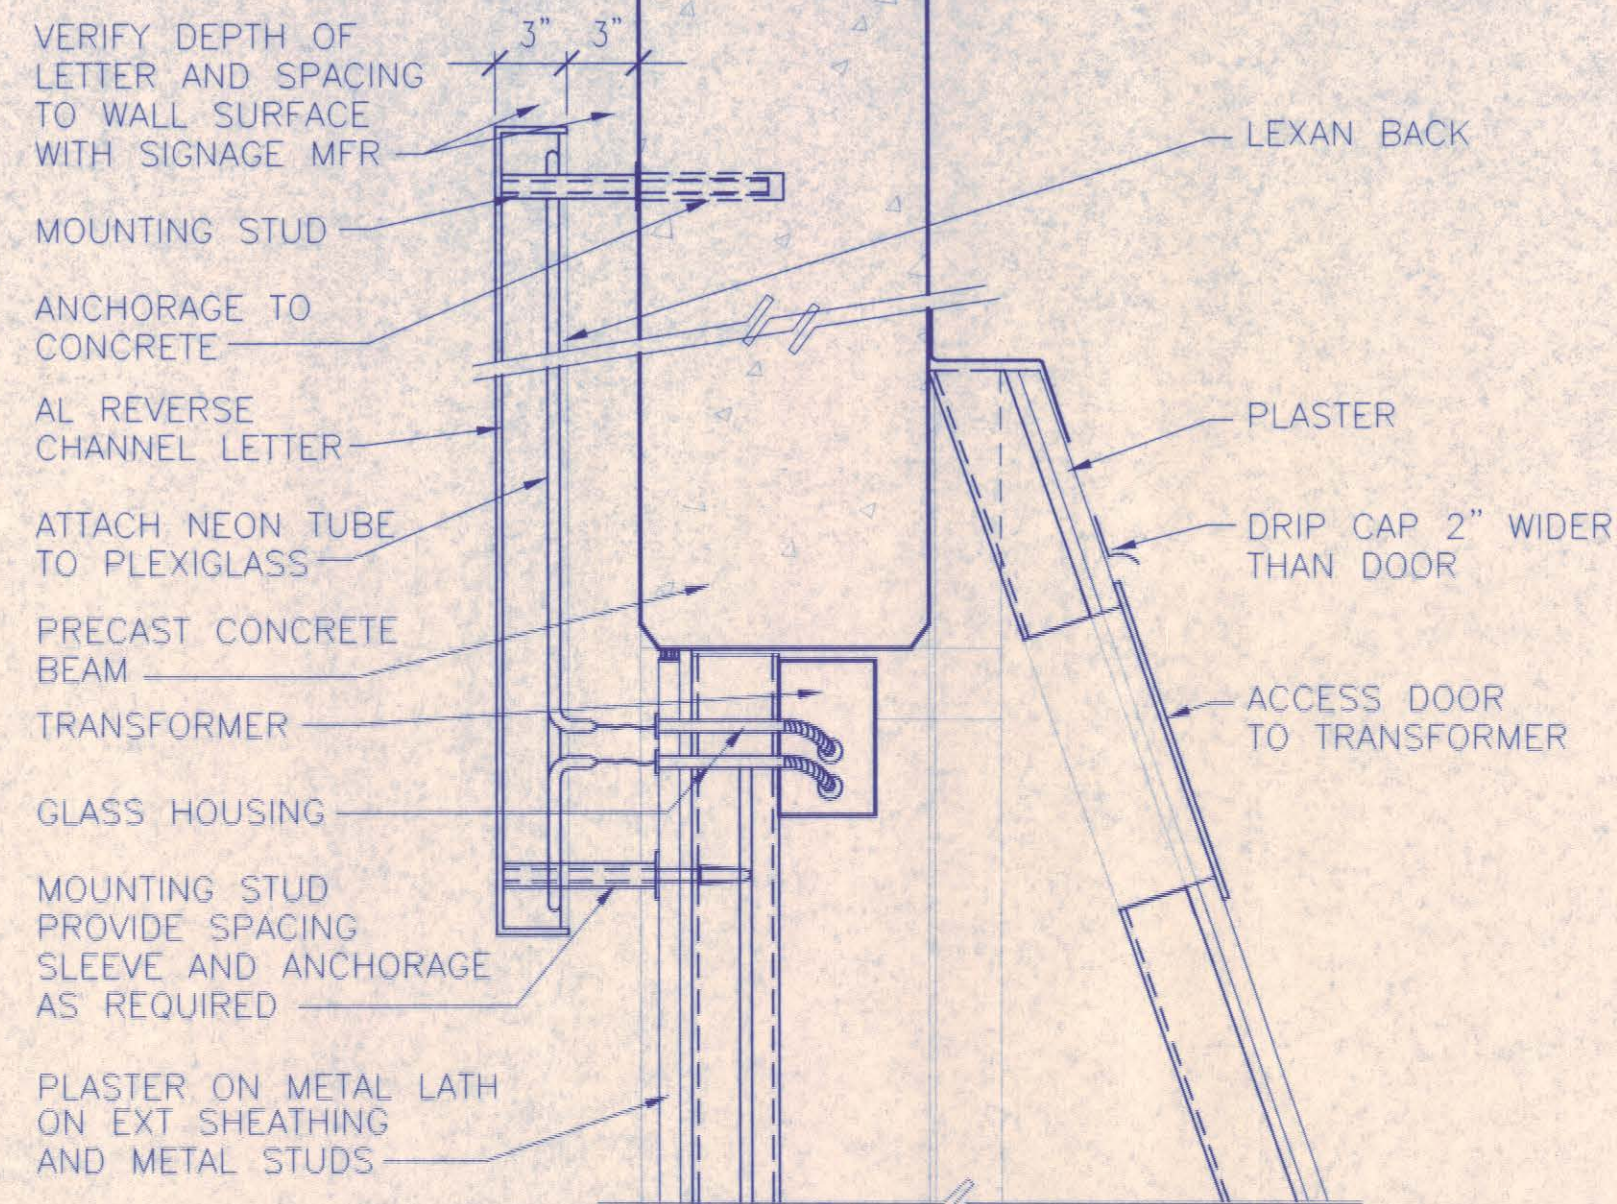


2 SIGNAGE TYPE 6 SECTION
1/4"=1'-0" TAATAD35

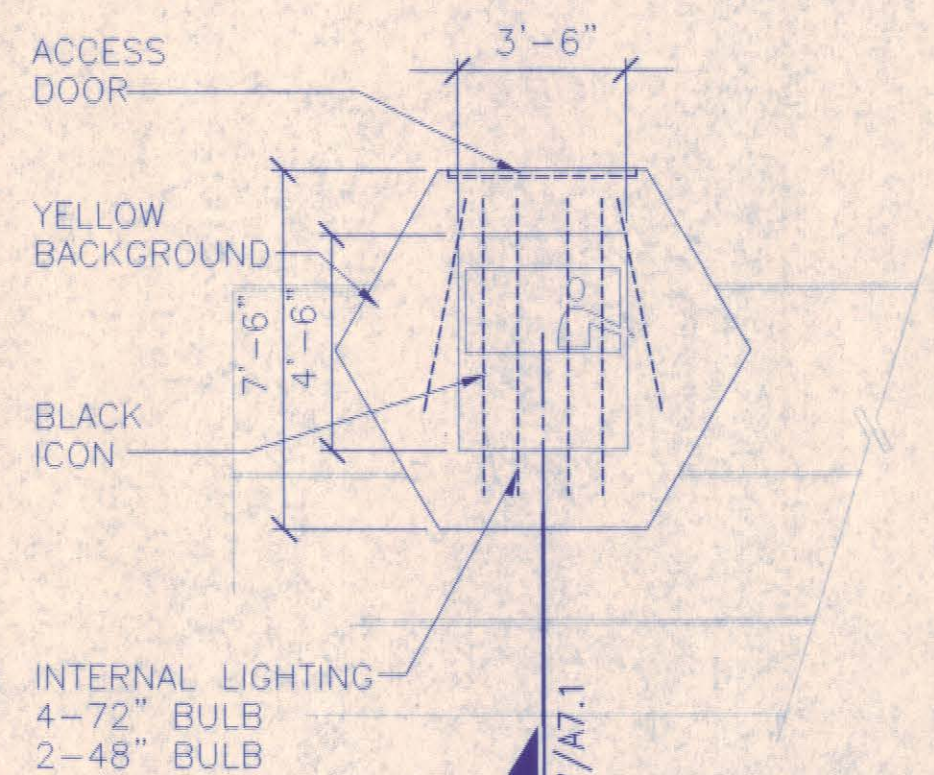


10 SIGNAGE TYPE 3 ELEVATION
1/4"=1'-0" TAATAD66

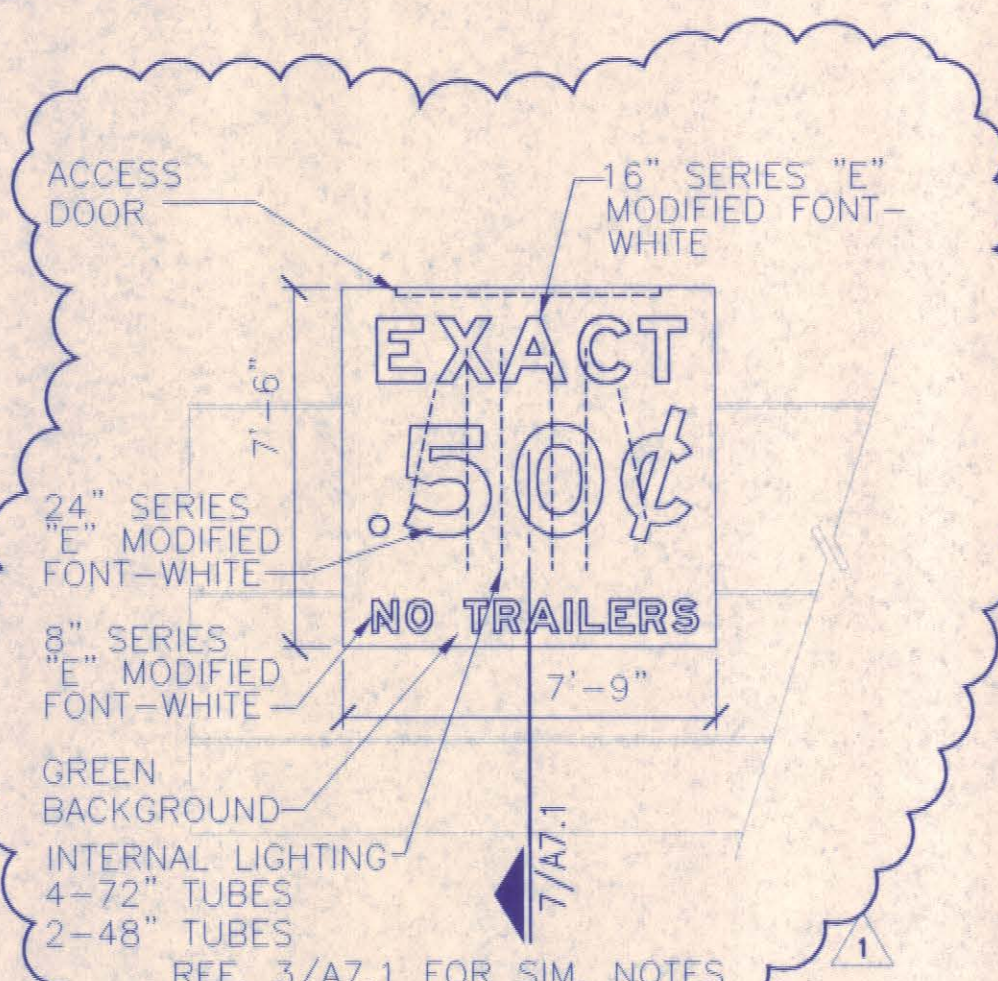


9 SIGNAGE TYPE 4 ELEVATION
1/4"=1'-0" TAATAD66

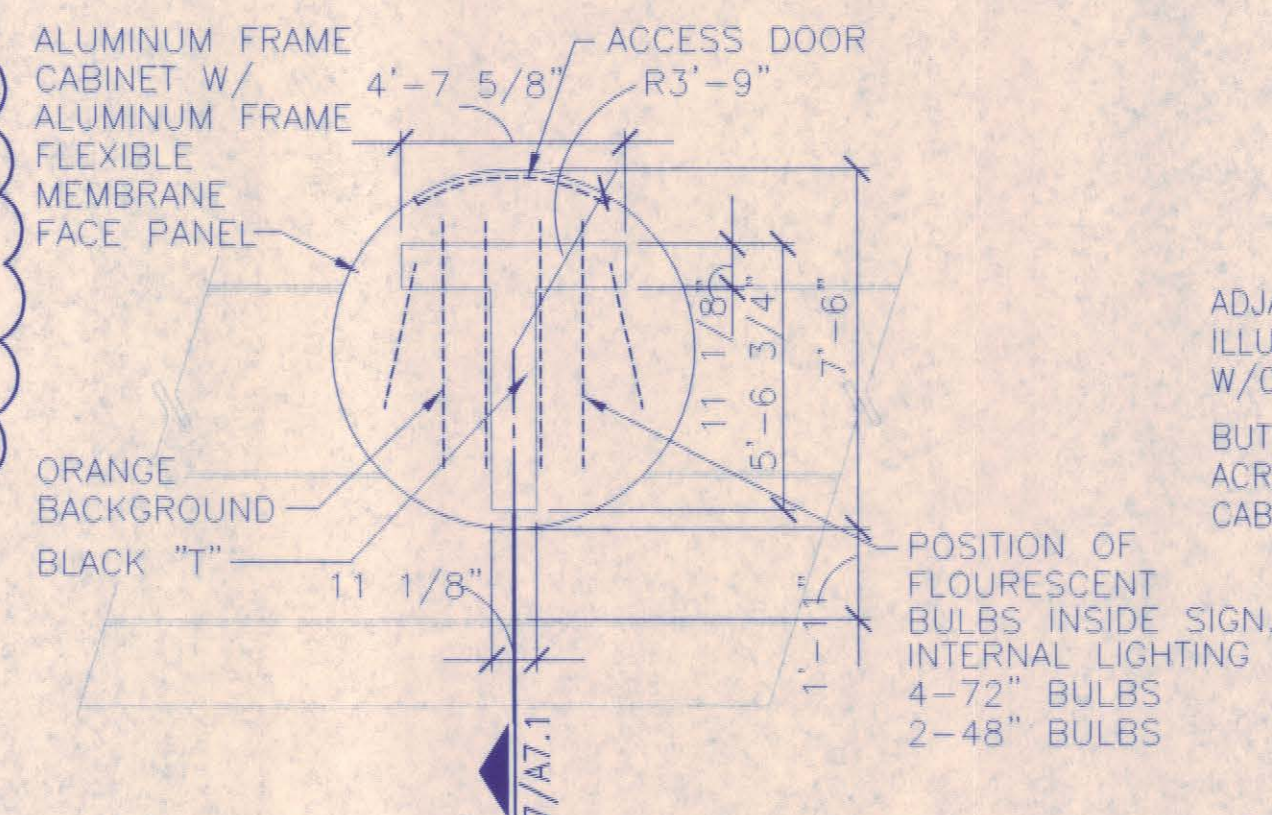


3 SIGNAGE TYPE 5 ELEVATION
1/4"=1'-0" TAATAD66

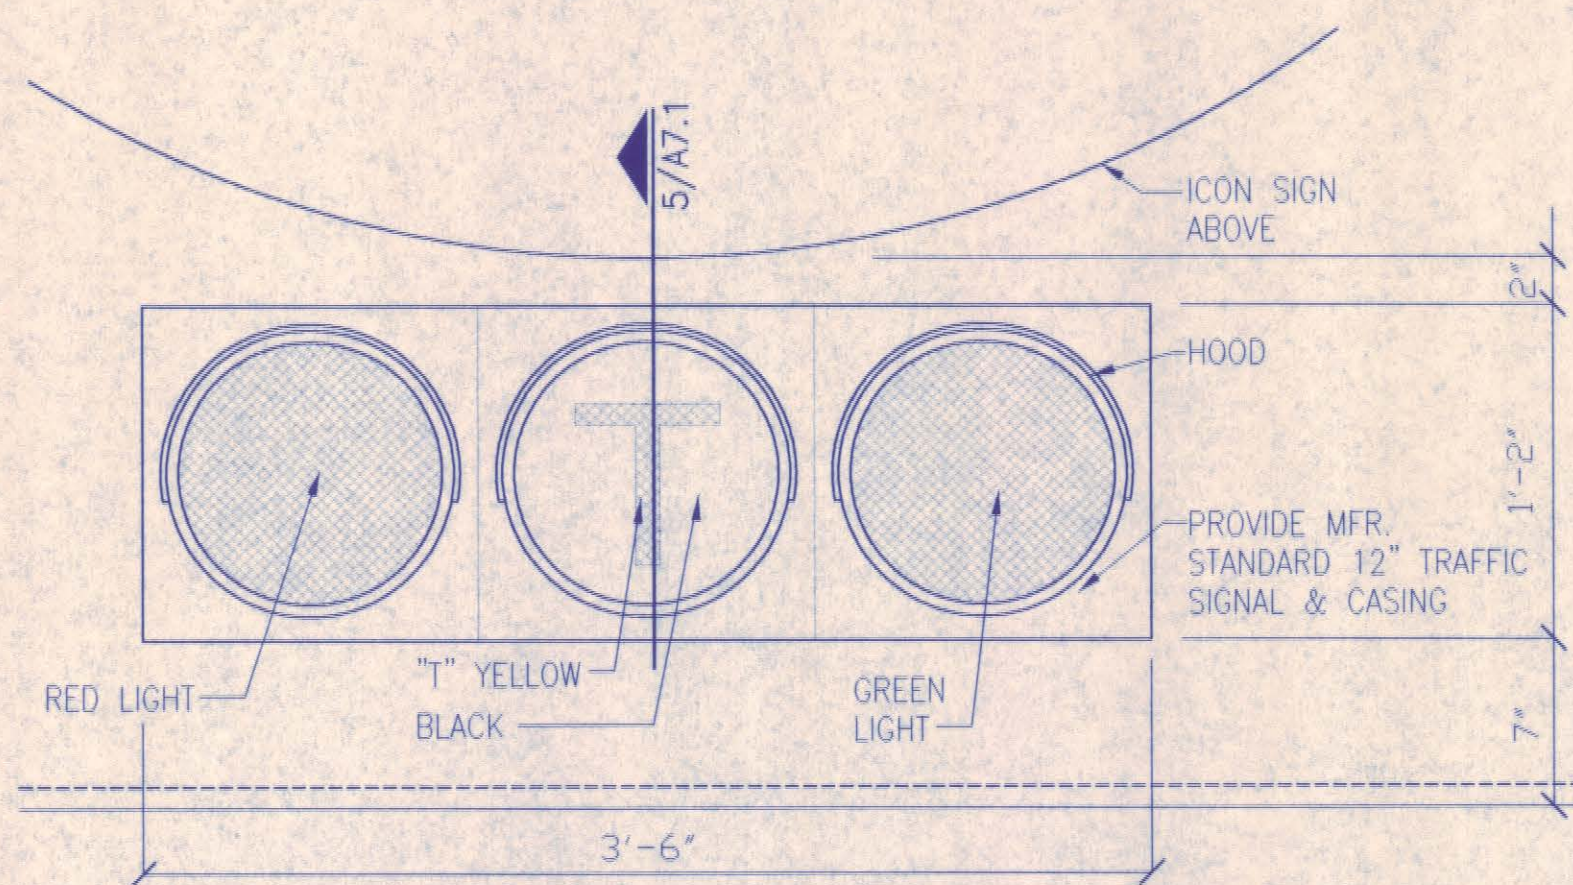


8 SIGNAGE TYPE 2
1 1/2"=1'-0" TAATAD64

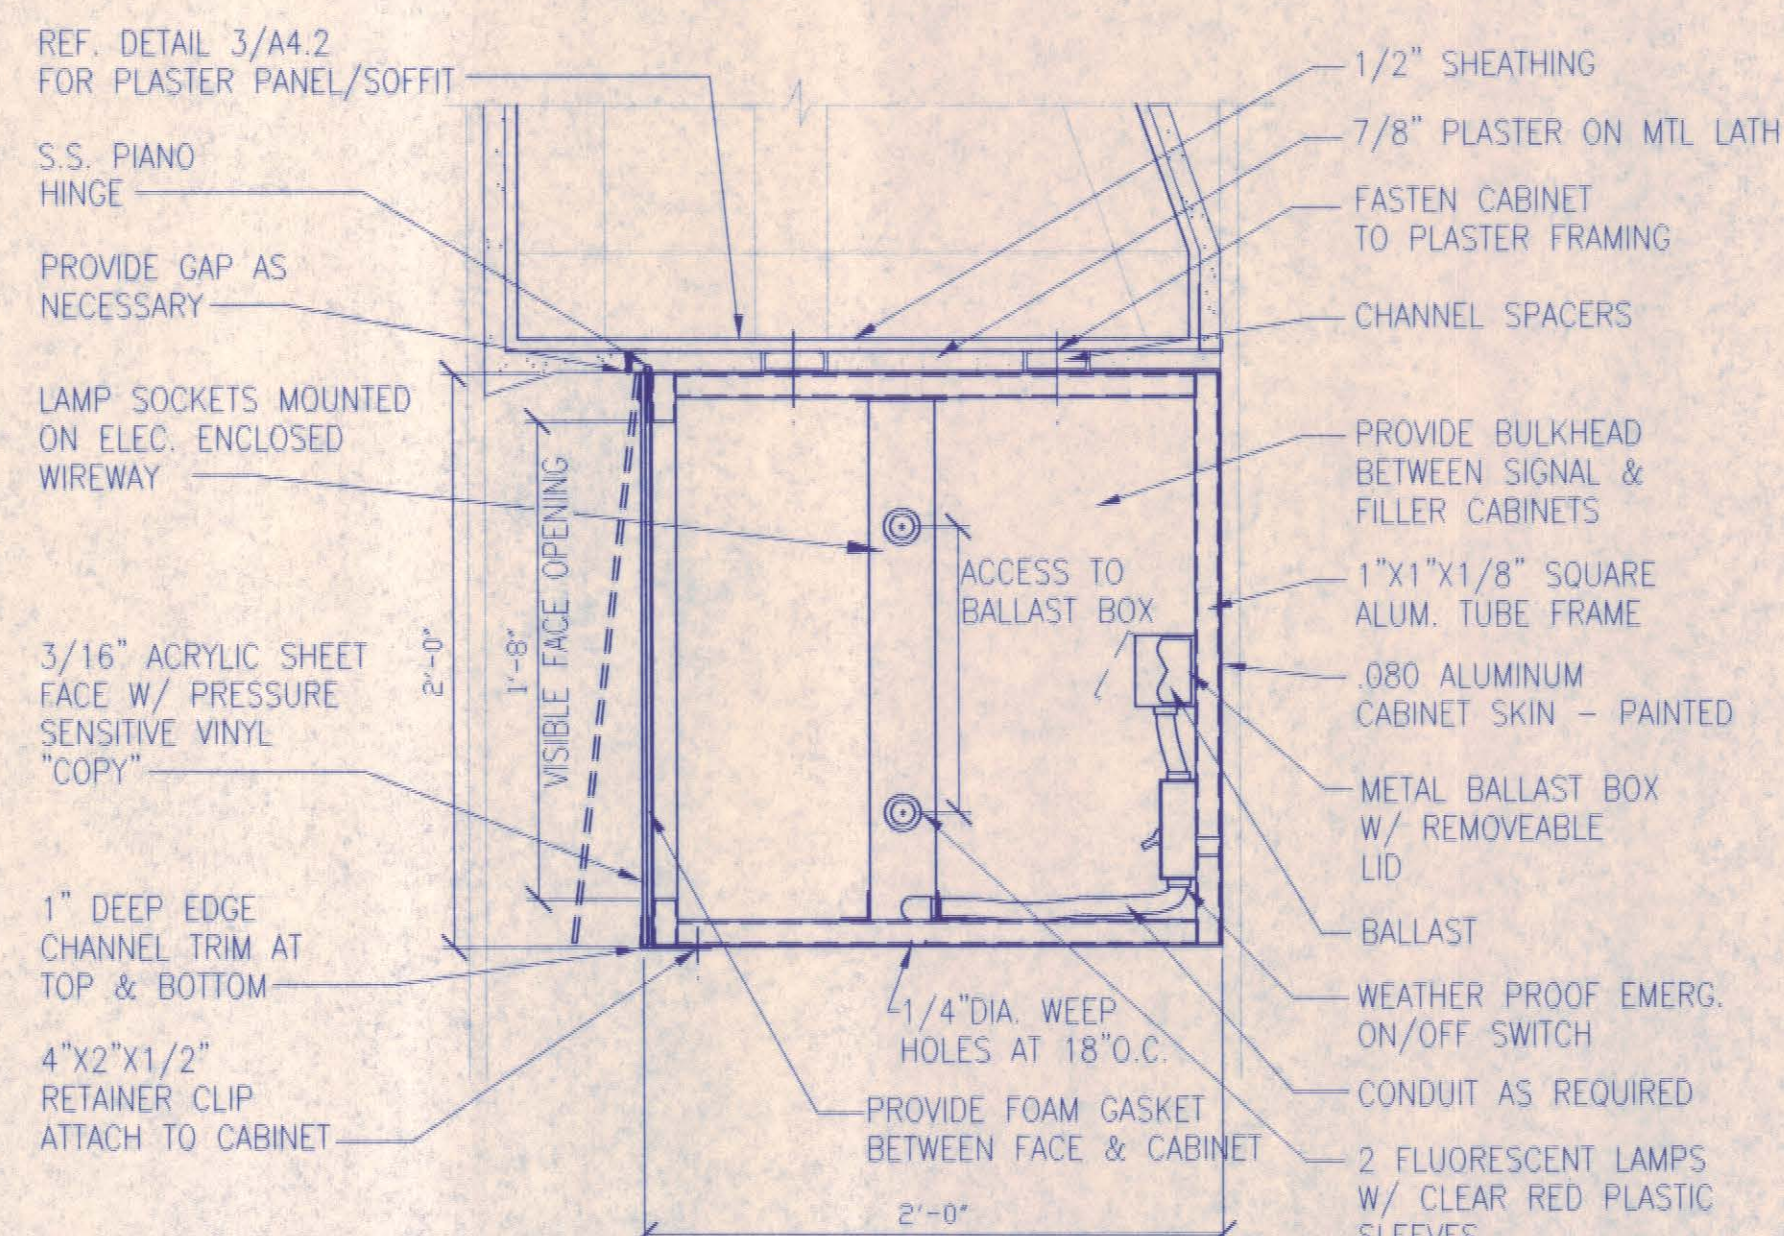


6 SECTION AT SIGN TYPE 1
1 1/2"=1'-0" TAATAD62

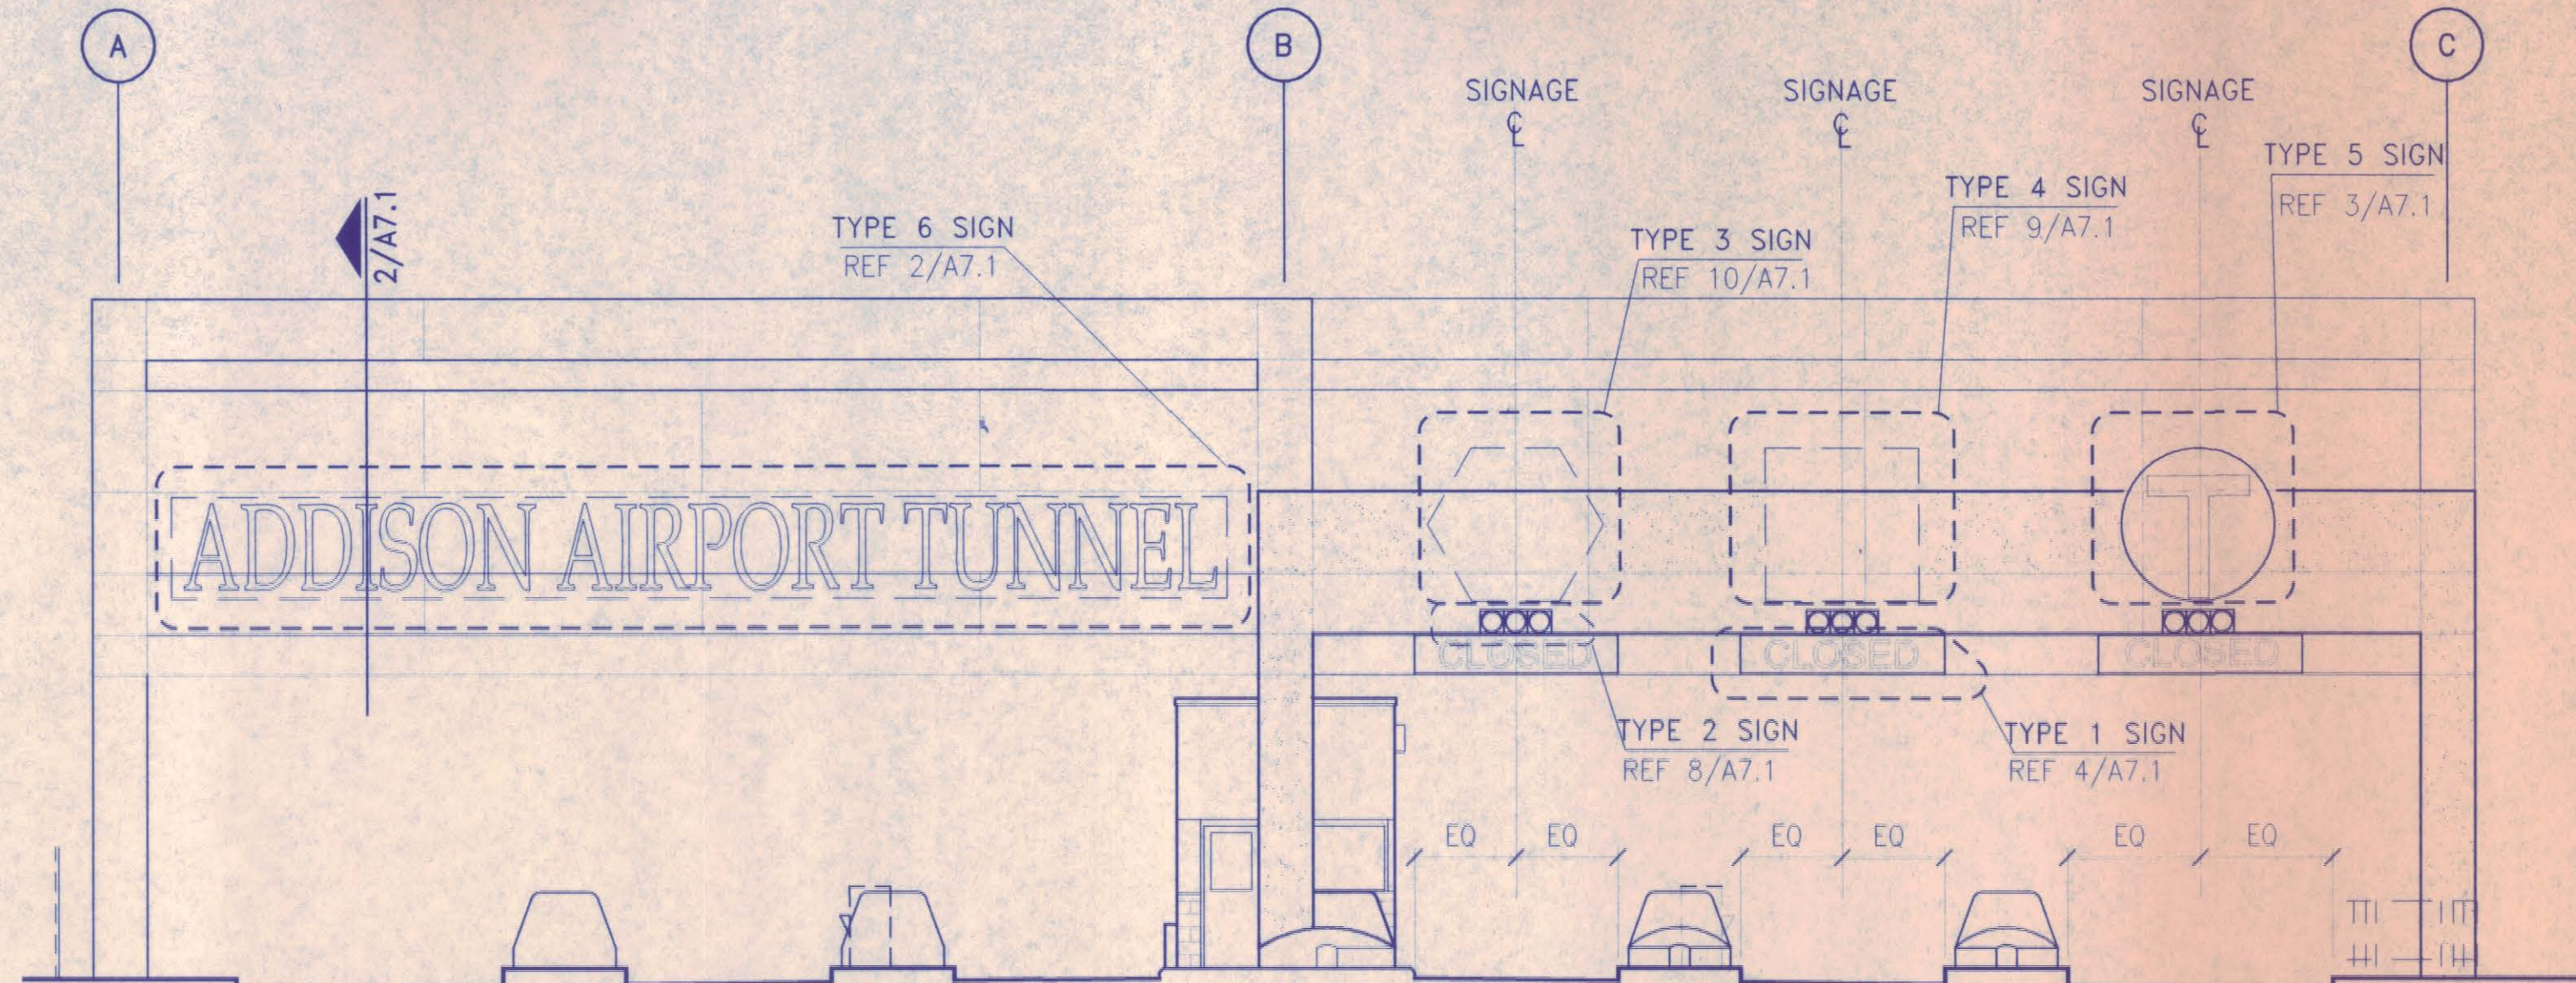


1 LOCATION OF SIGNAGE
1/8"=1'-0" TAATAD61

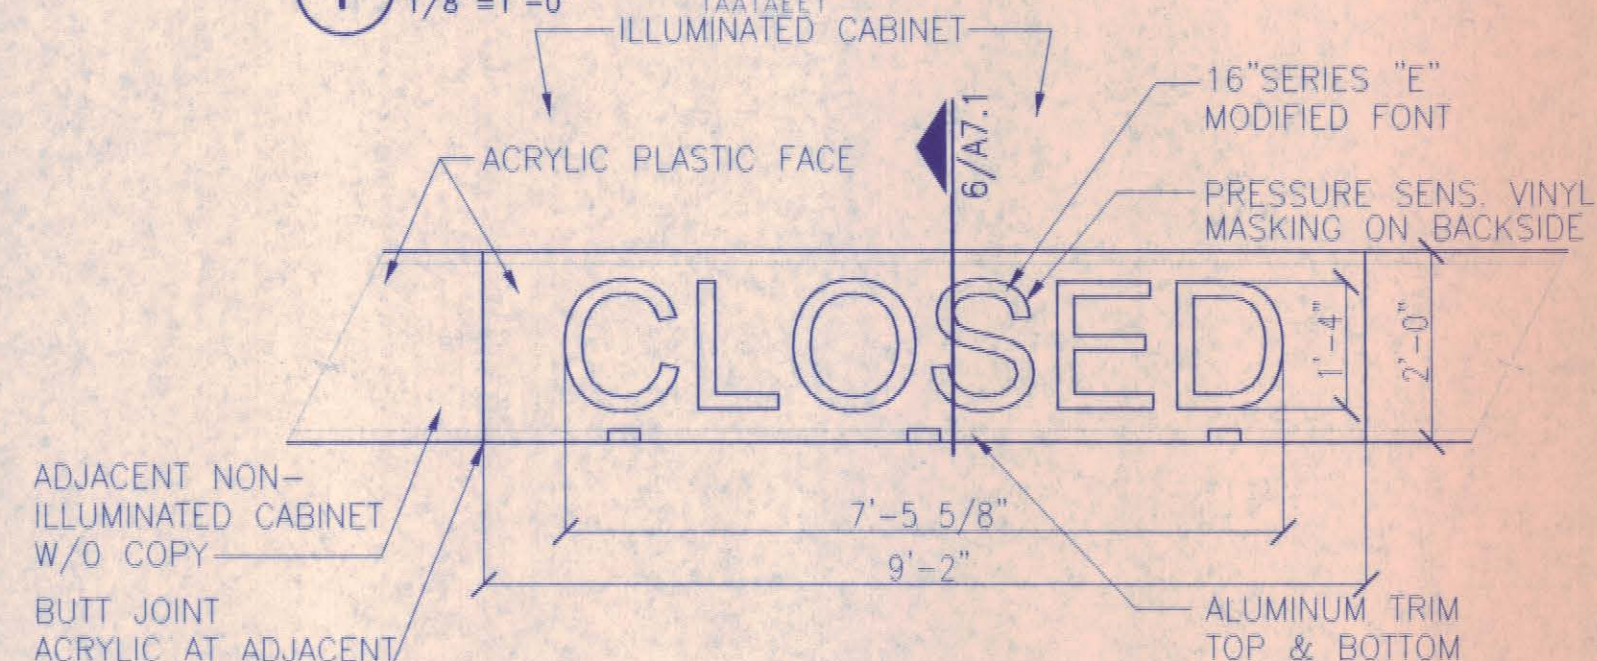

4 SIGNAGE TYPE 1
1/2"=1'-0" TAATAD65

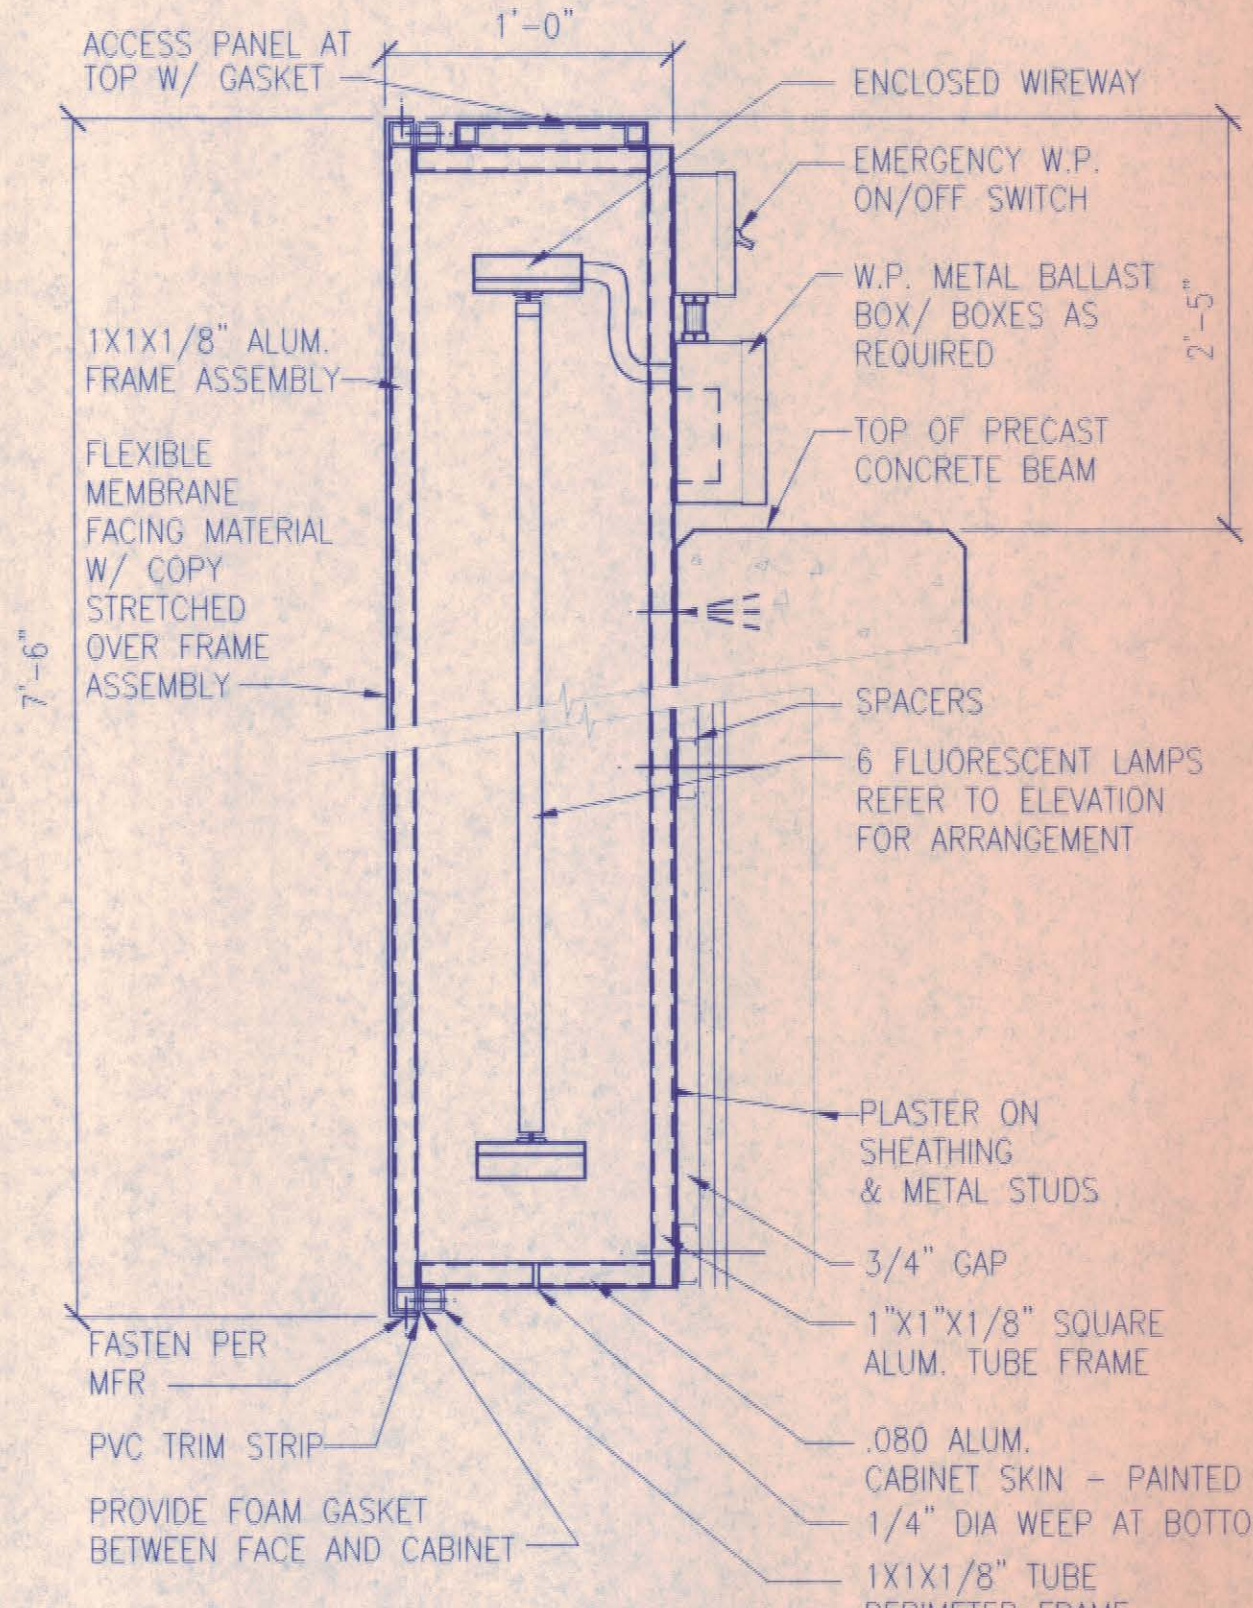


7 SIGNAGE TYPE 3/4&5 SECTION
1 1/2"=1'-0" TAATAD63

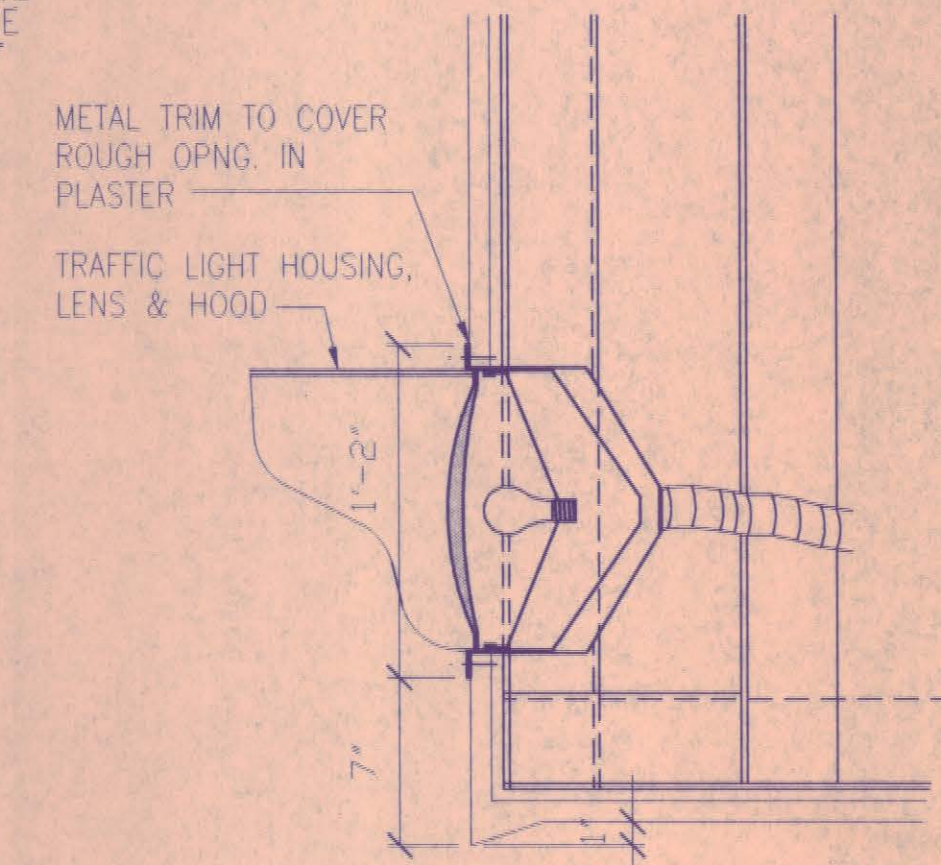

5 SECTION AT SIGN TYPE 2
1 1/2"=1'-0" TAATAD67



1	SIGNAGE TYPE 4 REVISION TO .50¢		1/8/98
NO.	REVISION	BY	DATE
NORTH TEXAS TOLLWAY AUTHORITY ADDISON AIRPORT TUNNEL BARRIER TOLL PLAZA			
TUNNEL PLAZA SIGNAGE DETAILS			
AGUIRRE Corporation 18700 PARK CENTRAL DRIVE 10 TH FLOOR DALLAS TEXAS 75281 TEL. (972) 788-1608		SECTION XIII	
CHECKED <i>[Signature]</i>	DATE 1/8/98	DESIGNED MM AS SHOWN	DATE 8/15/96
CHECKED <i>[Signature]</i>	DATE	SCALE	
CONTRACT NO. DNT-290		SHEET 29 OF 53	

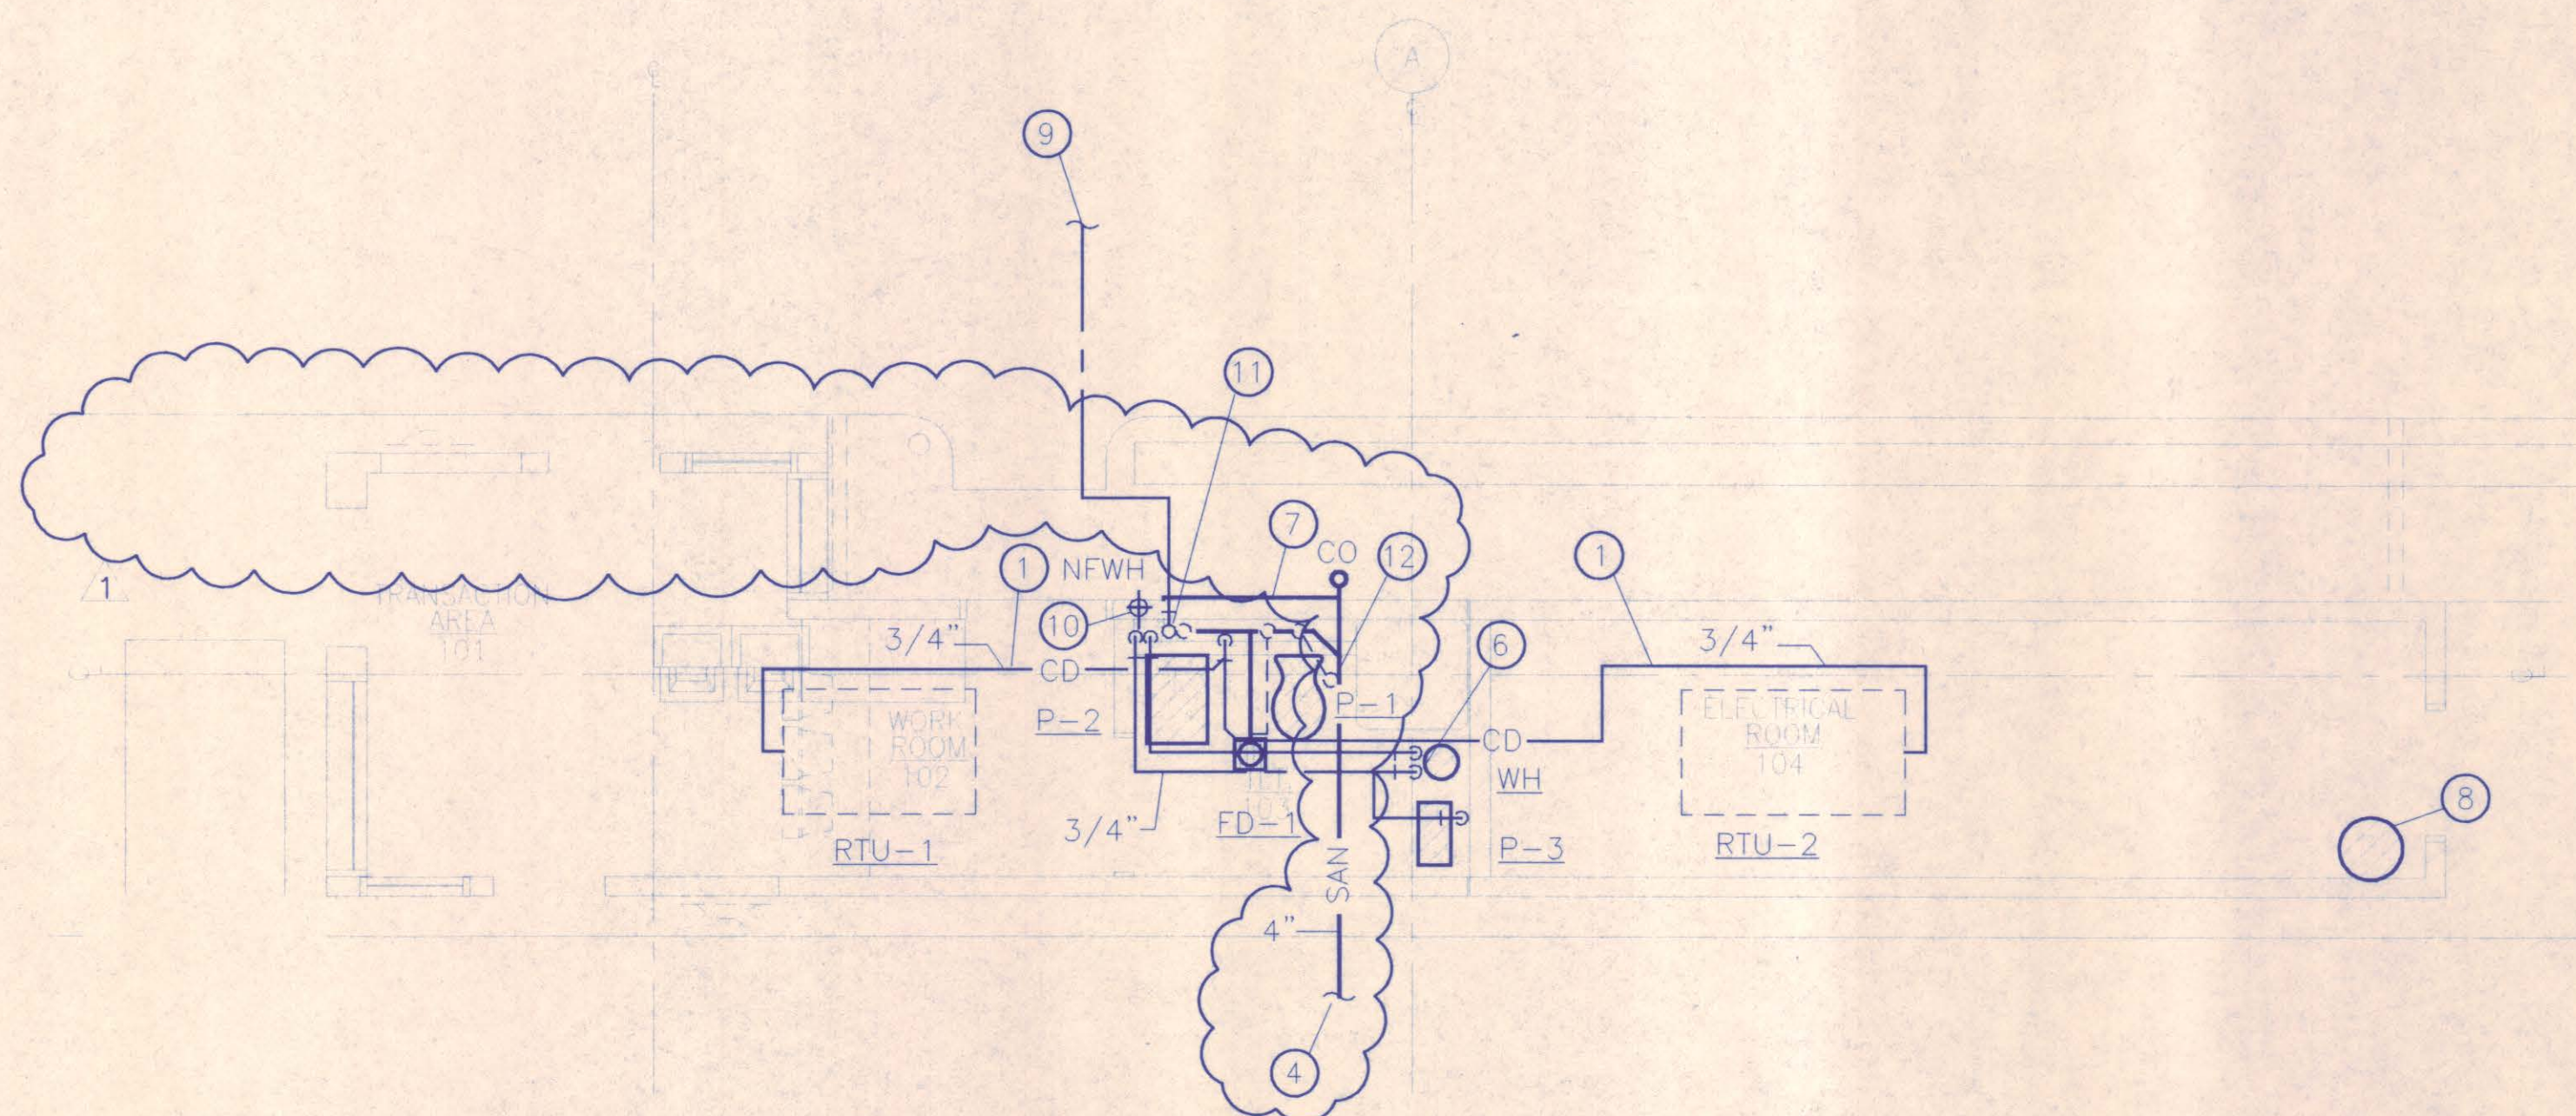

2 PLUMBING BOOTH PLAN
SCALE: 1/4" = 1'-0"


TAATPPB1



PLUMBING FIXTURE CONNECTION SCHEDULE

TAG	DESCRIPTION	CONNECTION				REMARKS
		CW	HW	SAN	VENT	
P-1	WATER CLOSET	1"	-	4"	2"	HANDICAP ACCESSIBLE
P-2	LAVATORY	1/2"	1/2"	2"	1 1/2"	HANDICAP ACCESSIBLE
FD-1	FLOOR DRAIN	-	-	3"	2"	PROVIDE WITH TRAP PRIMER
WH	WATER HEATER	1/2"	1/2"	-	-	WITH T&P DRAIN TO EXTERIOR
P-3	WATER CHILLER	1/2"	-	-	-	

WH A.O. SMITH STOCK NO. ELSF-10, OR STATE, OR RHEEM, OR APPROVED EQUAL.
1500 WATTS/120V, 150 PSI MAXIMUM.

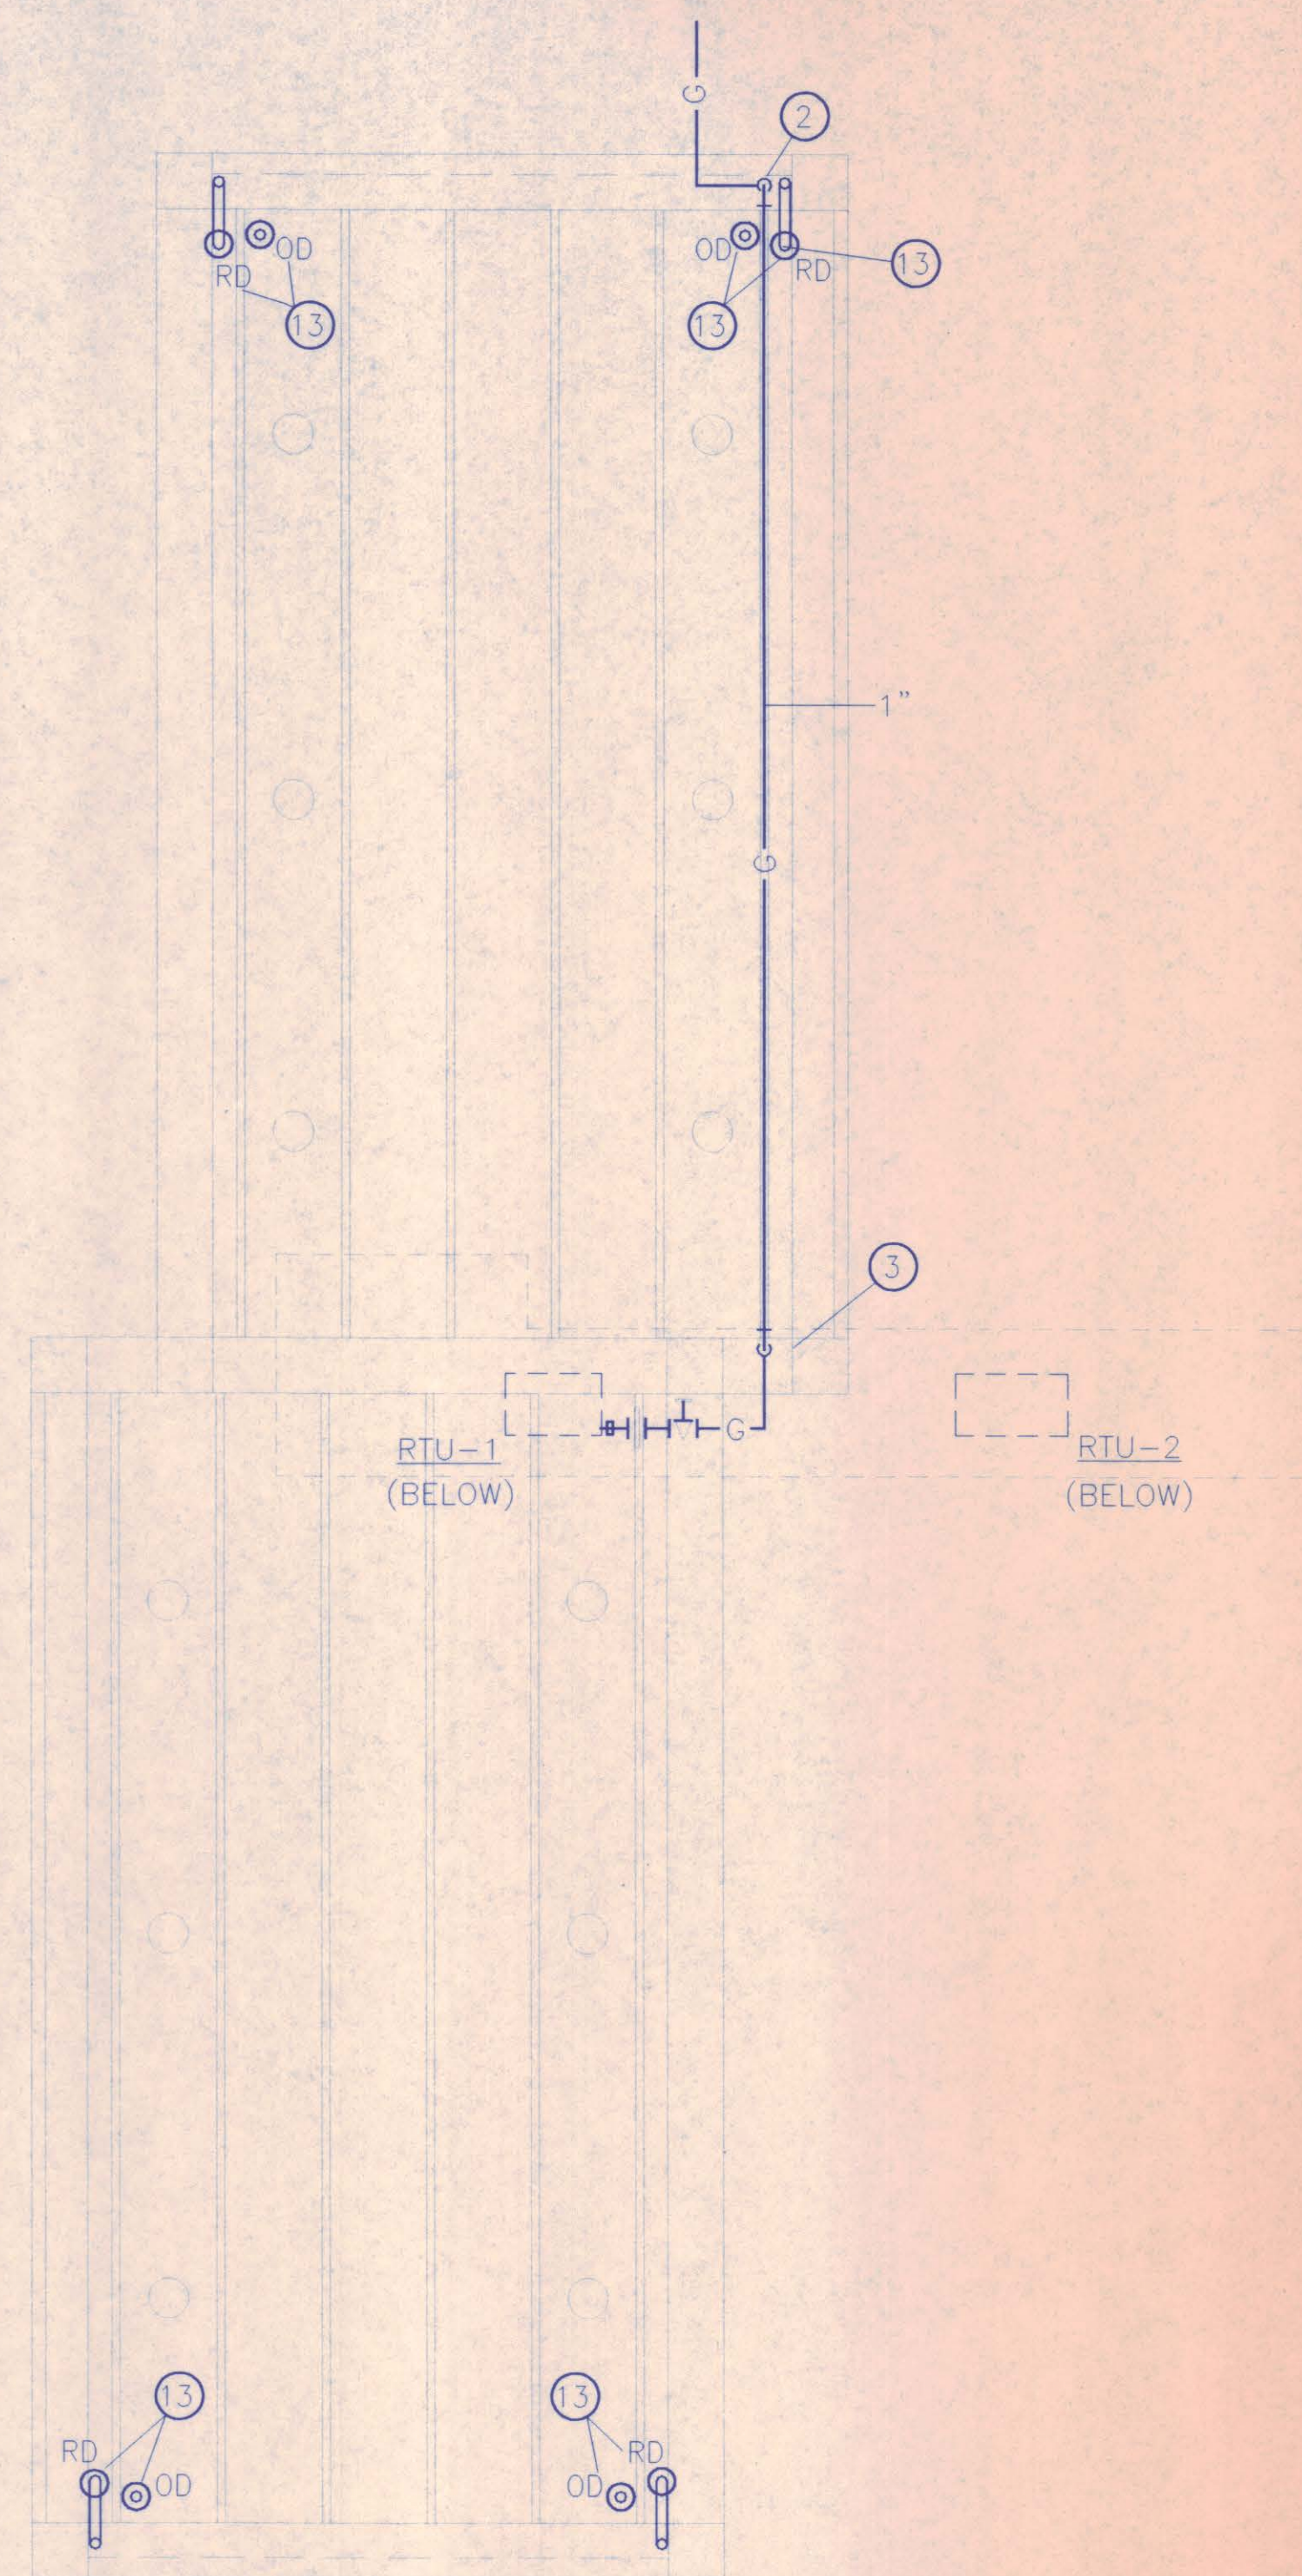

1 CANOPY PLUMBING PLAN
SCALE: 1/8" = 1'-0"

TAATMPC1



GENERAL NOTES

- ALL GAS PIPE IS TO BE EXPOSED UNDER CANOPY TO RTU'S. DO NOT ENCLOSE OR COVER IN RACEWAYS WITHOUT PROPER SLEEVE.
- PROVIDE ELECTRIC HEAT TRACE ON ALL HOT & COLD WATER PIPING EQUAL TO RAYCHEM 5XL-1, 40°F TEMPERATURE.

NOTES BY SYMBOL 'O'

- CONDENSATE LINE ON ROOF. TRAP ABOVE ROOF AND EXTEND 3/4" DOWN TO HUB DRAIN IN PLUMBING CHASE.
- ROUTE GAS LINE UP AT COLUMN TO UNDERSIDE OF PRECAST DOUBLE TEE ROOF STRUCTURE. PROVIDE 1 FOOT DEEP DIRT LEG WITH THREADED CAP AT BOTTOM.
- ROUTE 1" GAS LINE DOWN COLUMN TO ROOF OF BOOTH CONNECTION TO RTU-1.
- 4" SANITARY SEWER, I.E. = 98.0' AT BUILDING EXIT. REFER TO CIVIL FOR CONTINUATION. LOCATE ONE ADDITIONAL CLEAN-OUT AT GRADE IN ISLAND BETWEEN LANES, APPROX. 30'-0" SOUTH OF BOOTH. (NOT SHOWN)
- NOT USED.
- WATER HEATER ON SHELF ABOVE CEILING. FURNISH GALVANIZED PAN, 3" DEEP, 3" LARGER THAN HEATER O.D. WITH SWEATED 1/2" DRAIN LINE. ROUTE DRAIN LINE TO HUB DRAIN IN CHASE. FURNISH SHUT-OFF VALVE ON CW SUPPLY AND UNIONS AT HW/CW CONNECTIONS. ROUTE FULL SIZED DISCHARGE FROM T&P RELIEF DOWN IN CHASE AND OUT THROUGH EXTERIOR WALL NEAR NFWH AT 6" A.F.F. TERMINATE W/ 90° ELL DOWN.
- ACCESS PANELS. REF. ARCH.
- FIRE SUPPRESSION CANISTER FOR FM-200 SYSTEM. REF. DIV. 15 SPECIFICATIONS.
- 1 1/2" POTABLE WATER SUPPLY. REFER TO CIVIL FOR CONTINUATION.
- 3/4" CW DOWN TO RECESSED NFWH.
- ROUTE 1 1/2" POTABLE WATER SUPPLY UP INTO CHASE IN SLEEVE. PROVIDE SHUT-OFF VALVE IN VERTICAL, ACCESSIBLE FROM ACCESS PANEL. PROVIDE DOUBLE-CHECK BACKFLOW PREVENTER IN HORIZONTAL.
- 2" VENT THROUGH ROOF.
- 4" ROOF DRAIN WITH CAST IRON LEADER, AND OVERFLOW ROOF DRAIN. REFER TO ARCHITECTURAL FOR ROUTING ALONG COLUMN.

1	DELETE 4" SS WEST FROM TOLL BOOTH	SPL	1/6/98
NO.	REVISION	BY	DATE

NORTH TEXAS TOLLWAY AUTHORITY
**ADDISON AIRPORT TUNNEL
BARRIER TOLL PLAZA**

**PLUMBING PLANS
AND SCHEDULES**

AGUIRRE Corporation
8700 PARK CENTRAL DRIVE
16 TH FLOOR
DALLAS TEXAS 75281
TEL. 972 788-9000

SECTION XIV

CHECKED [Signature] DATE 12-18-97 DESIGNED JCN DATE 12/20/96

CHECKED [Signature] DATE 12/18/97 SCALE AS NOTED

CONTRACT NO. DNT-290 SHEET 43 OF 53

AT-P1.1